





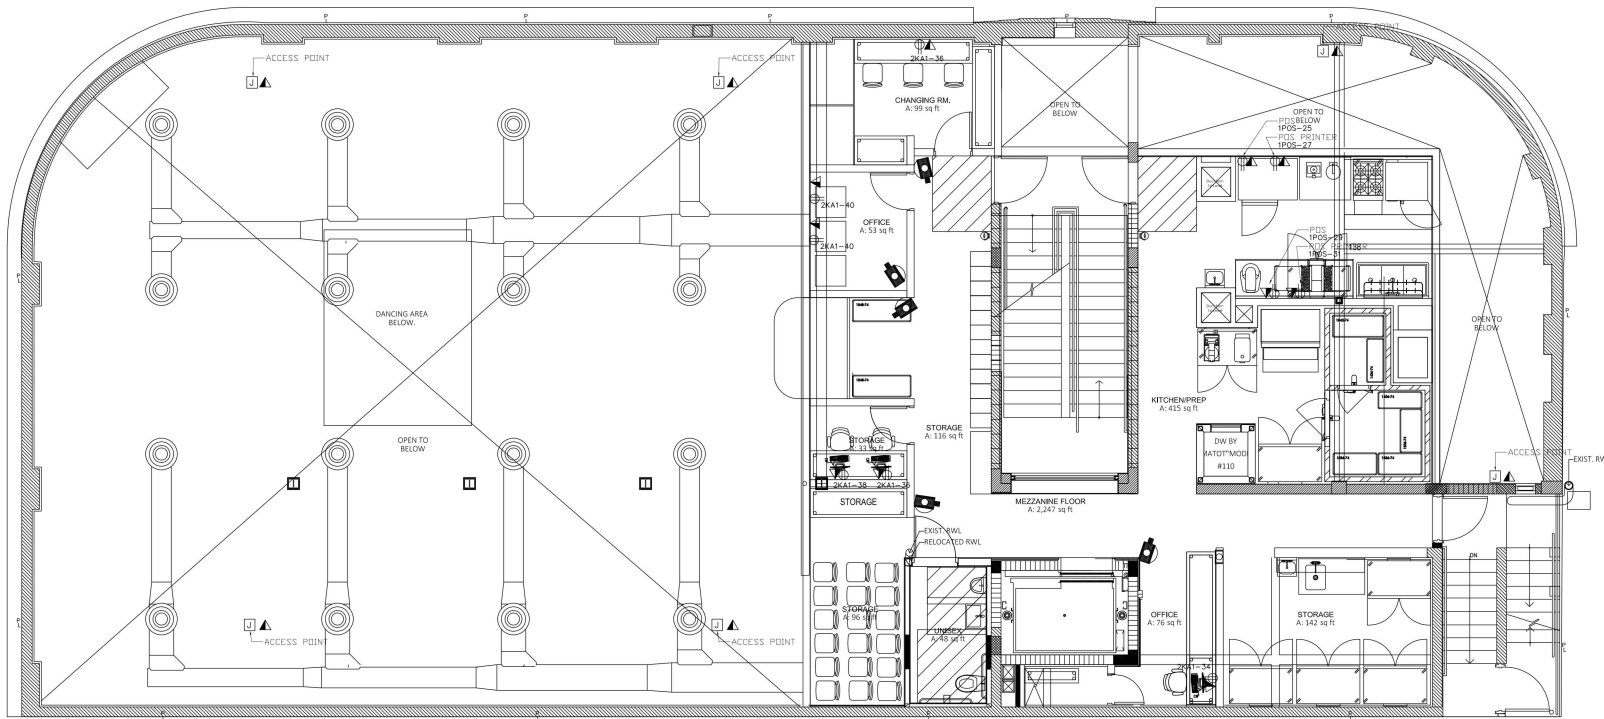

E VIDEO & SOUND AND POS / PRINTERS (WALL AND CEILING MOUNTED) MEZZANINE FLOOR PLAN

SCALE: 1/4" = 1'-0"

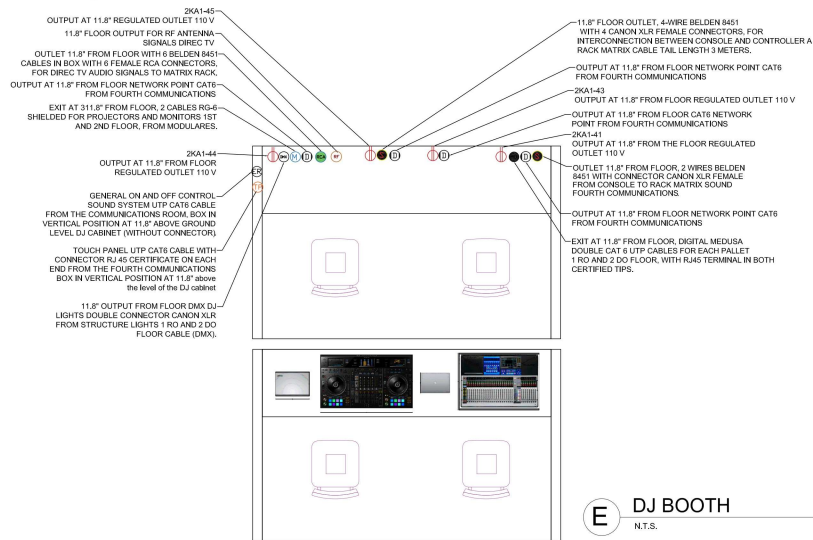

E DJ BOOTH
N.T.S.

VIDEO SYSTEM SYMBOLS

	TENSIONED CURTAIN ELITE SCREEN TE 135 HW2
	PROJECTOR LASER OPTOMA ZH 406ST
	TV LG 56"
	JBOX FOR RISE VIDEO SYSTEM
	RECEPTACLE 10N

SECURITY SYSTEM SYMBOLS

SYMBOLS	
	CCTV
	DATA
	ELECTRICAL RECEPTACLE (normal 110V)
	ELECTRICAL RECEPTACLE DEDICATE
	CHAUVET Rogue r16b
	CHAUVET Intimidator spot 360

SPEAKER SYSTEM SYMBOLS

TYPE OF SPEAKER	MODEL	COVERAGE
	OSC KLA-12	90°
	OSC K2-10C	180°
	OSC K2-112	360°
	OSC E-112	65°
	OSC CP-8	90°
	OSC AD-P SUB	360°
	OSC AD-P SAT	360°
CABLE & DATA OUTLET (4"x4"x2 1/2" OUTLET BOX) FOR HEIGHT MOUNTED REFER TO SOUND TECH DRAWINGS.		



OWNER:
LINCOLN DREXEL, LTD
AND LINCOLN DREXEL, II
3527 ALTON ROAD #403
MIAMI BEACH, FL 33140

ARCHITECT:
FORM GROUP, INC
4300 SW 73 AVE. #105
MIAMI, FL 33155
PH: 305-443-4244

INTERIOR DESIGNER:

KITCHEN CONSULTANT:
LACE FOOD SERVICE
10400 NW 20TH STREET,
MIAMI, FL 33172
PH: 305-513-6223

MEP ENGINEER:
LAUREDO ENGINEERING
COMPANY
1605 DREXEL AVENUE
SUITE 200
MIAMI BEACH, FL 33139
E-MAIL: info@laredo.com

STRUCTURAL ENGINEER:

INTERIOR TENANT BUILT-OUT FOR:

ANDRÉS
CARNE DE RES


LINCOLN DREXEL BUILDING
1605 DREXEL AVENUE
MIAMI BEACH, FL 33139

REVISIONS:
1 09/30/21 B.D.C



FORM GROUP, INC.
4300 SW 73 AVE. #105, MIAMI, FL 33155
TEL: 305-443-4244 FAX: 305-443-4200
ARCHITECT OF RECORD FOR ANDRÉS CARNE DE RES

PROJECT NO.: 19-1007
DATE: 5-8-20
SCALE: AS SHOWN
TITLE: VIDEO & SOUND MEZZANINE FLOOR PLAN
DRAWING NO.: E-102.2

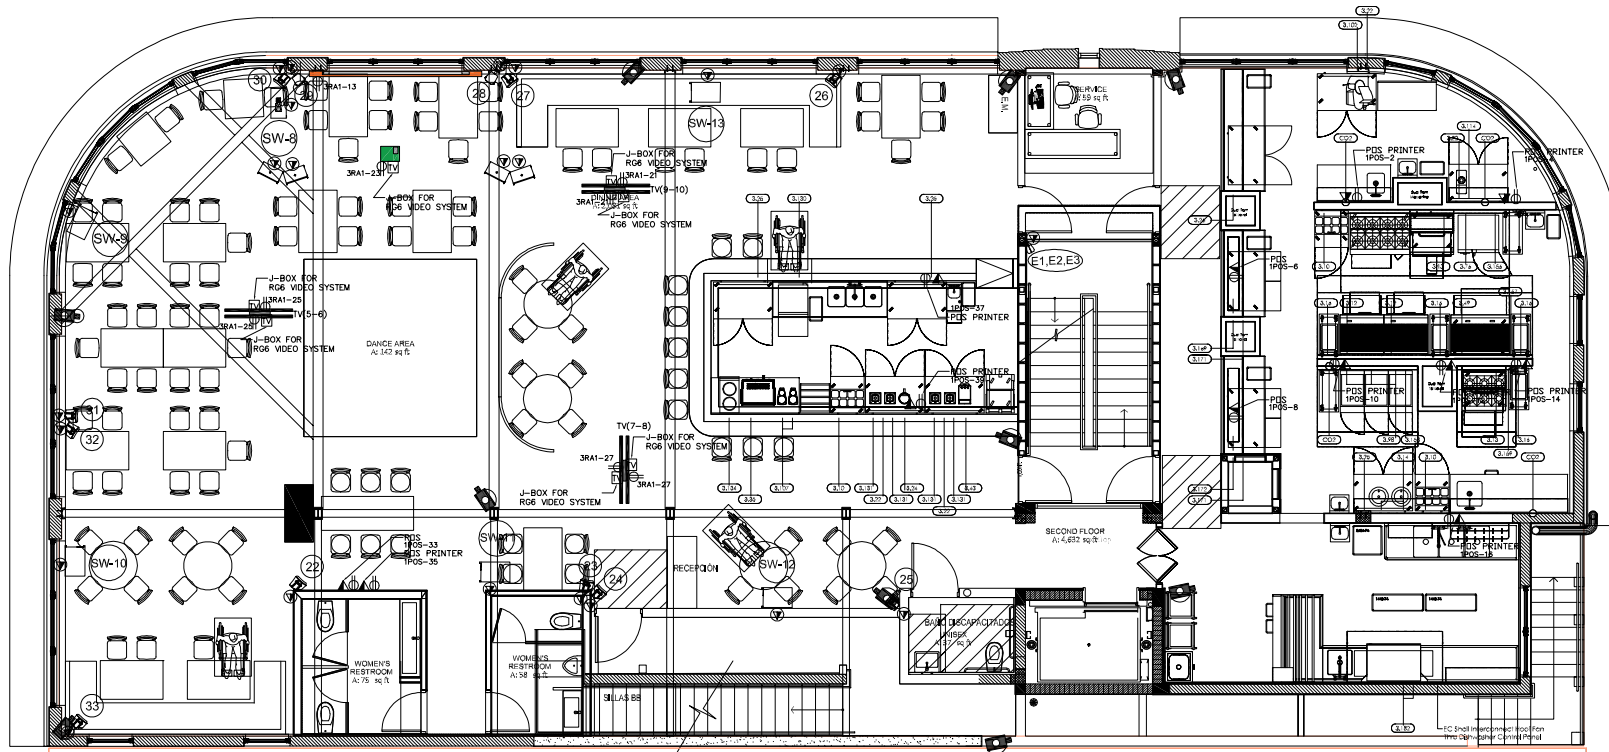

NOTES:
1. SEE SOUND SPEAKERS REQUIREMENTS NOTE AT SOUND/SPEAKERS DRAWINGS.

E VIDEO & SOUND AND POS / PRINTERS (WALL AND CEILING MOUNTED) POWER SECOND FLOOR PLAN
SCALE: 1/4" = 1'-0"

VIDEO SYSTEM SYMBOLS

	TENBYONES CURTAIN ELITE SCREEN TE 135-1112
	PROJECTOR LASER OPTIMA 2H 4088T
	J-BOX FOR R66 VIDEO SYSTEM
	RECEPTACLE 110V

SECURITY SYSTEM SYMBOLS

SYMBOLS	
	CCTV
	DATA
	ELECTRICAL RECEPTACLE (normal 110V)
	ELECTRICAL RECEPTACLE DEDICATED
	CHAUVET ROPER R-2
	CHAUVET INTIMIDATOR spot 385

SPEAKER SYSTEM SYMBOLS

TYPE OF SPEAKER	MODEL	COVERAGE
	QSC KL-A-12	90°
	QSC KS-212C	180°
	QSC KS-12	360°
	QSC E-112	90°
	QSC CP-8	90°
	QSC AD-P-36B	360°
	QSC AD-P-36AT	360°
	CABLE & DATA OUTLET (12" x 12" OUTLET BOX) FOR HEIGHT ADJUSTED REFER TO SOUND DRAWINGS.	



OWNER:
LINCOLN DREXEL, LTD.
AND LINCOLN DREXEL II,
3851 ALTON ROAD, #303
MIAMI BEACH, FL 33140

ARCHITECTS:
FORM GROUP INC.
4305 SW 73 AVE., #106
MIAMI, FL 33155
PH: 305-443-4244

INTERIOR DESIGNER:

INTERIOR CONSULTANT:
LACE FOOD SERVICE
1540 NW 20TH STREET,
MIAMI, FL 33172
PH: 305-613-6223

MEP ENGINEER:
LAUREDO ENGINEERING
COMPANY
2000 N.W. 10TH AVE., #100
MIAMI, FL 33136
PH: 305-581-1111

STRUCTURAL ENGINEER:

INTERIOR TENANT BUILT-OUT FOR:

**ANDRÉS
CARNE DE RES**

LINCOLN DREXEL BUILDING
1650 DREXEL AVENUE
MIAMI BEACH, FL 33139


DATE: 09/30/21 BY: B.D.C.



FORMGROUP
architecture . planning

FORM GROUP, INC.
4305 SW 73 AVE., SUITE 106, MIAMI, FL 33155
TEL: 305-443-4244 FAX: 305-443-4245
ARCHITECT OF RECORD

PROJECT NO.: 19-1007
DATE: 5-8-20
SCALE: AS SHOWN
TITLE: VIDEO & SOUND
SECOND FLOOR PLAN
DRAWING NO.: E-103.2

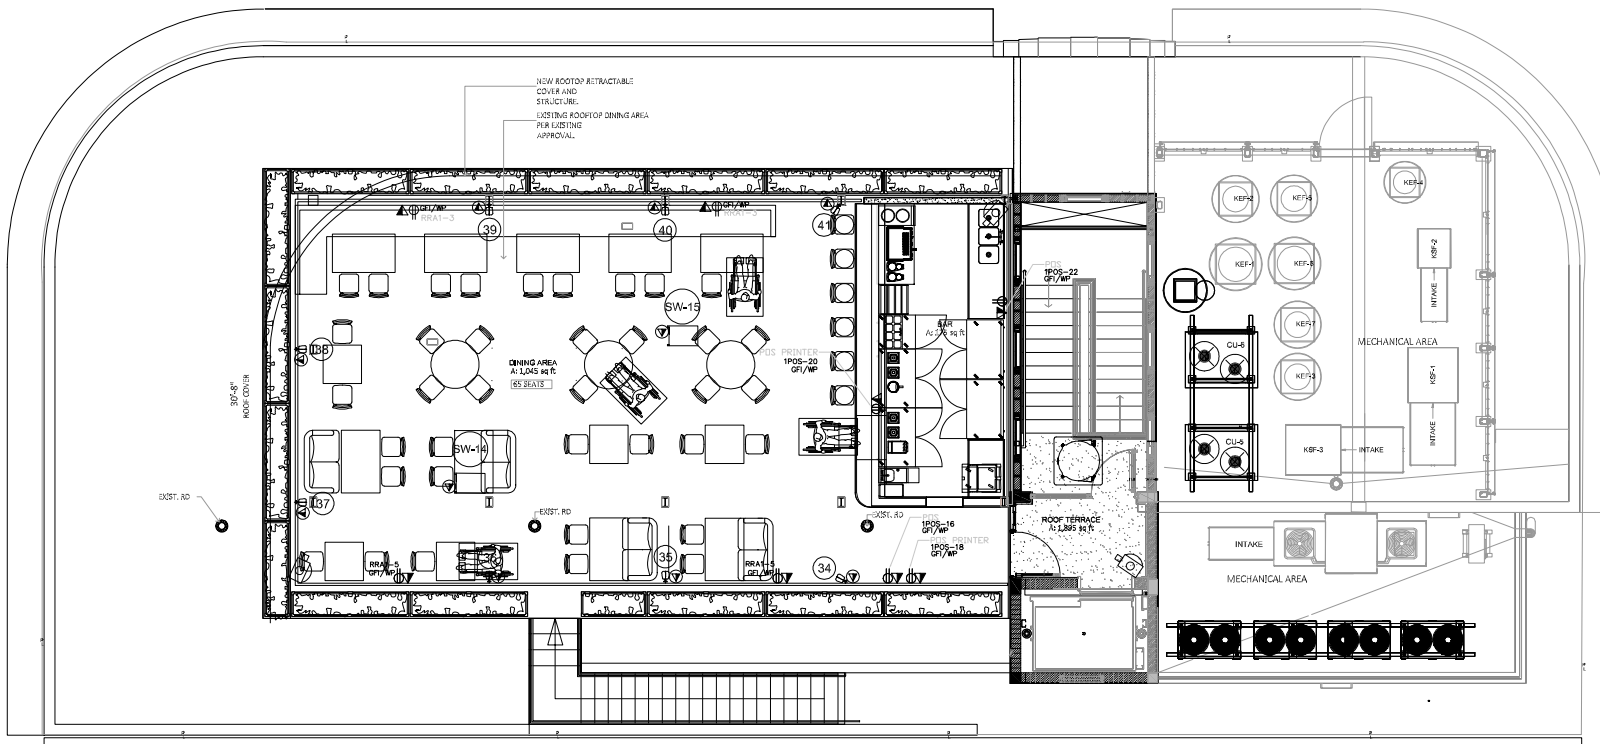

NOTES:
SEE SOUND SPEAKERS REQUIREMENTS NOTE A7 SOUND SPEAKERS DRAWINGS.

E VIDEO & SOUND AND POS / PRINTERS (WALL AND CEILING MOUNTED) ROOF PLAN
SCALE: 1/4" = 1'-0"

VIDEO SYSTEM SYMBOLS

	TENSIONED CURTAIN ELITE SCREENITE 136 HX12
	PROJECTOR/LASER OPTOMA 2H 408ST
	TV 10.9"
	J-BOX FOR HDB VIDEO SYSTEM
	RECEPTACLE 110V

SECURITY SYSTEM SYMBOLS

SYMBOLS	
	CCTV
	DATA
	ELECTRICAL RECEPTACLE (normal 110V)
	ELECTRICAL RECEPTACLE DEDICATE

	CHAMNET Pigeon 811-6
	CHAMNET Pigeon 811-6

SPEAKER SYSTEM SYMBOLS

TYPE OF SPEAKER	MODEL	COVERAGE
	OSC KLA-12	00°
	OSC KS-210C	180°
	OSC KS-12	360°
	OSC E-112	65°
	OSC CP-4	00°
	OSC AD-P-300	360°
	OSC AD-P-3AT	360°
	CABLE & DATA OUTLET (6"x4"x2 1/2" OUTLET BOX) FOR HEIGHT MOUNTED REFER TO SOUND TECHNIC DRAWINGS.	



OWNER:
LINCOLN DREXEL LTD.
AND LINCOLN DREXEL II
3851 ALTON ROAD #400
MIAMI BEACH, FL 33140

ARCHITECT:
FORM GROUP INC.
4300 SW 73 AVE. #108
MIAMI, FL 33155
PH: 305-413-4244

INTERIOR DESIGNER:

INTERIOR CONSULTANT:
LACE FOOD SERVICE
1640 NW 20TH STREET,
MIAMI, FL 33172
PH: 305-513-6223

MEP ENGINEER:
 LAUREDO ENGINEERING
COMPANY
1000 SW 10TH AVE.
MIAMI, FL 33135
PH: 305-351-1100
E-MAIL: LAUREDO@LAUREDOENGINEERING.COM

STRUCTURAL ENGINEER:

INTERIOR TENANT BUILT-OUT FOR:
ANDRÉS
CARNE DE RES

LINCOLN DREXEL BUILDING
1650 DREXEL AVENUE
MIAMI BEACH, FL 33139

DATE: 09/30/21 B.D.C.



FORMGROUP
architecture . planning

FORM GROUP, INC.
4300 SW 73 AVE. SUITE 108, MIAMI, FL 33155
TEL: 305-413-4244 FAX: 305-413-4245
ARCHITECT OF RECORD

PROJECT NO: 19-1007
DATE: 5-8-20
SCALE: AS SHOWN

E-104.2