


MIAMI BEACH, FL

T.S.

DESCRIPTION	ISSUE DATE
PROGRESS TO 100% CD	02-18-2014
FIRE REVIEW COMMENTS	04-09-2014
MASTER PERMIT COMMENTS	07-03-2014

PRIVATE PROVIDER SERVICES, LLC		
Construction Plans Review, Inspection, Testing & Consulting		
	REVIEWER INITIALS	DATE REVIEWED
BUILDING	EM	11-10-14
STRUCTURAL		
MECHANICAL		
ELECTRICAL		
PLUMBING		
SITE CIVIL		

0% CONSTRUCTION DOCUMENT SET

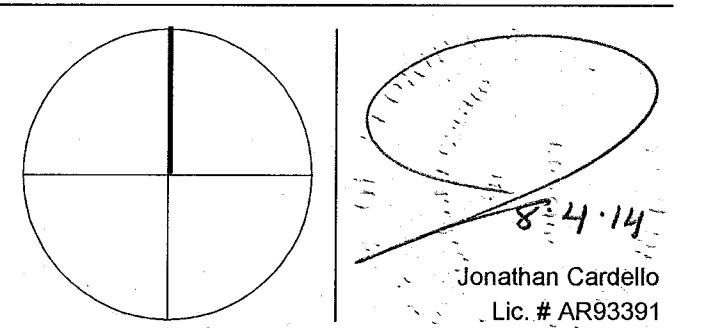

ADD Inc Architecture Interiors Planning

One Biscayne Tower
Suite 1670
Two South
Biscayne Boulevard
Miami, Fl 33131
T. 305.482.8700
F. 305.482.8770
www.addinc.com
Lic. # AA26001507

Boston Miami

JOB NUMBER: 13036.00

CHECKED BY: _____

ISSUE DATE: FEBRUARY 18, 2014

SCALE: $3/32" = 1'-0"$

SHEET TITLE _____

FIRST FLOOR
REFLECTED CEILING
PLAN

SHEET NUMBER: _____

A201

COPYRIGHT ADD INC 2011

GENERAL NOTES

- [illegible]


SHEET NOTES

- ① ALL EXISTING OUTRIGGERS BEHIND CHAIRS TO BE MAINTAINED AND REPAIRS WHERE POSSIBLE. MANUAL JOINTING FOR ADDITION OF NEW WALL GRILLS AND SCALES.
- ② ALL EXISTING LIGHT FIXTURES IN HATCHON HALL TO BE REMOVED AND REPLACED IN SAME LOCATION UNLESS OTHERWISE NOTED.
- FOR HATCHON ROOMS REFER TO SHEETS A401-518.
- ③ FOR OUTDOOR AREA LIGHTING REFER TO LANDSCAPE ARCHITECT'S DRAWINGS.
- ④ EXISTING HATCHON LIGHT FIXTURES IN HATCHON HALL BEING REPLACED FROM COMMON AREA TO BE KEPT AND REUSED.
- ⑤ EXISTING DOWNLIGHT SPRAWLER FIXTURES IN HATCHON HALL CEILING TO BE COORDDED WITH NEW PERIMETER SLOTTED AREA IN ALL CORRIDORS.
- ⑥ CENTER LIGHT FIXTURE IN CORRIDORS.
- ⑦ REFER TO A-281 FOR LIGHTING FIXTURE SCHEDULE.
- ⑧ -X=FOR FLOOR LIGHT BRIGHTNESS FOR FLOOR SURFACES
- ⑨ CORRELATIVE LOCATION OF HATCHON CHAIR WITH DESIGNER PREFER TO RESTAURATION. ADDITIONAL BROOMING MAY BE REQUIRED.
- ⑩ ALL GENERAL CHAIRS AND SPOFFS TO BE REMOVED AND REPLACED IN SAME LOCATION. CHAIRS AND PUBLIC RESTROOMS CHAIRS TO BE PAINTED #101 (EGGSHELL PINK).
- ⑪ LED STRIP LIGHTING SOURCE ON PLAIN WITH 100' OF PLAIN IN RESTROOMS.
- ⑫ ALL LIGHT FIXTURES IN CAMPERY APARTMENTS AND POOL AREAS TO BE NEW AND CENTERED IN SPACE UNL.
- ⑬ NEW DOWNLIGHT SPRING PLAIN CORNERS IN HATCHON LIGHT FIXTURES WILL BE REPLACED EXISTING IN SAME LOCATION. ALL DOWNLIGHT SPRING PLAIN CORNERS IN POOL AREA TO BE REMOVED TO BE REPLACED WITH DOWNLIGHT RECESSED FOR DOWNLIGHT HOUSING.
- ⑭ 12"X4" DOWNLIGHT TO CEILING IN FRONT OF WINDOW DO NOT ACT AS LIGHTS TO CORRAL. DOWNLIGHT PLAIN. 12"X4 TO BE PAINTED #101 (EGGSHELL PINK).

LEGEND

- | | | | |
|--|---|--|---|
| | CHS CODE/DEVICE | | BATTERY POWERED
MALL MOUNTED |
| | COLOR LIGHT KIT
CEILING LIGHT | | LIGHT OFFUSER |
| | COLOR HEIGHT - AFT
CEILING HEIGHT | | OCCUPANCY SENSOR |
| | 1" X 4" PENDANT | | EXT. SIGN
ARRIVING INDICATE DIRECTION |
| | DOWNLIGHT | | EXT. SIGN - MALL MOUNTED
ARRIVING INDICATE DIRECTION |
| | LED STRIP LIGHT | | SMOKE DETECTOR CEILING MOUNTED |
| | EXTERIOR/DECORATIVE SCIENCE
PENDANT FEATURE | | SMOKE DETECTOR MALL MOUNTED |
| | SURFACE MOUNTED FEATURE | | EXISTING CEILING MOUNTED
SPRINKLER |
| | MALL SCIENCE | | SPRINKLER |
| | EXISTING FEATURE TO
BE REPLACED WITH NEW
FEATURE IN SAME LOCATION | | EXISTING MALL MOUNTED
SUPPLY DIFFUSER |
| | DEMO FEATURE - PATCH
OUT AND REPAIR CEMENT | | RETURN AIR GRILLE |
| | NEW LIGHT FEATURE | | REPLACE CEILING MOUNTED
WITH NEW LIGHT FEATURE |
| | DEMO LIGHT FEATURE | | REPLACEMENT |

NOTE: CEILINGS AT EXISTING HADDON HALL GUESTROOMS ARE EXISTING TO REMAIN AT 9'-0" A.F.F. UNLESS OTHERWISE NOTED

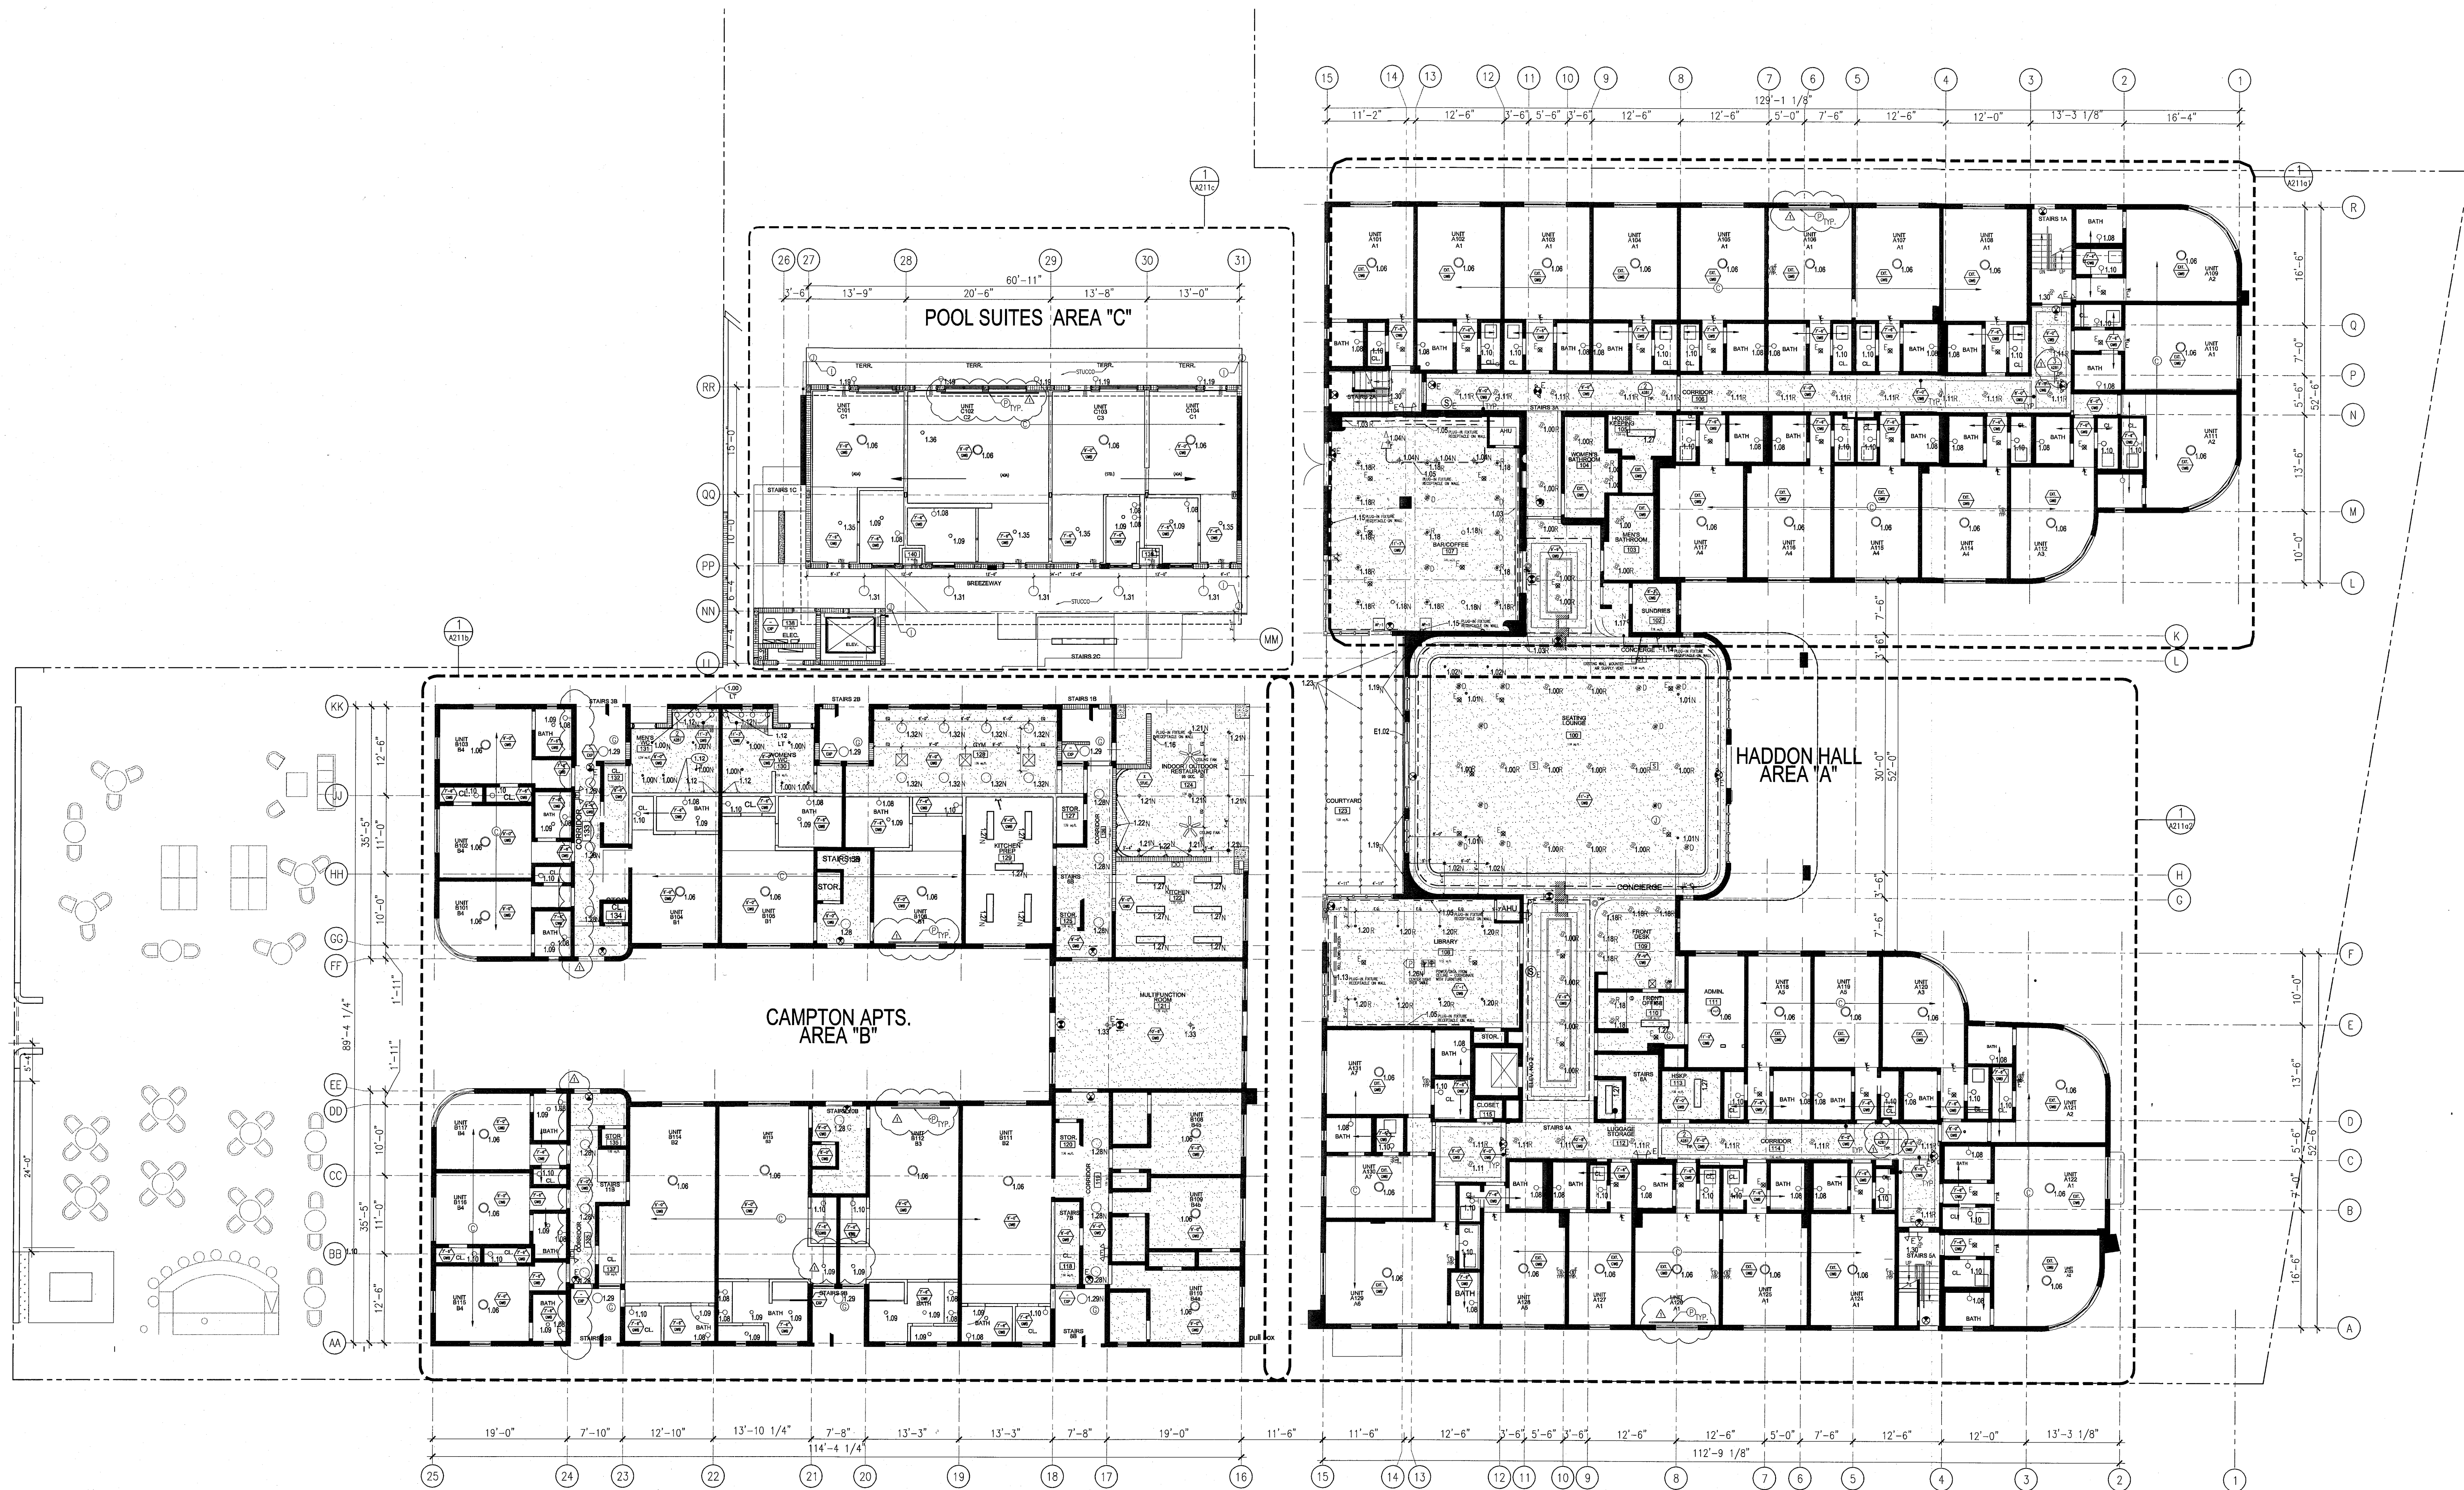

1 OVERALL FIRST FLOOR REFLECTED CEILING PLAN
SCALE: 3/32" = 1'-0"

APPROVED
MIAMI BEACH
FIRE DEPARTMENT

KEYPLAN N.T.S.

NOTIFY THE ARCHITECT OF ANY UNEXPECTED FIELD CONDITION OR OBSTACLE ENCOUNTERED DURING CONSTRUCTION. THE CONTRACTOR IS TO COORDINATE THE COMPLETE SCOPE OF WORK WITH CONSTRUCTION DOCUMENTS.

NO MAN FRAMING OR STRUCTURAL MEMBERS ARE TO BE ACQUIRED, USED OR CUT OUT WITHOUT THE APPROVAL OF THE ARCHITECT AND BUILDING DEPARTMENT.

REVIEW BUILDING STANDARD MANUAL PROVIDED BY THE BUILDING DEPARTMENT BEFORE PROCEEDING WITH WORK.

PROVIDE TEMPORARY SECURE ACCESS TO SPACE THROUGH CONSTRUCTION AND EMERGENCY EXITS.

PROVIDE STRICT CONTROL OF JOB CLEANING AND PREVENT DUST AND DEBRIS FROM EXAMINING FROM CONSTRUCTION AREA.

DEBRIS REMOVAL MUST BE DONE USING THE FREIGHT ELEVATOR. CONTACT BUILDING MANAGEMENT OFFICE TO OBTAIN SCHEDULE FOR USE OF FREIGHT ELEVATORS FOR DEBRIS REMOVAL. ALL DEBRIS MUST BE REMOVED FROM THE PROJECT IN ACCORDANCE WITH BUILDING MANAGEMENT REQUIREMENTS.

REVIEW AND CONFIRM ALL CODES AND PERMITS WITH BUILDING MANAGEMENT TO OBTAIN MOST RECENT REQUIREMENTS FOR DEBRIS REMOVAL.

- 7 CAP AND SHUT OFF ALL UNUSED UTILITIES PER CITY AND
STATE REQUIREMENTS. USE REQUIRED PERMITS.
- 8 FIRE ALARM DEVICES (SMOKE DETECTORS, HORN, STROBE
EXIT SOUNDS) WITHIN DEMO SPACE SHALL REMAIN COMING
EXISTING SYSTEMS. SECURE DEVICES AS NECESSARY TO
FROM HAVING FREELY UPON REMOVAL OF WALLS/COLUMNS.
- 9 PROTECT ALL BASE BUILDING SYSTEMS, TYPICAL.
- 10 ALL REQUIREMENTS FOR FIRE RATINGS TO BE MAINTAINED
DURING CONSTRUCTION.
- 11 THIS PROJECT INVOLVES CONSTRUCTION INSIDE AN EX-
STRUCTURE CONTRACTORS, BY SUBMITTING A BID, ARE
DEEMED TO BE COMPLETELY FAMILIAR WITH THE EXISTING
CONDITION OF THE BUILDING AS IT INFLUENCES THE
DESCRIBED. ABSOLUTELY NO CLAIMS FOR EXTRA
COSTS WILL BE ALLOWED FOR ANYTHING FOR EXISTING
CONDITIONS VISIBLE OR REASONABLY INFERRABLE FROM
CAREFUL EXAMINATION OF THE EXISTING BLDG.
- 12 ELECTRICAL DEVICES SHALL BE TERMINATED IN A SAFE AT
PROPER METHOD BY A LICENSED PROFESSIONAL.

13. ALL MEET-UP DEVICE LOCATIONS NOT SHOWN ON DRAWINGS OR IN CONFLICT WITH MEET-UP DRAWING ARE TO BE COORDINATED WITH ARCHITECT FIRM'S INSTALLATION.
14. SHUTDOWN OF EXISTING SYSTEMS FOR CONNECTION TO EXISTING SERVICES SHALL BE COORDINATED WITH THE CONSTRUCTION MANAGER AND BUILDING OWNER. THE CONTRACTOR SHALL SUBMIT REQUESTS, IN WRITING, THEY AFFECT THE OPERATION OF THE BUILDING SYSTEMS, AT LEAST ONE WEEK IN ADVANCE OF REQUIRED SHUTDOWN. THE ACTUAL SHUTDOWN DURATION SHALL BE AS SHORT AS POSSIBLE AND BE A TIME MUTUALLY AGREEABLE TO THE BUILDING OWNER AND THE CONSTRUCTION MANAGER.
15. ALL WORK SHALL COMPLY WITH FEDERAL, STATE, AND LOCAL BUILDING CODES
16. C.C. TO COORDINATE ALL AUDIO/VISUAL EQUIPMENT NEEDS WITH CLIENT.
17. BOTTOM OF ALL HANGING FIXTURES TO BE NO LOWER THAN 7'-0" AFF.

20. CONTRACTOR TO PROVIDE OVERLAP DRAWING OF EXISTING SPRINKLER SYSTEM, INCLUDING COMPONENTS, LIFT STATIONS, SIGNAL DEVICES, SMOKE DETECTORS, EMERGENCY LIGHTS AND ALARMS IN COLLING TO ENSURE NO CONFLICTS.
21. SPRINKLER HEADS SHOWN FOR ARCHITECTURAL PURPOSES ONLY. NOT FOR COLD DISTRIBUTION. SEE FIRE PROTECTION DRAWINGS FOR DISTRIBUTION AND CALCULATION.
22. CONTRACTOR WILL NOTIFY ARCHITECT IMMEDIATELY IN WRITING OF ANY DISCREPANCY BETWEEN ARCHITECTURE AND ENGINEERING DRAWINGS.
23. THE CONTRACTOR SHALL INSPECT THE EXISTING CONDITIONS AT THE SITE PRIOR TO THE START OF WORK TO DETERMINE WHAT EFFECT THE EXISTING CONDITIONS WILL HAVE ON HIS WORK. POTENTIAL AREAS SHALL BE BROUGHT TO THE ATTN. OF THE ARCHITECT AND/OR ENGINEER IMMEDIATELY.
24. CONTRACTOR SHALL PROVIDE SHEETS E-01 FOR ELECTRICAL COLD SERIES FOR FIRE SPRINKLER DRAWINGS.

- | | |
|--|--|
| ELECTRICAL,
SAFETY AND
AND OTHER | (6) ALL EXISTING CUPBOARD DOORS CEILING IS MAINTAINED AND RESTORED WHERE POSSIBLE. RELOCATION FOR ADDITION OF NEW KITCHEN SINKED AREA. |
| DESIGN INTENT
THE PROTECTION
S. | (7) ALL EXISTING LIGHT FIXTURES IN HALLWAY REMOVED AND REPLACED IN SAME LOCATION OTHERWISE NOTED. |
| LY OF ANY
ERING | (8) FOR HOTEL ROOMS REFER TO SHEET 09-01 |
| FIELD OF
ANY
TING | (9) FOR OUTDOOR AREA LIGHTING REFER TO PLANS. |
| AL PROBLEM
THE ARCHITECT | (10) EXISTING HISTORIC SOFFIT AREAS IN HALLWAY RESTORED ON COMMON AREA TO BE KEPT RESTORED. |
| HALLWAYS AND PP | (11) EXISTING EXPOSED SPRINKLER PIPES IN HALLWAY TO BE COVERED WITH NEW PEEL OFF ADHESIVE COATING AT ALL CORNERS. |
| | (12) CENTER LIGHT FIXTURE IN SPACE U.O.N. |
| | (13) REFER TO A-281 FOR LIGHTING FIXTURES. |
| | (14) J-BOX FOR FUTURE LED BACKLIGHT FOR |

- | | |
|---|---|
| TO BE
PLANTED
ANIMAL
GRILLS AND
CROCODILES | ② COORDINATE LOCATION OF HUNTING GUAH
WITH DESIGNER PRIOR TO INSTALLATION.
ADDITIONAL BUDGING MAY BE REQUIRED. |
| TO BE
HALL TO BE
UNLESS
ETS 490-918
LANDSCAPE | ③ ALL GENERAL CEMENTS AND SOFFITS TO
PAINTED PT-67 (FLAT FINISH, U.S.A.)
④ CEMENT AND CEMENT
TO BE PAINTED PT-67 (EGGSHALL FINISH) |
| TO BE
HALL
EYES AND
PADDED HALL
MATERIAL SOFFIT | ⑤ LEST LIGHTING SHOWN ON PLAN WILL
NOT BE PLUG-IN RECEPTACLE AT ALL |
| TO BE
HALL
EYES AND
PADDED HALL
MATERIAL SOFFIT | ⑥ ALL LIGHT FIXTURES IN CAMPTON AND
POOL. STATES TO BE NEW AND CENTER
IN SPACE U.S.A. |
| TO BE
HALL
EYES AND
PADDED HALL
MATERIAL SOFFIT | ⑦ WALL SCOVES SHOWN ON PLAN. ALL
FIXTURES IN HUNTON HALL. CEILING
REPLACE EXISTING IN SAME LOCATION.
⑧ SCOVES IN CAMPTON AND POOL. STATES
REFER TO CEILING FOR DIMENSIONS FOR
SPACE HEIGHT |
| TO BE
HALL
EYES AND
PADDED HALL
MATERIAL SOFFIT | ⑨ 1"x4" MOUNTED TO CEILING IN FRONT OF
WINDOWS TO ACT AS VENTS TO CONVEY
DRAFT NO. 134 TO BE PAINTED
PT-67 (FLAT FINISH, U.S.A.) |
| TO BE
HALL
EYES AND
PADDED HALL
MATERIAL SOFFIT | ⑩ TO BE PAINTED PT-67 (FLAT FINISH, U.S.A.) |
| TO BE
HALL
EYES AND
PADDED HALL
MATERIAL SOFFIT | ⑪ TO BE PAINTED PT-67 (FLAT FINISH, U.S.A.) |
| TO BE
HALL
EYES AND
PADDED HALL
MATERIAL SOFFIT | ⑫ TO BE PAINTED PT-67 (FLAT FINISH, U.S.A.) |
| TO BE
HALL
EYES AND
PADDED HALL
MATERIAL SOFFIT | ⑬ TO BE PAINTED PT-67 (FLAT FINISH, U.S.A.) |
| TO BE
HALL
EYES AND
PADDED HALL
MATERIAL SOFFIT | ⑭ TO BE PAINTED PT-67 (FLAT FINISH, U.S.A.) |
| TO BE
HALL
EYES AND
PADDED HALL
MATERIAL SOFFIT | ⑮ TO BE PAINTED PT-67 (FLAT FINISH, U.S.A.) |
| TO BE
HALL
EYES AND
PADDED HALL
MATERIAL SOFFIT | ⑯ TO BE PAINTED PT-67 (FLAT FINISH, U.S.A.) |
| TO BE
HALL
EYES AND
PADDED HALL
MATERIAL SOFFIT | ⑰ TO BE PAINTED PT-67 (FLAT FINISH, U.S.A.) |
| TO BE
HALL
EYES AND
PADDED HALL
MATERIAL SOFFIT | ⑱ TO BE PAINTED PT-67 (FLAT FINISH, U.S.A.) |
| TO BE
HALL
EYES AND
PADDED HALL
MATERIAL SOFFIT | ⑲ TO BE PAINTED PT-67 (FLAT FINISH, U.S.A.) |
| TO BE
HALL
EYES AND
PADDED HALL
MATERIAL SOFFIT | ⑳ TO BE PAINTED PT-67 (FLAT FINISH, U.S.A.) |
| TO BE
HALL
EYES AND
PADDED HALL
MATERIAL SOFFIT | ㉑ TO BE PAINTED PT-67 (FLAT FINISH, U.S.A.) |
| TO BE
HALL
EYES AND
PADDED HALL
MATERIAL SOFFIT | ㉒ TO BE PAINTED PT-67 (FLAT FINISH, U.S.A.) |
| TO BE
HALL
EYES AND
PADDED HALL
MATERIAL SOFFIT | ㉓ TO BE PAINTED PT-67 (FLAT FINISH, U.S.A.) |
| TO BE
HALL
EYES AND
PADDED HALL
MATERIAL SOFFIT | ㉔ TO BE PAINTED PT-67 (FLAT FINISH, U.S.A.) |
| TO BE
HALL
EYES AND
PADDED HALL
MATERIAL SOFFIT | ㉕ TO BE PAINTED PT-67 (FLAT FINISH, U.S.A.) |
| TO BE
HALL
EYES AND
PADDED HALL
MATERIAL SOFFIT | ㉖ TO BE PAINTED PT-67 (FLAT FINISH, U.S.A.) |
| TO BE
HALL
EYES AND
PADDED HALL
MATERIAL SOFFIT | ㉗ TO BE PAINTED PT-67 (FLAT FINISH, U.S.A.) |
| TO BE
HALL
EYES AND
PADDED HALL
MATERIAL SOFFIT | ㉘ TO BE PAINTED PT-67 (FLAT FINISH, U.S.A.) |
| TO BE
HALL
EYES AND
PADDED HALL
MATERIAL SOFFIT | ㉙ TO BE PAINTED PT-67 (FLAT FINISH, U.S.A.) |
| TO BE
HALL
EYES AND
PADDED HALL
MATERIAL SOFFIT | ㉚ TO BE PAINTED PT-67 (FLAT FINISH, U.S.A.) |
| TO BE
HALL
EYES AND
PADDED HALL
MATERIAL SOFFIT | ㉛ TO BE PAINTED PT-67 (FLAT FINISH, U.S.A.) |
| TO BE
HALL
EYES AND
PADDED HALL
MATERIAL SOFFIT | ㉜ TO BE PAINTED PT-67 (FLAT FINISH, U.S.A.) |
| TO BE
HALL
EYES AND
PADDED HALL
MATERIAL SOFFIT | ㉝ TO BE PAINTED PT-67 (FLAT FINISH, U.S.A.) |
| TO BE
HALL
EYES AND
PADDED HALL
MATERIAL SOFFIT | ㉞ TO BE PAINTED PT-67 (FLAT FINISH, U.S.A.) |
| TO BE
HALL
EYES AND
PADDED HALL
MATERIAL SOFFIT | ㉟ TO BE PAINTED PT-67 (FLAT FINISH, U.S.A.) |
| TO BE
HALL
EYES AND
PADDED HALL
MATERIAL SOFFIT | ㊱ TO BE PAINTED PT-67 (FLAT FINISH, U.S.A.) |
| TO BE
HALL
EYES AND
PADDED HALL
MATERIAL SOFFIT | ㊲ TO BE PAINTED PT-67 (FLAT FINISH, U.S.A.) |
| TO BE
HALL
EYES AND
PADDED HALL
MATERIAL SOFFIT | ㊳ TO BE PAINTED PT-67 (FLAT FINISH, U.S.A.) |
| TO BE
HALL
EYES AND
PADDED HALL
MATERIAL SOFFIT | ㊴ TO BE PAINTED PT-67 (FLAT FINISH, U.S.A.) |
| TO BE
HALL
EYES AND
PADDED HALL
MATERIAL SOFFIT | ㊵ TO BE PAINTED PT-67 (FLAT FINISH, U.S.A.) |
| TO BE
HALL
EYES AND
PADDED HALL
MATERIAL SOFFIT | ㊶ TO BE PAINTED PT-67 (FLAT FINISH, U.S.A.) |
| TO BE
HALL
EYES AND
PADDED HALL
MATERIAL SOFFIT | ㊷ TO BE PAINTED PT-67 (FLAT FINISH, U.S.A.) |
| TO BE
HALL
EYES AND
PADDED HALL
MATERIAL SOFFIT | ㊸ TO BE PAINTED PT-67 (FLAT FINISH, U.S.A.) |
| TO BE
HALL
EYES AND
PADDED HALL
MATERIAL SOFFIT | ㊹ TO BE PAINTED PT-67 (FLAT FINISH, U.S.A.) |
| TO BE
HALL
EYES AND
PADDED HALL
MATERIAL SOFFIT | ㊺ TO BE PAINTED PT-67 (FLAT FINISH, U.S.A.) |
| TO BE
HALL
EYES AND
PADDED HALL
MATERIAL SOFFIT | ㊻ TO BE PAINTED PT-67 (FLAT FINISH, U.S.A.) |
| TO BE
HALL
EYES AND
PADDED HALL
MATERIAL SOFFIT | ㊼ TO BE PAINTED PT-67 (FLAT FINISH, U.S.A.) |
| TO BE
HALL
EYES AND
PADDED HALL
MATERIAL SOFFIT | ㊽ TO BE PAINTED PT-67 (FLAT FINISH, U.S.A.) |
| TO BE
HALL
EYES AND
PADDED HALL
MATERIAL SOFFIT | ㊾ TO BE PAINTED PT-67 (FLAT FINISH, U.S.A.) |
| TO BE
HALL
EYES AND
PADDED HALL
MATERIAL SOFFIT | ㊿ TO BE PAINTED PT-67 (FLAT FINISH, U.S.A.) |
| TO BE
HALL
EYES AND
PADDED HALL
MATERIAL SOFFIT | ① TO BE PAINTED PT-67 (FLAT FINISH, U.S.A.) |
| TO BE
HALL
EYES AND
PADDED HALL
MATERIAL SOFFIT | ② TO BE PAINTED PT-67 (FLAT FINISH, U.S.A.) |
| TO BE
HALL
EYES AND
PADDED HALL
MATERIAL SOFFIT | ③ TO BE PAINTED PT-67 (FLAT FINISH, U.S.A.) |
| TO BE
HALL
EYES AND
PADDED HALL
MATERIAL SOFFIT | ④ TO BE PAINTED PT-67 (FLAT FINISH, U.S.A.) |
| TO BE
HALL
EYES AND
PADDED HALL
MATERIAL SOFFIT | ⑤ TO BE PAINTED PT-67 (FLAT FINISH, U.S.A.) |
| TO BE
HALL
EYES AND
PADDED HALL
MATERIAL SOFFIT | ⑥ TO BE PAINTED PT-67 (FLAT FINISH, U.S.A.) |
| TO BE
HALL
EYES AND
PADDED HALL
MATERIAL SOFFIT | ⑦ TO BE PAINTED PT-67 (FLAT FINISH, U.S.A.) |
| TO BE
HALL
EYES AND
PADDED HALL
MATERIAL SOFFIT | ⑧ TO BE PAINTED PT-67 (FLAT FINISH, U.S.A.) |
| TO BE
HALL
EYES AND
PADDED HALL
MATERIAL SOFFIT | ⑨ TO BE PAINTED PT-67 (FLAT FINISH, U.S.A.) |
| TO BE
HALL
EYES AND
PADDED HALL
MATERIAL SOFFIT | ⑩ TO BE PAINTED PT-67 (FLAT FINISH, U.S.A.) |
| TO BE
HALL
EYES AND
PADDED HALL
MATERIAL SOFFIT | ⑪ TO BE PAINTED PT-67 (FLAT FINISH, U.S.A.) |
| TO BE
HALL
EYES AND
PADDED HALL
MATERIAL SOFFIT | ⑫ TO BE PAINTED PT-67 (FLAT FINISH, U.S.A.) |
| TO BE
HALL
EYES AND
PADDED HALL
MATERIAL SOFFIT | ⑬ TO BE PAINTED PT-67 (FLAT FINISH, U.S.A.) |
| TO BE
HALL
EYES AND
PADDED HALL
MATERIAL SOFFIT | ⑭ TO BE PAINTED PT-67 (FLAT FINISH, U.S.A.) |
| TO BE | |

- | | | | |
|---|---|---|------------|
|  | GAB CEILING/SOFFIT |  | BATH |
|  | CEILING HIGHT KEY |  | DOOR |
|  | CEILING TYPE |  | EXIT ARROW |
|  | CEILING TYPE - ATT |  | LOC |
|  | 1' X 4' PENDANT |  | SMOKE |
|  | DOWNLIGHT |  | EXIT ARROW |
|  | LED STRIP LIGHT |  | LOC |
|  | EXTERIOR/DECORATIVE SOURCE |  | SMOKE |
|  | PENDANT FEATURE |  | EXIT ARROW |
|  | SURFACE MOUNTED FIXTURE |  | LOC |
|  | WALL SOURCE |  | SMOKE |
|  | EXISTING FIXTURE TO BE REPLACED WITH NEW FIXTURE IN SAME LOCATION |  | EXIT ARROW |
|  | DEMOS FIXTURES - PATCH AND REPAIR CEILING |  | LOC |
|  | NEW LIGHT FIXTURE |  | SMOKE |
|  | DEMOS LIGHT FIXTURE |  | EXIT ARROW |
|  | DEMOS LIGHT FIXTURE |  | LOC |

- EXPOSED POWERED
 MOUNTED
 AIR DIFFUSER
 VAPORCANDY SENSOR
 SIGN
 TOWNS INDICATE DIRECTION
 SIGN - WALL MOUNTED
 TOWNS INDICATE DIRECTION
 DETECTOR CEILING MOUNTED
 DETECTOR WALL MOUNTED
 CEILING MOUNTED
 WINDER
 CEILING WALL MOUNTED
 WINDER
 PLY DIFFUSER
 RN AIR GRILLE
 CASE EXISTING FIXTURE
 NEW LIGHT FIXTURE

- DON HALL
 COLLINS AVE
 MIAMI BEACH, FL
 N.T.S.

- ④ ALL EXISTING GROUND WOOD CEILING IN IS TO BE MAINTAINED AND RESTORED WHERE POSSIBLE. MINIMAL SOAKING AND ADDITION OF NEW HANG GRILLS AND SOFFIT AREAS.
- ⑤ ALL EXISTING LIGHT FIXTURES IN HANG HALL ARE TO BE REMOVED AND REPLACED IN SAME LOCATION UNLESS OTHERWISE NOTED.
- ⑥ FOR LIGHT ROOMS, ROOMS REFER TO SHEETS 400-91A.
- ⑦ FOR OUTDOOR AREA LIGHTING REFER TO LANDSCAPE PLANS.
- ⑧ EXISTING HISTORIC SOFFIT AREAS IN HANG HALL, GROUND FLOOR COMMON AREA IS TO BE KEPT AND RESTORED.
- ⑨ EXISTING EXPOSED SPRINKLER PIPES IN HANG HALL BUILDING TO BE COVERED WITH NEW PERMITTER SOFFIT AREA AT ALL CORNERS.
- ⑩ CENTER LIGHT FIXTURE IN SPACE U.O.N.
- ⑪ REFER TO A-281 FOR LIGHTING FIXTURE SCHEDULE.
- ⑫ J-BOX FOR FUTURE LED BACKLIGHT FOR TREE SCREEN

- COORDINATE LOCATION OF HANGING CHAIR WITH DESIGNER PRIOR TO INSTALLATION. ANCHORING, BLOCKING MAY BE REQUIRED.
- ② ALL GENERAL CEILINGS AND SOFFITS TO BE PAINTED PT-07 (FLAT FINISH), U.S.G. ALL RECESSED CEILING JOINTS TO BE PAINTED PT-01 (EGGSHELL FINISH).
- ③ LED STRIP LIGHTING SHOWN ON PLAN WITH NOTE AS PLACING-IN RECEPTACLE AT JUL.
- ④ ALL LIGHT FIXTURES IN CAMPTON APARTMENTS AND LIGHT FIXTURES TO BE NEW AND CENTERED IN SPACE U.O.N.
- ⑤ WALL SOFFITS SHOWN ON PLAN, ALL WALL CORNERS AND WALL QUESTIONS WILL REPLACE EXISTING IN SAME LOCATION. ALL SCORNERS IN CAMPTON AND PULL SUITES NEW. REFER TO ROOM ELEVATIONS FOR SCORNER HEIGHT.
- ⑥ 1"x4" MOUNTED TO CEILING IN FRONT OF WINDOWS TO ACT AS VALANCE TO CONCEAL DRAPERY ROD. 1"x4" TO BE PAINTED PT-07, 1"x4" TO BE PAINTED PT-01.
- ⑦ N

- | | | | |
|---|--|---|--|
| CWS CEILING/SURF | | BATTERY POWERED WALL MOUNTED | |
| CEILING HEIGHT KEY | | LINEAR DIFFUSER | |
| CEILING HEIGHT - AFF | | OCCUPANCY SENSOR | |
| 1' X 4' PENDANT | | EXIT SIGN | |
| DOWNSIGHT | | ARROWS INDICATE DIRECTION | |
| LED STRIP LIGHT | | EXIT SIGN - WALL MOUNT | |
| EXTERIOR/DECORATIVE SCENCE | | ARROWS INDICATE DIRECTION | |
| PENDANT FEATURE | | SMOKE DETECTOR CEILING | |
| SURFACE MOUNTED FEATURE | | SMOKE DETECTOR WALL | |
| WALL SCIENCE | | EXISTING CEILING MOUNT SPRINKLER | |
| EXISTING FEATURE TO BE REMOVED IN SAME LOCATION | | SPRINKLER | |
| CEILING PATCH - PATCH AND REPAIR CEILING | | EXISTING WALL MOUNT SPRINKLER | |
| NEW LIGHT FEATURE | | SUPPLY DIFFUSER | |
| NEW LIGHT FEATURE | | RETURN AIR GRILLE | |
| NEW LIGHT FEATURE | | REPLACE EXISTING WITH NEW LIGHT FEATURE | |
| NEW LIGHT FEATURE | | REPLACE EXISTING WITH NEW LIGHT FEATURE | |

- SECTION
UNITED
ITION
C MOUNTED
C MOUNTED
TED
D
URE
E
- HADDON
1500 COLLIN
MIAMI BEACH, FL
KEYPLAN

- HALL
NS AVE
FL

N.T.S.

	GA GAS CEILING/SOFT CEILING LIGHT		BATTERY POWERED WALL MOUNTED
	CG GAS CEILING LIGHT CEILING PIPE		LINE DEFUSER
	CH CHAIR Y 1/4 X 1/4 PENDANT		OCCUPANCY SENSOR
	CD DOWNLIGHT		EXIT SIGN ARROWS INDICATE DIRECTION
	LED STRIP LIGHT		EXIT SIGN - MAIN MO- ARROWS INDICATE DIRECTION
	CD/CEILING/DECORATIVE SCIENCE		SMOKE DETECTOR CEILING
	P PENDANT FIXTURE		SMOKE DETECTOR WALL SPRINKLER
	S SURFACE MOUNTED FIXTURE		EXISTING CEILING MOUNTED SPRINKLER
	W WALL SOURCE		SPRINKLER
	P PENDING CEILING LIGHT		EXISTING WALL MOUNTED CEILING LIGHT
	CG GAS CEILING WITH NEW FIXTURES IN SAME LOCATION		EXISTING WALL MOUNTED SPRINKLER
	CD DOWNLIGHT - PATCH NEW CEILING LIGHT		SPRINKLER
	N NEW LIGHT FIXTURE		RETURN AIR GRILLE
	CG GAS CEILING FIXTURE		REPLACE EXISTING LIGHT WITH NEW LIGHT FIXTURE

- SECTION
UNITED
ITION
C MOUNTED
C MOUNTED
TED
D
URE
E
- HADDON
1500 COLLIN
MIAMI BEACH, FL
KEYPLAN

- HALL
NS AVE
FL
N.T.S.



A202

COPYRIGHT ADD INC 2011

[illegible]

JOB NUMBER: 13036.00

SHEET TITLE _____

QUEST. NUMBER

A202

KEYPLAN N.T.S.

1. NOTIFY THE ARCHITECT OF ANY UNEXPECTED FIELD CONDITION THAT MAY AFFECT THE PROGRESS OF THE APPROVAL OF THE ARCHITECT AND BUILDING MANAGEMENT.
2. NO WORK FACING OR STRUCTURAL MEMBERS ARE TO BE EXPOSED WITHOUT THE APPROVAL OF THE ARCHITECT AND BUILDING MANAGEMENT.
3. REVIEW BUILDING STANDARD MANUAL, PROVIDED BY THE PROPERTY MANAGER BEFORE PROCEEDING WITH WORK.
4. PROVIDE TEMPORARY SECURE ACCESS TO SPACE THROUGH CORRIDORS AND ELEVATOR SHAFTS TO PROPERTY MANAGER.
5. PROVIDE STRICT CONTROL OF GUN CLEANING AND NICK AND DENT BEANS FROM EXHAUSTING FROM CONSTRUCTION AREA.
6. DESIRS REMOVAL MUST BE DONE USING THE PROTECT ELEVATOR CONTAIN BUILDING MANAGEMENT OFFICE TO OBTAIN SCHEDULE FOR USE OF FREIGHT ELEVATORS PRIOR TO WORKING IN THE AREA. ALL WORK MUST BE COMPLETED IN ACCORDANCE WITH BUILDING MANAGEMENT REQUIREMENTS AND PROCEDURES. CONTRACTOR TO COORDINATE WITH BUILDING MANAGEMENT TO OBTAIN MOST RECENT REQUIREMENTS FOR DESIRS REMOVAL.

7. CAP AND SHUT OFF ALL UNUSED UTILITIES PER CITY AND STATE REQUIREMENTS, HERE REQUIRED.
8. FIRE ALARM DEVICES (SMOKE DETECTORS, HORNS, STROBES AND EXITS) WITHIN DEMO SPACE SHALL REMAIN CONNECTED TO THE CITY FIRE DEPARTMENT AND NOT BE DISCONNECTED FROM HANGING FREELY UPON REMOVAL OF MAINTENANCE/CEILING.
9. PROTECT ALL BASE BUILDING SERVICES, TYPICAL.
10. ALL REQUIREMENTS FOR FIRE RATINGS TO BE MAINTAINED DURING CONSTRUCTION.
11. THIS PROJECT INVOLVES CONSTRUCTION INTO AN EXISTING STRUCTURE. CONTRACTORS, BY SUBMITTING A BID, ARE DEEMED TO BE COMPLETELY FAMILIAR WITH THE EXISTING CONDITION OF THE BUILDING AS IT INFLUENCES THE WORK TO BE DONE. CONTRACTORS SHALL BE RESPONSIBLE FOR ANY COMPENSATION WILL BE CONSIDERED FOR EXISTING CONDITIONS UNLESS OR OTHERWISE NOTED ON THE DRAWINGS. A CAREFUL EXAMINATION OF THE EXISTING BLDG.
12. ELECTRIC DEVICES SHALL BE TERMINATED IN A SAFE AND PROPER METHOD BY A LICENSED PROFESSIONAL.

- | | | | |
|-----|--|-----|--|
| 13. | ALL MEP-PERMEABLE LOCATIONS NOT SHOWN ON THE EXISTING CONDITIONS SHEET SHALL BE IDENTIFIED AND BE CO-ORDINATED WITH ARCHITECT PRIOR TO INSTALLATION. | 18. | CON-
DIRE |
| 14. | SHUTDOWN OF EXISTING SYSTEMS FOR CONNECTION TO EXISTING SERVICES SHALL BE COORDINATED WITH THE CONSTRUCTION MANAGER AND BUILDING OWNER. THE OWNER SHALL SUBMIT REQUESTS, WHERE THEY AFFECT THE OPERATION OF THE BUILDING SYSTEMS, AT LEAST ONE WEEK IN ADVANCE OF ANY SHUTDOWN. THE ACTUAL SHUTDOWN PERIOD SHALL BE AS SHORT AS POSSIBLE AND TO THE EXTENT AGREEABLE TO THE BUILDING OWNER AND THE CONSTRUCTION MANAGER. | 19. | SPE-
CIFIC |
| 15. | ALL WORK SHALL COMPLY WITH FEDERAL, STATE, AND LOCAL BUILDING CODES. | 20. | CON-
DIRE |
| 16. | G.C. TO COORDINATE ALL AUDIO/VISUAL EQUIPMENT WITH THE CONSTRUCTION MANAGER. | 21. | TH-
CON-
WE-
CON-
AR-
AR- |
| 17. | BOTTOM OF ALL HANGING FLOORS TO BE NO LOWER THAN 1'-0" AFF. | 22. | CON-
DIRE |

- CONTRACTOR TO PROVIDE DRYER DRYING OF ELECTRICAL EQUIPMENT, LUMPS, SYSTEMS AND COMPONENTS, LIFE-SAFETY EQUIPMENT, SMOKE DETECTORS, EMERGENCY LIGHTS AND ANY OTHER VIE IN RELATING TO SHOW NO CONFLICTS.
- SPRINKLER HEADS SHOWN FOR ARCHITECTURAL DESIGN INTENT ONLY. NOT FOR QUOTE DISTRIBUTION. SEE FIRE PROTECTION DRAWINGS FOR DISTRIBUTION AND CALCULATIONS.
- THE CONTRACTOR WILL NOTIFY ARCHITECT IMMEDIATELY OF ANY DISCREPANCIES BETWEEN ARCHITECTURE AND ENGINEERING DRAWINGS.
- THE CONTRACTOR SHALL INSPECT THE EXISTING FIELD CONDITIONS AT THE SITE PRIOR TO THE START OF ANY WORK TO DETERMINE WHAT OFFICE THE CONTRACTOR'S OBLIGATIONS WILL HAVE ON HIS WORK. POTENTIAL PROBLEMS SHALL BE BROUGHT TO THE ATTN. OF THE ARCHITECT IMMEDIATELY UPON DISCOVERY.
- THE CONTRACTOR SHALL PROVIDE 10 SHEETS 10"X10" FOR ELECTRICAL DRAWINGS AND 10 SHEETS FOR FIRE SPRINKLER DRAWINGS.

① ALL EXISTING CIPSTONE BENCH GRABINS IN TO BE MAINTAINED AND RESTORED WHERE POSSIBLE. MINIMAL CEMENT ADDITION OF NEW HOLE GRILLS AND SORTED AREAS. ②
 ③ ALL EXISTING LIGHT FIXTURES IN HADDOON HALL TO BE REMOVED AND REPLACED IN SAME LOCATION UNLESS OTHERWISE NOTED. ④
 ⑤ FOR HOLE, ROOMS, ROOPS REFER TO SHEETS A801-218. ⑥
 ⑦ FOR OUTDOOR AREA LIGHTING REFER TO LANDSCAPE PLANS. ⑧
 ⑨ EXISTING HISTORIC SPOKE AREAS IN HADDOON HALL GROUND FLOOR COMMON AREA TO BE KEPT AND RESTORED. ⑩
 ⑪ EXISTING CAPPED SPRINKLER PIPS IN HADDOON HALL BUILDING TO BE COVERED WITH NEW PERIMETER STRIP AREA AT ALL CORRIDORS. ⑫
 ⑬ CENTER LIGHT FIXTURE IN SPACE U2A. ⑭
 ⑮ REFER TO A-281 FOR LIGHTING TIEOUT SCHEDULE. ⑯
 ⑰ J-BOOK FOR FUTURE LED BUGHOUT FOR TUBE SCREEN. ⑱

- [illegible]

	ON/OFF CONTROL		BATTERY POWERED
	CEILING MOUNT		LINEAR OUTPUT
	ON/OFF CONTROL WITH ARROW		OCCUPANCY SENSOR
	1' x 4' PENDANT		ARROW POINTS DIRECTION
	DOWNLIGHT		EXIT SIGN - WALL MOUNTED
	LED STRIP LIGHT		ARROW POINTS DIRECTION
	EXTERNAL/DECORATIVE SOURCE		SMOKE DETECTOR CEILING MOUNTED
	PENDANT FIXTURE		SMOKE DETECTOR WALL MOUNTED
	SURFACE MOUNTED FIXTURE		EXISTING CEILING MOUNTED SPRINKLER
	WALL SOURCE		SPRINKLER
	EXISTING FIXTURE TO BE REPLACED WITH NEW FIXTURE IN SAME LOCATION		EXISTING WALL MOUNTED
	ON/OFF CONTROL - PARACH AND ARROW CONTROL		SUPPLY AIR DIFFUSER
	NEW LIGHT FIXTURE		RETURN AIR GRILLE
	DEMO LIGHT FIXTURE		REPLACE EXISTING FIXTURE WITH NEW LIGHT FIXTURE



PRIVATE PROVIDER SERVICES, LLC
Construction Plans Review, Inspections, Testing & Consulting

	REVIEWER INITIALS	DATE REVIEWED
BUILDING	EM	11-10-14
STRUCTURAL		
MECHANICAL		
ELECTRICAL		
PLUMBING		
SITE CIVIL		

One Biscayne Tower
Suite 1670
Two South
Biscayne Boulevard
Miami, Fl 33131
T. 305.482.8700
F. 305.482.8770
www.addlinc.com
Lic. # AA26001507

Boston Miami

CHECKED BY: _____
 ISSUE DATE: FEBRUARY 18, 2014
 SCALE: $3/32" = 1'-0"$

THIRD FLOOR
REFLECTED CEILING
PLAN

A203

COPYRIGHT ADD INC 2011

APPROVED
MIAMI BEACH
FIRE DEPARTMENT


MIAMI BEACH, FL

N.T.S.

DESCRIPTION	ISSUE DATE
MASTER PERMIT COMMENTS	07-03-20

PRIVATE PROVIDED		
Construction Plans Review, Inspections, Testing & Consulting		
	REVIEWER INITIALS	DATE REVIEWED
BUILDING	EM	11-10-14
STRUCTURAL		
MECHANICAL		
ELECTRICAL		
PLUMBING		
SITE CIVIL		

NORTH SEA

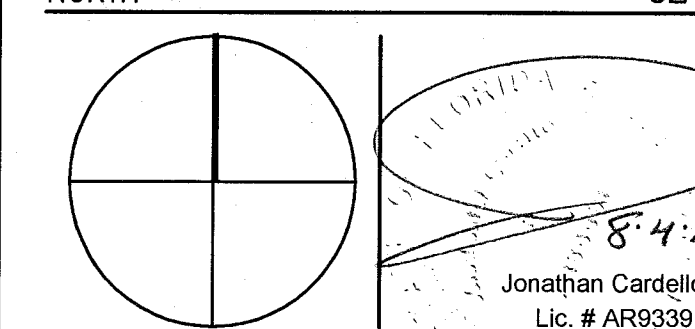

ADD Inc Architecture Interiors Planning

One Biscayne Tower
Suite 1670
Two South
Biscayne Boulevard
Miami, Fl 33131
T. 305.482.8700
F. 305.482.8770
www.addlinc.com
Lic. # AA26001507

Boston Miami

JOB NUMBER: 13036.0
CHECKED BY:
ISSUE DATE: FEBRUARY 18, 2011
SCALE: $3/32" = 1'-0"$

SHEET TITLE

ROOF DECK
REFLECTED CEILING
PLAN

SHEET NUMBER _____

A204

COPYRIGHT ADD INC 2011

GENERAL NOTES


- | | | | |
|---|---|--|--|
| 1. NOTIFY THE ARCHITECT OF ANY UNEXPECTED FIELD CONDITION OR AN OBSTACLE BEFORE PROCEEDING. CONTACT THE ARCHITECT IMMEDIATELY TO CORRECT THE OBSTACLE BEFORE WORK BEGINS ON STRUCTURAL MEMBERS. | CAP AND SHUT OFF ALL UNUSED UTILITIES PER CITY AND STATE REQUIREMENTS, WHEN REQUIRED. | 14. ALL MEP-PF DEVICES LOCATED NOT SHOWN ON DRAWINGS OR IN CONFLICT WITH MEP-PF DRAWINGS, OR TO BE COORDINATED WITH MEP-PF FROM ANOTHER INSTALLATION. | 18. CONTRACTOR TO PROVIDE OVERSIGHT DRAWING FOR ELECTRICAL, MECHANICAL, AND PLUMBING SYSTEMS AND COMPONENTS. LIFE SAFETY DEVICES, SMOKE DETECTORS, EMERGENCY LIGHTS AND ALARMS ARE TO BE IN COMPLIANCE WITH ALL CITY AND STATE CODES OF ELECTRICAL ENGINEERING FOR NOTIFICATION. |
| 2. NO MAN FRAMING OR STRUCTURAL MEMBERS ARE TO BE INSTALLED UNTIL ALL REQUIRED CONCRETE DEVICES FOR THE ARCHITECT AND BUILDING MANAGER. | 8. FIRE ALARM DEVICES (SMOKE DETECTORS, HORN, STRONGER AND TIE) SHOWN ON DRAWING SPACE SHALL BE CORRELATED TO EXISTING CONCRETE DEVICES TO BE INSTALLED FROM HANGING RIGIDLY UPON REMOVAL OF WALLS-COLUMNS. | 15. SHOWN OF EXISTING SYSTEMS FOR CONNECTION TO EXISTING CONCRETE DEVICES SHALL BE COORDINATED WITH THE CONSTRUCTION MANAGER AND BUILDING OWNER. CONTRACTOR SHALL BE RESPONSIBLE FOR THE DEVICES THEY AFFECT THE OPERATION OF THE BUILDING SYSTEMS. CONTRACTOR SHALL BE RESPONSIBLE FOR ANY REQUIRED SHUTTING. THE ACTUAL SHUTTING OF THE BUILDING SYSTEMS SHALL BE AS SHORT AS POSSIBLE AND TO BE A TIME MUTUALLY AGREEABLE TO THE BUILDING OWNER AND THE CONSTRUCTION MANAGER. | 19. SPRINKLER HANGERS FOR ARCHITECTURAL DESIGN SHALL BE INSTALLED IN ACCORDANCE WITH THE DRAWINGS FOR DISTRIBUTION AND CALCULATIONS. |
| 3. REVIEW BUILDING STANDARD MANUAL PROVIDED BY THE ARCHITECT AND BUILDING MANAGER BEFORE PROCEEDING WITH STRUCTURAL WORK. | 9. PROTECT ALL BASE BUILDING SYSTEMS, TYPICAL. | 16. ALL REQUIREMENTS FOR FIRE RETARDING TO BE MAINTAINED THROUGHOUT CONSTRUCTION. | 20. CONTRACTOR WILL NOTIFY ARCHITECT IMMEDIATELY OF ANY FIELD CONDITIONS THAT MAY AFFECT THE DRAWINGS. |
| 4. PROVIDE TEMPORARY SECURE ACCESS TO SPACE THROUGH CONSTRUCTION AND TEMPORARY LIGHT A POWER. | 10. THIS PROJECT INVOLVES CONSTRUCTION INSIDE AN EXISTING STRUCTURE. CONTRACTORS, BY SUBMITTING A B.A. ARE ASSUMING THE RESPONSIBILITY FOR THE PROTECTION OF THE BUILDING AS IT INFLUENCES THE WORK OF THE ARCHITECT. CONTRACTOR SHALL BE RESPONSIBLE FOR THE PROTECTION OF THE BUILDING AS IT INFLUENCES THE WORK OF THE ARCHITECT. CONTRACTOR SHALL BE RESPONSIBLE FOR THE PROTECTION OF THE BUILDING AS IT INFLUENCES THE WORK OF THE ARCHITECT. | 17. WORK SHALL COMPLY WITH FEDERAL, STATE, AND LOCAL BUILDING CODES. | 21. THE CONTRACTOR SHALL RESPECT THE EXISTING FIELD CONDITIONS AND BETWEEN ARCHITECT AND ENGINEER. CONTRACTOR SHALL BE RESPONSIBLE FOR THE PROTECTION OF THE BUILDING AS IT INFLUENCES THE WORK OF THE ARCHITECT. CONTRACTOR SHALL BE RESPONSIBLE FOR THE PROTECTION OF THE BUILDING AS IT INFLUENCES THE WORK OF THE ARCHITECT. |
| 5. PROVIDE STRICT CONTROL OF JOB CLEANING AND PREVENT DEBRIS FROM LEAVING FROM CONSTRUCTION AREA. | 11. DEBRIS REMOVAL, MUST BE USED TO PREVENT THE DEBRIS FROM LEAVING FROM CONSTRUCTION AREA. CONTRACTOR SHALL BE RESPONSIBLE FOR THE PROTECTION OF THE BUILDING AS IT INFLUENCES THE WORK OF THE ARCHITECT. CONTRACTOR SHALL BE RESPONSIBLE FOR THE PROTECTION OF THE BUILDING AS IT INFLUENCES THE WORK OF THE ARCHITECT. | 13. G.C. TO COORDINATE ALL ANNUAL/BIENNIAL EQUIPMENT MAINTENANCE WITH THE ARCHITECT AND BUILDING MANAGER. | 22. REFER TO SHEETS 10-01 FOR ELECTRICAL DRAWINGS AND SERIES FOR SPREADSHEETS DRAWINGS. |
| 6. OBTAIN SCHEDULING, MUST BE USED TO PREVENT THE DEBRIS FROM LEAVING FROM CONSTRUCTION AREA. CONTRACTOR SHALL BE RESPONSIBLE FOR THE PROTECTION OF THE BUILDING AS IT INFLUENCES THE WORK OF THE ARCHITECT. CONTRACTOR SHALL BE RESPONSIBLE FOR THE PROTECTION OF THE BUILDING AS IT INFLUENCES THE WORK OF THE ARCHITECT. | 12. CONSTRUCTION SHALL BE CONSIDERED FOR EXISTING CONCRETE DEVICES TO BE INSTALLED FROM HANGING RIGIDLY UPON REMOVAL OF WALLS-COLUMNS. CONTRACTOR SHALL BE RESPONSIBLE FOR THE PROTECTION OF THE BUILDING AS IT INFLUENCES THE WORK OF THE ARCHITECT. CONTRACTOR SHALL BE RESPONSIBLE FOR THE PROTECTION OF THE BUILDING AS IT INFLUENCES THE WORK OF THE ARCHITECT. | 17. BOTTOM OF ALL HANGING UTILITIES TO BE NO LOWER THAN 7'-0" AFF. | |
| 7. OBTAIN SCHEDULING, MUST BE USED TO PREVENT THE DEBRIS FROM LEAVING FROM CONSTRUCTION AREA. CONTRACTOR SHALL BE RESPONSIBLE FOR THE PROTECTION OF THE BUILDING AS IT INFLUENCES THE WORK OF THE ARCHITECT. CONTRACTOR SHALL BE RESPONSIBLE FOR THE PROTECTION OF THE BUILDING AS IT INFLUENCES THE WORK OF THE ARCHITECT. | 13. G.C. TO COORDINATE ALL ANNUAL/BIENNIAL EQUIPMENT MAINTENANCE WITH THE ARCHITECT AND BUILDING MANAGER. | | |

SHEET NOTES

- [illegible]




	LEGEND
--	--------

- | | | | |
|---|---|---|---|
|  | CEILING MOUNT/SOFFIT |  | BATTERY POWERED
WALL MOUNTED |
|  | CEILING HEIGHT KEY
CEILING TYPE |  | AIR DIFFUSER |
|  | CEILING HEIGHT - AFT |  | OCCUPANCY SENSOR |
|  | 1" X 4" PENDANT |  | EXIT SIGN
ARROWS INDICATE DIRECTION |
|  | DOWNLIGHT |  | SMOKE SMOKE - WALL MOUNTED
ARROWS INDICATE DIRECTION |
|  | LED STRIP LIGHT |  | SMOKE DETECTOR CEILING MOUNT |
|  | EXTERIOR/OCCUPANCY SCIENCE |  | SMOKE DETECTOR WALL MOUNT |
|  | PENDANT VENT |  | EXISTING CEILING MOUNT
SPRINKLER |
|  | SURFACE MOUNTED FIXTURE |  | SPRINKLER |
|  | WALL SCIENCE |  | EXISTING WALL MOUNTED
SUPPLY DIFFUSER |
|  | EXISTING FIXTURE TO
BE REPLACED WITH NEW
FIXTURE IN SAME LOCATION |  | EXISTING AIR GRILLE |
|  | EXISTING FIXTURE - PATCH
AND REPAIR CEILING |  | REPLACE EXISTING FIXTURE
WITH NEW LIGHT FIXTURE |
|  | NEW LIGHT FIXTURE |  | |

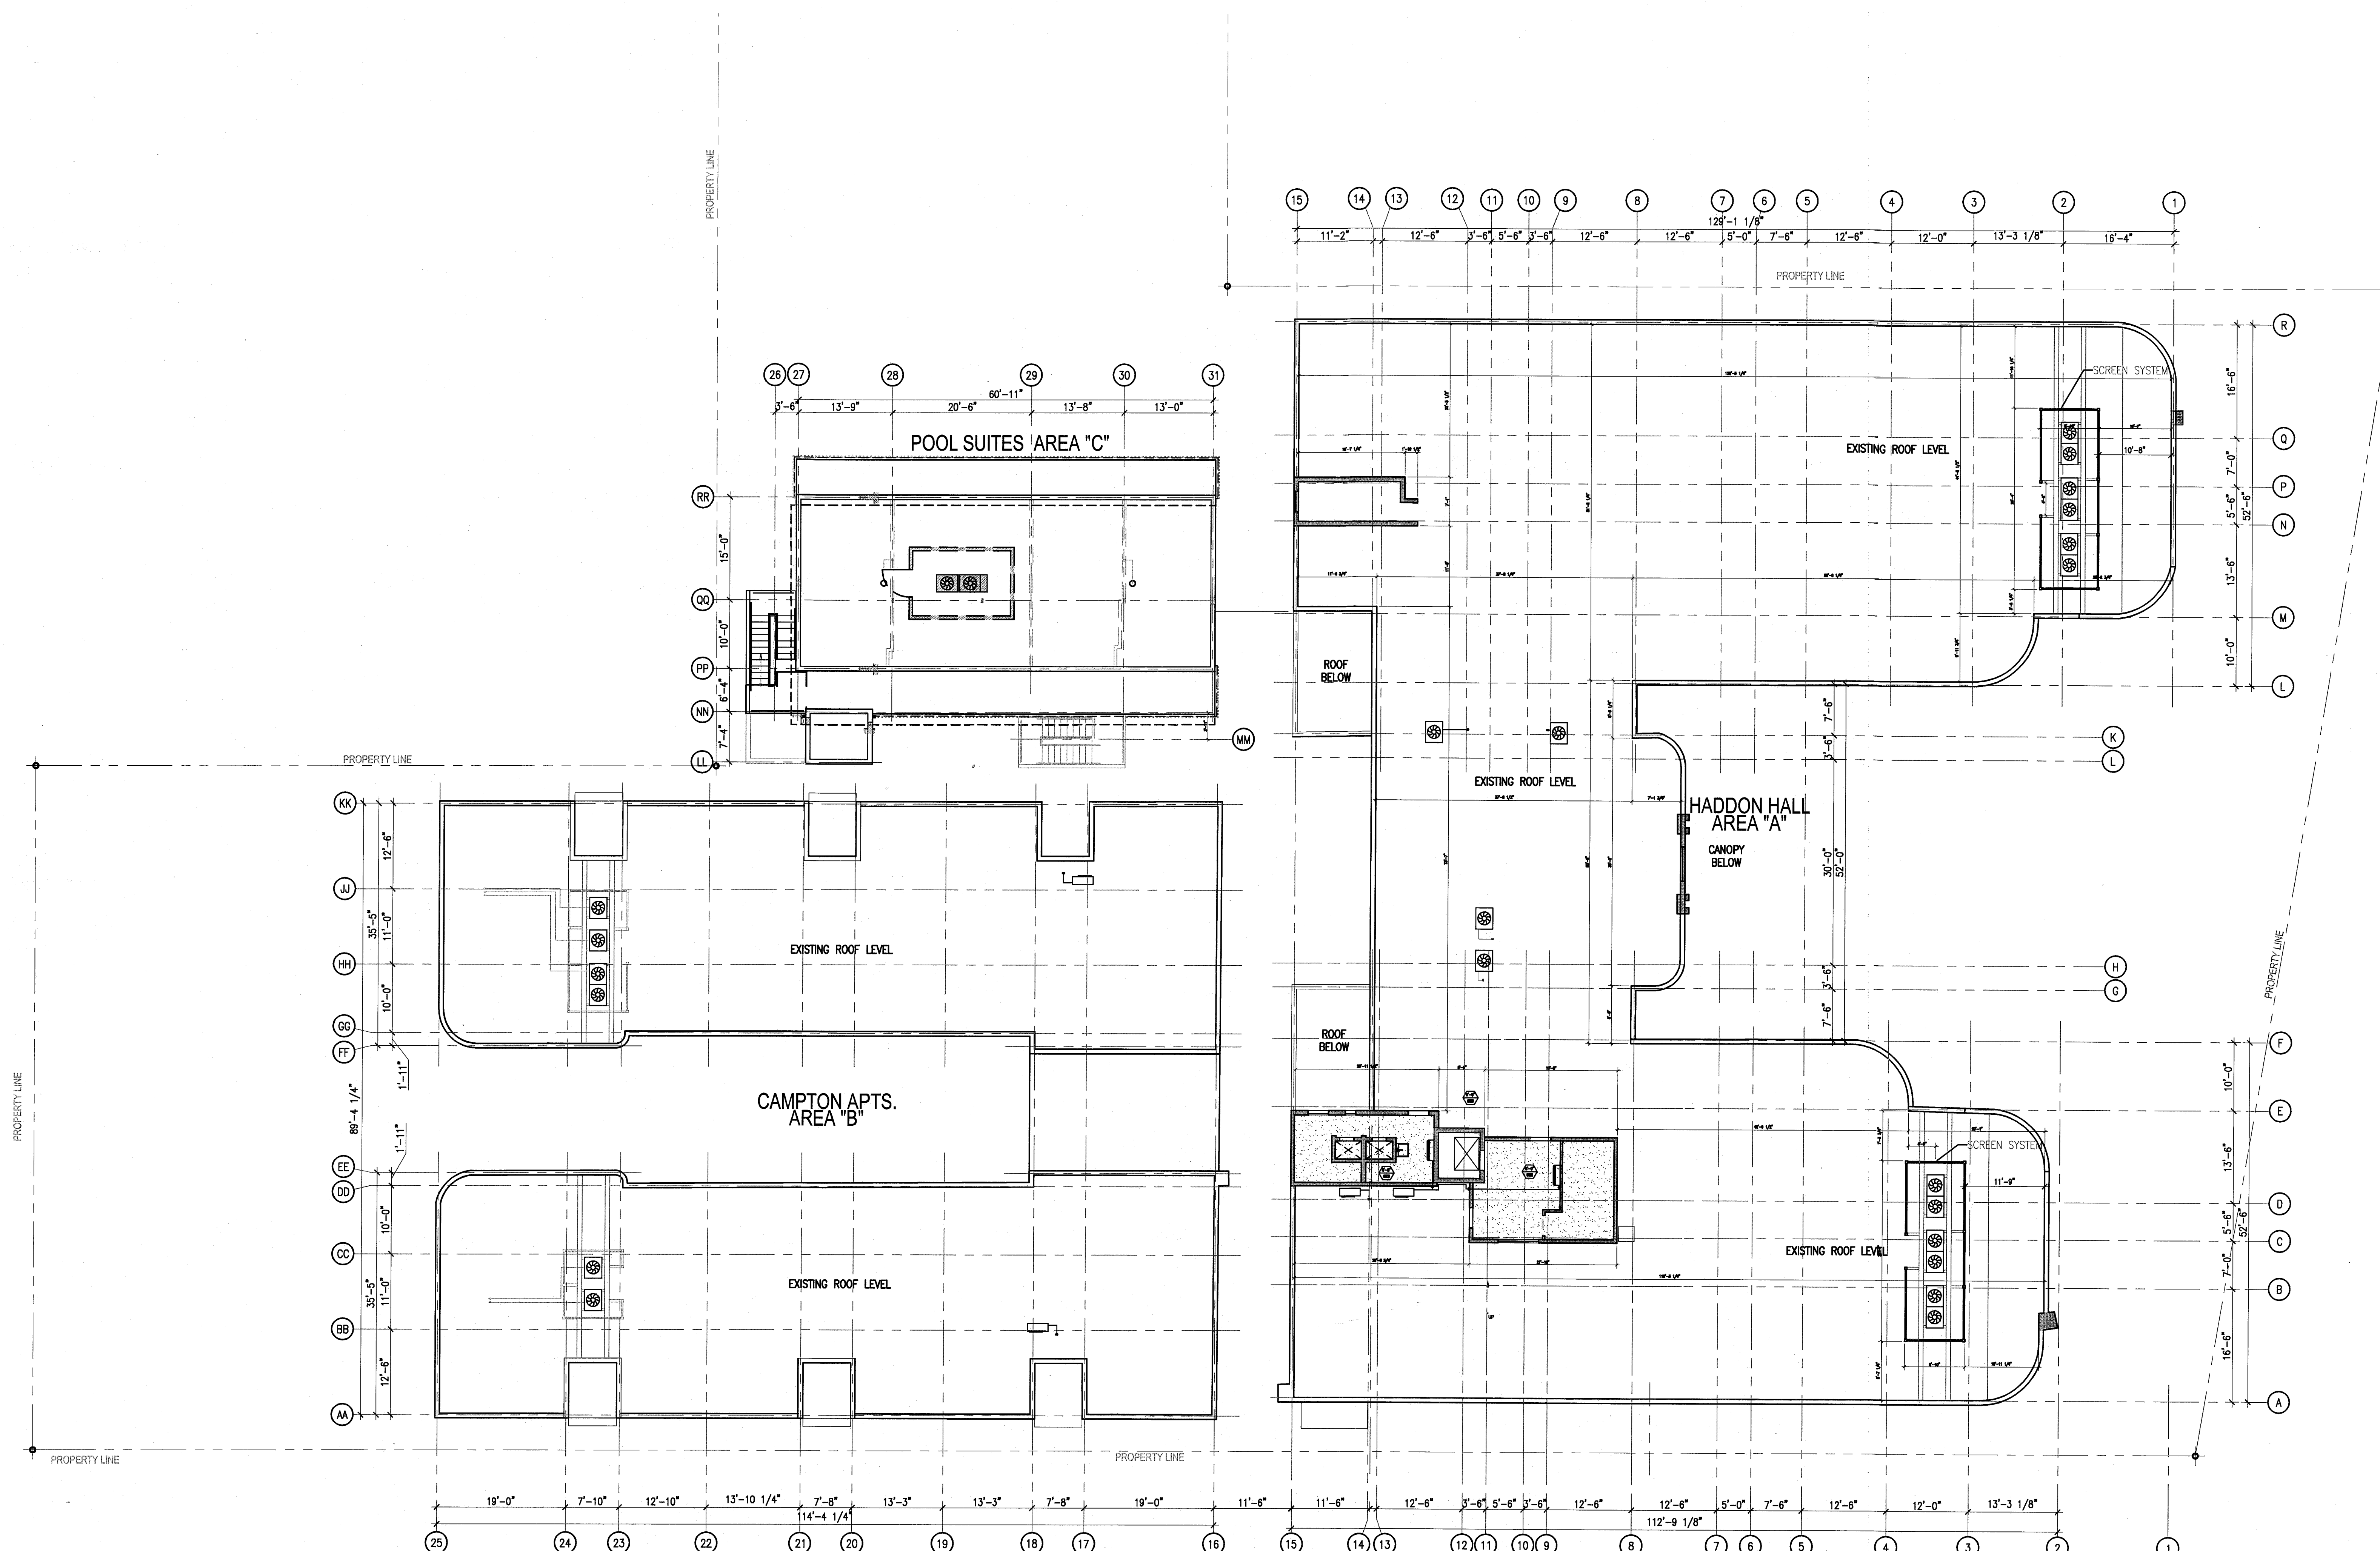

1 OVERALL ROOF DECK REFLECTED CEILING PLAN
SCALE: 3/32" = 1'-0"

APPROVED
MIAMI BEACH
FIRE DEPARTMENT

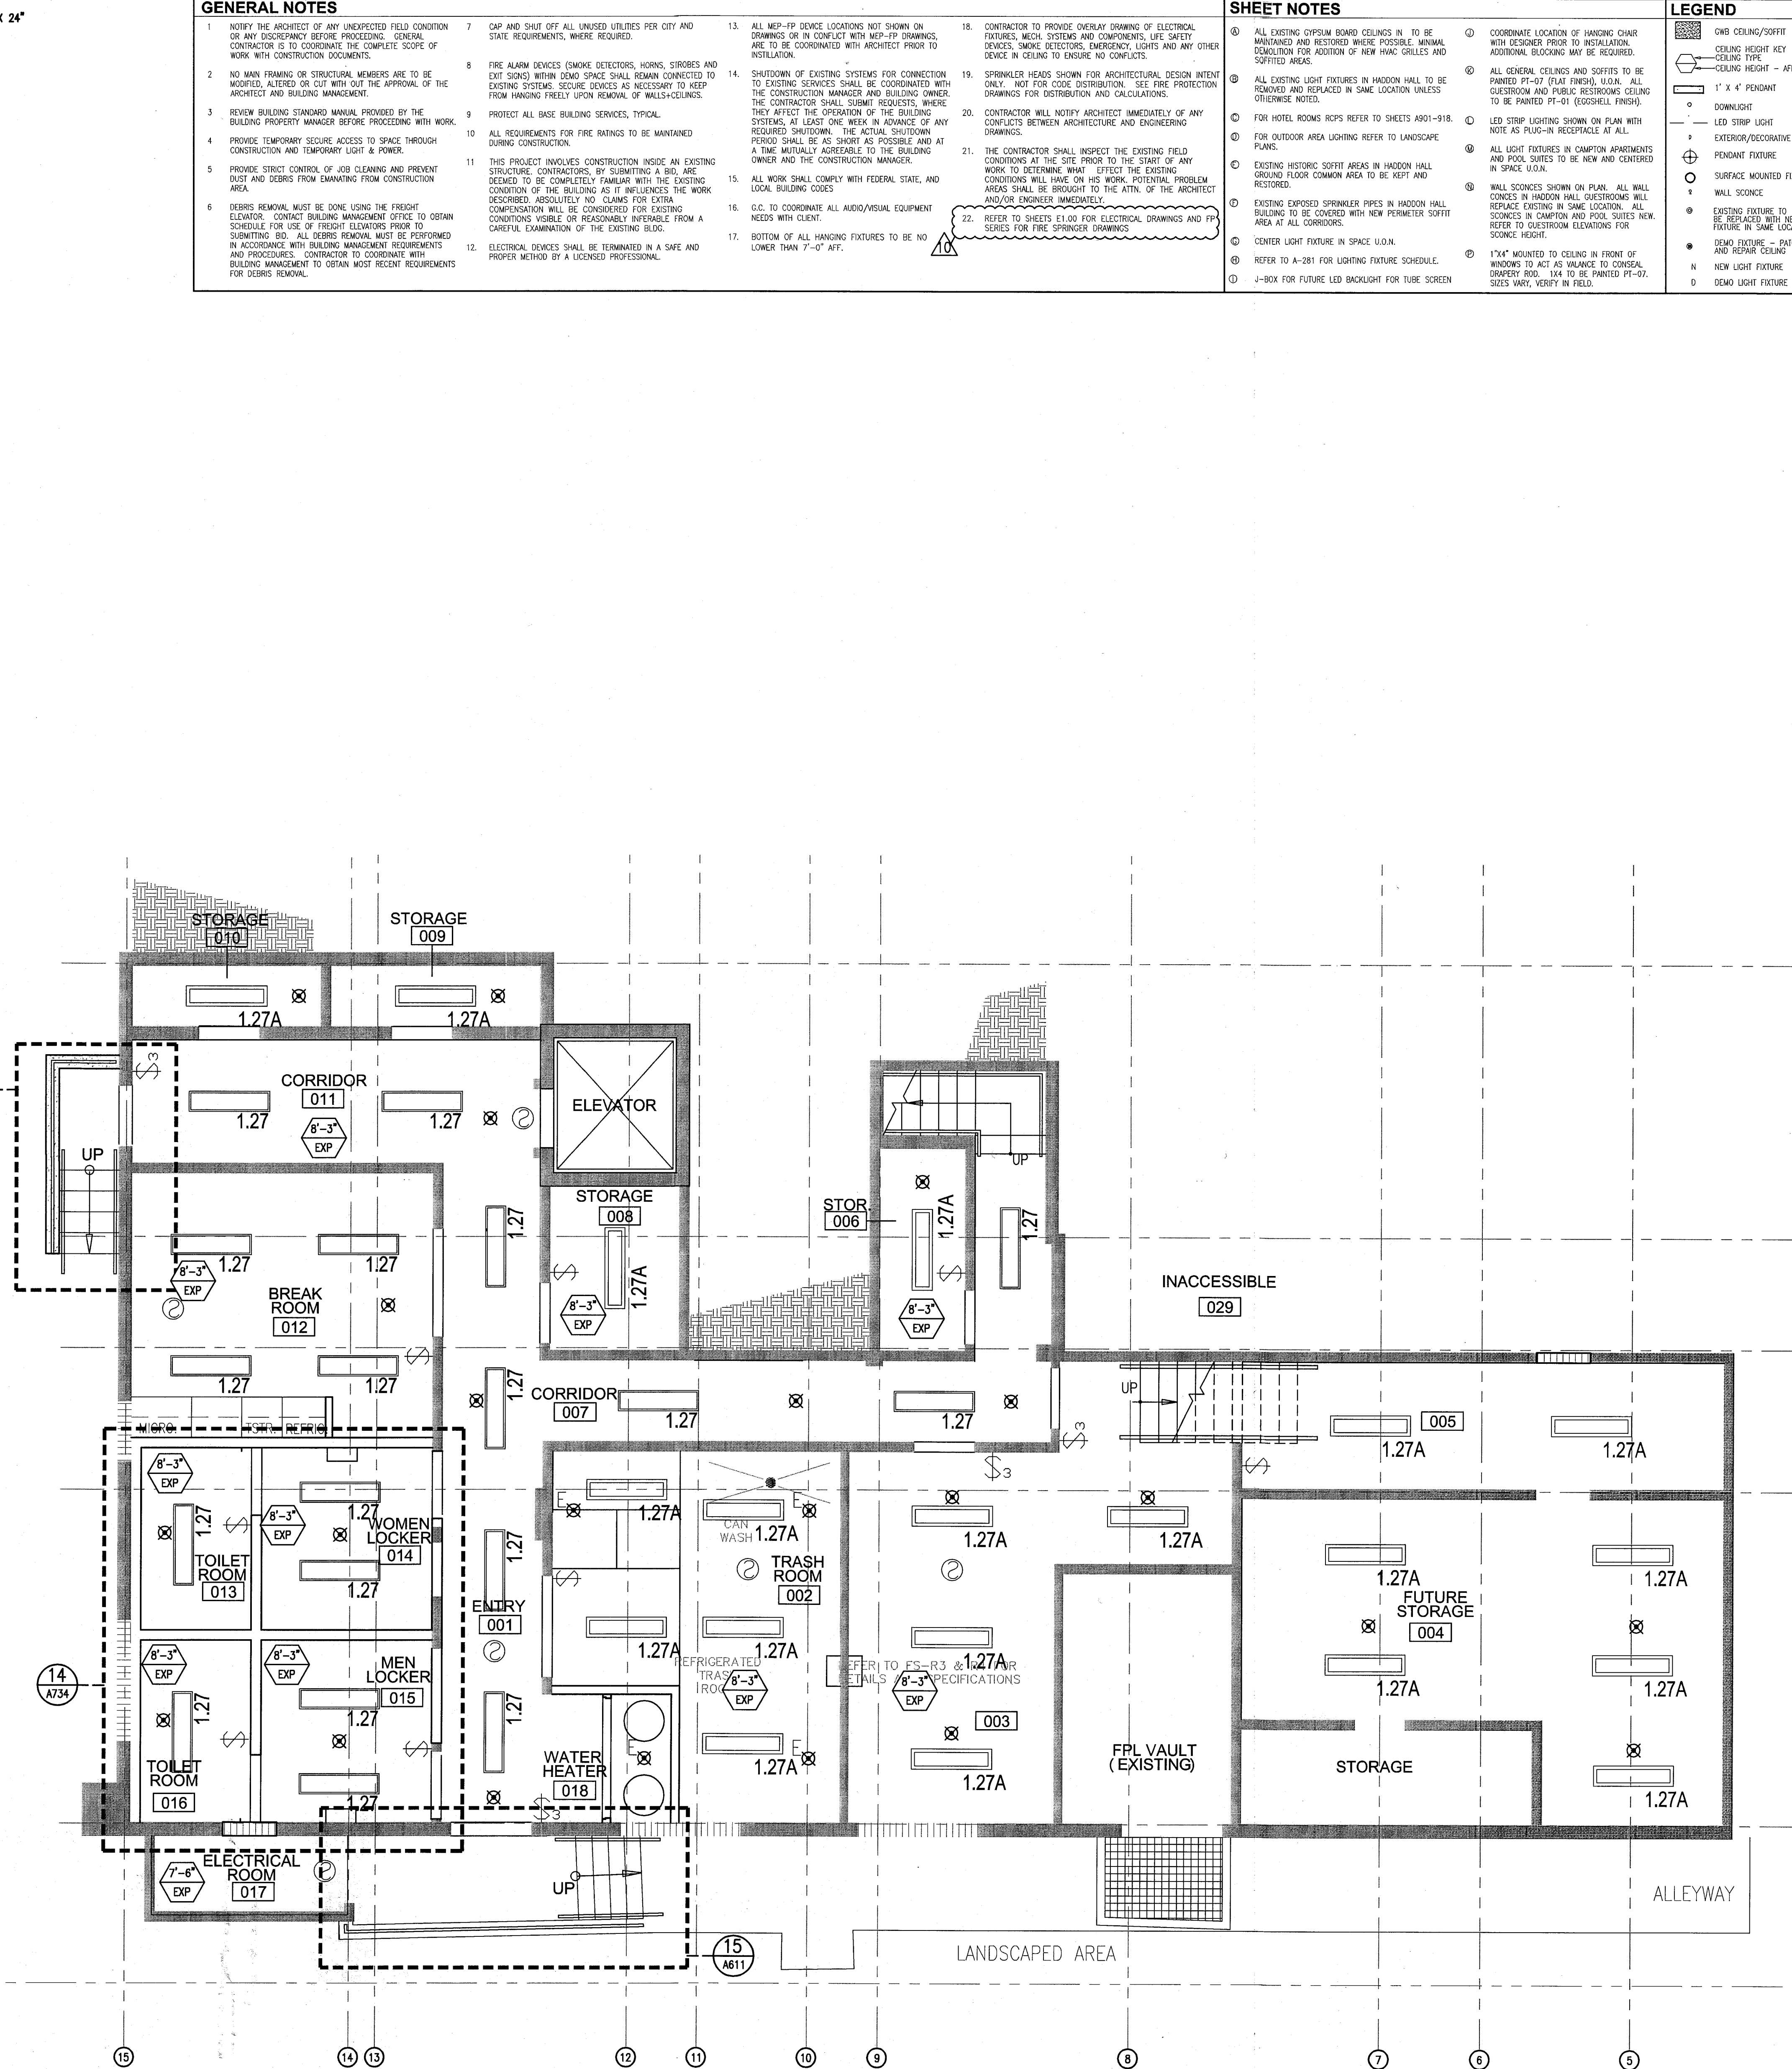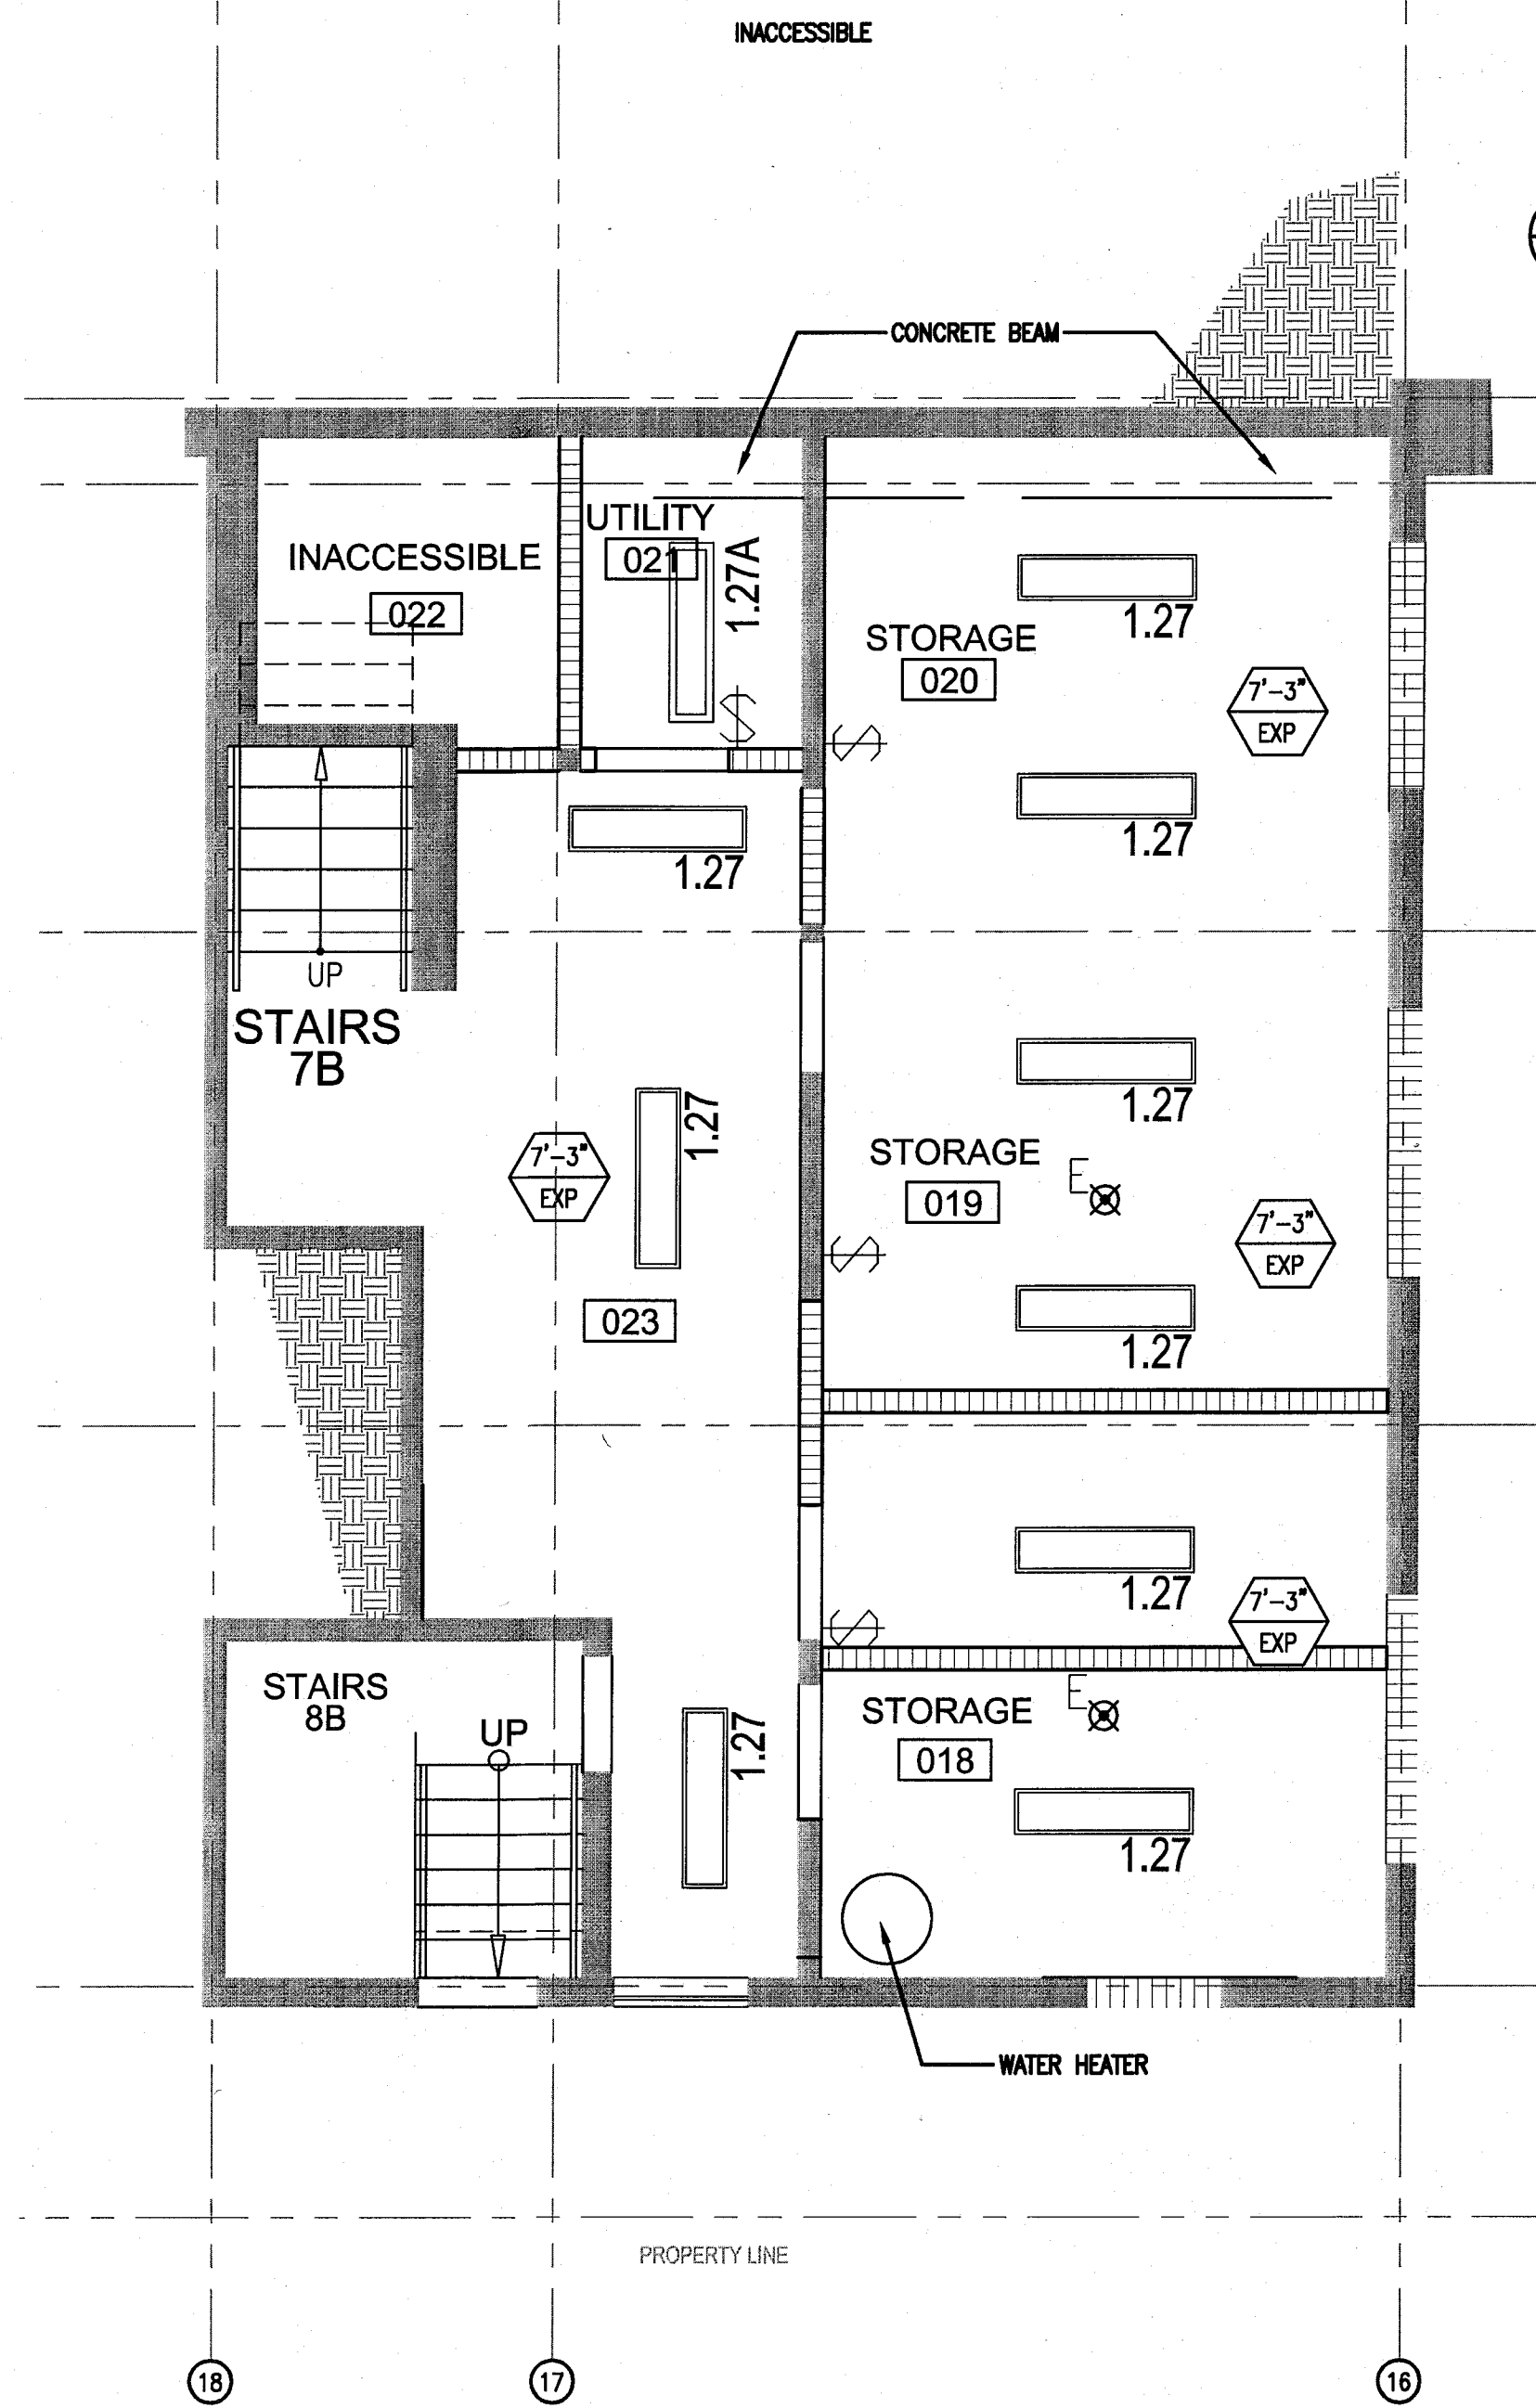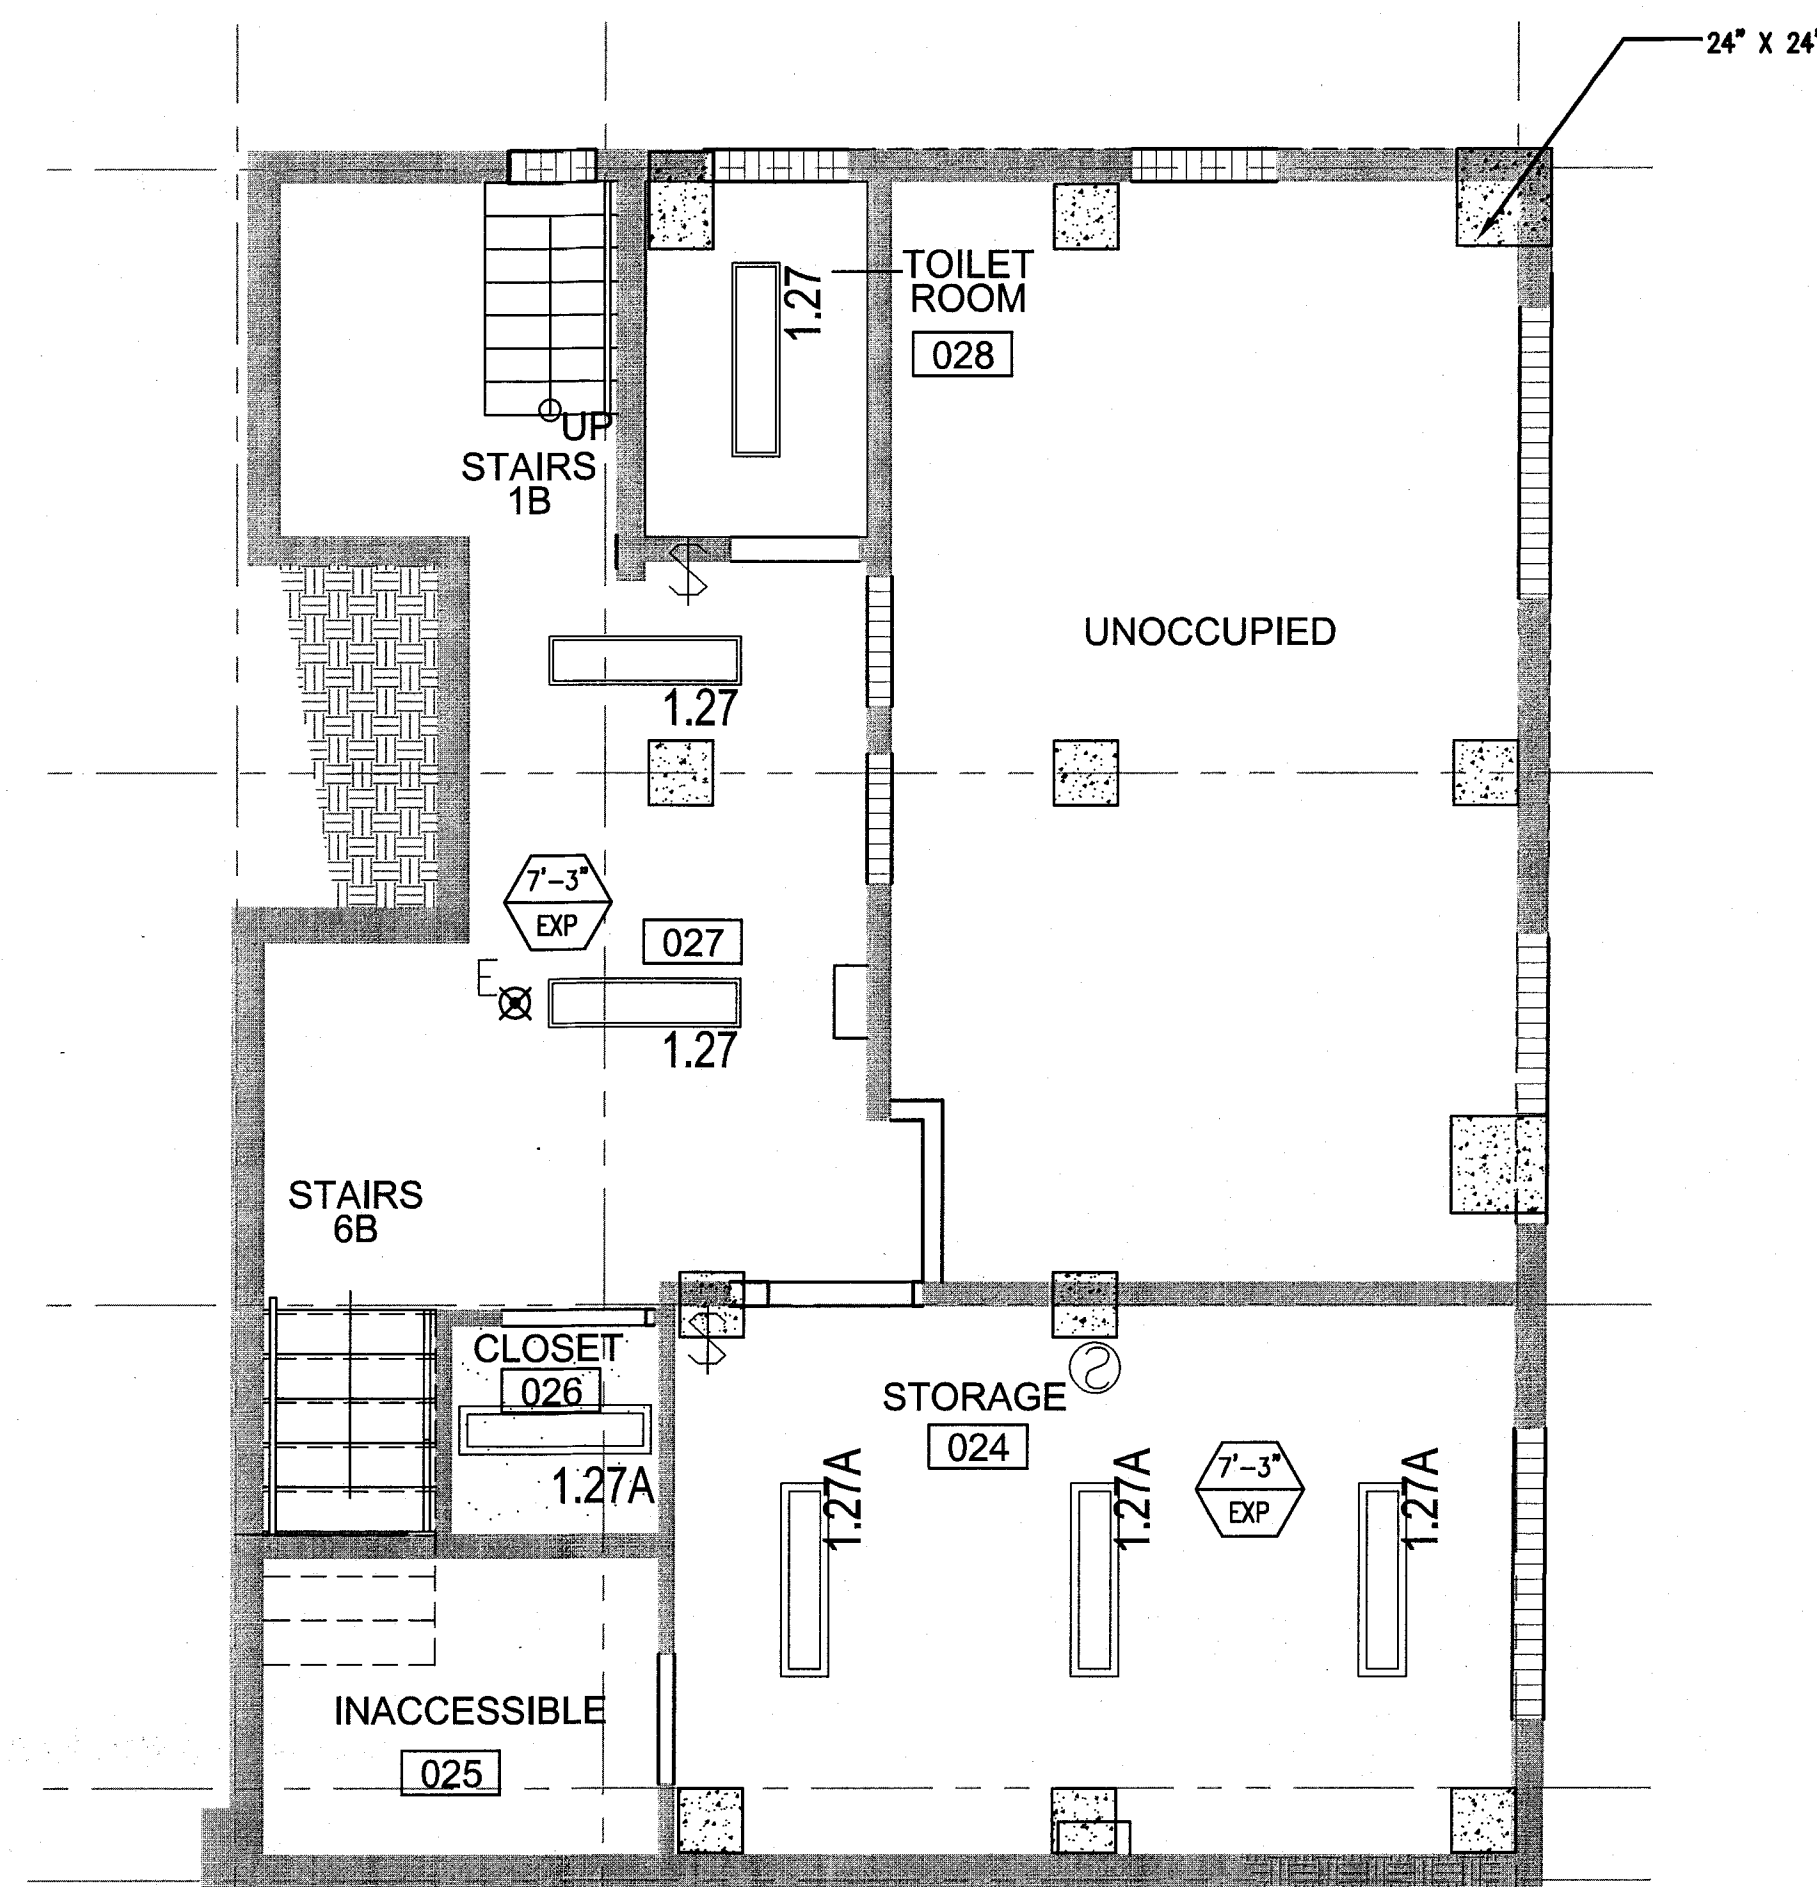

GENERAL NOTES

1. NOTIFY THE ARCHITECT OF ANY UNEXPECTED FIELD CONDITION OR ANY DISCREPANCY BEFORE PROCEEDING. GENERAL CONTRACTOR IS TO COORDINATE THE COMPLETE SCOPE OF WORK WITH CONSTRUCTION DOCUMENTS.
2. NO WORK SHALL BE DONE ON STRUCTURAL MEMBERS ARE TO BE MODIFIED, ALTERED OR CUT OUT WITH THE APPROVAL OF THE ARCHITECT AND BUILDING MANAGEMENT.
3. REVIEW BUILDING STANDARDS MANUAL PROVIDED BY THE BUILDING PROPERTY MANAGER BEFORE PROCEEDING WITH WORK. PROVIDE TEMPORARY SECURE ACCESS TO SPACE THROUGH CONSTRUCTION AND TEMPORARY LIGHT & POWER.
4. PROVIDE STRICT CONTROL OF JOB CLEANING AND PREVENT DUST AND DEBRIS FROM EMANATING FROM CONSTRUCTION AREA.
5. DEBRIS REMOVAL MUST BE DONE USING THE FREIGHT ELEVATOR. CONTACT BUILDING MANAGEMENT OFFICE TO OBTAIN SCHEDULE FOR USE OF FREIGHT ELEVATORS PRIOR TO SUBMITTING BID. ALL DEBRIS REMOVAL MUST BE PERFORMED IN ACCORDANCE WITH BUILDING MANAGEMENT REQUIREMENTS AND PROCEDURES. CONTRACTOR TO COORDINATE WITH BUILDING MANAGEMENT TO OBTAIN MOST RECENT REQUIREMENTS FOR DEBRIS REMOVAL.
6. CAP AND SHUT OFF ALL UNUSED UTILITIES PER CITY AND STATE REQUIREMENTS, WHERE REQUIRED.
7. FIRE ALARM DEVICES (SMOKE DETECTORS, HORNS, SIRENS AND EXISTING SMOKE DETECTORS) SHALL REMAIN CONNECTED TO EXISTING SYSTEMS. SECURE DEVICES AS NECESSARY TO KEEP FROM HANGING FREELY UPON REMOVAL OF WALLS+CEILINGS.
8. PROTECT ALL BASE BUILDING SERVICES, TYPICAL.
9. THIS PROJECT INVOLVES CONSTRUCTION INSIDE AN EXISTING STRUCTURE. CONTRACTORS, BY SUBMITTING A BID, ARE DEEMED TO BE COMPLETELY FAMILIAR WITH THE EXISTING CONDITION OF THE BUILDING AS IT INFLUENCES THE WORK DESCRIBED. ABSOLUTELY NO CLAIMS FOR EXTRA COMPENSATION WILL BE CONSIDERED FOR EXISTING CONDITIONS VISIBLE OR REASONABLY INFERRABLE FROM A CAREFUL EXAMINATION OF THE EXISTING BLDG.
10. ELECTRICAL DEVICES SHALL BE TERMINATED IN A SAFE AND PROPER MANNER BY A LICENSED PROFESSIONAL.
11. ALL MEP-PP DEVICES LOCATIONS NOT SHOWN ON DRAWINGS OR IN CONFLICT WITH MEP-PP DRAWINGS ARE TO BE COORDINATED WITH ARCHITECT PRIOR TO INSTALLATION.
12. SHUTDOWN OF EXISTING SYSTEMS FOR CONNECTION TO EXISTING SERVICES SHALL BE COORDINATED WITH THE CONTRACTOR. THE CONTRACTOR SHALL SUBMIT REQUESTS, WHERE THEY AFFECT THE OPERATION OF THE BUILDING SYSTEMS, AT LEAST ONE WEEK IN ADVANCE OF ANY REQUIRED SHUTDOWN. THE ACTUAL SHUTDOWN PERIOD SHALL BE AS SHORT AS POSSIBLE AND AT A TIME MUTUALLY AGREEABLE TO THE BUILDING OWNERS AND THE CONSTRUCTION MANAGER.
13. ALL WORK SHALL COMPLY WITH FEDERAL, STATE, AND LOCAL BUILDING CODES.
14. G.C. TO COORDINATE ALL AUDIO/VISUAL EQUIPMENT NEEDS WITH CLIENT.
15. BOTTOM OF ALL HANGING FIXTURES TO BE NO LOWER THAN 7'-0" AFF.
16. CONTRACTOR TO PROVIDE OVERLAY DRAWING OF ELECTRICAL FIXTURES, MECH. SYSTEMS AND COMPONENTS, LIFE SAFETY DEVICES, SMOKE DETECTORS, EMERGENCY LIGHTS AND ANY OTHER DEVICES IN CEILING TO ENSURE NO CONFLICTS.
17. SPRINKLER HEADS SHOWN FOR ARCHITECTURAL DESIGN INTENT ONLY. NOT FOR CODE DISTRIBUTION. SEE FIRE PROTECTION DRAWINGS FOR DISTRIBUTION AND CALCULATIONS.
18. CONTRACTOR WILL NOTIFY ARCHITECT IMMEDIATELY OF ANY CONFLICTS BETWEEN ARCHITECTURE AND ENGINEERING DRAWINGS.
19. THE CONTRACTOR SHALL INSPECT THE EXISTING FIELD CONDITIONS AT THE SITE PRIOR TO THE START OF ANY WORK TO DETERMINE WHAT EFFECT THE EXISTING CONDITIONS WILL HAVE ON HIS WORK. POTENTIAL PROBLEM AREAS SHALL BE BROUGHT TO THE ATTN. OF THE ARCHITECT AND/OR ENGINEER IMMEDIATELY.
20. REFER TO SHEETS E1.00 FOR ELECTRICAL DRAWINGS AND E1.01 SERIES FOR FIRE SPRINKLER DRAWINGS.

SHEET NOTES

1. ALL EXISTING GYPSON BOARD CEILINGS IN TO BE MAINTAINED AND RESTORED WHERE POSSIBLE. MINIMAL EXCAVATION FOR ADDITION OF NEW HANG GRILLES AND SUFFIT AREAS.
2. ALL EXISTING LIGHT FIXTURES IN HADDON HALL TO BE REMOVED AND REPLACED IN SAME LOCATION UNLESS OTHERWISE NOTED.
3. FOR HOTEL ROOMS ROPS REFER TO SHEETS A801-918.
4. FOR OUTDOOR AREA LIGHTING REFER TO LANDSCAPE PLANS.
5. EXISTING EXPOSED SPRINKLER PIPES IN HADDON HALL BUILDING TO BE COVERED WITH NEW PERIMETER SUFFIT AREA AT ALL CORRIDORS.
6. CENTER LIGHT FIXTURE IN SPACE U.O.N.
7. REFER TO A-281 FOR LIGHTING FIXTURE SCHEDULE.
8. J-BOX FOR FUTURE LED BACKLIGHT FOR TUBE SCREEN
9. COORDINATE LOCATION OF HANGING CHAIR WITH DESIGNER PRIOR TO INSTALLATION. ADDITIONAL GLASSING MAY BE REQUIRED.
10. ALL GENERAL CEILING AND SUFFIT TO BE PAINTED PT-07 (FLAT FINISH) U.O.N. ALL GUESTROOM AND PUBLIC RESTROOMS CEILING TO BE PAINTED PT-01 (EGGSHELL FINISH).
11. LED STRIP LIGHTING SHOWN ON PLAN WITH NOTE AS PLUG-IN RECEPTACLE AT ALL.
12. ALL LIGHT FIXTURES IN CAMPION APARTMENTS AND POOL SUITES TO BE NEW AND CENTERED IN SPACE U.O.N.
13. WALL SCONES SHOWN ON PLAN. ALL WALL SCONES IN HADDON HALL GUESTROOMS WILL REPLACE EXISTING IN SAME LOCATION. ALL SCONES IN CAMPION AND POOL SUITES NEW. REFER TO GUESTROOM ELEVATIONS FOR SCONES HEIGHT.
14. 1"x4" MOUNTED TO CEILING IN FRONT OF WINDOWS TO ACT AS VALANCE TO CONCEAL DRAPERY ROD. 1"x4" TO BE PAINTED PT-07. SIZES VARY, VERIFY IN FIELD.

LEGEND

- OMB CEILING/SUFFIT
- CEILING HEIGHT KEY
- CEILING TYPE
- CEILING HEIGHT - AFF
- 1" x 4" PENDANT
- DOWNLIGHT
- LED STRIP LIGHT
- EXTERIOR/DECORATIVE SCONCE
- PENDANT FIXTURE
- SURFACE MOUNTED FIXTURE
- WALL SCONCE
- EXISTING FIXTURE TO BE REPLACED WITH NEW
- EXISTING FIXTURE TO BE PATCHED AND REPAIR CEILING
- NEW LIGHT FIXTURE
- EXISTING CEILING MOUNTED SPRINKLER
- SMOKE DETECTOR WALL MOUNTED
- SMOKE DETECTOR CEILING MOUNTED
- SPRINKLER
- EXISTING WALL MOUNTED SPRINKLER
- REPLACE EXISTING FIXTURE WITH NEW LIGHT FIXTURE
- RETURN AIR GRILLE
- BATTERY POWERED WALL MOUNTED
- LINER OFFICER
- EXIT SIGN
- ARROWS INDICATE DIRECTION
- OCCUPANCY SENSOR

HADDON HALL
1500 COLLINS AVE
MIAMI BEACH, FL

KEYPLAN N.T.S.

REVISIONS		
NO.	DESCRIPTION	ISSUE DATE
10	MASTER PERMIT COMMENTS	07-03-2014

BUILDING	REVIEWER	DATE	REVIEWED
STRUCTURAL	EM	11-10-14	
MECHANICAL			
ELECTRICAL			
PLUMBING			
SITE CIVIL			

100% CONSTRUCTION DOCUMENT SET

NORTH	SEAL

ADD Inc Architecture Interiors Planning

One Biscayne Tower
Suite 1670
Two South
Biscayne Boulevard
Miami, FL 33131
T: 305.482.8700
F: 305.482.8770
www.addinc.com
Lic. # AA26001507

JOB NUMBER: 13036.00
CHECKED BY:
ISSUE DATE: FEBRUARY 18, 2014
SCALE: 1/4" = 1'-0"

SHEET TITLE

ENLARGED BASEMENT REFLECTED CEILING PLAN - HADDON HALL

SHEET NUMBER

A210


COPYRIGHT ADD INC 2011

1 ENLARGED BASEMENT REFLECTED CEILING PLAN/HADDON HALL
SCALE: 1/4" = 1'-0"

APPROVED
MIAMI BEACH
FIRE DEPARTMENT

HADDON HALL
1500 COLLINS AVE
MIAMI BEACH, FL


KEYPLAN N.T.S.

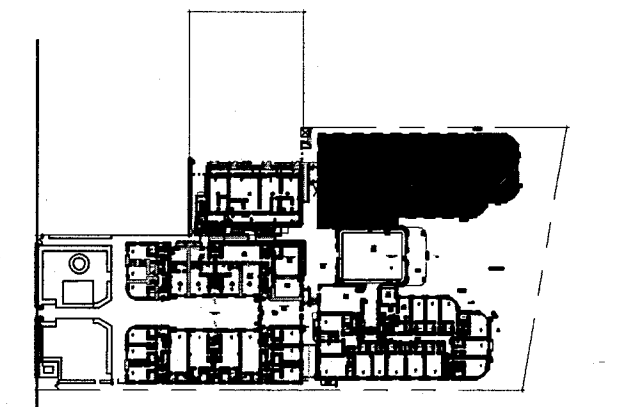

NO.	DESCRIPTION	ISSUE DATE
1	PROGRESS TO 100% CD	02-18-2014
2	MASTER PERMIT COMMENTS	07-03-2014
3	P&Z COMMENTS	07-14-2014

PRIVATE PROVIDER SERVICES, LLC			
Occupational Health, Safety, Inspection, Training & Scheduling			
BUILDING	REVIEWER INITIALS	DATE REVIEWED	
STRUCTURAL	EM	11-10-14	
MECHANICAL			
ELECTRICAL			
PLUMBING			
SITE CIVIL			

100% CONSTRUCTION
DOCUMENT SET

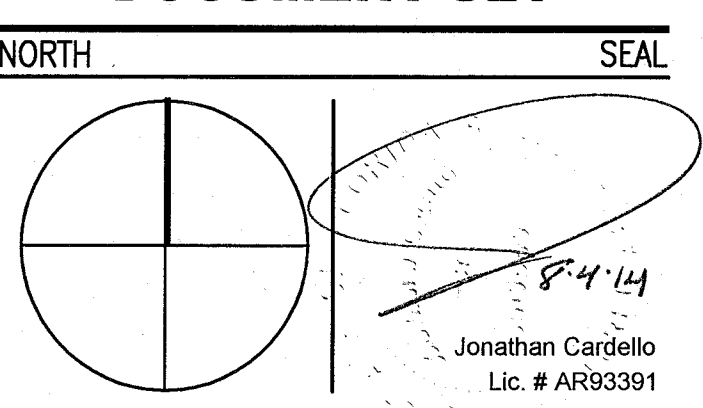

ADD Inc Architecture Interiors Planning

One Biscayne Tower
Suite 1670
Two South
Biscayne Boulevard
Miami, FL 33131
T. 305.482.8700
F. 305.482.8770
www.addinc.com
Lic. # AA26001507

JOB NUMBER: 13036.00
CHECKED BY:
ISSUE DATE: FEBRUARY 18, 2014
SCALE: 1/4" = 1'-0"

SHEET TITLE

ENLARGED PUBLIC
AREA/COURTYARD
CEILING PLAN
FIRST FLOOR

SHEET NUMBER

A211

COPYRIGHT ADD INC 2011

GENERAL NOTES

1. NOTIFY THE ARCHITECT OF ANY UNEXPECTED FIELD CONDITION OR ANY DISCREPANCY BEFORE PROCEEDING. GENERAL CONTRACTOR IS TO COORDINATE THE COMPLETE SCOPE OF WORK WITH CONSTRUCTION DOCUMENTS.
2. NO MAIN FRAMING OR STRUCTURAL MEMBERS ARE TO BE MOVED, ALTERED OR CUT WITH OUT THE APPROVAL OF THE ARCHITECT AND BUILDING DEPARTMENT.
3. REVIEW BUILDING STANDARD MANUAL PROVIDED BY THE BUILDING DEPARTMENT BEFORE PROCEEDING WITH WORK.
4. PROVIDE TEMPORARY SECURE ACCESS TO SPACE THROUGH CONSTRUCTION AND TEMPORARY LIGHT & POWER.
5. PROVIDE STRICT CONTROL OF JOB CLEANING AND PREVENT DIRT AND DEBRIS FROM EMANATING FROM CONSTRUCTION AREA.
6. DESER REMOVAL MUST BE DONE USING THE FREIGHT ELEVATOR. CONTACT BUILDING MANAGEMENT OFFICE TO OBTAIN SCHEDULE FOR USE OF FREIGHT ELEVATORS PRIOR TO SUBMITTING BID. ALL DESER REMOVAL MUST BE PERFORMED IN ACCORDANCE WITH BUILDING MANAGEMENT REQUIREMENTS AND PROCEDURES. CONTRACTOR TO COORDINATE WITH BUILDING MANAGEMENT TO OBTAIN MOST RECENT REQUIREMENTS FOR DESER REMOVAL.
7. CAP AND SHUT OFF ALL UNUSED UTILITIES PER CITY AND STATE REQUIREMENTS, WHERE REQUIRED.
8. FIRE ALARM DEVICES (SMOKE DETECTORS, HORNS, STROBES AND EXT. SIGNS) WITHIN DEMO SPACE SHALL REMAIN CONNECTED TO EXISTING SYSTEMS. SECURE DEVICES AS NECESSARY TO KEEP FROM HANGING FREELY UPON REMOVAL OF WALLS/CEILINGS.
9. PROTECT ALL BASE BUILDING SERVICES, TYPICAL.
10. ALL REQUIREMENTS FOR FIRE RATINGS TO BE MAINTAINED DURING CONSTRUCTION.
11. THIS PROJECT INVOLVES CONSTRUCTION INSIDE AN EXISTING STRUCTURE. CONTRACTORS, BY SUBMITTING A BID, ARE DEEMED TO BE COMPLETELY FAMILIAR WITH THE EXISTING CONDITION OF THE BUILDING AS IT INFLUENCES THE WORK REQUIRED. ABSOLUTELY NO CLAIMS FOR EXTRA COMPENSATION WILL BE CONSIDERED FOR EXISTING CONDITIONS VISIBLE OR REASONABLY INFERRABLE FROM A CAREFUL EXAMINATION OF THE EXISTING BLDG.
12. ELECTRICAL DEVICES SHALL BE TERMINATED IN A SAFE AND PROPER METHOD BY A LICENSED PROFESSIONAL.
13. ALL MEP-FP DEVICE LOCATIONS NOT SHOWN ON DRAWINGS OR IN CONFLICT WITH MEP-FP DRAWINGS, ARE TO BE COORDINATED WITH ARCHITECT PRIOR TO INSTALLATION.
14. SHUTDOWN OF EXISTING SYSTEMS FOR CONNECTION TO EXISTING SERVICES SHALL BE COORDINATED WITH THE CONSTRUCTION MANAGER AND BUILDING OWNER. THE CONTRACTOR SHALL SUBMIT REQUESTS, WHERE THEY AFFECT THE OPERATION OF THE BUILDING SYSTEMS, AT LEAST ONE WEEK IN ADVANCE OF ANY REQUIRED SHUTDOWN. THE ACTUAL SHUTDOWN PERIOD SHALL BE AS SHORT AS POSSIBLE AND AT A TIME MUTUALLY AGREEABLE TO THE BUILDING OWNER AND THE CONSTRUCTION MANAGER.
15. ALL WORK SHALL COMPLY WITH FEDERAL, STATE, AND LOCAL BUILDING CODES.
16. G.C. TO COORDINATE ALL AUDIO/VISUAL EQUIPMENT NEEDS WITH CLIENT.
17. BOTTOM OF ALL HANGING FIXTURES TO BE NO LOWER THAN 7'-0" AFF.
18. CONTRACTOR TO PROVIDE OVERLAY DRAWING OF ELECTRICAL, MECHANICAL SYSTEMS AND COMPONENTS, LIFE SAFETY DEVICES, SMOKE DETECTORS, EMERGENCY LIGHTS AND ANY OTHER DEVICES IN CEILING TO ENSURE NO CONFLICTS.
19. SPRINKLER HEADS SHOWN FOR ARCHITECTURAL DESIGN INTENT ONLY. NOT FOR CODE DISTRIBUTION. SEE FIRE PROTECTION DRAWINGS FOR DISTRIBUTION AND CALCULATIONS.
20. CONTRACTOR WILL NOTIFY ARCHITECT IMMEDIATELY OF ANY CONFLICTS BETWEEN ARCHITECTURE AND ENGINEERING DRAWINGS.
21. THE CONTRACTOR SHALL INSPECT THE EXISTING FIELD CONDITIONS AT THE SITE PRIOR TO THE START OF ANY WORK TO DETERMINE WHAT EFFECT THE EXISTING CONDITIONS WILL HAVE ON HIS WORK. PROBLEM AREAS SHALL BE BROUGHT TO THE ATTENTION OF THE ARCHITECT AND/OR ENGINEER IMMEDIATELY.
22. REFER TO SHEETS 11-00 FOR ELECTRICAL DRAWINGS AND 11-01 SERIES FOR FIRE SPRINKLER DRAWINGS.
23. ALL EXISTING GYPSUM BOARD CEILINGS IN TO BE MAINTAINED AND RESTORED WHERE POSSIBLE. MINIMAL DEMOLITION FOR ADDITION OF NEW HVAC GRILLES AND SUFFOCATED AREAS.
24. ALL EXISTING LIGHT FIXTURES IN HADDON HALL TO BE REMOVED AND REPLACED IN SAME LOCATION UNLESS OTHERWISE NOTED.
25. FOR HOTEL ROOMS REFER TO SHEETS A801-918.
26. FOR OUTDOOR AREA LIGHTING REFER TO LANDSCAPE PLANS.
27. EXISTING EXPOSED SPRINKLER PIPES IN HADDON HALL BUILDING TO BE COVERED WITH NEW PERIMETER SUFFIT AREA AT ALL CORRIDORS.
28. CENTER LIGHT FIXTURE IN SPACE U.O.N.
29. REFER TO A-281 FOR LIGHTING SCHEDULE.
30. 4-BAY FOR FUTURE LED BACKLIGHT FOR TUBE SCREEN

SHEET NOTES

1. ALL EXISTING GYPSUM BOARD CEILINGS IN TO BE MAINTAINED AND RESTORED WHERE POSSIBLE. MINIMAL DEMOLITION FOR ADDITION OF NEW HVAC GRILLES AND SUFFOCATED AREAS.
2. ALL EXISTING LIGHT FIXTURES IN HADDON HALL TO BE REMOVED AND REPLACED IN SAME LOCATION UNLESS OTHERWISE NOTED.
3. FOR HOTEL ROOMS REFER TO SHEETS A801-918.
4. FOR OUTDOOR AREA LIGHTING REFER TO LANDSCAPE PLANS.
5. EXISTING EXPOSED SPRINKLER PIPES IN HADDON HALL BUILDING TO BE COVERED WITH NEW PERIMETER SUFFIT AREA AT ALL CORRIDORS.
6. CENTER LIGHT FIXTURE IN SPACE U.O.N.
7. REFER TO A-281 FOR LIGHTING SCHEDULE.
8. 4-BAY FOR FUTURE LED BACKLIGHT FOR TUBE SCREEN
9. COORDINATE LOCATION OF HANGING CHAIR WITH DESIGNER PRIOR TO INSTALLATION. ADDITIONAL BRACING MAY BE REQUIRED.
10. ALL GENERAL CEILING AND SUFFIT TO BE PAINTED PT-07 (FLAT FINISH), U.O.N. ALL CEILINGTRIM AND PUBLIC RESTROOMS CEILING TO BE PAINTED PT-01 (EGG SHELL FINISH).
11. LED STRIP LIGHTING SHOWN ON PLAN WITH NOTE AS PLUG-IN RECEPTACLE AT ALL.
12. ALL LIGHT FIXTURES IN CAMPION APARTMENTS AND POOL SUITES TO BE NEW AND CENTERED IN SPACE U.O.N.
13. WALL SCONES SHOWN ON PLAN. ALL WALL SCONES IN HADDON HALL GUESTROOMS WILL REPLACE EXISTING IN SAME LOCATION. ALL SCONES IN CAMPION AND POOL SUITES NEW. REFER TO GUESTROOM ELEVATIONS FOR SCONES HEIGHT.
14. 17x4" MOUNTED TO CEILING IN FRONT OF WINDOWS TO ACT AS WAIVER TO CONCEAL DRUMPT ROD. 14x TO BE PAINTED PT-07. SIZES VARY, VERIFY IN FIELD.

LEGEND

- 1. GWS CEILING/SUFFIT
- 2. CEILING HEIGHT KEY
- 3. CEILING TYPE
- 4. CEILING HEIGHT
- 5. DOWNLIGHT
- 6. LED STRIP LIGHT
- 7. EXTERIOR/DECORATIVE SCONCE
- 8. PENDANT FIXTURE
- 9. SURFACE MOUNTED FIXTURE
- 10. WALL SCONCE
- 11. EXISTING FIXTURE TO BE REMOVED WITH NEW FIXTURE IN SAME LOCATION
- 12. DEMO FIXTURE - PATCH AND REPAIR CEILING
- 13. NEW LIGHT FIXTURE
- 14. DEMO LIGHT FIXTURE
- 15. BATTERY POWERED WALL MOUNTED LINEAR DIFFUSER
- 16. OCCUPANCY SENSOR
- 17. EXT. SIGN - WALL MOUNTED ARROWS INDICATE DIRECTION
- 18. SMOKE DETECTOR CEILING MOUNTED
- 19. SMOKE DETECTOR WALL MOUNTED
- 20. EXISTING CEILING MOUNTED SPRINKLER
- 21. SPRINKLER
- 22. EXISTING WALL MOUNTED SPRINKLER
- 23. SUPPLY DIFFUSER
- 24. RETURN AIR GRILLE
- 25. REPLACE EXISTING FIXTURE WITH NEW LIGHT FIXTURE JUNCTION BOX

1 ENLARGED HADDON HALL REFLECTED CEILING PLAN FIRST FLOOR- NORTH
SCALE: 1/4" = 1'-0"

GENERAL NOTES

1. NOTIFY THE ARCHITECT OF ANY UNEXPECTED FIELD CONDITION OR ANY DISCREPANCY BEFORE PROCEEDING. GENERAL CONTRACTOR IS TO COORDINATE THE COMPLETE SCOPE OF WORK WITH CONSTRUCTION DOCUMENTS.
2. NO MAIN FRAMING OR STRUCTURAL MEMBERS ARE TO BE MODIFIED, ALTERED OR CUT WITH OUT THE APPROVAL OF THE ARCHITECT AND BUILDING MANAGEMENT.
3. REVIEW BUILDING STANDARD MANUAL, PROVIDED BY THE BUILDING PROPERTY MANAGER BEFORE PROCEEDING WITH WORK.
4. PROVIDE TEMPORARY SECURE ACCESS TO SPACE THROUGH CONSTRUCTION AND TEMPORARY LIGHT & POWER.
5. PROVIDE STRICT CONTROL OF JOB CLEANING AND PREVENT DUST AND DEBRIS FROM DRAINING FROM CONSTRUCTION AREA.
6. DEBRIS REMOVAL MUST BE DONE USING THE FREIGHT ELEVATOR. CONTACT BUILDING MANAGEMENT OFFICE TO OBTAIN SCHEDULE FOR USE OF FREIGHT ELEVATORS PRIOR TO SUBMITTING BID. ALL DEBRIS REMOVAL MUST BE PERFORMED IN ACCORDANCE WITH BUILDING MANAGEMENT REQUIREMENTS AND PROCEDURES. CONTRACTOR TO COORDINATE WITH BUILDING MANAGEMENT TO OBTAIN MOST RECENT REQUIREMENTS FOR DEBRIS REMOVAL.
7. CAP AND SHUT OFF ALL UNUSED UTILITIES PER CITY AND STATE REQUIREMENTS, WHERE REQUIRED.
8. FIRE ALARM DEVICES (SMOKE DETECTORS, HORNS, STROBES AND EXT. SOUNDS) WITHIN COMMON SPACE SHALL REMAIN CONNECTED TO EXISTING SYSTEMS. SERVICE DEVICES AS NECESSARY TO KEEP FROM HANGING FREELY UPON REMOVAL OF WALLS/CEILING.
9. PROTECT ALL BASE BUILDING SERVICES, TYPICAL.
10. ALL REQUIREMENTS FOR FIRE RATINGS TO BE MAINTAINED DURING CONSTRUCTION.
11. THIS PROJECT INVOLVES CONSTRUCTION INSIDE AN EXISTING STRUCTURE. CONTRACTORS, BY SUBMITTING A BID, ARE DEEMED TO BE COMPLETELY FAMILIAR WITH THE EXISTING CONDITION OF THE BUILDING AS IT INFLUENCES THE WORK DESCRIBED. ABSOLUTELY NO CLAIMS FOR EXTRA COMPENSATION WILL BE CONSIDERED FOR EXISTING CONDITIONS UNLESS OR REASONABLY INFERRABLE FROM A CAREFUL EXAMINATION OF THE EXISTING BLDG.
12. ELECTRICAL DEVICES SHALL BE TERMINATED IN A SAFE AND PROPER METHOD BY A LICENSED PROFESSIONAL.
13. ALL MEP-FP DEVICE LOCATIONS NOT SHOWN ON DRAWINGS OR IN CONFLICT WITH MEP-FP DRAWINGS, ARE TO BE COORDINATED WITH ARCHITECT PRIOR TO INSTALLATION.
14. SHUTDOWN OF EXISTING SYSTEMS FOR CONNECTION TO EXISTING SERVICES SHALL BE COORDINATED WITH THE CONTRACTOR. THE CONTRACTOR SHALL, PRIOR TO ANY WORK, THEY AFFECT THE OPERATION OF THE BUILDING SYSTEMS, AT LEAST ONE WEEK IN ADVANCE, OF ANY REQUIRED SHUTDOWN. THE ACTUAL SHUTDOWN PERIOD SHALL BE AS SHORT AS POSSIBLE AND AT A TIME MUTUALLY AGREEABLE TO THE BUILDING OWNER AND THE CONTRACTOR MANAGER.
15. ALL WORK SHALL COMPLY WITH FEDERAL, STATE, AND LOCAL BUILDING CODES.
16. G.O. TO COORDINATE ALL AUDIO/VISUAL EQUIPMENT NEEDS WITH CLIENT.
17. BOTTOM OF ALL HANGING FIXTURES TO BE NO LOWER THAN 7'-0" AFF.
18. CONTRACTOR TO PROVIDE OVERLAY DRAWING OF ELECTRICAL, MECHANICAL, AND PLUMBING SYSTEMS AND COMPONENTS. LIFE SAFETY DEVICES, SMOKE DETECTORS, EMERGENCY LIGHTS AND ANY OTHER DEVICES IN CEILING TO ENSURE NO CONFLICTS.
19. SPRINKLER HEADS SHOWN FOR ARCHITECTURAL DESIGN INTENT ONLY. NOT FOR CODE DISTRIBUTION. SEE FIRE PROTECTION DRAWINGS FOR DISTRIBUTION AND CALCULATIONS.
20. CONTRACTOR WILL NOTIFY ARCHITECT IMMEDIATELY OF ANY CONFLICTS BETWEEN ARCHITECTURE AND ENGINEERING DRAWINGS.
21. THE CONTRACTOR SHALL INSPECT THE EXISTING FIELD CONDITIONS AT THE SITE PRIOR TO THE START OF ANY WORK TO DETERMINE WHAT EFFECT THE EXISTING CONDITIONS WILL HAVE ON THE WORK. POTENTIAL PROBLEM AREAS SHALL BE BROUGHT TO THE ATTN. OF THE ARCHITECT AND/OR ENGINEER IMMEDIATELY.
22. REFER TO SHEETS E1.01 FOR ELECTRICAL DRAWINGS AND P1.01 SERIES FOR FIRE SPRINGER DRAWINGS.

SHEET NOTES

1. ALL EXISTING Gypsum BOARD CEILING IN, TO BE MAINTAINED AND RESTORED WHERE POSSIBLE. MINIMAL DEMOLITION FOR ADDITION OF NEW HANGING GRILLES AND SPOFFED AREAS.
2. ALL EXISTING LIGHT FIXTURES IN HADDON HALL TO BE REMOVED AND REPLACED IN SAME LOCATION UNLESS OTHERWISE NOTED.
3. FOR OUTDOOR AREA LIGHTING REFER TO LANDSCAPE PLANS.
4. EXISTING HISTORIC SPOFFED AREAS IN HADDON HALL GROUND FLOOR COMMON AREA TO BE KEPT AND RESTORED.
5. EXISTING EXPOSED SPRINKLER PIPES IN HADDON HALL BUILDING TO BE COVERED WITH NEW FIBERGLASS SPOFFED AREA AT ALL CORRIDORS.
6. CENTER LIGHT FIXTURE IN SPACE U.O.N.
7. REFER TO A-281 FOR LIGHTING FIXTURE SCHEDULE.
8. J-BLOCK FOR FUTURE LED BACKLIGHT FOR TUBE SCREEN.
9. COORDINATE LOCATION OF HANGING CHAIR WITH DESIGNER PRIOR TO INSTALLATION. ADDITIONAL BUILDINGS MAY BE REQUIRED.
10. ALL GENERAL CEILING AND SPOFFS TO BE PAINTED PT-07 (FLAT FINISH), U.O.N. ALL CEILINGSTROM AND PUBLIC RESTROOMS CEILING TO BE PAINTED PT-01 (EGGSHELL FINISH) IN SPACE U.O.N.
11. ALL LIGHT FIXTURES IN COMMON AREAS AND POOL SUITES TO BE NEW AND COVERED IN SPACE U.O.N.
12. WALL SPOFFS SHOWN ON PLAN. ALL WALL CORNICES IN HADDON HALL GUESTROOMS WILL REPLACE EXISTING IN SAME LOCATION. ALL SPOFFS IN COMMON AND POOL SUITES NEW. REFER TO GUESTROOM ELEVATIONS FOR FINISHES.
13. 17x4" MOUNTED TO CEILING IN FRONT OF WINDOWS TO ACT AS VALANCE TO CONCEAL DRAPERY ROD. 14x4" TO BE PAINTED PT-01 SIZES WAY, VERIFY IN FIELD.

LEGEND

- CEILING HEIGHT KEY
- CEILING TYPE
- CEILING HEIGHT - AFF
- 1" X 4" PENDANT
- DOWNLIGHT
- LED STRIP LIGHT
- EXTERIOR/DECORATIVE SCIENCE
- PENDANT FIXTURE
- SURFACE MOUNTED FIXTURE
- WALL SPOFF
- EXISTING FIXTURE TO BE REPLACED WITH NEW FIXTURE IN SAME LOCATION
- NEW LIGHT FIXTURE
- DEMOW LIGHT FIXTURE
- BATTERY POWERED WALL MOUNTED
- LINEAR DIFFUSER
- OCCUPANCY SENSOR
- EXIT SIGN - WALL MOUNTED
- SMOKE DETECTOR CEILING MOUNTED
- SMOKE DETECTOR WALL MOUNTED
- EXISTING CEILING MOUNTED SPRINKLER
- NEW SPRINKLER
- EXISTING WALL MOUNTED SPRINKLER
- SUPPLY DIFFUSER
- RETURN AIR GRILLE
- REPLACE EXISTING FIXTURE WITH NEW LIGHT FIXTURE
- JUNCTION BOX

HADDON HALL
1500 COLLINS AVE
MIAMI BEACH, FL

KEYPLAN N.T.S.




REVISIONS

NO.	DESCRIPTION	ISSUE DATE
1	PROGRESS TO 100% CD	02-18-2014
2	MASTER PERMIT COMMENTS	07-03-2014

PRIVATE PROVIDER SERVICES, LLC			
REVIEWER INITIALS DATE REVIEWED			
BUILDING	EM	11-10-14	
STRUCTURAL			
MECHANICAL			
ELECTRICAL			
PLUMBING			
SITE CIVIL			

100% CONSTRUCTION DOCUMENT SET

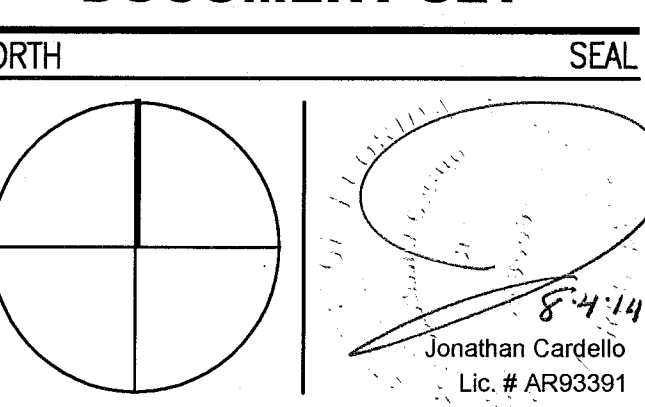

ADD Inc Architecture Interiors Planning

One Biscayne Tower
Suite 1670
Two South
Biscayne Boulevard
Miami, FL 33131
T. 305.482.8700
F. 305.482.8770
www.addinc.com
Lic. # AA26001507
Boston Miami

JOB NUMBER: 13036.00
CHECKED BY:
ISSUE DATE: FEBRUARY 18, 2014
SCALE: 1/4" = 1'-0"

SHEET TITLE

ENLARGED HADDON HALL REFLECTED CEILING PLAN FIRST FLOOR-NORTH

SHEET NUMBER

A211a1

APPROVED
MIAMI BEACH
FIRE DEPARTMENT

COPYRIGHT ADD INC 2011



1 ENLARGED HADDON HALL REFLECTED CEILING PLAN FIRST FLOOR- NORTH
SCALE: 1/4" = 1'-0"

GENERAL NOTES

1. NOTIFY THE ARCHITECT OF ANY UNEXPECTED FIELD CONDITION OR ANY DISCREPANCY BEFORE PROCEEDING. GENERAL CONTRACTOR IS TO COORDINATE THE COMPLETE SCOPE OF WORK WITH CONSTRUCTION DOCUMENTS.
2. NO NEW FRAMING OR CONSTRUCTION MEMBERS ARE TO BE MODIFIED, ALTERED OR CUT OUT WITH OUT THE APPROVAL OF THE ARCHITECT AND BUILDING MANAGEMENT.
3. REVIEW BUILDING STANDARD MANUAL PROVIDED BY THE BUILDING PROPERTY MANAGER BEFORE PROCEEDING WITH WORK. PROVIDE TEMPORARY SECURE ACCESS TO SPACE THROUGH CONSTRUCTION AND TEMPORARY LIGHT & POWER.
4. PROVIDE STRICT CONTROL OF JOB CLEANING AND PREVENT DIRT AND DEBRIS FROM CRAWLING FROM CONSTRUCTION AREA.
5. DEBRIS REMOVAL MUST BE DONE USING THE FREIGHT ELEVATOR. CONTACT BUILDING MANAGEMENT OFFICE TO OBTAIN SCHEDULE FOR USE OF FREIGHT ELEVATORS PRIOR TO SUBMITTING. E.D. ALL DEBRIS REMOVAL MUST BE PERFORMED IN ACCORDANCE WITH BUILDING MANAGEMENT REQUIREMENTS AND PROCEDURES. CONTRACTOR TO COORDINATE WITH BUILDING MANAGEMENT TO OBTAIN MOST RECENT REQUIREMENTS FOR DEBRIS REMOVAL.
7. CAP AND SHUT OFF ALL UNUSED UTILITIES PER CITY AND STATE REQUIREMENTS, WHERE REQUIRED.
8. FIRE ALARM DEVICES (SMOKE DETECTORS, HORNS, STROBES AND EXT. SIRS) WITH DEMO SPACE SHALL REMAIN CONNECTED TO EXISTING SYSTEM. SECURE DEVICES AS NECESSARY TO KEEP FROM HANGING FREELY UPON REMOVAL OF WALLS/CEILING.
9. PROTECT ALL BASE BUILDING SERVICES, TYPICAL.
10. ALL REQUIREMENTS FOR FIRE RATINGS TO BE MAINTAINED DURING CONSTRUCTION.
11. THIS PROJECT INVOLVES CONSTRUCTION INSIDE AN EXISTING STRUCTURE. CONTRACTORS, BY SUBMITTING A BID, ARE DEEMED TO BE COMPLETELY FAMILIAR WITH THE EXISTING CONDITION OF THE BUILDING AS IT INFLUENCES THE WORK DESCRIBED. ABSOLUTELY NO CLAIMS FOR EXTRA COMPENSATION WILL BE CONSIDERED FOR EXISTING CONDITIONS VISIBLE OR REASONABLY INFERRABLE FROM A CAREFUL EXAMINATION OF THE EXISTING BLDG.
12. ELECTRICAL DEVICES SHALL BE TERMINATED IN A SAFE AND PROPER METHOD BY A LICENSED PROFESSIONAL.
13. ALL MEP-PP DEVICES LOCATIONS NOT SHOWN ON DRAWINGS OR IN CONFLICT WITH MEP-PP DRAWINGS, ARE TO BE COORDINATED WITH ARCHITECT PRIOR TO INSTALLATION.
14. SHUTDOWN OF EXISTING SYSTEMS FOR CONNECTION TO EXISTING SERVICES SHALL BE COORDINATED WITH THE CONSTRUCTION MANAGER AND BUILDING OWNER. THEY AFFECT THE OPERATION OF THE BUILDING SYSTEMS. AT LEAST ONE WEEK IN ADVANCE OF ANY REQUIRED SHUTDOWN, THE ACTUAL SHUTDOWN PERIOD SHALL BE AS SHORT AS POSSIBLE AND AT A TIME MUTUALLY AGREEABLE TO THE BUILDING OWNER AND THE CONSTRUCTION MANAGER.
15. ALL WORK SHALL COMPLY WITH FEDERAL, STATE, AND LOCAL BUILDING CODES.
16. G.C. TO COORDINATE ALL AUDIO/VISUAL EQUIPMENT NEEDS WITH CLIENT.
17. BOTTOM OF ALL HANGING FIXTURES TO BE NO LOWER THAN 7'-0" AFF.
18. CONTRACTOR TO PROVIDE OVERLAY DRAWING OF ELECTRICAL, MECHANICAL, AND COMMUNICATIONS LIFE SAFETY DEVICES, SMOKE DETECTORS, EMERGENCY LIGHTS AND ANY OTHER DEVICES IN CEILING TO ENSURE NO CONFLICTS.
19. SPRINKLER HEADS SHOWN FOR ARCHITECTURAL DESIGN INTENT ONLY. NOT FOR CODE DISTRIBUTION. SEE FIRE PROTECTION DRAWINGS FOR DISTRIBUTION AND CALCULATIONS.
20. CONTRACTOR WILL NOTIFY ARCHITECT IMMEDIATELY OF ANY CONFLICTS BETWEEN ARCHITECTURE AND ENGINEERING DRAWINGS.
21. THE CONTRACTOR SHALL INSPECT THE EXISTING FIELD CONDITIONS AT THE SITE PRIOR TO THE START OF ANY WORK TO DETERMINE WHAT EFFECT THE EXISTING CONDITIONS WILL HAVE ON HIS WORK. POTENTIAL PROBLEM AREAS SHALL BE BROUGHT TO THE ATT. OF THE ARCHITECT AND/OR ENGINEER IMMEDIATELY.
22. REFER TO SHEETS E110 FOR ELECTRICAL DRAWINGS AND SERIES FOR FIRE SPRINKLER DRAWINGS.

SHEET NOTES

1. ALL EXISTING CHIPS/BOARD CEILING IN TO BE MAINTAINED AND RESTORED WHERE POSSIBLE. MINIMAL MODIFICATION FOR ADDITION OF NEW HANGING CEILING AND SOFFIT AREAS.
2. FOR HOTEL ROOMS ROPS REFER TO SHEETS A001-918.
3. FOR OUTDOOR AREA LIGHTING REFER TO LANDSCAPE PLANS.
4. EXISTING HISTORIC SOTTI AREAS IN HADDON HALL GROUND FLOOR COMMON AREA TO BE KEPT AND RESTORED.
5. EXISTING EXPOSED SPRINKLER PIPES IN HADDON HALL BUILDING TO BE COVERED WITH NEW PERIMETER SOFFIT AREA AT ALL CORRIDORS.
6. CENTER LIGHT FIXTURE IN SPACE U.O.N.
7. REFER TO A-281 FOR LIGHTING FIXTURE SCHEDULE.
8. J-BOX FOR FUTURE LED BACKLIGHT FOR TUBE SCREEN.
9. COORDINATE LOCATION OF HANGING CHAIR WITH DESIGNER PRIOR TO INSTALLATION. ADDITIONAL BLOCKING MAY BE REQUIRED.
10. ALL GENERAL CEILING AND SOFFIT TO BE PAINTED PT-07 (FLAT FINISH), U.S.A. ALL GUESTROOM AND PUBLIC RESTROOMS CEILING TO BE PAINTED PT-01 (EGGSHELL FINISH).
11. LED STRIP LIGHTING SHOWN ON PLAN WITH NOTE AS PLUS-IN RECEPTACLE AT ALL.
12. ALL LIGHT FIXTURES IN CORRIDOR, HALLWAYS AND POOL SUITES TO BE NEW AND CENTERED IN SPACE U.O.N.
13. WALL SOCKETS SHOWN ON PLAN. ALL WALL SOCKETS IN HADDON HALL GUESTROOMS WILL REPLACE EXISTING IN SAME LOCATION. ALL SOCKETS IN CORRIDOR AND POOL SUITES NEW. REFER TO GUESTROOM ELEVATIONS FOR SOCKET PLACES.
14. 12"X4" MOUNTED TO CEILING IN FRONT OF WINDOWS TO ACT AS VALANCE TO CONCEAL COUNTRY ROD. U.S.A. TO BE PAINTED PT-07. SIZES VARY, VARY IN FIELD.

LEGEND


- 1. GWS CEILING/SOFT
- 2. CEILING HEIGHT KEY
- 3. CEILING TYPE
- 4. CEILING HEIGHT - AFF
- 5. 1" X 4" PENDANT
- 6. DOWNLIGHT
- 7. LED STRIP LIGHT
- 8. EXTERIOR/DECORATIVE SCONCE
- 9. PENDANT FIXTURE
- 10. SURFACE MOUNTED FIXTURE
- 11. WALL SCONCE
- 12. EXISTING FIXTURE TO BE REPLACED WITH NEW FIXTURE IN SAME LOCATION
- 13. DEMO FIXTURE - PATCH AND REPAIR CEILING
- 14. NEW LIGHT FIXTURE
- 15. DEMO LIGHT FIXTURE
- 16. BATTERY POWERED WALL MOUNTED
- 17. LINEAR DIFFUSER
- 18. EXIT SIGN
- 19. EXIT SIGN - WALL MOUNTED
- 20. SMOKE DETECTOR CEILING MOUNTED
- 21. SMOKE DETECTOR WALL MOUNTED
- 22. SPRINKLER
- 23. EXISTING WALL MOUNTED SPRINKLER
- 24. SUPPLY DIFFUSER
- 25. RETURN AIR GRILLE
- 26. REPLACE EXISTING FIXTURE WITH NEW LIGHT FIXTURE
- 27. JUNCTION BOX

NOTE: CEILING AT EXISTING HADDON HALL GUESTROOMS ARE EXISTING TO REMAIN AT 9'-0" A.F.F. UNLESS OTHERWISE NOTED



HADDON HALL
1500 COLLINS AVE
MIAMI BEACH, FL


KEYPLAN N.T.S.

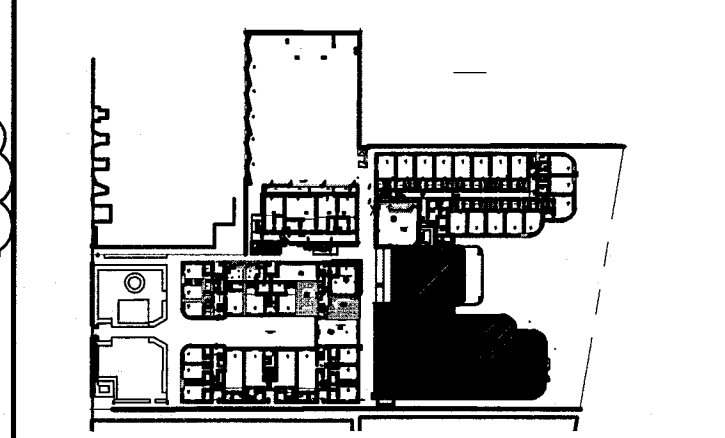

REVISIONS		
NO.	DESCRIPTION	ISSUE DATE
1	PROGRESS TO 100% CD	02-18-2014
2	FIRE REVIEW COMMENTS	04-09-2014
3	MASTER PERMIT COMMENTS	07-03-2014

MTCI PRIVATE PROVIDER SERVICES, LLC			
Construction Plans, Drawings, Inspection, Testing & Consulting			
BUILDING	REVIEWER	DATE	REVIEWED
STRUCTURAL	EM	11-10-14	
MECHANICAL			
ELECTRICAL			
PLUMBING			
SITE/CIVIL			

100% CONSTRUCTION DOCUMENT SET

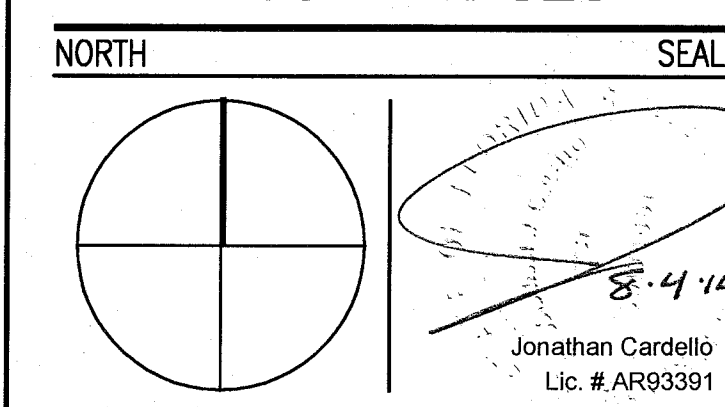

ADD Inc Architecture Interiors Planning
One Biscayne Tower
Suite 1670
Two South
Biscayne Boulevard
Miami, FL 33131
T. 305.482.8700
F. 305.482.8770
www.addinc.com
Lic. # AA28001507

JOB NUMBER: 13036.00
CHECKED BY:
ISSUE DATE: FEBRUARY 18, 2014
SCALE: 1/4" = 1'-0"

SHEET TITLE

ENLARGED HADDON HALL REFLECTED CEILING PLAN
FIRST FLOOR - SOUTH

SHEET NUMBER

A211a2


COPYRIGHT ADD INC 2011

1 ENLARGED HADDON HALL REFLECTED CEILING PLAN FIRST FLOOR- SOUTH
SCALE: 1/4" = 1'-0"

APPROVED
MIAMI BEACH
FIRE DEPARTMENT

HADDON HALL
1500 COLLINS AVE
MIAMI BEACH, FL


KEYPLAN N.T.S.

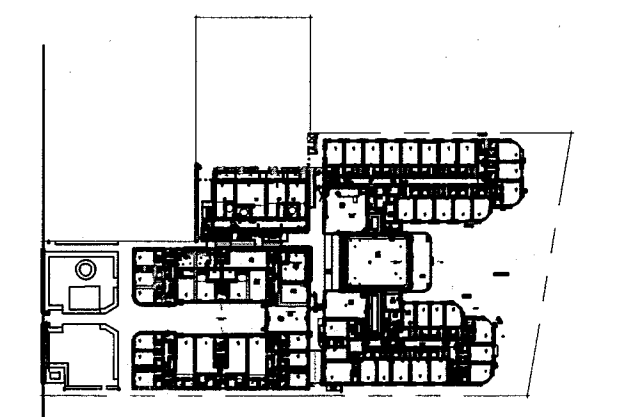

NO.	DESCRIPTION	ISSUE DATE
1	PROGRESS TO 100% CD	02-18-2014
2	PERMIT REVIEW COMMENTS	03-14-2014
3	KITCHEN REINFORCEMENT	05-30-2014
4	MASTER PERMIT COMMENTS	07-03-2014

PRIVATE PROVIDER SERVICES, LLC			
Construction Plans, Specifications, and Schedules			
BUILDING	REVIEWER INITIALS	DATE REVIEWED	
STRUCTURAL	RM	11-12-14	
MECHANICAL			
ELECTRICAL			
PLUMBING			
SITE CIVIL			

100% CONSTRUCTION
DOCUMENT SET

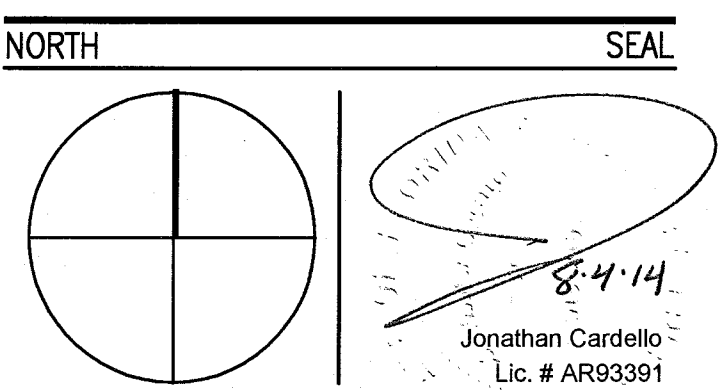

ADD Inc Architecture Interiors Planning

One Biscayne Tower
Suite 1670
Two South
Biscayne Boulevard
Miami, FL 33131
T. 305.482.8700
F. 305.482.8770
www.addinc.com
Lic. # AA26001507

JOB NUMBER: 13036.00
CHECKED BY:
ISSUE DATE: FEBRUARY 18, 2014
SCALE: 1/4" = 1'-0"

SHEET TITLE

ENLARGED CAMPTON
APT. REFLECTED
CEILING PLAN -
FIRST FLOOR

SHEET NUMBER

A211b

COPYRIGHT ADD INC 2011

GENERAL NOTES


- NOTIFY THE ARCHITECT OF ANY UNEXPECTED FIELD CONDITION OR ANY DISCREPANCY BEFORE PROCEEDING. GENERAL CONTRACTOR IS TO COORDINATE THE COMPLETE SCOPE OF WORK WITH CONSTRUCTION DOCUMENTS.
- NO MAN TOWNS OR STRUCTURAL MEMBERS ARE TO BE MOVED, ALTERED OR CUT WITH OUT THE APPROVAL OF THE ARCHITECT AND BUILDING DEPARTMENT.
- REVIEW BUILDING STANDARDS MANUAL, PROVIDED BY THE BUILDING DEPARTMENT BEFORE PROCEEDING WITH WORK.
- PROVIDE TEMPORARY SECURE ACCESS TO SPACE THROUGH CONSTRUCTION AND TEMPORARY LIGHT & POWER.
- PROVIDE STRICT CONTROL OF JOB CLEANING AND PREVENT DUST AND DEBRIS FROM SPREADING FROM CONSTRUCTION AREA.
- DEBRIS REMOVAL MUST BE DONE USING THE FREIGHT ELEVATORS. CONTACT BUILDING MANAGEMENT OFFICE TO OBTAIN SCHEDULE FOR USE OF FREIGHT ELEVATORS PRIOR TO SUBMITTING BID. ALL DEBRIS REMOVAL MUST BE PERFORMED IN ACCORDANCE WITH BUILDING MANAGEMENT REQUIREMENTS AND PROCEDURES. CONTRACTOR TO COORDINATE WITH BUILDING MANAGEMENT TO OBTAIN MOST RECENT REQUIREMENTS FOR DEBRIS REMOVAL.
- CAP AND SHUT OFF ALL UNUSED UTILITIES PER CITY AND STATE REQUIREMENTS, WHERE REQUIRED.
- FIRE ALARM DEVICES (SMOKE DETECTORS, HORNS, STROBES AND EXIT SIGNS) WITHIN COMMON SPACE SHALL REMAIN CONNECTED TO EXISTING SYSTEMS. SECURE DEVICES AS NECESSARY TO KEEP FROM HANGING FREELY UPON REMOVAL OF WALLS/CEILINGS.
- PROTECT ALL BASE BUILDING SERVICES, TYPICAL.
- ALL REQUIREMENTS FOR FIRE RATINGS TO BE MAINTAINED DURING CONSTRUCTION.
- THIS PROJECT INVOLVES CONSTRUCTION INSIDE AN EXISTING STRUCTURE. CONTRACTORS, BY SUBMITTING A BID, ARE DEEMED TO BE COMPLETELY FAMILIAR WITH THE EXISTING CONDITION OF THE BUILDING AS IT INFLUENCES THE WORK DESCRIBED. ABSOLUTELY NO CLAIMS FOR EXTRA COMPENSATION WILL BE CONSIDERED FOR EXISTING CONDITIONS VISIBLY OR REASONABLY VISIBLE FROM A CAREFUL EXAMINATION OF THE EXISTING BLDG.
- ELECTRICAL DEVICES SHALL BE TERMINATED IN A SAFE AND PROPER MANNER BY A LICENSED PROFESSIONAL.
- ALL MEP-FP DEVICE LOCATIONS NOT SHOWN ON DRAWINGS OR IN CONFLICT WITH MEP-FP DRAWINGS, ARE TO BE COORDINATED WITH ARCHITECT PRIOR TO INSTALLATION.
- SHUTDOWN OF EXISTING SYSTEMS FOR CONNECTION TO EXISTING SERVICES SHALL BE COORDINATED WITH THE CONTRACTOR MANAGER AND BUILDING OWNER. THEY AFFECT THE OPERATION OF THE BUILDING SYSTEMS, AS SUCH, ONE WEEK IN ADVANCE OF ANY REQUIRED SHUTDOWN. THE ACTUAL SHUTDOWN PERIOD SHALL BE AS SHORT AS POSSIBLE AND AT A TIME MUTUALLY AGREEABLE TO THE BUILDING OWNER AND THE CONTRACTOR MANAGER.
- ALL WORK SHALL COMPLY WITH FEDERAL, STATE, AND LOCAL BUILDING CODES.
- G.O. TO COORDINATE ALL AUDIO/VISUAL EQUIPMENT NEEDS WITH CLIENT.
- BOTTOM OF ALL HANGING FIXTURES TO BE NO LOWER THAN 7'-0" AFF.

SHEET NOTES

- ALL EXISTING GYPSUM BOARD CEILINGS IN TO BE MAINTAINED AND RESTORED WHERE POSSIBLE. MINIMAL EXCAVATION FOR ADDITION OF NEW HVAC GRILLES AND SUFFICIENT AREAS.
- ALL EXISTING LIGHT FIXTURES IN HADDON HALL TO BE REMOVED AND REPLACED IN SAME LOCATION UNLESS OTHERWISE NOTED.
- FOR HOTEL ROOMS ROPS REFER TO SHEETS A001-918.
- FOR OUTDOOR AREA LIGHTING REFER TO LANDSCAPE PLANS.
- EXISTING EXPOSED SPRINKLER PIPES IN HADDON HALL GROUND FLOOR COMMON AREA TO BE KEPT AND REPAIRED.
- EXISTING EXPOSED SPRINKLER PIPES IN HADDON HALL GROUND FLOOR COMMON AREA TO BE KEPT AND REPAIRED.
- REFER TO A-281 FOR LIGHTING FIXTURE SCHEDULE.
- 4-BOR FOR FUTURE LED BACKLIGHT FOR TUBE SCREEN.
- COORDINATE LOCATION OF HANGING CHAIR WITH DESIGNER PRIOR TO INSTALLATION. ADDITIONAL BLOOMS MAY BE REQUIRED.
- ALL GENERAL CEILING AND SOFFIT TO BE PAINTED PF-07 (FLAT FINISH), U.O.N. ALL GYMSTROOM AND PUBLIC RESTROOMS CEILING TO BE PAINTED PF-01 (EGGSHALL FINISH).
- LED STRIP LIGHTING SHOWN ON PLAN WITH NOTE AS FLOOR-IN RECEPTACLE AT ALL LOCATIONS. LED STRIP LIGHTING TO BE NEW AND CENTERED IN SPACE U.O.N.
- WALL SCONES SHOWN ON PLAN. ALL WALL SCONES IN HADDON HALL GYMSTROOMS WILL REPLACE EXISTING IN SAME LOCATION. ALL SCONES IN CAMPTON AND POOL SUITES NEW. REFER TO GYMSTROOM ELEVATIONS FOR SCONES.
- 174" MOUNTED TO CEILING IN FRONT OF WORKERS TO ACT AS VALANCE TO CONCEAL DRUMPT ROD. 114" TO BE PAINTED PF-07. SIZES VARY, VERIFY IN FIELD.

LEGEND

- GWB CEILING/SOFFIT
- CEILING HEIGHT KEY
- CEILING TYPE
- 1' x 4' PENDANT
- DOWNLIGHT
- LED STRIP LIGHT
- EXTERIOR/DECORATIVE SCONCE
- PENDANT FIXTURE
- SURFACE MOUNTED FIXTURE
- EXISTING FIXTURE TO BE REPAIRED WITH NEW FIXTURE IN SAME LOCATION
- REMOVAL OF EXISTING FIXTURE
- NEW LIGHT FIXTURE
- DOWNDOWN LIGHT FIXTURE
- BATTERY POWERED WALL MOUNTED
- LINEAR DIFFUSER
- OCCUPANCY SENSOR
- EXIT SIGN - ARROWS INDICATE DIRECTION
- EXIT SIGN - WALL MOUNTED
- SMOKE DETECTOR CEILING MOUNTED
- SMOKE DETECTOR WALL MOUNTED
- EXISTING CEILING MOUNTED SPRINKLER
- EXISTING WALL MOUNTED SPRINKLER
- RETURN AIR GRILLE
- REPLACE EXISTING FIXTURE WITH NEW LIGHT FIXTURE
- JUNCTION BOX

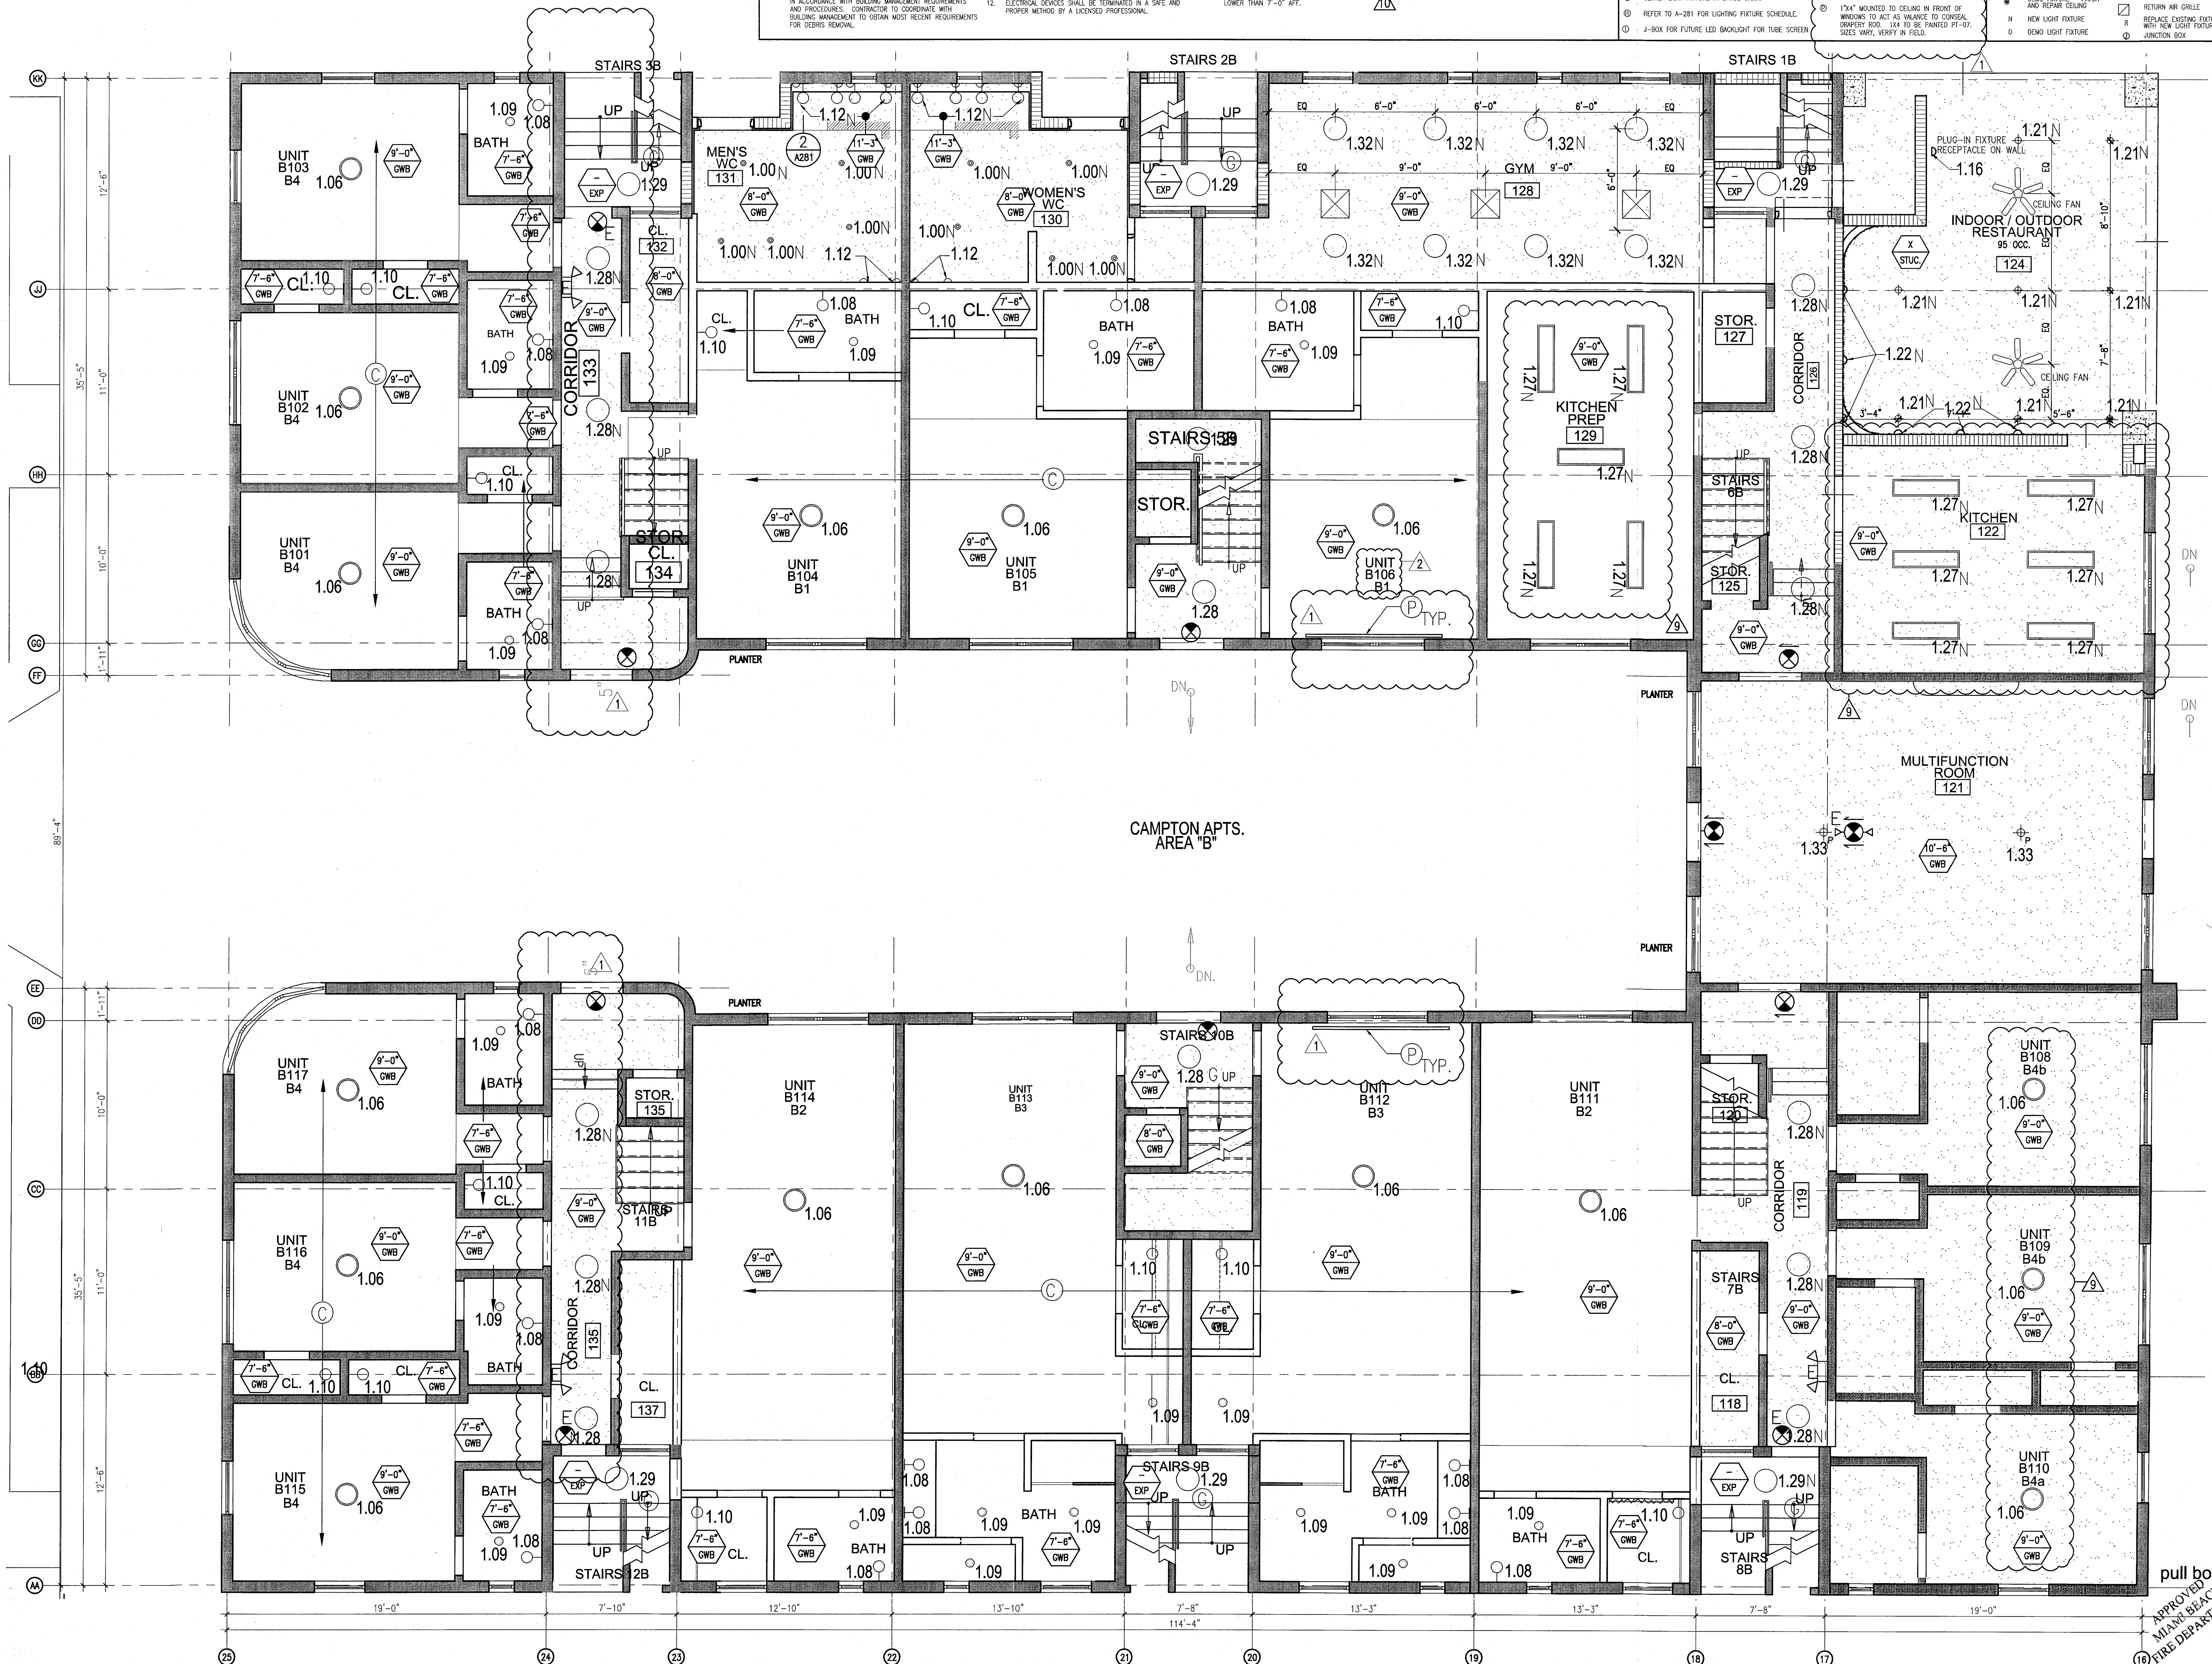

1 ENLARGED CAMPTON APARTMENTS REFLECTED CEILING PLAN - FIRST FLOOR

SCALE: 1/4" = 1'-0"

GENERAL NOTES

1. NOTIFY THE ARCHITECT OF ANY UNEXPECTED FIELD CONDITION OR ANY DISCREPANCY BEFORE PROCEEDING. ELECTRICAL CONSTRUCTION IS TO COORDINATE THE COMPLETE SCOPE OF WORK WITH CONSTRUCTION DOCUMENTS.
2. NO MAIN FRAMING OR STRUCTURAL MEMBERS ARE TO BE MOVED, ALTERED OR CUT WITH OUT THE APPROVAL OF THE ARCHITECT AND BUILDING MANAGEMENT.
3. REVIEW BUILDING STANDARD MANUAL PROVIDED BY THE BUILDING PROPERTY MANAGER BEFORE PROCEEDING WITH WORK.
4. PROVIDE TEMPORARY SECURE ACCESS TO SPACE THROUGH CONSTRUCTION AND TEMPORARY LIGHT & POWER.
5. PROVIDE STRICT CONTROL OF JOB CLEANING AND PREVENT DIRT AND DEBRIS FROM CRAWLING FROM CONSTRUCTION AREA.
6. DEBRIS REMOVAL MUST BE DONE USING THE FREIGHT ELEVATOR. CONTACT BUILDING MANAGEMENT OFFICE TO OBTAIN SCHEDULE FOR USE OF FREIGHT ELEVATORS PRIOR TO SUBMITTING BID. ALL DEBRIS REMOVAL MUST BE PERFORMED IN ACCORDANCE WITH BUILDING MANAGEMENT REQUIREMENTS AND PROCEDURES. CONTRACTOR TO COORDINATE WITH BUILDING MANAGEMENT TO OBTAIN MOST RECENT REQUIREMENTS FOR DEBRIS REMOVAL.
7. CAP AND SHUT OFF ALL UNUSED UTILITIES PER CITY AND STATE REQUIREMENTS, WHERE REQUIRED.
8. FIRE ALARM DEVICES (SMOKE DETECTORS, HORNS, SIRENS AND EXT. SONS) WITHIN DEMO SPACE SHALL REMAIN CONNECTED TO EXISTING SYSTEMS. SECURE DEVICES AS NECESSARY TO KEEP FROM HANGING FREELY UPON REMOVAL OF WALLS+CEILING.
9. PROTECT ALL BASE BUILDING SERVICES, TYPICAL.
10. ALL REQUIREMENTS FOR FIRE RATINGS TO BE MAINTAINED DURING CONSTRUCTION.
11. THIS PROJECT INVOLVES CONSTRUCTION INSIDE AN EXISTING STRUCTURE. CONTRACTORS, BY SUBMITTING A BID, ARE DEEMED TO BE COMPLETELY FAMILIAR WITH THE EXISTING CONDITION OF THE BUILDING AS IT INFLUENCES THE WORK DESCRIBED. ABSOLUTELY NO CLAIM FOR EXTRA COMPENSATION WILL BE CONSIDERED FOR EXISTING CONDITIONS VISIBLE OR REASONABLY INFERRABLE FROM A CAREFUL EXAMINATION OF THE EXISTING BLDG.
12. ELECTRICAL DEVICES SHALL BE TERMINATED IN A SAFE AND PROPER METHOD BY A LICENSED PROFESSIONAL.
13. ALL MEP-FP DEVICE LOCATIONS NOT SHOWN ON DRAWINGS OR IN CONFLICT WITH MEP-FP DRAWINGS, ARE TO BE COORDINATED WITH ARCHITECT PRIOR TO INSTALLATION.
14. SHUTDOWN OF EXISTING SYSTEMS FOR CONNECTION TO EXISTING SERVICES SHALL BE COORDINATED WITH THE CONSTRUCTION MANAGER AND BUILDING OWNER. THE CONTRACTOR SHALL SUBMIT REQUESTS, WHERE THEY AFFECT THE OPERATION OF THE BUILDING SYSTEMS, AT LEAST ONE WEEK IN ADVANCE OF ANY REQUIRED SHUTDOWN. THE ACTUAL SHUTDOWN PERIOD SHALL BE AS SHORT AS POSSIBLE AND AT A TIME MUTUALLY AGREEABLE TO THE BUILDING OWNER AND THE CONSTRUCTION MANAGER.
15. ALL WORK SHALL COMPLY WITH FEDERAL STATE, AND LOCAL BUILDING CODES.
16. C.G. TO COORDINATE ALL AUDIO/VISUAL EQUIPMENT NEEDS WITH CLIENT.
17. BOTTOM OF ALL HANGING FIXTURES TO BE NO LOWER THAN 7'-0" AFF.
18. CONTRACTOR TO PROVIDE OVERLAY DRAWING OF ELECTRICAL FIXTURES, MEDIA SYSTEMS AND COMPONENTS, LIFE SAFETY DEVICES, SMOKE DETECTORS, EMERGENCY LIGHTS AND ANY OTHER DEVICES IN CEILING TO ENSURE NO CONFLICTS.
19. SPRINKLER HEADS SHOWN FOR ARCHITECTURAL DESIGN INTENT ONLY. NOT FOR CODE DISTRIBUTION. SEE FIRE PROTECTION DRAWINGS FOR DISTRIBUTION AND CALCULATIONS.
20. CONTRACTOR WILL NOTIFY ARCHITECT IMMEDIATELY OF ANY CONFLICTS BETWEEN ARCHITECTURE AND ENGINEERING DRAWINGS.
21. THE CONTRACTOR SHALL INSPECT THE EXISTING FIELD CONDITIONS AT THE SITE PRIOR TO THE START OF ANY WORK TO DETERMINE WHAT EFFECT THE EXISTING CONDITIONS WILL HAVE ON HIS WORK. POTENTIAL PROBLEM AREAS SHALL BE BROUGHT TO THE ATTN. OF THE ARCHITECT AND/OR ENGINEER IMMEDIATELY.
22. REFER TO SHEETS E1.00 FOR ELECTRICAL DRAWINGS AND F1.00 SERIES FOR FIRE SPRINKLER DRAWINGS.

SHEET NOTES


1. ALL EXISTING GYPSUM BOARD CEILING IN TO BE MAINTAINED AND RESTORED WHERE POSSIBLE. MINIMAL CEILING FLOOR RESTORATION OF NEW HANG GRILLES AND SUFFIT AREAS.
2. ALL EXISTING LIGHT FIXTURES IN HADDON HALL TO BE REMOVED AND REPLACED IN SAME LOCATION UNLESS OTHERWISE NOTED.
3. FOR HOTEL ROOMS ROPS REFER TO SHEETS A001-018.
4. FOR OUTDOOR AREA LIGHTING REFER TO LANDSCAPE PLANS.
5. EXISTING EXPOSED SPRINKLER PIPES IN HADDON HALL BUILDING TO BE CONCEALED WITH NEW PERIMETER SUFFIT AREA AT ALL CORRIDORS.
6. CENTER LIGHT FIXTURE IN SPACE U.O.N.
7. REFER TO A-281 FOR LIGHTING FIXTURE SCHEDULE.
8. J-BOX FOR FUTURE LED BACKLIGHT FOR TUBE SCREEN.
9. COORDINATE LOCATION OF HANGING CHAIR WITH DESIGNED PRIOR TO INSTALLATION. ADDITIONAL BLOCKING MAY BE REQUIRED.
10. ALL GENERAL CEILING AND SUFFIT TO BE PAINTED PT-02 (FLAT FINISH), U.O.N. ALL CEILING AND PUBLIC RESTROOMS CEILING TO BE PAINTED PT-03 (EGG SHELL FINISH).
11. LED STRIP LIGHTING SHOWN ON PLAN WITH NOTE AS PLUG-IN RECEPTACLE AT ALL.
12. ALL LIGHT FIXTURES IN CAMPHAN APARTMENTS WILL REPLACE EXISTING IN SAME LOCATION. ALL SMOKE DETECTORS IN CAMPHAN AND POOL SUITES NEW REFER TO QUESTROOM ELEVATIONS FOR SPACE U.O.N.
13. WALL SCONCES SHOWN ON PLAN. ALL WALL SCONCES IN HADDON HALL QUESTROOMS WILL REPLACE EXISTING IN SAME LOCATION. ALL SCONCES IN CAMPHAN AND POOL SUITES NEW REFER TO QUESTROOM ELEVATIONS FOR SPACE U.O.N.
14. 174" MOUNTED TO CEILING IN FRONT OF WINDOWS TO ACT AS VALANCE TO CONCEAL WINDOW ROD. JAX TO BE PAINTED PT-02. SIZES VARY, VERIFY IN FIELD.

LEGEND

- 1. GNB CEILING/SUFFIT
- 2. CEILING HEIGHT KEY
- 3. CEILING TYPE
- 4. CEILING HEIGHT - AFF
- 5. 1" x 4" PENDANT
- 6. DOWNLIGHT
- 7. LED STRIP LIGHT
- 8. EXTERIOR/DECORATIVE SCONCE
- 9. PENDANT FIXTURE
- 10. SURFACE MOUNTED FIXTURE
- 11. WALL SCONCE
- 12. EXISTING FIXTURE TO BE REPLACED WITH NEW FIXTURE IN SAME LOCATION
- 13. DEMO FIXTURE - PATCH AND REPAIR CEILING
- 14. NEW LIGHT FIXTURE
- 15. DEMO LIGHT FIXTURE
- 16. BATTERY POWERED WALL MOUNTED LINEAR DEFUSER
- 17. OCCUPANCY SENSOR
- 18. EXT. SON - WALL MOUNTED - ARROWS INDICATE DIRECTION
- 19. EXT. SON - WALL MOUNTED - ARROWS INDICATE DIRECTION
- 20. SMOKE DETECTOR CEILING MOUNTED
- 21. SMOKE DETECTOR WALL MOUNTED
- 22. SPRINKLER
- 23. EXISTING WALL MOUNTED SPRINKLER
- 24. RETURN AIR GRILLE
- 25. REPLACE EXISTING FIXTURE WITH NEW LIGHT FIXTURE
- 26. JUNCTION BOX


HADDON HALL
1500 COLLINS AVE
MIAMI BEACH, FL

KEYPLAN N.T.S.

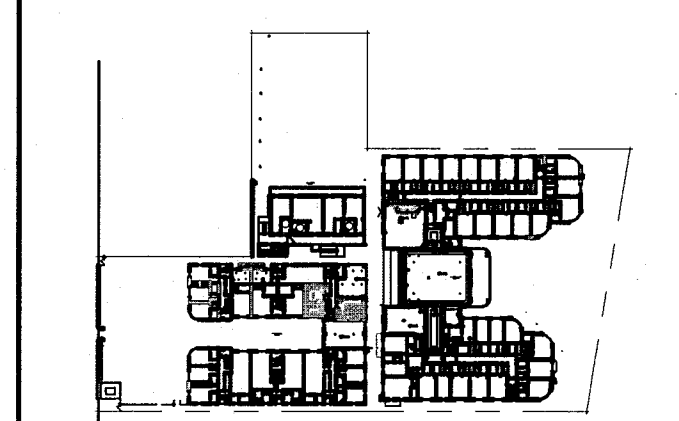


REVISIONS

NO.	DESCRIPTION	ISSUE DATE
1	PROGRESS TO 100% CD	02-18-2014
2	POOL SUITES WALLS	04-14-2014
3	MASTER PERMIT COMMENTS	07-03-2014

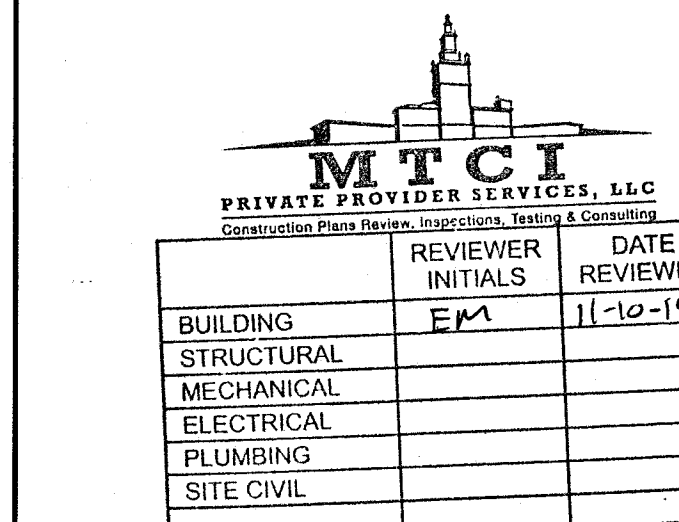

100% CONSTRUCTION DOCUMENT SET

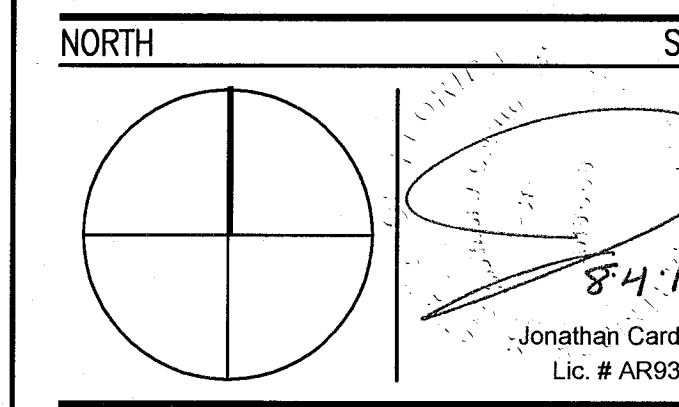

ADD Inc Architecture Interiors Planning

One Biscayne Tower
Suite 1670
Two South
Biscayne Boulevard
Miami, FL 33131
T: 305.482.8700
F: 305.482.8770
www.addinc.com
Lic. # AA26001507

Boston Miami

JOB NUMBER: 13036.00

CHECKED BY:

ISSUE DATE: FEBRUARY 18, 2014

SCALE: 1/4" = 1'-0"


SHEET TITLE

ENLARGED POOL SUITES REFLECTED CEILING PLAN - FIRST FLOOR

SHEET NUMBER

A211c

COPYRIGHT ADD INC 2011

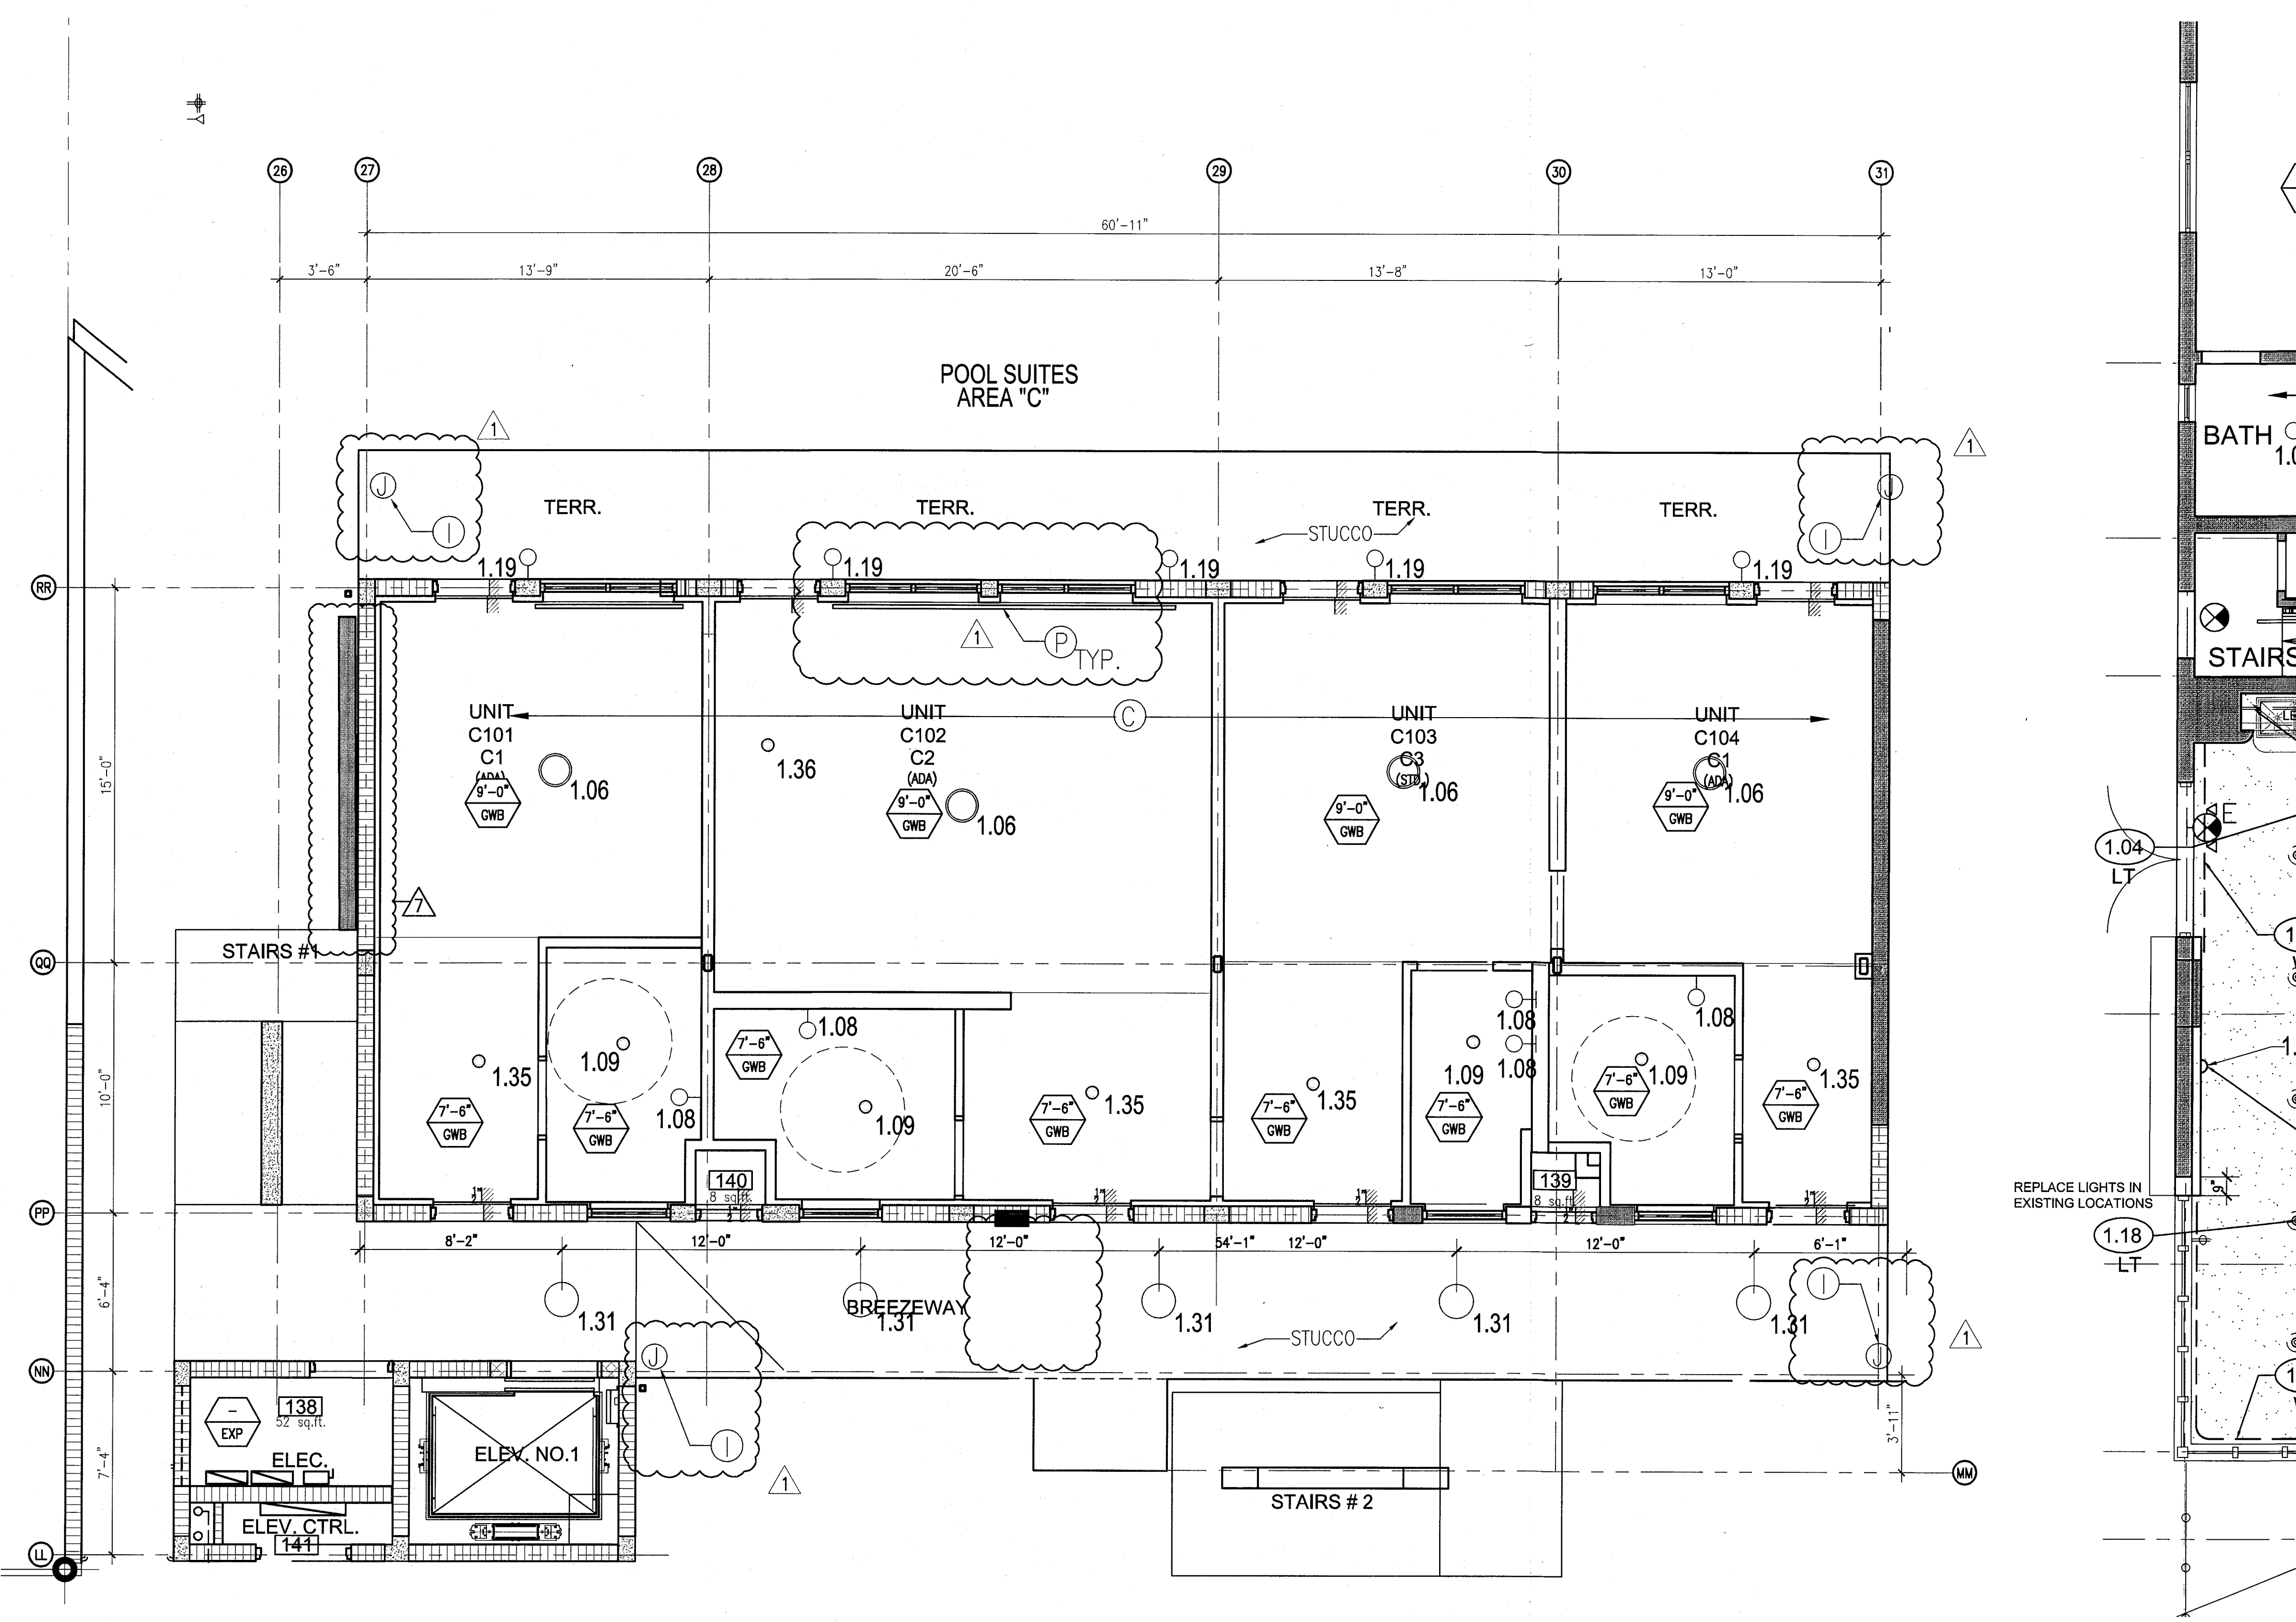

1 ENLARGED POOL SUITES REFLECTED CEILING PLAN - FIRST FLOOR
SCALE: 1/4" = 1'-0"

APPROVED
MIAMI BEACH
FIRE DEPARTMENT

GENERAL NOTES

1. NOTIFY THE ARCHITECT OF ANY UNEXPECTED FIELD CONDITION OR DISCREPANCY BEFORE PROCEEDING. GENERAL CONTRACTOR IS TO COORDINATE THE COMPLETE SCOPES OF WORK WITH CONSTRUCTION DOCUMENTS.
2. NO MAIN FRAMING OR STRUCTURAL MEMBERS ARE TO BE MOVED, ALTERED OR CUT OUT WITH OUT THE APPROVAL OF THE ARCHITECT AND BUILDING DEPARTMENT.
3. REVIEW BUILDING STANDARD MANUAL PROVIDED BY THE BUILDING DEPARTMENT BEFORE PROCEEDING WITH WORK.
4. PROVIDE TEMPORARY SECURE ACCESS TO SPACE THROUGH CORRIDOR AND TEMPORARY LIGHT & POWER.
5. PROVIDE STRICT CONTROL OF JOB CLEANING AND PREVENT DIRT AND DEBRIS FROM CRAWLING FROM CONSTRUCTION AREA.
6. DEBRIS REMOVAL MUST BE DONE USING THE FREIGHT ELEVATOR. CONTACT BUILDING MANAGEMENT OFFICE TO OBTAIN SCHEDULE FOR USE OF FREIGHT ELEVATOR PRIOR TO SCHEDULING. ALL DEBRIS REMOVAL MUST BE PERFORMED IN ACCORDANCE WITH BUILDING MANAGEMENT REQUIREMENTS AND PROCEDURES. CONTRACTOR TO COORDINATE WITH BUILDING MANAGEMENT TO OBTAIN MOST RECENT REQUIREMENTS FOR DEBRIS REMOVAL.

7. CAP AND SHUT OFF ALL UNUSED UTILITIES PER CITY AND STATE REQUIREMENTS, WHERE REQUIRED.
8. FIRE ALARM DEVICES (SMOKE DETECTORS, HORNS, STROBES AND EXIT SIGNS) WITHIN DEMO SPACE SHALL REMAIN CONNECTED TO EXISTING SYSTEMS. SECURE DEVICES AS NECESSARY TO KEEP FROM HANGING FREELY UPON REMOVAL OF WALLS+CEILING.
9. PROTECT ALL BASE BUILDING SERVICES, TYPICAL.
10. ALL REQUIREMENTS FOR FIRE RATINGS TO BE MAINTAINED DURING CONSTRUCTION.
11. THIS PROJECT INVOLVES CONSTRUCTION INSIDE AN EXISTING STRUCTURE. CONTRACTORS, BY SUBMITTING A BID, ARE DEMAND TO BE COMPLETELY FAMILIAR WITH THE EXISTING CONDITION OF THE BUILDING AS IT INFLUENCES THE WORK DESCRIBED. ABSOLUTELY NO CLAIMS FOR EXTRA COMPENSATION WILL BE CONSIDERED FOR EXISTING CONDITIONS VISIBLE OR REASONABLY INFERRABLE FROM A CAREFUL EXAMINATION OF THE EXISTING BLDG.
12. ELECTRICAL DEVICES SHALL BE TERMINATED IN A SAFE AND PROPER METHOD BY A LICENSED PROFESSIONAL.

13. ALL MEP-PP DEVICE LOCATIONS NOT SHOWN ON DRAWINGS OR IN CONFLICT WITH MEP-PP DRAWINGS, ARE TO BE COORDINATED WITH ARCHITECT PRIOR TO INSTALLATION.
14. SHUTDOWN OF EXISTING SYSTEMS FOR CONNECTION TO EXISTING SERVICES SHALL BE COORDINATED WITH THE CONSTRUCTION MANAGER AND BUILDING OWNER. THE CONTRACTOR SHALL SUBMIT REQUESTS, WHEN THEY AFFECT THE OPERATION OF THE BUILDING SYSTEMS, AT LEAST ONE WEEK IN ADVANCE OF ANY REQUIRED SHUTDOWN. THE ACTUAL SHUTDOWN PERIOD SHALL BE AS SHORT AS POSSIBLE AND AT A TIME MUTUALLY AGREEABLE TO THE BUILDING OWNER AND THE CONSTRUCTION MANAGER.
15. ALL WORK SHALL COMPLY WITH FEDERAL, STATE, AND LOCAL BUILDING CODES.
16. E.C. TO COORDINATE ALL AUDIO/VISUAL EQUIPMENT NEEDS WITH CLIENT.
17. BOTTOM OF ALL HANGING FIXTURES TO BE NO LOWER THAN 7'-0" AFF.

18. CONTRACTOR TO PROVIDE OVERLAY DRAWING OF ELECTRICAL FIXTURES, MECH. SYSTEMS AND COMPONENTS, LIFE SAFETY DEVICES, SMOKE DETECTORS, EMERGENCY LIGHTS AND ANY OTHER DEVICE IN CEILING TO ENSURE NO CONFLICTS.
19. SPRINKLER HEADS SHOWN FOR ARCHITECTURAL DESIGN INTENT ONLY. NOT FOR CODE DISTRIBUTION. SEE FIRE PROTECTION DRAWINGS FOR DISTRIBUTION AND CALCULATIONS.
20. CONTRACTOR WILL NOTIFY ARCHITECT IMMEDIATELY OF ANY CONFLICTS BETWEEN ARCHITECTURE AND ENGINEERING DRAWINGS.
21. THE CONTRACTOR SHALL INSPECT THE EXISTING FIELD CONDITIONS AT THE SITE PRIOR TO THE START OF ANY WORK TO DETERMINE WHAT EFFECT THE EXISTING CONDITIONS WILL HAVE ON HIS WORK. POTENTIAL PROBLEM AREAS SHALL BE BROUGHT TO THE ATTENTION OF THE ARCHITECT AND/OR ENGINEER IMMEDIATELY.
22. REFER TO SHEETS E1.00 FOR ELECTRICAL DRAWINGS AND FFP SITES FOR FIRE SPRINKLER DRAWINGS.

23. CONTRACTOR TO PROVIDE OVERLAY DRAWING OF ELECTRICAL FIXTURES, MECH. SYSTEMS AND COMPONENTS, LIFE SAFETY DEVICES, SMOKE DETECTORS, EMERGENCY LIGHTS AND ANY OTHER DEVICE IN CEILING TO ENSURE NO CONFLICTS.
24. SPRINKLER HEADS SHOWN FOR ARCHITECTURAL DESIGN INTENT ONLY. NOT FOR CODE DISTRIBUTION. SEE FIRE PROTECTION DRAWINGS FOR DISTRIBUTION AND CALCULATIONS.
25. CONTRACTOR WILL NOTIFY ARCHITECT IMMEDIATELY OF ANY CONFLICTS BETWEEN ARCHITECTURE AND ENGINEERING DRAWINGS.
26. THE CONTRACTOR SHALL INSPECT THE EXISTING FIELD CONDITIONS AT THE SITE PRIOR TO THE START OF ANY WORK TO DETERMINE WHAT EFFECT THE EXISTING CONDITIONS WILL HAVE ON HIS WORK. POTENTIAL PROBLEM AREAS SHALL BE BROUGHT TO THE ATTENTION OF THE ARCHITECT AND/OR ENGINEER IMMEDIATELY.
27. REFER TO SHEETS E1.00 FOR ELECTRICAL DRAWINGS AND FFP SITES FOR FIRE SPRINKLER DRAWINGS.

28. CONTRACTOR TO PROVIDE OVERLAY DRAWING OF ELECTRICAL FIXTURES, MECH. SYSTEMS AND COMPONENTS, LIFE SAFETY DEVICES, SMOKE DETECTORS, EMERGENCY LIGHTS AND ANY OTHER DEVICE IN CEILING TO ENSURE NO CONFLICTS.
29. SPRINKLER HEADS SHOWN FOR ARCHITECTURAL DESIGN INTENT ONLY. NOT FOR CODE DISTRIBUTION. SEE FIRE PROTECTION DRAWINGS FOR DISTRIBUTION AND CALCULATIONS.
30. CONTRACTOR WILL NOTIFY ARCHITECT IMMEDIATELY OF ANY CONFLICTS BETWEEN ARCHITECTURE AND ENGINEERING DRAWINGS.
31. THE CONTRACTOR SHALL INSPECT THE EXISTING FIELD CONDITIONS AT THE SITE PRIOR TO THE START OF ANY WORK TO DETERMINE WHAT EFFECT THE EXISTING CONDITIONS WILL HAVE ON HIS WORK. POTENTIAL PROBLEM AREAS SHALL BE BROUGHT TO THE ATTENTION OF THE ARCHITECT AND/OR ENGINEER IMMEDIATELY.
32. REFER TO SHEETS E1.00 FOR ELECTRICAL DRAWINGS AND FFP SITES FOR FIRE SPRINKLER DRAWINGS.

33. CONTRACTOR TO PROVIDE OVERLAY DRAWING OF ELECTRICAL FIXTURES, MECH. SYSTEMS AND COMPONENTS, LIFE SAFETY DEVICES, SMOKE DETECTORS, EMERGENCY LIGHTS AND ANY OTHER DEVICE IN CEILING TO ENSURE NO CONFLICTS.
34. SPRINKLER HEADS SHOWN FOR ARCHITECTURAL DESIGN INTENT ONLY. NOT FOR CODE DISTRIBUTION. SEE FIRE PROTECTION DRAWINGS FOR DISTRIBUTION AND CALCULATIONS.
35. CONTRACTOR WILL NOTIFY ARCHITECT IMMEDIATELY OF ANY CONFLICTS BETWEEN ARCHITECTURE AND ENGINEERING DRAWINGS.
36. THE CONTRACTOR SHALL INSPECT THE EXISTING FIELD CONDITIONS AT THE SITE PRIOR TO THE START OF ANY WORK TO DETERMINE WHAT EFFECT THE EXISTING CONDITIONS WILL HAVE ON HIS WORK. POTENTIAL PROBLEM AREAS SHALL BE BROUGHT TO THE ATTENTION OF THE ARCHITECT AND/OR ENGINEER IMMEDIATELY.
37. REFER TO SHEETS E1.00 FOR ELECTRICAL DRAWINGS AND FFP SITES FOR FIRE SPRINKLER DRAWINGS.

38. CONTRACTOR TO PROVIDE OVERLAY DRAWING OF ELECTRICAL FIXTURES, MECH. SYSTEMS AND COMPONENTS, LIFE SAFETY DEVICES, SMOKE DETECTORS, EMERGENCY LIGHTS AND ANY OTHER DEVICE IN CEILING TO ENSURE NO CONFLICTS.
39. SPRINKLER HEADS SHOWN FOR ARCHITECTURAL DESIGN INTENT ONLY. NOT FOR CODE DISTRIBUTION. SEE FIRE PROTECTION DRAWINGS FOR DISTRIBUTION AND CALCULATIONS.
40. CONTRACTOR WILL NOTIFY ARCHITECT IMMEDIATELY OF ANY CONFLICTS BETWEEN ARCHITECTURE AND ENGINEERING DRAWINGS.
41. THE CONTRACTOR SHALL INSPECT THE EXISTING FIELD CONDITIONS AT THE SITE PRIOR TO THE START OF ANY WORK TO DETERMINE WHAT EFFECT THE EXISTING CONDITIONS WILL HAVE ON HIS WORK. POTENTIAL PROBLEM AREAS SHALL BE BROUGHT TO THE ATTENTION OF THE ARCHITECT AND/OR ENGINEER IMMEDIATELY.
42. REFER TO SHEETS E1.00 FOR ELECTRICAL DRAWINGS AND FFP SITES FOR FIRE SPRINKLER DRAWINGS.

43. CONTRACTOR TO PROVIDE OVERLAY DRAWING OF ELECTRICAL FIXTURES, MECH. SYSTEMS AND COMPONENTS, LIFE SAFETY DEVICES, SMOKE DETECTORS, EMERGENCY LIGHTS AND ANY OTHER DEVICE IN CEILING TO ENSURE NO CONFLICTS.
44. SPRINKLER HEADS SHOWN FOR ARCHITECTURAL DESIGN INTENT ONLY. NOT FOR CODE DISTRIBUTION. SEE FIRE PROTECTION DRAWINGS FOR DISTRIBUTION AND CALCULATIONS.
45. CONTRACTOR WILL NOTIFY ARCHITECT IMMEDIATELY OF ANY CONFLICTS BETWEEN ARCHITECTURE AND ENGINEERING DRAWINGS.
46. THE CONTRACTOR SHALL INSPECT THE EXISTING FIELD CONDITIONS AT THE SITE PRIOR TO THE START OF ANY WORK TO DETERMINE WHAT EFFECT THE EXISTING CONDITIONS WILL HAVE ON HIS WORK. POTENTIAL PROBLEM AREAS SHALL BE BROUGHT TO THE ATTENTION OF THE ARCHITECT AND/OR ENGINEER IMMEDIATELY.
47. REFER TO SHEETS E1.00 FOR ELECTRICAL DRAWINGS AND FFP SITES FOR FIRE SPRINKLER DRAWINGS.

48. CONTRACTOR TO PROVIDE OVERLAY DRAWING OF ELECTRICAL FIXTURES, MECH. SYSTEMS AND COMPONENTS, LIFE SAFETY DEVICES, SMOKE DETECTORS, EMERGENCY LIGHTS AND ANY OTHER DEVICE IN CEILING TO ENSURE NO CONFLICTS.
49. SPRINKLER HEADS SHOWN FOR ARCHITECTURAL DESIGN INTENT ONLY. NOT FOR CODE DISTRIBUTION. SEE FIRE PROTECTION DRAWINGS FOR DISTRIBUTION AND CALCULATIONS.
50. CONTRACTOR WILL NOTIFY ARCHITECT IMMEDIATELY OF ANY CONFLICTS BETWEEN ARCHITECTURE AND ENGINEERING DRAWINGS.
51. THE CONTRACTOR SHALL INSPECT THE EXISTING FIELD CONDITIONS AT THE SITE PRIOR TO THE START OF ANY WORK TO DETERMINE WHAT EFFECT THE EXISTING CONDITIONS WILL HAVE ON HIS WORK. POTENTIAL PROBLEM AREAS SHALL BE BROUGHT TO THE ATTENTION OF THE ARCHITECT AND/OR ENGINEER IMMEDIATELY.
52. REFER TO SHEETS E1.00 FOR ELECTRICAL DRAWINGS AND FFP SITES FOR FIRE SPRINKLER DRAWINGS.

53. CONTRACTOR TO PROVIDE OVERLAY DRAWING OF ELECTRICAL FIXTURES, MECH. SYSTEMS AND COMPONENTS, LIFE SAFETY DEVICES, SMOKE DETECTORS, EMERGENCY LIGHTS AND ANY OTHER DEVICE IN CEILING TO ENSURE NO CONFLICTS.
54. SPRINKLER HEADS SHOWN FOR ARCHITECTURAL DESIGN INTENT ONLY. NOT FOR CODE DISTRIBUTION. SEE FIRE PROTECTION DRAWINGS FOR DISTRIBUTION AND CALCULATIONS.
55. CONTRACTOR WILL NOTIFY ARCHITECT IMMEDIATELY OF ANY CONFLICTS BETWEEN ARCHITECTURE AND ENGINEERING DRAWINGS.
56. THE CONTRACTOR SHALL INSPECT THE EXISTING FIELD CONDITIONS AT THE SITE PRIOR TO THE START OF ANY WORK TO DETERMINE WHAT EFFECT THE EXISTING CONDITIONS WILL HAVE ON HIS WORK. POTENTIAL PROBLEM AREAS SHALL BE BROUGHT TO THE ATTENTION OF THE ARCHITECT AND/OR ENGINEER IMMEDIATELY.
57. REFER TO SHEETS E1.00 FOR ELECTRICAL DRAWINGS AND FFP SITES FOR FIRE SPRINKLER DRAWINGS.

58. CONTRACTOR TO PROVIDE OVERLAY DRAWING OF ELECTRICAL FIXTURES, MECH. SYSTEMS AND COMPONENTS, LIFE SAFETY DEVICES, SMOKE DETECTORS, EMERGENCY LIGHTS AND ANY OTHER DEVICE IN CEILING TO ENSURE NO CONFLICTS.
59. SPRINKLER HEADS SHOWN FOR ARCHITECTURAL DESIGN INTENT ONLY. NOT FOR CODE DISTRIBUTION. SEE FIRE PROTECTION DRAWINGS FOR DISTRIBUTION AND CALCULATIONS.
60. CONTRACTOR WILL NOTIFY ARCHITECT IMMEDIATELY OF ANY CONFLICTS BETWEEN ARCHITECTURE AND ENGINEERING DRAWINGS.
61. THE CONTRACTOR SHALL INSPECT THE EXISTING FIELD CONDITIONS AT THE SITE PRIOR TO THE START OF ANY WORK TO DETERMINE WHAT EFFECT THE EXISTING CONDITIONS WILL HAVE ON HIS WORK. POTENTIAL PROBLEM AREAS SHALL BE BROUGHT TO THE ATTENTION OF THE ARCHITECT AND/OR ENGINEER IMMEDIATELY.
62. REFER TO SHEETS E1.00 FOR ELECTRICAL DRAWINGS AND FFP SITES FOR FIRE SPRINKLER DRAWINGS.

SHEET NOTES

1. ALL EXISTING GYPSUM BOARD CEILING IN TO BE MAINTAINED AND RESTORED WHERE POSSIBLE. MINIMAL DEMOLITION FOR ADDITION OF NEW HVAC GRILLES AND SUPPLIED AREAS.
2. ALL EXISTING LIGHT FIXTURES IN HADDON HALL TO BE REMOVED AND REPLACED IN SAME LOCATION UNLESS OTHERWISE NOTED.
3. FOR OUTDOOR AREA LIGHTING REFER TO LANDSCAPE PLANS.
4. EXISTING HISTORIC SOFFIT AREAS IN HADDON HALL SECOND FLOOR COMMON AREA TO BE KEPT AND RESTORED.
5. EXISTING EXPOSED SPRINKLER PIPES IN HADDON HALL BUILDING TO BE COVERED WITH NEW PERIMETER SOFFIT AREA AT ALL CORRIDORS.
6. CENTER LIGHT FIXTURE IN SPACE U.O.A.
7. REFER TO A-281 FOR LIGHTING FIXTURE SCHEDULE.
8. J-BOX FOR FUTURE LED BACKLIGHT FOR TUBE SCREENS.

9. COORDINATE LOCATION OF HANGING DOWNER WITH DESIGNER PRIOR TO INSTALLATION. ADDITIONAL BLOCKING MAY BE REQUIRED.
10. ALL GENERAL CEILING AND SOFFITS TO BE PAINTED PT-02 (FLAT PEARL) U.O.A. ALL GUESTROOM AND PUBLIC RESTROOMS CEILING TO BE PAINTED PT-03 (EGGSHELL) FINISH.
11. LED STRIP LIGHTING SHOWN ON PLAN WITH NOTE AS PLUG-IN RECEPTACLE AT ALL.
12. ALL LIGHT FIXTURES IN CAMPTON APARTMENTS AND 1000 SUITES TO BE NEW AND CENTERED IN SPACE U.O.A.
13. WALL SCONES SHOWN ON PLAN. ALL WALL SCONES IN HADDON HALL GUESTROOMS AND 1000 SUITES TO BE NEW AND CENTERED IN SPACE U.O.A.
14. 1"x4" MOUNTED TO CEILING IN FRONT OF WINDOWS TO ACT AS VALANCE TO CORREL DRAPERY ROD. 1"x4" TO BE PAINTED PT-02. SEE WMY, VERIFY IN FIELD.

15. COORDINATE LOCATION OF HANGING DOWNER WITH DESIGNER PRIOR TO INSTALLATION. ADDITIONAL BLOCKING MAY BE REQUIRED.
16. ALL GENERAL CEILING AND SOFFITS TO BE PAINTED PT-02 (FLAT PEARL) U.O.A. ALL GUESTROOM AND PUBLIC RESTROOMS CEILING TO BE PAINTED PT-03 (EGGSHELL) FINISH.
17. LED STRIP LIGHTING SHOWN ON PLAN WITH NOTE AS PLUG-IN RECEPTACLE AT ALL.
18. ALL LIGHT FIXTURES IN CAMPTON APARTMENTS AND 1000 SUITES TO BE NEW AND CENTERED IN SPACE U.O.A.
19. WALL SCONES SHOWN ON PLAN. ALL WALL SCONES IN HADDON HALL GUESTROOMS AND 1000 SUITES TO BE NEW AND CENTERED IN SPACE U.O.A.
20. 1"x4" MOUNTED TO CEILING IN FRONT OF WINDOWS TO ACT AS VALANCE TO CORREL DRAPERY ROD. 1"x4" TO BE PAINTED PT-02. SEE WMY, VERIFY IN FIELD.

21. COORDINATE LOCATION OF HANGING DOWNER WITH DESIGNER PRIOR TO INSTALLATION. ADDITIONAL BLOCKING MAY BE REQUIRED.
22. ALL GENERAL CEILING AND SOFFITS TO BE PAINTED PT-02 (FLAT PEARL) U.O.A. ALL GUESTROOM AND PUBLIC RESTROOMS CEILING TO BE PAINTED PT-03 (EGGSHELL) FINISH.
23. LED STRIP LIGHTING SHOWN ON PLAN WITH NOTE AS PLUG-IN RECEPTACLE AT ALL.
24. ALL LIGHT FIXTURES IN CAMPTON APARTMENTS AND 1000 SUITES TO BE NEW AND CENTERED IN SPACE U.O.A.
25. WALL SCONES SHOWN ON PLAN. ALL WALL SCONES IN HADDON HALL GUESTROOMS AND 1000 SUITES TO BE NEW AND CENTERED IN SPACE U.O.A.
26. 1"x4" MOUNTED TO CEILING IN FRONT OF WINDOWS TO ACT AS VALANCE TO CORREL DRAPERY ROD. 1"x4" TO BE PAINTED PT-02. SEE WMY, VERIFY IN FIELD.

27. COORDINATE LOCATION OF HANGING DOWNER WITH DESIGNER PRIOR TO INSTALLATION. ADDITIONAL BLOCKING MAY BE REQUIRED.
28. ALL GENERAL CEILING AND SOFFITS TO BE PAINTED PT-02 (FLAT PEARL) U.O.A. ALL GUESTROOM AND PUBLIC RESTROOMS CEILING TO BE PAINTED PT-03 (EGGSHELL) FINISH.
29. LED STRIP LIGHTING SHOWN ON PLAN WITH NOTE AS PLUG-IN RECEPTACLE AT ALL.
30. ALL LIGHT FIXTURES IN CAMPTON APARTMENTS AND 1000 SUITES TO BE NEW AND CENTERED IN SPACE U.O.A.
31. WALL SCONES SHOWN ON PLAN. ALL WALL SCONES IN HADDON HALL GUESTROOMS AND 1000 SUITES TO BE NEW AND CENTERED IN SPACE U.O.A.
32. 1"x4" MOUNTED TO CEILING IN FRONT OF WINDOWS TO ACT AS VALANCE TO CORREL DRAPERY ROD. 1"x4" TO BE PAINTED PT-02. SEE WMY, VERIFY IN FIELD.

LEGEND

- GYPSUM BOARD/JOIST
- CEILING HEIGHT KEY
- CEILING TYPE
- 1" x 4" PENDANT
- DOWNLIGHT
- LED STRIP LIGHT
- EXTERIOR/DECORATIVE SCONES
- PENDANT FIXTURE
- SURFACE MOUNTED FIXTURE
- WALL SCONES
- EXISTING FEATURE TO BE REPLACED WITH NEW FIXTURE IN SAME LOCATION
- DEMO FIXTURE - PATCH AND REPAIR CEILING
- NEW LIGHT FIXTURE
- DEMO LIGHT FIXTURE

- BATTERY POWERED WALL MOUNTED LINEAR DIFFUSER
- OCCUPANCY SENSOR
- EXIT SIGN - WALL MOUNTED
- EXIT SIGN - WALL MOUNTED
- SMOKE DETECTOR CEILING MOUNTED
- SMOKE DETECTOR WALL MOUNTED
- EXISTING CEILING MOUNTED SPRINKLER
- EXISTING WALL MOUNTED SPRINKLER
- SUPPLY DIFFUSER
- RETURN AIR GRILLE
- REPLACE EXISTING FIXTURE WITH NEW LIGHT FIXTURE
- JUNCTION BOX


NOTE: CEILING AT EXISTING HADDON HALL GUESTROOMS ARE EXISTING TO REMAIN AT 9'-0" A.F.F. UNLESS OTHERWISE NOTED



1 ENLARGED SECOND FLOOR REFLECTED CEILING PLAN/HADDON HALL NORTH
SCALE: 3/32" = 1'-0"

HADDON HALL
1500 COLLINS AVE
MIAMI BEACH, FL


KEYPLAN N.T.S.

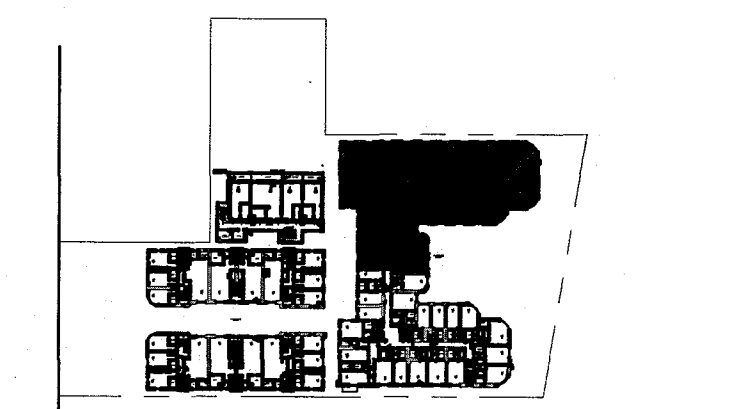

NO.	DESCRIPTION	ISSUE DATE
1	PROGRESS TO 100% CD	02-18-2014
2	FIRE REVIEW COMMENTS	04-09-2014
3	MASTER PERMIT COMMENTS	07-03-2014

MTCI PRIVATE PROVIDER SERVICES, LLC		
BUILDING	REVIEWER INITIALS	DATE REVIEWED
STRUCTURAL	EM	11-12-14
MECHANICAL		
ELECTRICAL		
PLUMBING		
SITE CIVIL		

100% CONSTRUCTION DOCUMENT SET

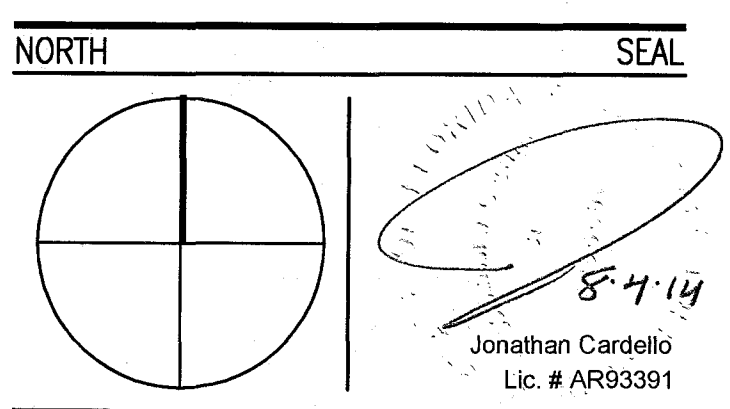

ADD Inc Architecture Interiors Planning
One Biscayne Tower Suite 1670
Two South Biscayne Boulevard
Miami, FL 33131
T: 305.482.8700
F: 305.482.8770
www.addinc.com
Lic. # AA26001507

JOB NUMBER: 13036.00
CHECKED BY:
ISSUE DATE: FEBRUARY 18, 2014
SCALE: 1/4" = 1'-0"

SHEET TITLE

ENLARGED HADDON HALL REFLECTED CEILING PLAN
SECOND FLOOR-NORTH

SHEET NUMBER

A212a1

APPROVED
MIAMI BEACH
FIRE DEPARTMENT

GENERAL NOTES

1. NOTIFY THE ARCHITECT OF ANY UNEXPECTED FIELD CONDITION OR ANY DISCREPANCY BEFORE PROCEEDING. GENERAL CONSTRUCTION IS TO COORDINATE THE COMPLETE SCOPE OF WORK WITH CONSTRUCTION DOCUMENTS.
2. NO MAJOR REWORK OR STRUCTURAL MEMBERS ARE TO BE MOVED, ALTERED OR CUT WITH OUT THE APPROVAL OF THE ARCHITECT AND BUILDING MANAGEMENT.
3. REVIEW BUILDING STANDARD MANUAL PROVIDED BY THE BUILDING PROPERTY MANAGER BEFORE PROCEEDING WITH WORK.
4. PROVIDE TEMPORARY SECURE ACCESS TO SPACE THROUGH CONSTRUCTION AND TEMPORARY LIGHT & POWER.
5. PROVIDE STRICT CONTROL OF JOB CLEANING AND PREVENT DUST AND DEBRIS FROM EMANATING FROM CONSTRUCTION AREA.
6. DEBRIS REMOVAL MUST BE DONE USING THE FREIGHT ELEVATOR. CONTACT BUILDING MANAGEMENT OFFICE TO OBTAIN SCHEDULE FOR USE OF FREIGHT ELEVATORS PRIOR TO SUBMITTING BID. ALL DEBRIS REMOVAL MUST BE PERFORMED IN ACCORDANCE WITH BUILDING MANAGEMENT REQUIREMENTS AND PROCEDURES. CONTRACTOR TO COORDINATE WITH BUILDING MANAGEMENT TO OBTAIN MOST RECENT REQUIREMENTS FOR DEBRIS REMOVAL.
7. CAP AND SHUT OFF ALL UNUSED UTILITIES PER CITY AND STATE REQUIREMENTS, WHERE REQUIRED.
8. FIRE ALARM DEVICES (SMOKE DETECTORS, HORNS, STROBES AND EXIT SIGNS) WITHIN DEMO SPACE SHALL REMAIN CONNECTED TO EXISTING SYSTEMS. SECURE DEVICES AS NECESSARY TO KEEP FROM HANGING FREELY UPON REMOVAL OF WALLS/CEILING.
9. PROTECT ALL BASE BUILDING SERVICES, TYPICAL.
10. ALL REQUIREMENTS FOR FIRE RATINGS TO BE MAINTAINED DURING CONSTRUCTION.
11. THIS PROJECT INVOLVES CONSTRUCTION INSIDE AN EXISTING STRUCTURE. CONTRACTORS, BY SUBMITTING A BID, ARE DEEMED TO BE COMPLETELY FAMILIAR WITH THE EXISTING CONDITION OF THE BUILDING AS IT INFLUENCES THE WORK DESCRIBED. RESISTANCE TO CLAIM FOR EXTRA COMPENSATION WILL BE CONSIDERED FOR EXISTING CONDITIONS VISIBLE OR REASONABLY INFERRABLE FROM A CAREFUL EXAMINATION OF THE EXISTING BLDG.
12. ELECTRICAL DEVICES SHALL BE TERMINATED IN A SAFE AND PROPER METHOD BY A LICENSED PROFESSIONAL.
13. ALL MEP-PP DEVICE LOCATIONS NOT SHOWN ON DRAWINGS OR IN CONFLICT WITH MEP-PP DRAWINGS, ARE TO BE COORDINATED WITH ARCHITECT PRIOR TO INSTALLATION.
14. SHUTDOWN OF EXISTING SYSTEMS FOR CONNECTION TO EXISTING SERVICES SHALL BE COORDINATED WITH THE CONSTRUCTION MANAGER AND BUILDING OWNER. THE CONTRACTOR SHALL SUBMIT REQUESTS, WHERE THEY AFFECT THE OPERATION OF THE BUILDING SYSTEMS, AT LEAST ONE WEEK IN ADVANCE OF ANY REQUIRED SHUTDOWN. THE ACTUAL SHUTDOWN PERIOD SHALL BE AS SHORT AS POSSIBLE AND AT A TIME MUTUALLY AGREEABLE TO THE BUILDING OWNER AND THE CONSTRUCTION MANAGER.
15. ALL WORK SHALL COMPLY WITH FEDERAL, STATE, AND LOCAL BUILDING CODES.
16. G.C. TO COORDINATE ALL AUDIO/VISUAL EQUIPMENT NEEDS WITH CLIENT.
17. BOTTOM OF ALL HANGING FIXTURES TO BE NO LOWER THAN 7'-0" AFF.
18. CONTRACTOR TO PROVIDE OVERLAY DRAWING OF ELECTRICAL FIXTURES, MECH. SYSTEMS AND COMPONENTS, LIFE SAFETY DEVICES, SMOKE DETECTORS, EMERGENCY LIGHTS AND ANY OTHER DEVICES IN CEILING TO ENSURE NO CONFLICTS.
19. SPRINKLER HEADS SHOWN FOR ARCHITECTURAL DESIGN INTENT ONLY. NOT FOR CODE DISTRIBUTION. SEE FIRE PROTECTION DRAWINGS FOR DISTRIBUTION AND CALCULATIONS.
20. CONTRACTOR WILL NOTIFY ARCHITECT IMMEDIATELY OF ANY CONFLICTS BETWEEN ARCHITECTURE AND ENGINEERING DRAWINGS.
21. THE CONTRACTOR SHALL INSPECT THE EXISTING FIELD CONDITIONS AT THE SITE PRIOR TO THE START OF ANY WORK TO DETERMINE WHAT EFFECT THE EXISTING CONDITIONS WILL HAVE ON HIS WORK. POTENTIAL PROBLEM AREAS SHALL BE BROUGHT TO THE ATTN. OF THE ARCHITECT AND/OR ENGINEER IMMEDIATELY.
22. REFER TO SHEETS E100 FOR ELECTRICAL DRAWINGS AND F100 SERIES FOR FIRE SPRINKLER DRAWINGS.

SHEET NOTES

1. ALL EXISTING GYPSUM BOARD CEILING IN TO BE MAINTAINED AND RESTORED WHERE POSSIBLE. MINIMAL CONDITION FOR POSITION OF NEW HANG GRILLES AND SUFFITED AREAS.
2. ALL EXISTING LIGHT FIXTURES IN HADDON HALL TO BE REMOVED AND REPLACED IN SAME LOCATION UNLESS OTHERWISE NOTED.
3. FOR HOTEL ROOMS ROPS REFER TO SHEETS A901-918.
4. FOR OUTDOOR AREA LIGHTING REFER TO LANDSCAPE PLANS.
5. EXISTING HISTORIC SUFFIT AREAS IN HADDON HALL GROUND FLOOR COMMON AREA TO BE KEPT AND RESTORED.
6. EXISTING EXPOSED SPRINKLER PIPES IN HADDON HALL BUILDING TO BE COVERED WITH NEW PERIMETER SUFFIT AREA AT ALL CORRIDORS.
7. CENTER LIGHT FIXTURE IN SPACE U.G.
8. REFER TO A-281 FOR LIGHTING FIXTURE SCHEDULE.
9. J-BOX FOR FUTURE LED BACKLIGHT FOR TUBE SCALES.
10. COORDINATE LOCATION OF HANGING CHAIR WITH DESIGNER PRIOR TO INSTALLATION. ADDITIONAL BLOSSOM MAY BE REQUIRED.
11. ALL GENERAL CEILING AND SUFFIT TO BE PAINTED PL-07 (FLAT FINISH) U.G.N. ALL OUTDOOR AND PUBLIC RESTROOMS CEILING TO BE PAINTED PL-01 (GLOSS/SEMI GLOSS).
12. LED STRIP LIGHTING SHOWN ON PLAN WITH NOTE AS PLUG-IN RECEPTACLE AT ALL.
13. ALL LIGHT FIXTURES IN CAPTION APARTMENTS AND POOL SUITES TO BE NEW AND CENTERED IN SPACE U.G.A.
14. WALL SCAFFOLD SHOWN ON PLAN. ALL WALL CONES IN HADDON HALL GUESTROOMS WILL REPLACE EXISTING IN SAME LOCATION. ALL SCAFFOLDS IN CAPTION AND POOL SUITES NEW. REFER TO GUESTROOM ELEVATIONS FOR SPACE-4000.
15. 1"X4" WOODEN TO SCULPT IN FRONT OF WINDOWS TO ACT AS VALANCE TO CONCEAL, DRAPERY ROD. 1/4" TO BE PAINTED PL-07. SIZES VARY, VERIFY IN FIELD.


LEGEND

- GNB CEILING/SUFFIT
- CEILING HEIGHT KEY
- CEILING TYPE
- CEILING HEIGHT - AFF
- 1" X 4" PENDANT
- DOWNLIGHT
- LED STRIP LIGHT
- EXTERIOR/DECORATIVE SCAFFOLD
- PENDANT FIXTURE
- SURFACE MOUNTED FIXTURE
- WALL SCAFFOLD
- EXISTING FIXTURE TO BE REPLACED WITH NEW FIXTURE IN SAME LOCATION
- DEMO FIXTURE - PATCH AND REPAIR CEILING
- NEW LIGHT FIXTURE
- DEMO LIGHT FIXTURE
- BATTERY POWERED WALL MOUNTED LINEAR DIFFUSER
- OCCUPANCY SENSOR
- EXIT SIGN - WALL MOUNTED
- EXIT SIGN - WALL MOUNTED
- SMOKE DETECTOR CEILING MOUNTED
- SMOKE DETECTOR WALL MOUNTED
- EXISTING CEILING MOUNTED SPRINKLER
- EXISTING WALL MOUNTED SPRINKLER
- RETURN AIR GRILLE
- REPLACE EXISTING FIXTURE WITH NEW LIGHT FIXTURE JUNCTION BOX

NOTE: CEILING AT EXISTING HADDON HALL GUESTROOMS ARE EXISTING TO REMAIN AT 9'-0" A.F.F. UNLESS OTHERWISE NOTED

HADDON HALL
1500 COLLINS AVE
MIAMI BEACH, FL

KEYPLAN N.T.S.

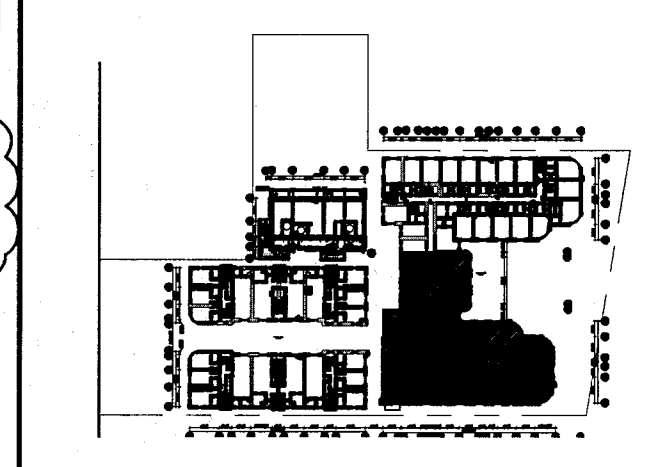


REVISIONS

NO.	DESCRIPTION	ISSUE DATE
1	PROGRESS TO 100% CD	02-18-2014
2	FIRE REVIEW COMMENTS	04-09-2014
3	MASTER PERMIT COMMENTS	07-03-2014

MTCI			
PRIVATE PROVIDER SERVICES, LLC			
Construction Plans Review, Inspection, Testing & Consulting			
BUILDING	REVIEWER	DATE	REVIEWED
STRUCTURAL	EM	11-10-14	
MECHANICAL			
ELECTRICAL			
PLUMBING			
SITE CIVIL			

100% CONSTRUCTION DOCUMENT SET

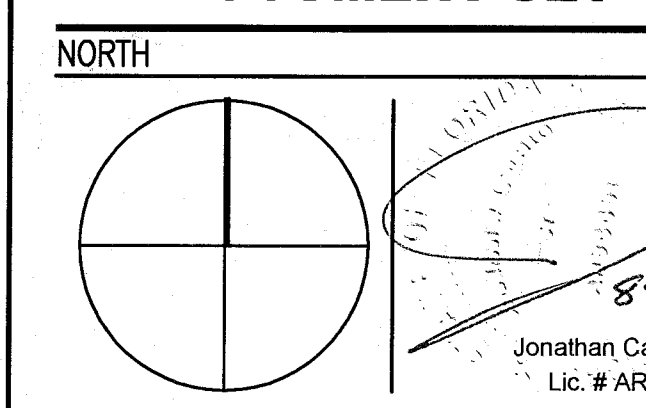

ADD Inc Architecture Interiors Planning

One Biscayne Tower
Suite 1670
Two South
Biscayne Boulevard
Miami, FL 33131
T. 305.482.8700
F. 305.482.8770
www.addinc.com
Lic. # AA26001507

JOB NUMBER: 13036.00
CHECKED BY:
ISSUE DATE: FEBRUARY 18, 2014
SCALE: 1/4" = 1'-0"


SHEET TITLE

ENLARGED HADDON HALL REFLECTED CEILING PLAN SECOND FLOOR-SOUTH

SHEET NUMBER

A212a2

COPYRIGHT ADD INC 2011

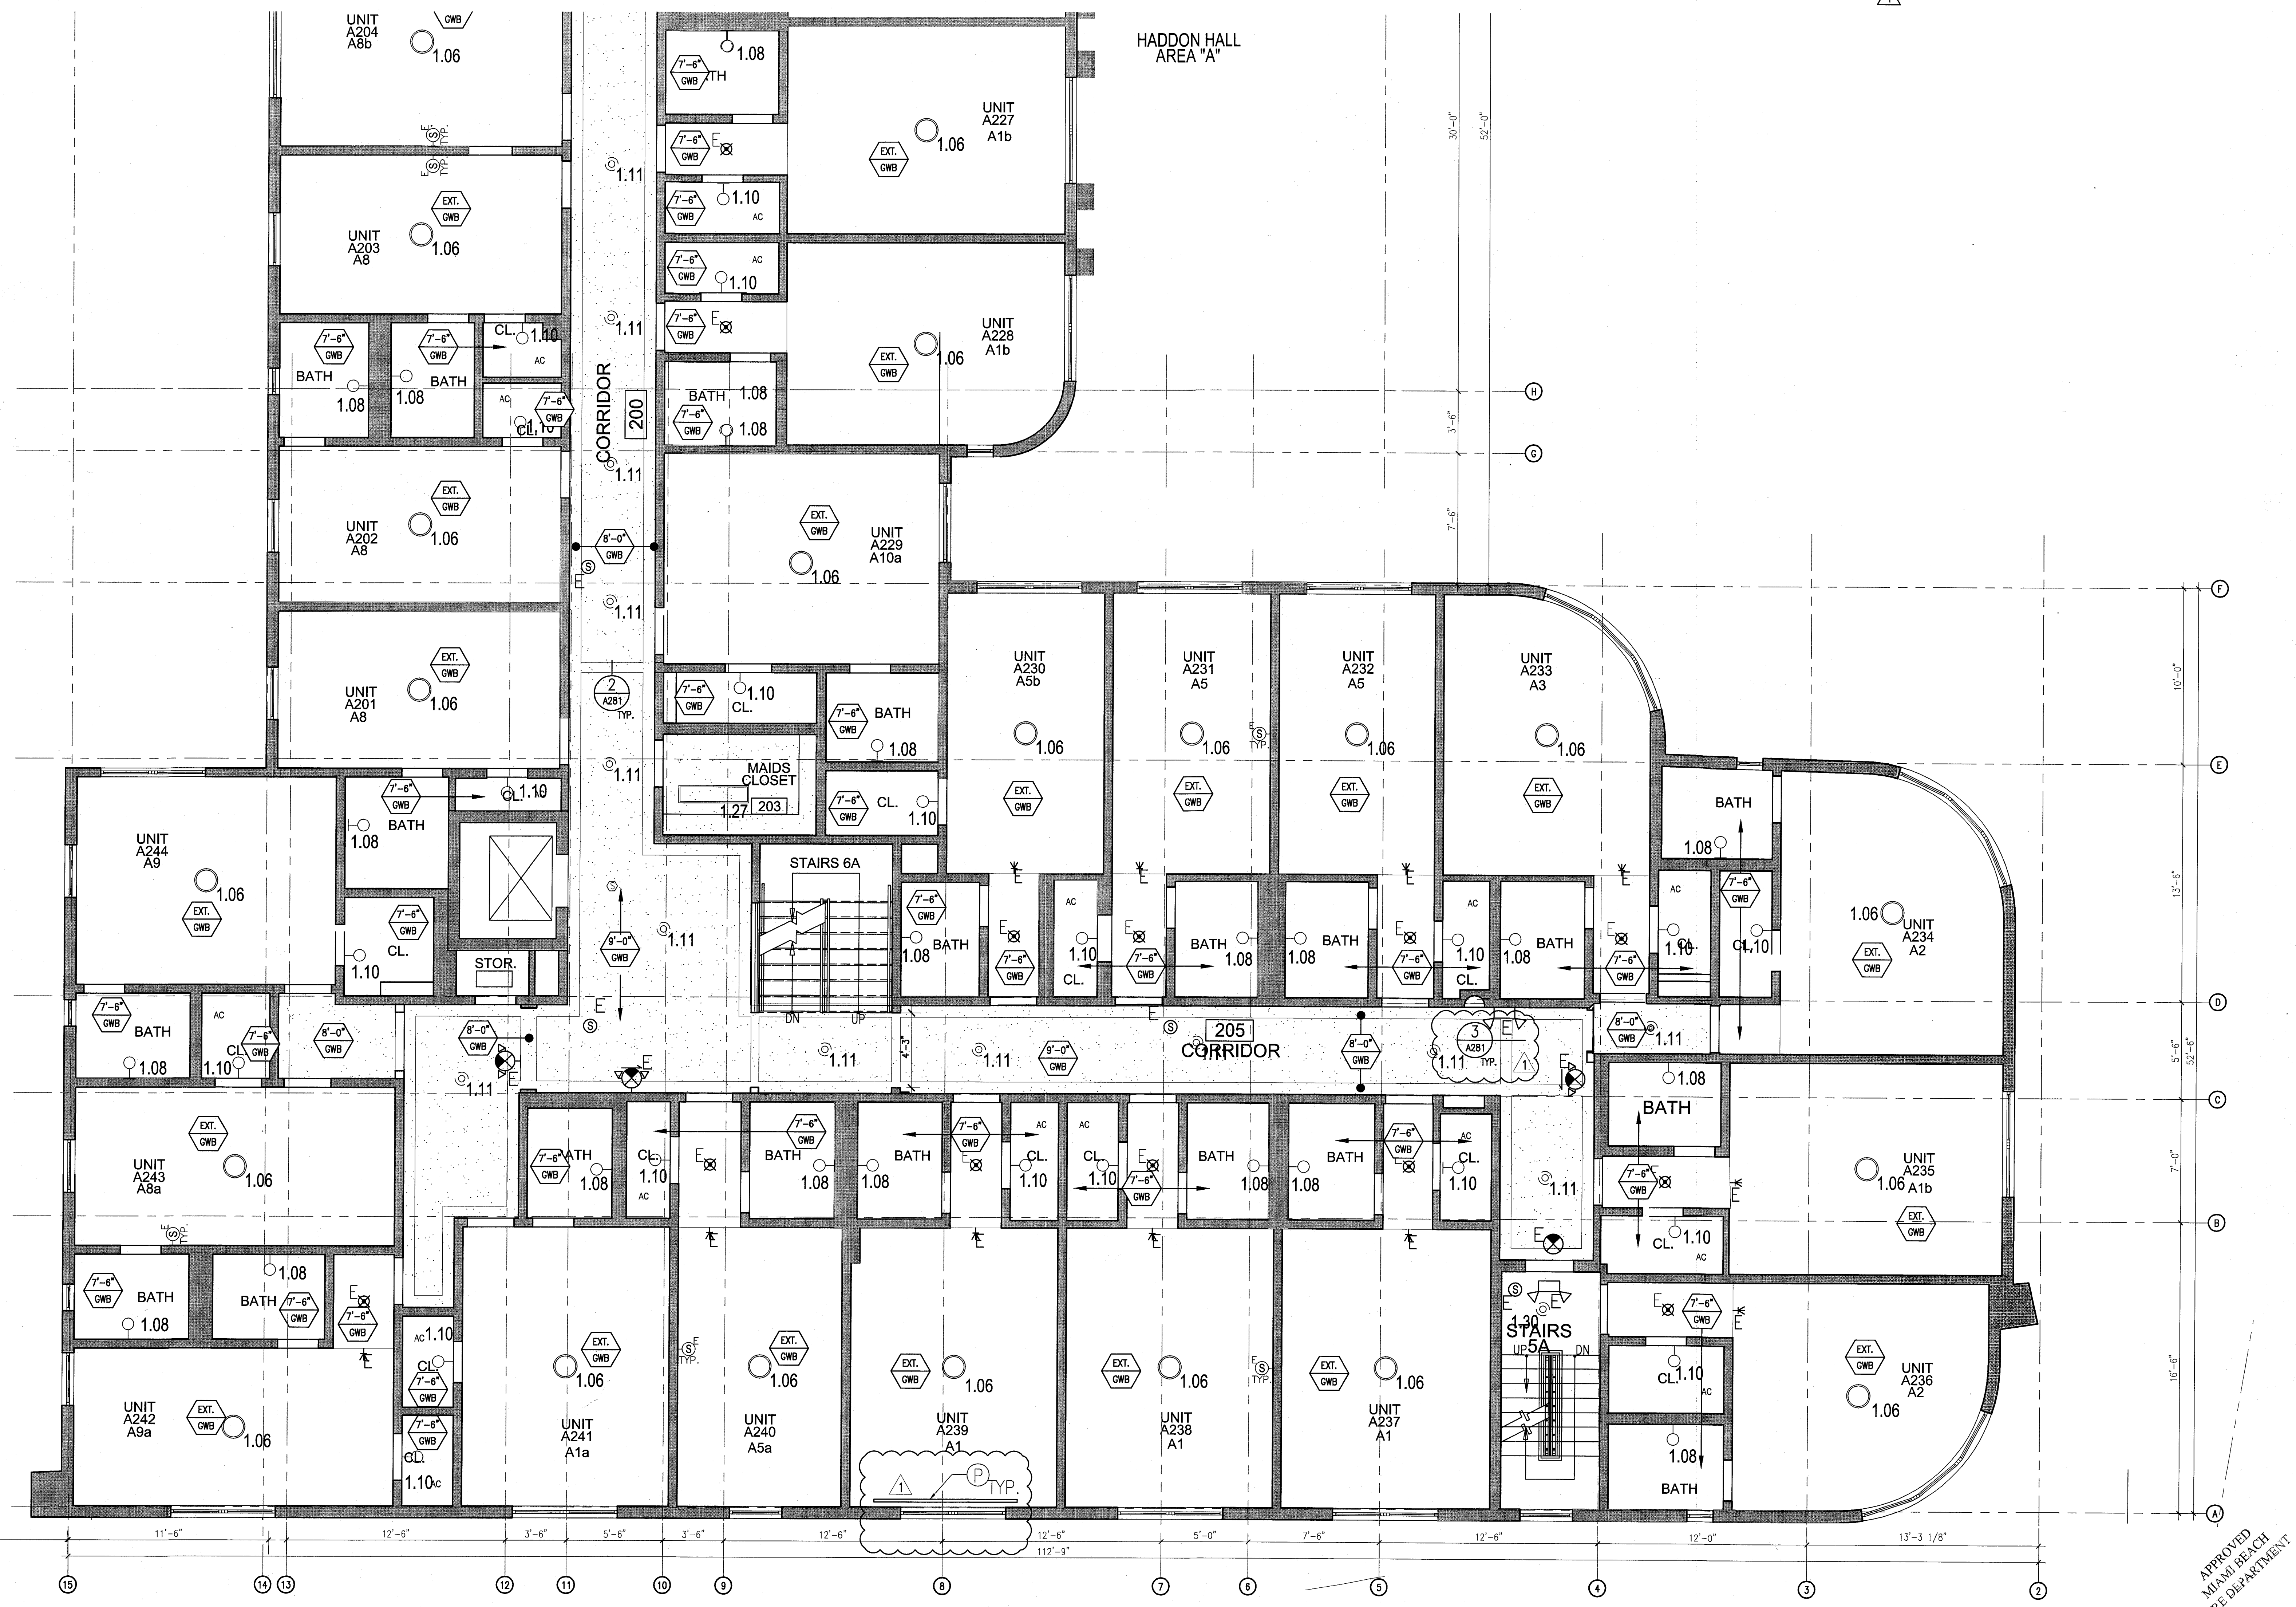


1 ENLARGED SECOND FLOOR REFLECTED CEILING PLAN/HADDON HALL SOUTH
SCALE: 1/4" = 1'-0"

APPROVED
MIAMI BEACH
FIRE DEPARTMENT


[illegible][illegible]

	ON/OFF CEILING SWITCH		BATTERY POWERED
	CEILING LIGHT		LINEAR DIFFUSER
	CEILING TYPE		OCCUPANCY SENSOR
	1' X 6' PENDANT		EXIT SIGN
	DOWNLIGHT		ARROWS INDICATE DIRECTION
	NO STRIP LIGHT		EXIT SIGN - WALL MOUNTED
	EXTENDER/DECORATIVE SCONCE		ARROWS INDICATE DIRECTION
	PENDANT FIXTURE		SMOKE DETECTOR CEILING MOUNTED
	SURFACE MOUNTED FIXTURE		SMOKE DETECTOR WALL MOUNTED
	WALL SCONCE		EXISTING CEILING MOUNTED SPRINKLER
	EXISTING FIXTURE TO BE REPLACED WITH NEW FIXTURE IN SAME LOCATION		SPRINKLER
	EXISTING FIXTURE TO BE REPLACED WITH NEW FIXTURE IN SAME LOCATION		EXISTING WALL MOUNTED SPRINKLER
	EXISTING FIXTURE TO BE REPLACED WITH NEW FIXTURE IN SAME LOCATION		SUPPLY DIFFUSER
	EXISTING FIXTURE TO BE REPLACED WITH NEW FIXTURE IN SAME LOCATION		RETURN AIR GRILLE
	EXISTING FIXTURE TO BE REPLACED WITH NEW FIXTURE IN SAME LOCATION		REPLACE EXISTING FIXTURE WITH NEW FIXTURE IN SAME LOCATION
	EXISTING FIXTURE TO BE REPLACED WITH NEW FIXTURE IN SAME LOCATION		JUNCTION BOX

PLAN	N.T.S.
------	--------

 


RTH SEAI

 

3 NUMBER:	13036.00
-----------	----------


A212b

COPYRIGHT ADD INC 2011

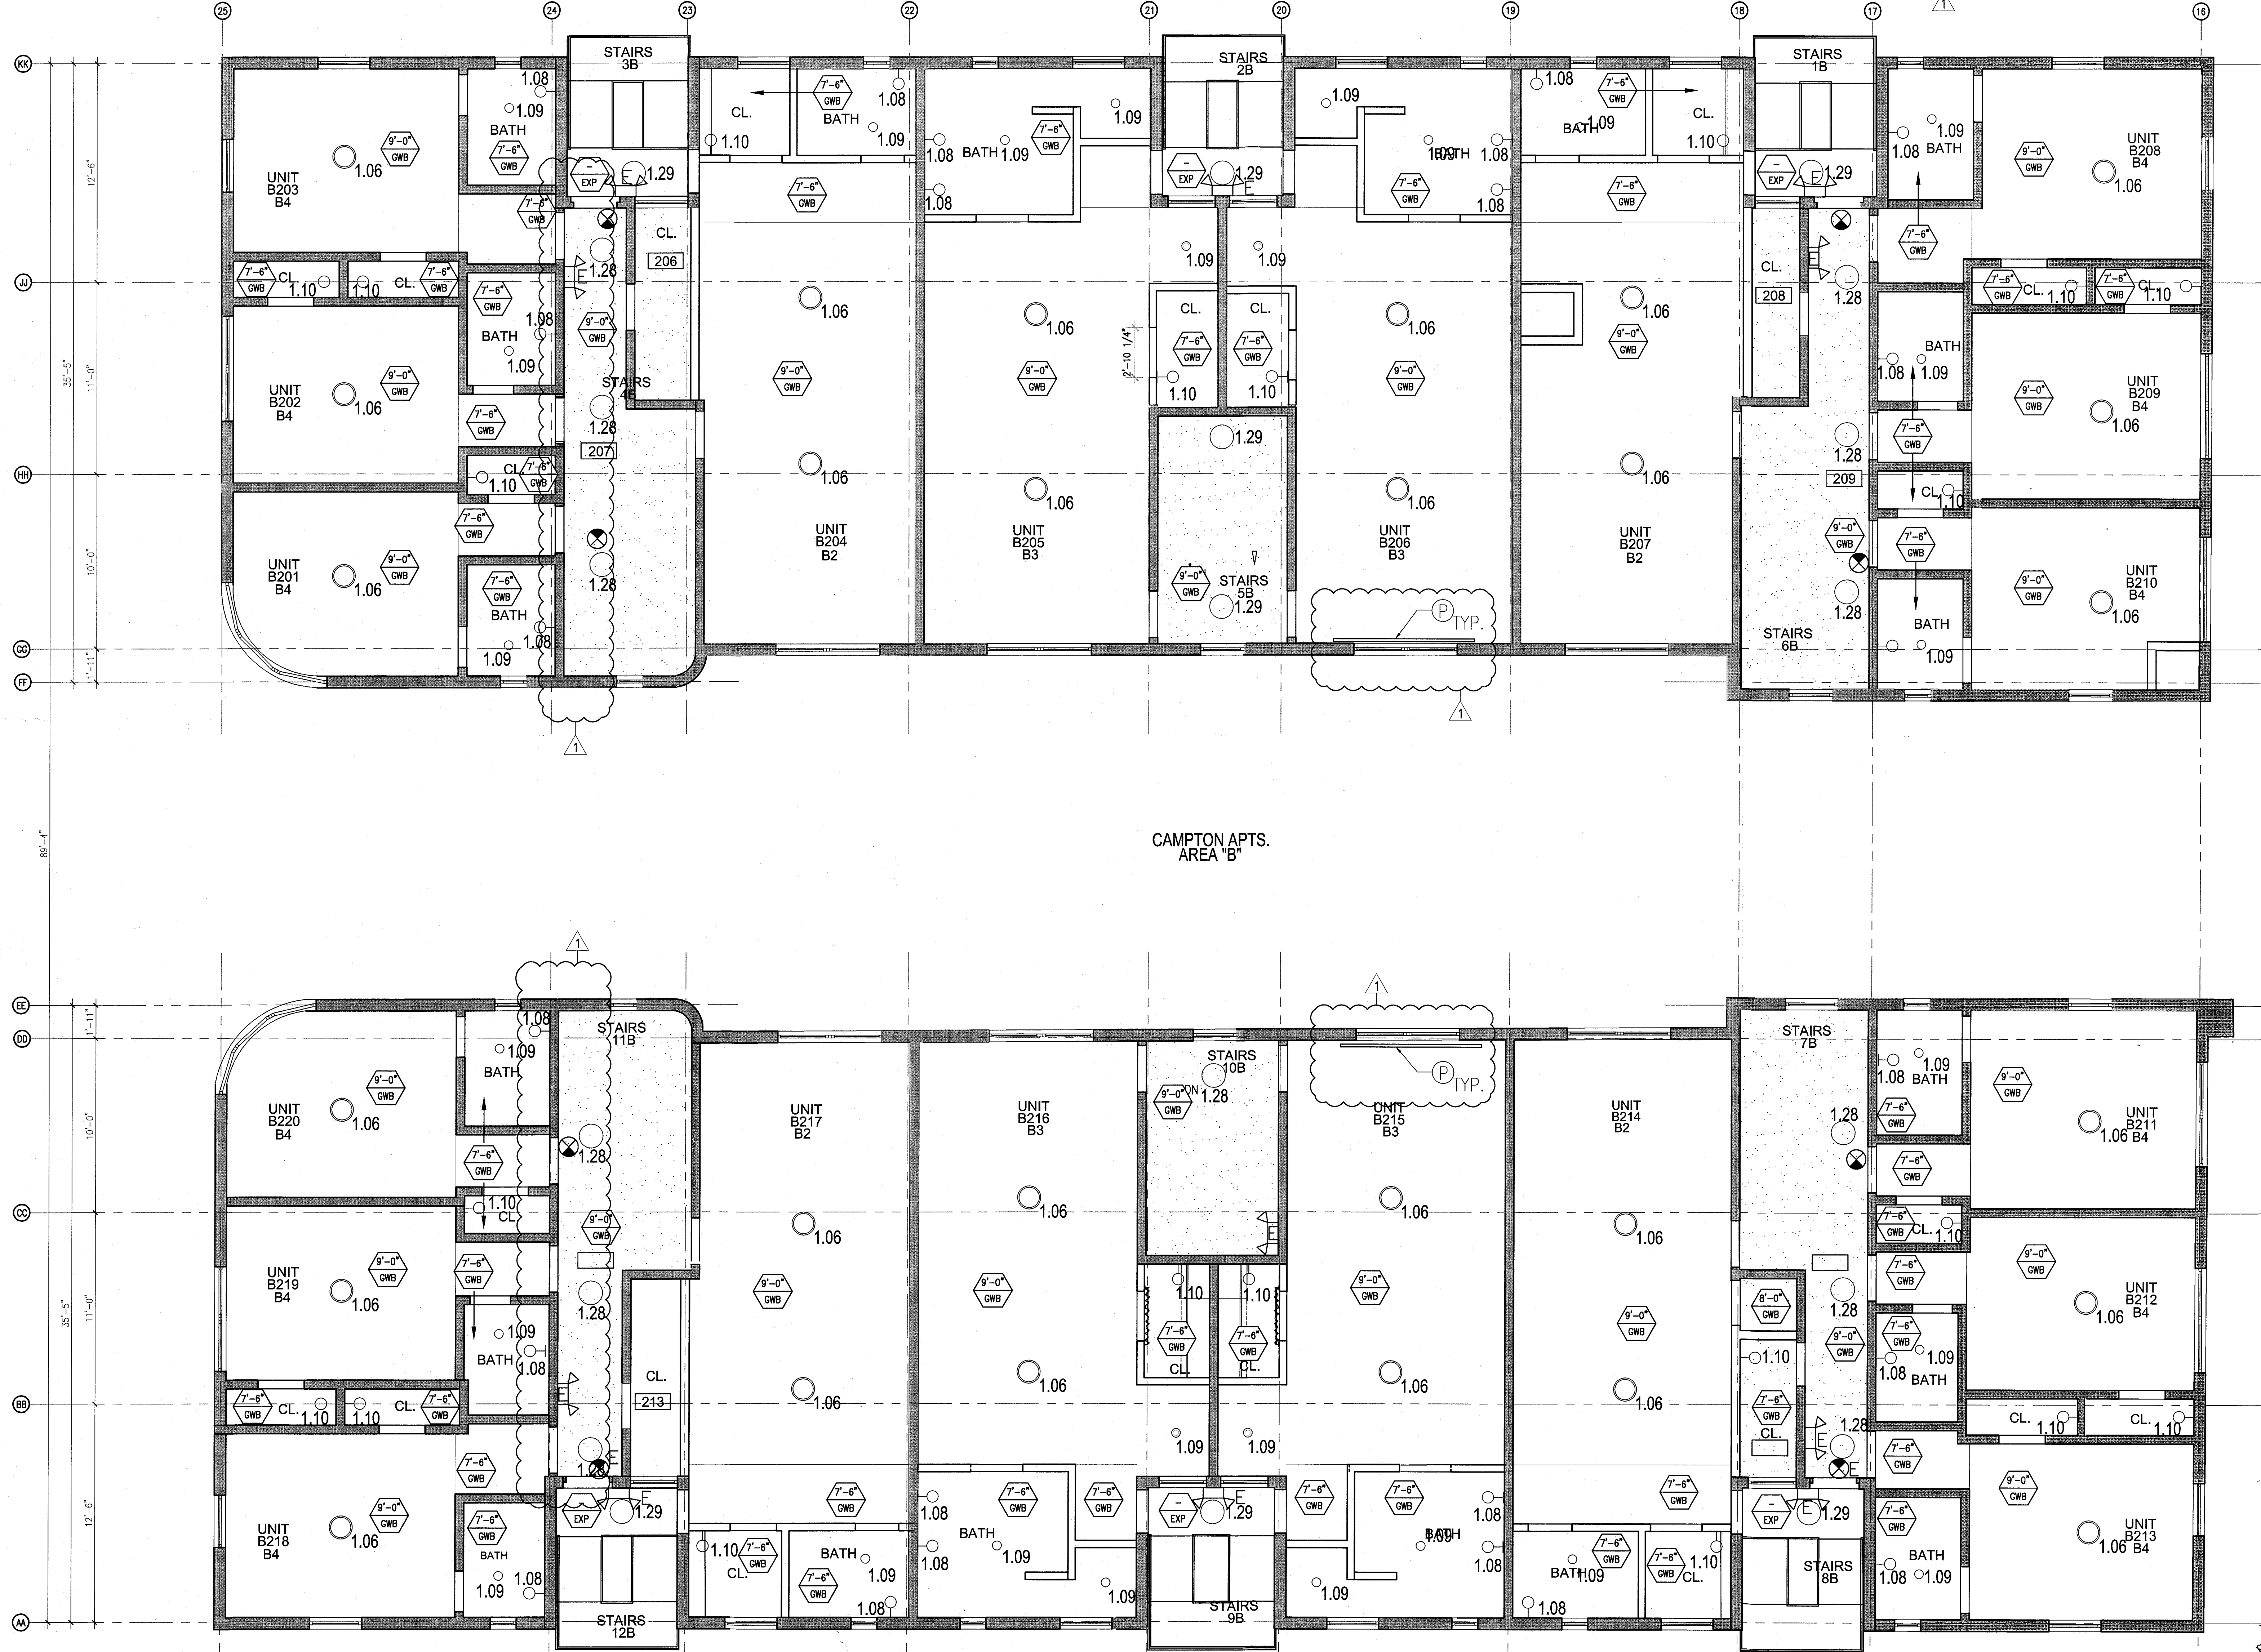

1 ENLARGED CAMPTON APTS. REFLECTED CEILING PLAN - SECOND FLOOR
SCALE: 1/4" = 1'-0"


GENERAL NOTES				SHEET NOTES		LEGEND	
1. NOTIFY THE ARCHITECT OF ANY UNEXPECTED FIELD CONDITION OR ANY DISCREPANCY BEFORE PROCEEDING. GENERAL CONTRACTOR IS TO COORDINATE THE COMPLETE SCOPE OF WORK WITH CONSTRUCTION DOCUMENTS.	7. CAP AND SHUT OFF ALL UNUSED UTILITIES PER CITY AND STATE REQUIREMENTS, WHERE REQUIRED.	13. ALL MEP-PP DEVICE LOCATIONS NOT SHOWN ON DRAWINGS OR IN CONFLICT WITH MEP-PP DRAWINGS, ARE TO BE COORDINATED WITH ARCHITECT PRIOR TO INSTALLATION.	18. CONTRACTOR TO PROVIDE OVERLAY DRAWING OF ELECTRICAL, MECHANICAL, AND PLUMBING SYSTEMS AND COMPONENTS, LIFE SAFETY DEVICES, SMOKE DETECTORS, EMERGENCY LIGHTS AND ANY OTHER DEVICES IN CEILING TO ENSURE NO CONFLICTS.	① ALL EXISTING GYPSUM BOARD CEILING IN, TO BE MAINTAINED AND RESTORED WHERE POSSIBLE. MINIMAL ADDITIONAL SMOKEPROOFING MAY BE REQUIRED.	③ COORDINATE LOCATION OF HANGING CHAIR WITH DESIGNER PRIOR TO INSTALLATION. ADDITIONAL SMOKEPROOFING MAY BE REQUIRED.	⬆ BATTERY POWERED WALL MOUNTED LINEAR DIFFUSER	⬆ OCCUPANCY SENSOR
2. NO WORK FRAMING OR STRUCTURAL MEMBERS ARE TO BE MODIFIED, ALTERED OR CUT WITH OUT THE APPROVAL OF THE ARCHITECT AND BUILDING MANAGEMENT.	8. FIRE ALARM DEVICES (SMOKE DETECTORS, HORNS, STROBES AND EXIT SIGNS) WITHIN DEMO SPACE SHALL REMAIN CONNECTED TO EXISTING SYSTEMS. SECURE DEVICES AS NECESSARY TO KEEP FROM HANGING FREELY UPON REMOVAL OF WALLS+CEILINGS.	14. SHUTDOWN OF EXISTING SYSTEMS FOR CONNECTION TO EXISTING SERVICES SHALL BE COORDINATED WITH THE CONSTRUCTION MANAGER AND BUILDING OWNER. THE CONTRACTOR SHALL SUBMIT REQUESTS WHERE THEY AFFECT THE OPERATION OF THE BUILDING SYSTEMS, AT LEAST ONE WEEK IN ADVANCE OF ANY REQUIRED SHUTDOWN. THE ACTUAL SHUTDOWN PERIOD SHALL BE AS SHORT AS POSSIBLE AND AT A TIME MUTUALLY AGREEABLE TO THE BUILDING OWNER AND THE CONSTRUCTION MANAGER.	19. SPRINKLER HEADS SHOWN FOR ARCHITECTURAL DESIGN INTENT ONLY. NOT FOR CODE DISTRIBUTION. SEE FIRE PROTECTION DRAWINGS FOR DISTRIBUTION AND CALCULATIONS.	② ALL EXISTING LIGHT FIXTURES IN HADDON HALL TO BE REMOVED AND REPLACED IN SAME LOCATION UNLESS OTHERWISE NOTED.	④ ALL GENERAL CEILING AND SUFFITS TO BE PAINTED PT-07 (FLAT FINISH) U.O.N. ALL CLOSETROOM AND PUBLIC RESTROOMS CEILING TO BE PAINTED PT-01 (EGGSHELL FINISH).	⬆ DOWNLIGHT	⬆ LED STRIP LIGHT
3. REVIEW BUILDING STANDARDS MANUAL PROVIDED BY THE BUILDING PROPERTY MANAGER BEFORE PROCEEDING WITH WORK.	9. PROTECT ALL BASE BUILDING SERVICES, TYPICAL.	15. ALL WORK SHALL COMPLY WITH FEDERAL, STATE, AND LOCAL BUILDING CODES.	20. CONTRACTOR WILL NOTIFY ARCHITECT IMMEDIATELY OF ANY CONFLICTS BETWEEN ARCHITECTURE AND ENGINEERING DRAWINGS.	③ FOR HOTEL ROOMS ROPS REFER TO SHEETS A801-918.	⑤ LED STRIP LIGHTING SHOWN ON PLAN WITH NOTE AS PLUG-IN RECEPTACLE AT ALL.	⬆ EXTERIOR/DECORATIVE SCIENCE	⬆ PENDANT FIXTURE
4. PROVIDE TEMPORARY SECURE ACCESS TO SPACE THROUGH CONSTRUCTION AND TEMPORARY LIGHT & POWER.	10. ALL REQUIREMENTS FOR FIRE RATINGS TO BE MAINTAINED DURING CONSTRUCTION.	16. G.C. TO COORDINATE ALL AUDIO/VISUAL EQUIPMENT NEEDS WITH CLIENT.	21. THE CONTRACTOR SHALL INSPECT THE EXISTING FIELD CONDITIONS AT THE SITE PRIOR TO THE START OF ANY WORK TO DETERMINE WHAT EFFECT THE EXISTING CONDITIONS WILL HAVE ON HIS WORK. POTENTIAL PROBLEM AREAS SHALL BE BROUGHT TO THE ATTN. OF THE ARCHITECT AND/OR ENGINEER IMMEDIATELY.	④ EXISTING HISTORIC SUFFIT AREAS IN HADDON HALL CEILING FLOOR COMMON AREA TO BE LEFT AND RESIGNED.	⑥ ALL LIGHT FIXTURES IN CAMPHOR APARTMENTS AND POOL SUITES TO BE NEW AND CENTERED IN SPACE U.O.N.	⬆ SURFACE MOUNTED FIXTURE	⬆ WALL SCONCE
5. PROVIDE STRICT CONTROL OF JOB CLEANING AND PROTECT DUST AND DEBRIS FROM EMANATING FROM CONSTRUCTION AREA.	11. THIS PROJECT INVOLVES CONSTRUCTION INSIDE AN EXISTING STRUCTURE. CONTRACTORS, BY SUBMITTING A BID, ARE DEEMED TO BE COMPLETELY FAMILIAR WITH THE EXISTING CONDITION OF THE BUILDING AS IT INFLUENCES THE WORK DESCRIBED. ABSOLUTELY NO CLAIMS FOR EXTRA COMPENSATION WILL BE CONSIDERED FOR EXISTING CONDITIONS VISIBLE OR REASONABLY IMPRISON FROM A CAREFUL EXAMINATION OF THE EXISTING BLDG.	17. BOTTOM OF ALL HANGING FIXTURES TO BE NO LOWER THAN 7'-0" AFF.	22. REFER TO SHEETS E1.00 FOR ELECTRICAL DRAWINGS AND FOR SERIES FOR FIRE SPRINKLER DRAWINGS.	⑤ EXISTING EXPOSED SPRINKLER PIPES IN HADDON HALL BUILDING TO BE COVERED WITH NEW PERIMETER SUFFIT AREA AT ALL CORNERS.	⑦ 1"x4" MOUNTED TO CEILING IN FRONT OF WINDOWS TO ACT AS VALANCE TO CONCEAL SUNSHY ROLL. TYP. TO BE PAINTED PT-07. SIZES VARY, VERIFY IN FIELD.	⬆ NEW LIGHT FIXTURE	⬆ DEMO LIGHT FIXTURE
6. DEBRIS REMOVAL MUST BE DONE USING THE FREIGHT ELEVATOR. CONTACT BUILDING MANAGEMENT OFFICE TO OBTAIN SCHEDULE FOR USE OF FREIGHT ELEVATORS PRIOR TO SUBMITTING BID. ALL DEBRIS REMOVAL MUST BE PERFORMED IN ACCORDANCE WITH BUILDING MANAGEMENT REQUIREMENTS AND PROCEDURES. CONTRACTOR TO COORDINATE WITH BUILDING MANAGEMENT TO OBTAIN MOST RECENT REQUIREMENTS FOR DEBRIS REMOVAL.	12. ELECTRICAL DEVICES SHALL BE TERMINATED IN A SAFE AND PROPER METHOD BY A LICENSED PROFESSIONAL.			⑥ CENTER LIGHT FIXTURE IN SPACE U.O.N.	⑧ REFER TO A-281 FOR LIGHTING FIXTURE SCHEDULE.	⬆ 4-BOX FOR FUTURE LED BACKLIGHT FOR TUBE SCREEN	

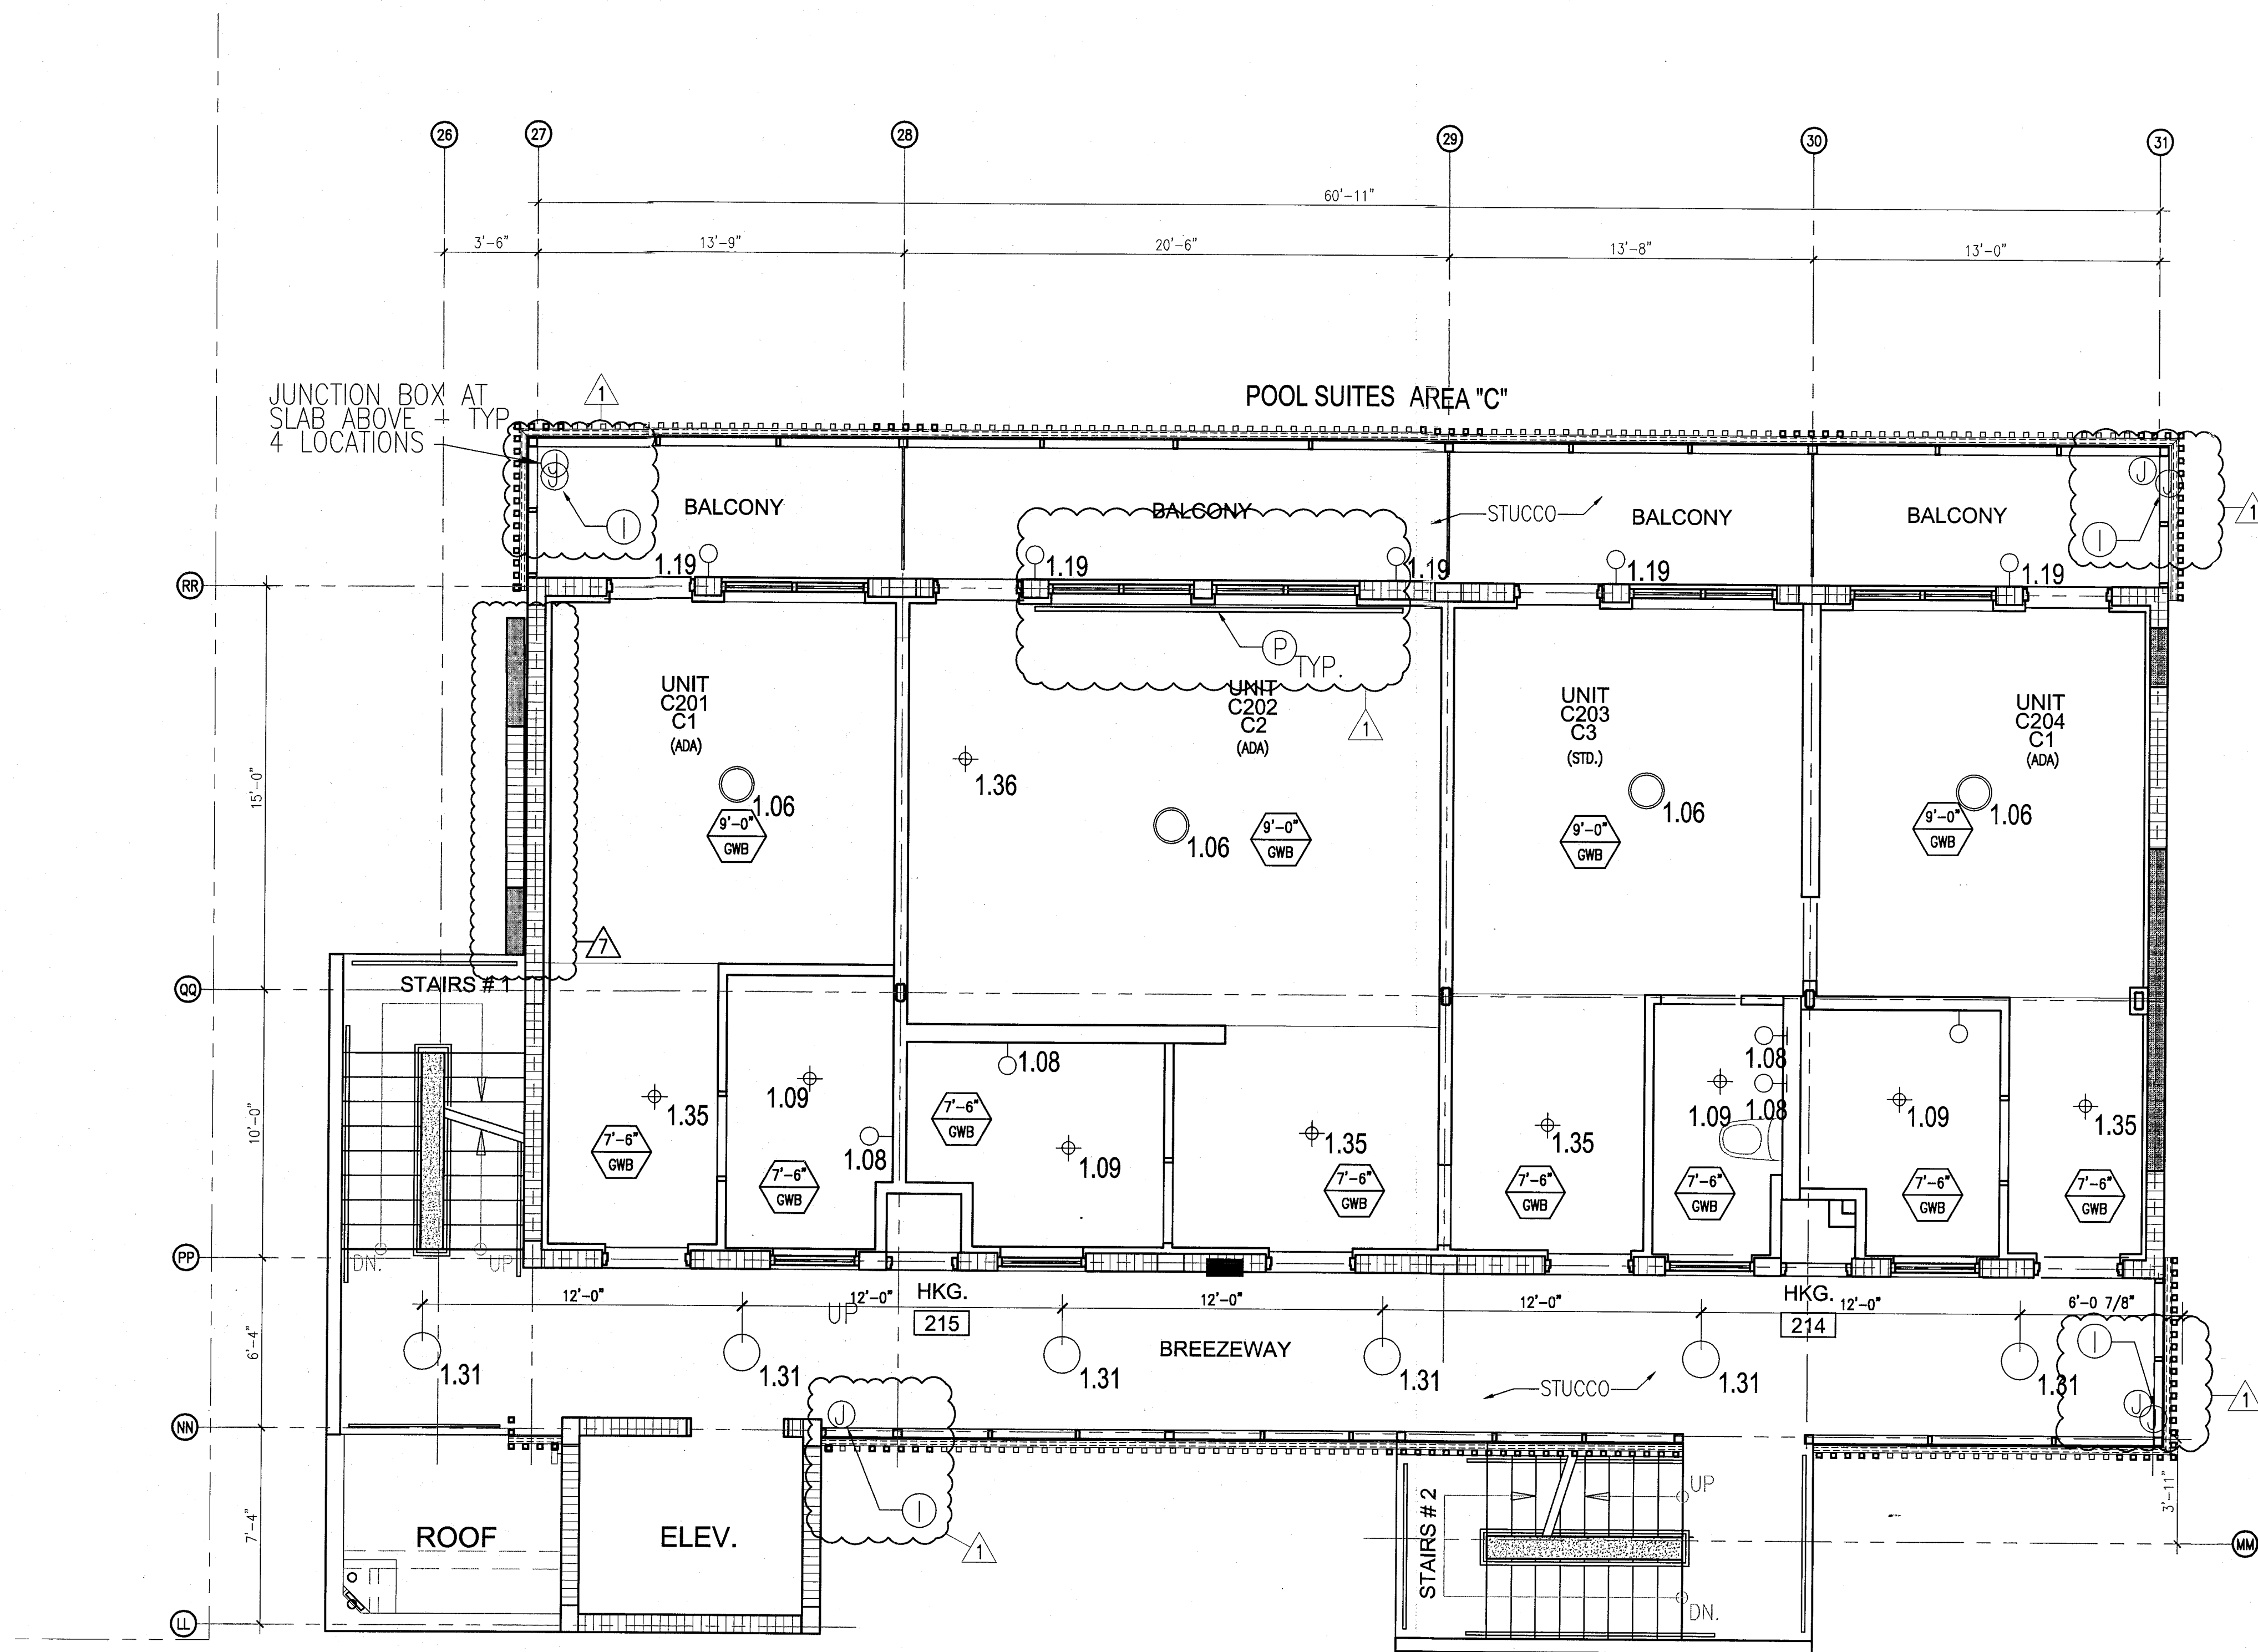

1 ENLARGED POOL SUITES REFLECTED CEILING PLAN - SECOND FLOOR
SCALE: 1/4" = 1'-0"

HADDON HALL
1500 COLLINS AVE
MIAMI BEACH, FL

KEYPLAN N.T.S.

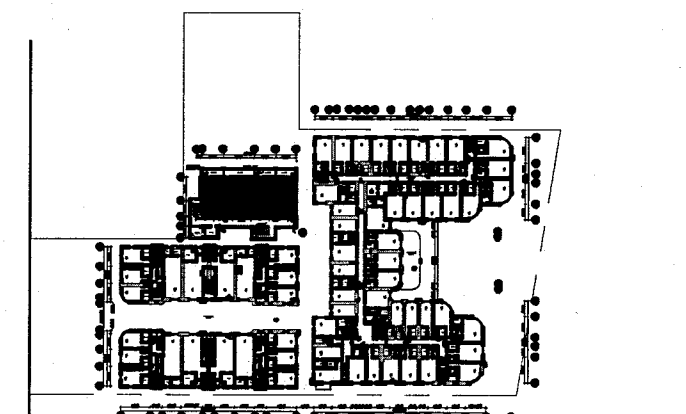

REVISIONS		
NO.	DESCRIPTION	ISSUE DATE
1	PROGRESS TO 100% CD	02-18-2014
2	POOL SUITES WALLS	04-14-2014
3	MASTER PERMIT COMMENTS	07-03-2014

PRIVATE PROVIDER SERVICES, LLC Construction Plans Review, Inspection, Testing & Consulting			
BUILDING	REVIEWER INITIALS	DATE REVIEWED	
STRUCTURAL	EM	11-16-14	
MECHANICAL			
ELECTRICAL			
PLUMBING			
SITE CIVIL			

100% CONSTRUCTION DOCUMENT SET

NORTH	SEAL

ADD Inc Architecture Interiors Planning

One Biscayne Tower
Suite 1670
Two South
Biscayne Boulevard
Miami, FL 33131
T. 305.482.8700
F. 305.482.8770
www.addinc.com
Lic. # A-29001507

JOB NUMBER: 13036.00
CHECKED BY:
ISSUE DATE: FEBRUARY 18, 2014
SCALE: 1/4" = 1'-0"

SHEET TITLE

ENLARGED POOL SUITES REFLECTED CEILING PLAN SECOND FLOOR

SHEET NUMBER

A212c

COPYRIGHT ADD INC 2011

APPROVED
MIAMI BEACH
FIRE DEPARTMENT

GENERAL NOTES

- NOTIFY THE ARCHITECT OF ANY UNEXPECTED FIELD CONDITION OR ANY DISCREPANCY BEFORE PROCEEDING. GENERAL CONTRACTOR IS TO COORDINATE THE COMPLETE SCOPE OF WORK WITH CONSTRUCTION DOCUMENTS.
- NO MAIN FRAMING OR STRUCTURAL MEMBERS ARE TO BE MOVED, ALTERED, OR CUT WITH OUT THE APPROVAL OF THE ARCHITECT AND BUILDING DEPARTMENT.
- REVIEW BUILDING STANDARD MANUAL PROVIDED BY THE BUILDING DEPARTMENT BEFORE PROCEEDING WITH WORK.
- PROVIDE TEMPORARY SECURE ACCESS TO SPACE THROUGH CONSTRUCTION AND TEMPORARY LIGHT & POWER.
- PROVIDE STRICT CONTROL OF JOB CLEANING AND PREVENT DUST AND DEBRIS FROM EXHAUSTING FROM CONSTRUCTION AREA.
- DEBRIS REMOVAL MUST BE DONE USING THE FREIGHT ELEVATOR. CONTACT BUILDING MANAGEMENT OFFICE TO OBTAIN SCHEDULE FOR USE OF FREIGHT ELEVATORS PRIOR TO SCHEDULING. ALL DEBRIS REMOVAL MUST BE PERFORMED IN ACCORDANCE WITH BUILDING MANAGEMENT REQUIREMENTS AND PROCEDURES. CONTRACTOR TO COORDINATE WITH BUILDING MANAGEMENT TO OBTAIN MOST RECENT REQUIREMENTS FOR DEBRIS REMOVAL.
- CAP AND SHUT OFF ALL UNUSED UTILITIES PER CITY AND STATE REQUIREMENTS, WHERE REQUIRED.
- FIRE ALARM DEVICES (SMOKE DETECTORS, HORNS, STROBES AND EXT SENS) WITHIN DEMO SPACE SHALL REMAIN CONNECTED TO EXISTING SYSTEMS. SECURE DEVICES AS NECESSARY TO KEEP FROM HANGING FREELY UPON REMOVAL OF WALLS/CEILING.
- PROTECT ALL BASE BUILDING SERVICES, TYPICAL.
- ALL REQUIREMENTS FOR FIRE RATINGS TO BE MAINTAINED DURING CONSTRUCTION.
- THIS PROJECT INVOLVES CONSTRUCTION INSIDE AN EXISTING STRUCTURE. CONTRACTORS, BY SUBMITTING A BID, ARE DEEMED TO BE COMPLETELY FAMILIAR WITH THE EXISTING CONDITION OF THE BUILDING AS IT INFLUENCES THE WORK DESCRIBED. ABSOLUTELY NO CLAIM FOR OTHER COMPENSATION WILL BE CONSIDERED FOR EXISTING CONDITIONS UNLESS ON REASONABLY INFERABLE FROM A CAREFUL EXAMINATION OF THE EXISTING BLDG.
- ELECTRICAL DEVICES SHALL BE TERMINATED IN A SAFE AND PROPER METHOD BY A LICENSED PROFESSIONAL.
- ALL MEP-PP DEVICES LOCATIONS NOT SHOWN ON DRAWING OR IN CONFLICT WITH MEP-PP DRAWINGS, ARE TO BE COORDINATED WITH ARCHITECT PRIOR TO INSTALLATION.
- SHUTDOWN OF EXISTING SYSTEMS FOR CONNECTION TO EXISTING SERVICES SHALL BE COORDINATED WITH THE CONTRACTOR MANAGER AND BUILDING OWNER. THE CONTRACTOR SHALL SUBMIT REQUESTS, WHERE THEY AFFECT THE OPERATION OF THE BUILDING SYSTEMS, AT LEAST ONE WEEK IN ADVANCE OF ANY REQUIRED SHUTDOWN. THE ACTUAL SHUTDOWN PERIOD SHALL BE AS SHORT AS POSSIBLE AND AT A TIME MUTUALLY AGREEABLE TO THE BUILDING OWNER AND THE CONSTRUCTION MANAGER.
- ALL WORK SHALL COMPLY WITH FEDERAL STATE, AND LOCAL BUILDING CODES.
- G.C. TO COORDINATE ALL AUDIO/VISUAL EQUIPMENT NEEDS WITH CLIENT.
- BOTTOM OF ALL HANGING FIXTURES TO BE NO LOWER THAN 7'-0" AFF.
- CONTRACTOR TO PROVIDE OVERLAY DRAWING OF ELECTRICAL FIXTURES, MECA SYSTEMS AND COMPONENTS, LIFE SCHED. DEVICES, SMOKE DETECTORS, EMERGENCY LIGHTS AND ANY OTHER DEVICES IN CEILING TO ENSURE NO CONFLICTS.
- SPRINKLER HEADS SHOWN FOR ARCHITECTURAL DESIGN INTENT ONLY. NOT FOR CODE DISTRIBUTION. SEE FIRE PROTECTION DRAWINGS FOR DISTRIBUTION AND CALCULATIONS.
- CONTRACTOR WILL NOTIFY ARCHITECT IMMEDIATELY OF ANY CONFLICTS BETWEEN ARCHITECTURE AND ENGINEERING DRAWINGS.
- THE CONTRACTOR SHALL INSPECT THE EXISTING FIELD CONDITIONS AT THE SITE PRIOR TO THE START OF ANY WORK TO DETERMINE WHAT EFFECT THE EXISTING CONDITIONS WILL HAVE ON HIS WORK. POTENTIAL PROBLEM AREAS SHALL BE BROUGHT TO THE ATTN. OF THE ARCHITECT AND/OR ENGINEER IMMEDIATELY.
- REFER TO SHEETS E-100 FOR ELECTRICAL DRAWINGS AND PP-SERIES FOR FIRE SPRINKLER DRAWINGS.

SHEET NOTES

- ALL EXISTING GYPSON BOARD CEILING IN TO BE MAINTAINED AND RESTORED WHERE POSSIBLE. MINIMAL DEMOLITION FOR ADDITION OF NEW HVAC GRILLES AND SUFFIT AREAS.
- ALL EXISTING LIGHT FIXTURES IN HADDON HALL TO BE REMOVED AND REPLACED IN SAME LOCATION UNLESS OTHERWISE NOTED.
- FOR HOTEL ROOMS ROPS REFER TO SHEETS A201-218.
- FOR OUTDOOR AREA LIGHTING REFER TO LANDSCAPE PLANS.
- EXISTING EXPOSED SPRINKLER PIPES IN HADDON HALL BUILDING TO BE COVERED WITH NEW PERIMETER SUFFIT AREA AT ALL CORRIDORS.
- CENTER LIGHT FIXTURE IN SPACE U.O.N.
- REFER TO A-281 FOR LIGHTING FIXTURE SCHEDULE.
- J-BLOCK FOR FUTURE LED BACKLIGHT FOR TUBE SCREEN.
- COORDINATE LOCATION OF HANGING CHAIR WITH DESIGNER PRIOR TO INSTALLATION. ADDITIONAL BUILDING MAY BE REQUIRED.
- ALL GENERAL CEILING AND SUFFIT TO BE PAINTED PT-07 (FLAT FINISH), U.O.N. ALL GUESTROOM AND PUBLIC RESTROOMS CEILING TO BE PAINTED PT-01 (EGG SHELL FINISH).
- LED STRIP LIGHTING SHOWN ON PLAN WITH NOTE AS PLUG-IN RECEPTACLE AT ALL.
- ALL LIGHT FIXTURES IN CAMPION APARTMENTS AND POOL SUITES TO BE NEW AND CENTERED IN SPACE U.O.N.
- WALL SCONES SHOWN ON PLAN. ALL WALL SCONES IN HADDON HALL GUESTROOMS WILL REPLACE EXISTING IN SAME LOCATION. ALL SCONES IN CAMPION AND POOL SUITES NEW. REFER TO GUESTROOM ELEVATIONS FOR SCHEDULE.
- 1"x4" MOUNTED TO CEILING IN FRONT OF WINDOWS TO ACT AS VALANCE TO CONSIDER SHADOWS FROM WINDOWS. 1"x4" TO BE PAINTED PT-07. SEE'S VERY VERY IN FIELD.

LEGEND

- GWB CEILING/SUFFIT
- CEILING HEIGHT KEY
- CEILING TYPE
- CEILING HEIGHT - AFF
- 1" X 4" PENDANT
- DOWNLIGHT
- LED STRIP LIGHT
- EXTERIOR/ACCENT SCONES
- PENDANT FIXTURE
- SURFACE MOUNTED FIXTURE
- WALL SCONES
- EXISTING FIXTURE TO BE REMOVED WITH NEW FIXTURE IN SAME LOCATION
- NEW LIGHT FIXTURE
- DEMO LIGHT FIXTURE
- BATTERY POWERED WALL MOUNTED
- LINEAR OFFICER
- OCCUPANCY SENSOR
- EXT. SGN - WALL MOUNTED
- SMOKE DETECTOR CEILING MOUNTED
- SMOKE DETECTOR WALL MOUNTED
- EXISTING CEILING MOUNTED SPRINKLER
- SPRINKLER
- EXISTING WALL MOUNTED SPRINKLER
- SUPPLY OFFICER
- RETURN AIR GRILLE
- REPLACE EXISTING FIXTURE WITH NEW LIGHT FIXTURE
- JUNCTION BOX

NOTE: CEILING AT EXISTING HADDON HALL GUESTROOMS ARE EXISTING TO REMAIN AT 9'-0" A.F.F. UNLESS OTHERWISE NOTED

HADDON HALL
1500 COLLINS AVE
MIAMI BEACH, FL

KEYPLAN N.T.S.

NO.	DESCRIPTION	ISSUE DATE
1	PROGRESS TO 100% CD	02-18-2014
4	FIRE REVIEW COMMENTS	04-09-2014
10	MASTER PERMIT COMMENTS	07-03-2014

PRIVATE PROVIDER SERVICES, LLC			
Construction Plans Manager, Project Manager, Testing & Consulting			
BUILDING	REVIEWER	DATE	REVIEWED
STRUCTURAL	EM	11-10-14	
MECHANICAL			
ELECTRICAL			
PLUMBING			
SITE CIVIL			

100% CONSTRUCTION DOCUMENT SET

NORTH	SEAL

ADD Inc

Architecture Interiors Planning
One Biscayne Tower
Suite 1670
Two South
Biscayne Boulevard
Miami, FL 33131
T. 305.482.8700
www.addinc.com
Lic. # AA26001507
Boston Miami

JOB NUMBER: 13036.00
CHECKED BY:
ISSUE DATE: FEBRUARY 18, 2014
SCALE: 1/4" = 1'-0"


SHEET TITLE

ENLARGED HADDON HALL REFLECTED CEILING PLAN
THIRD FLOOR - NORTH

SHEET NUMBER

A213a1

COPYRIGHT ADD INC 2011

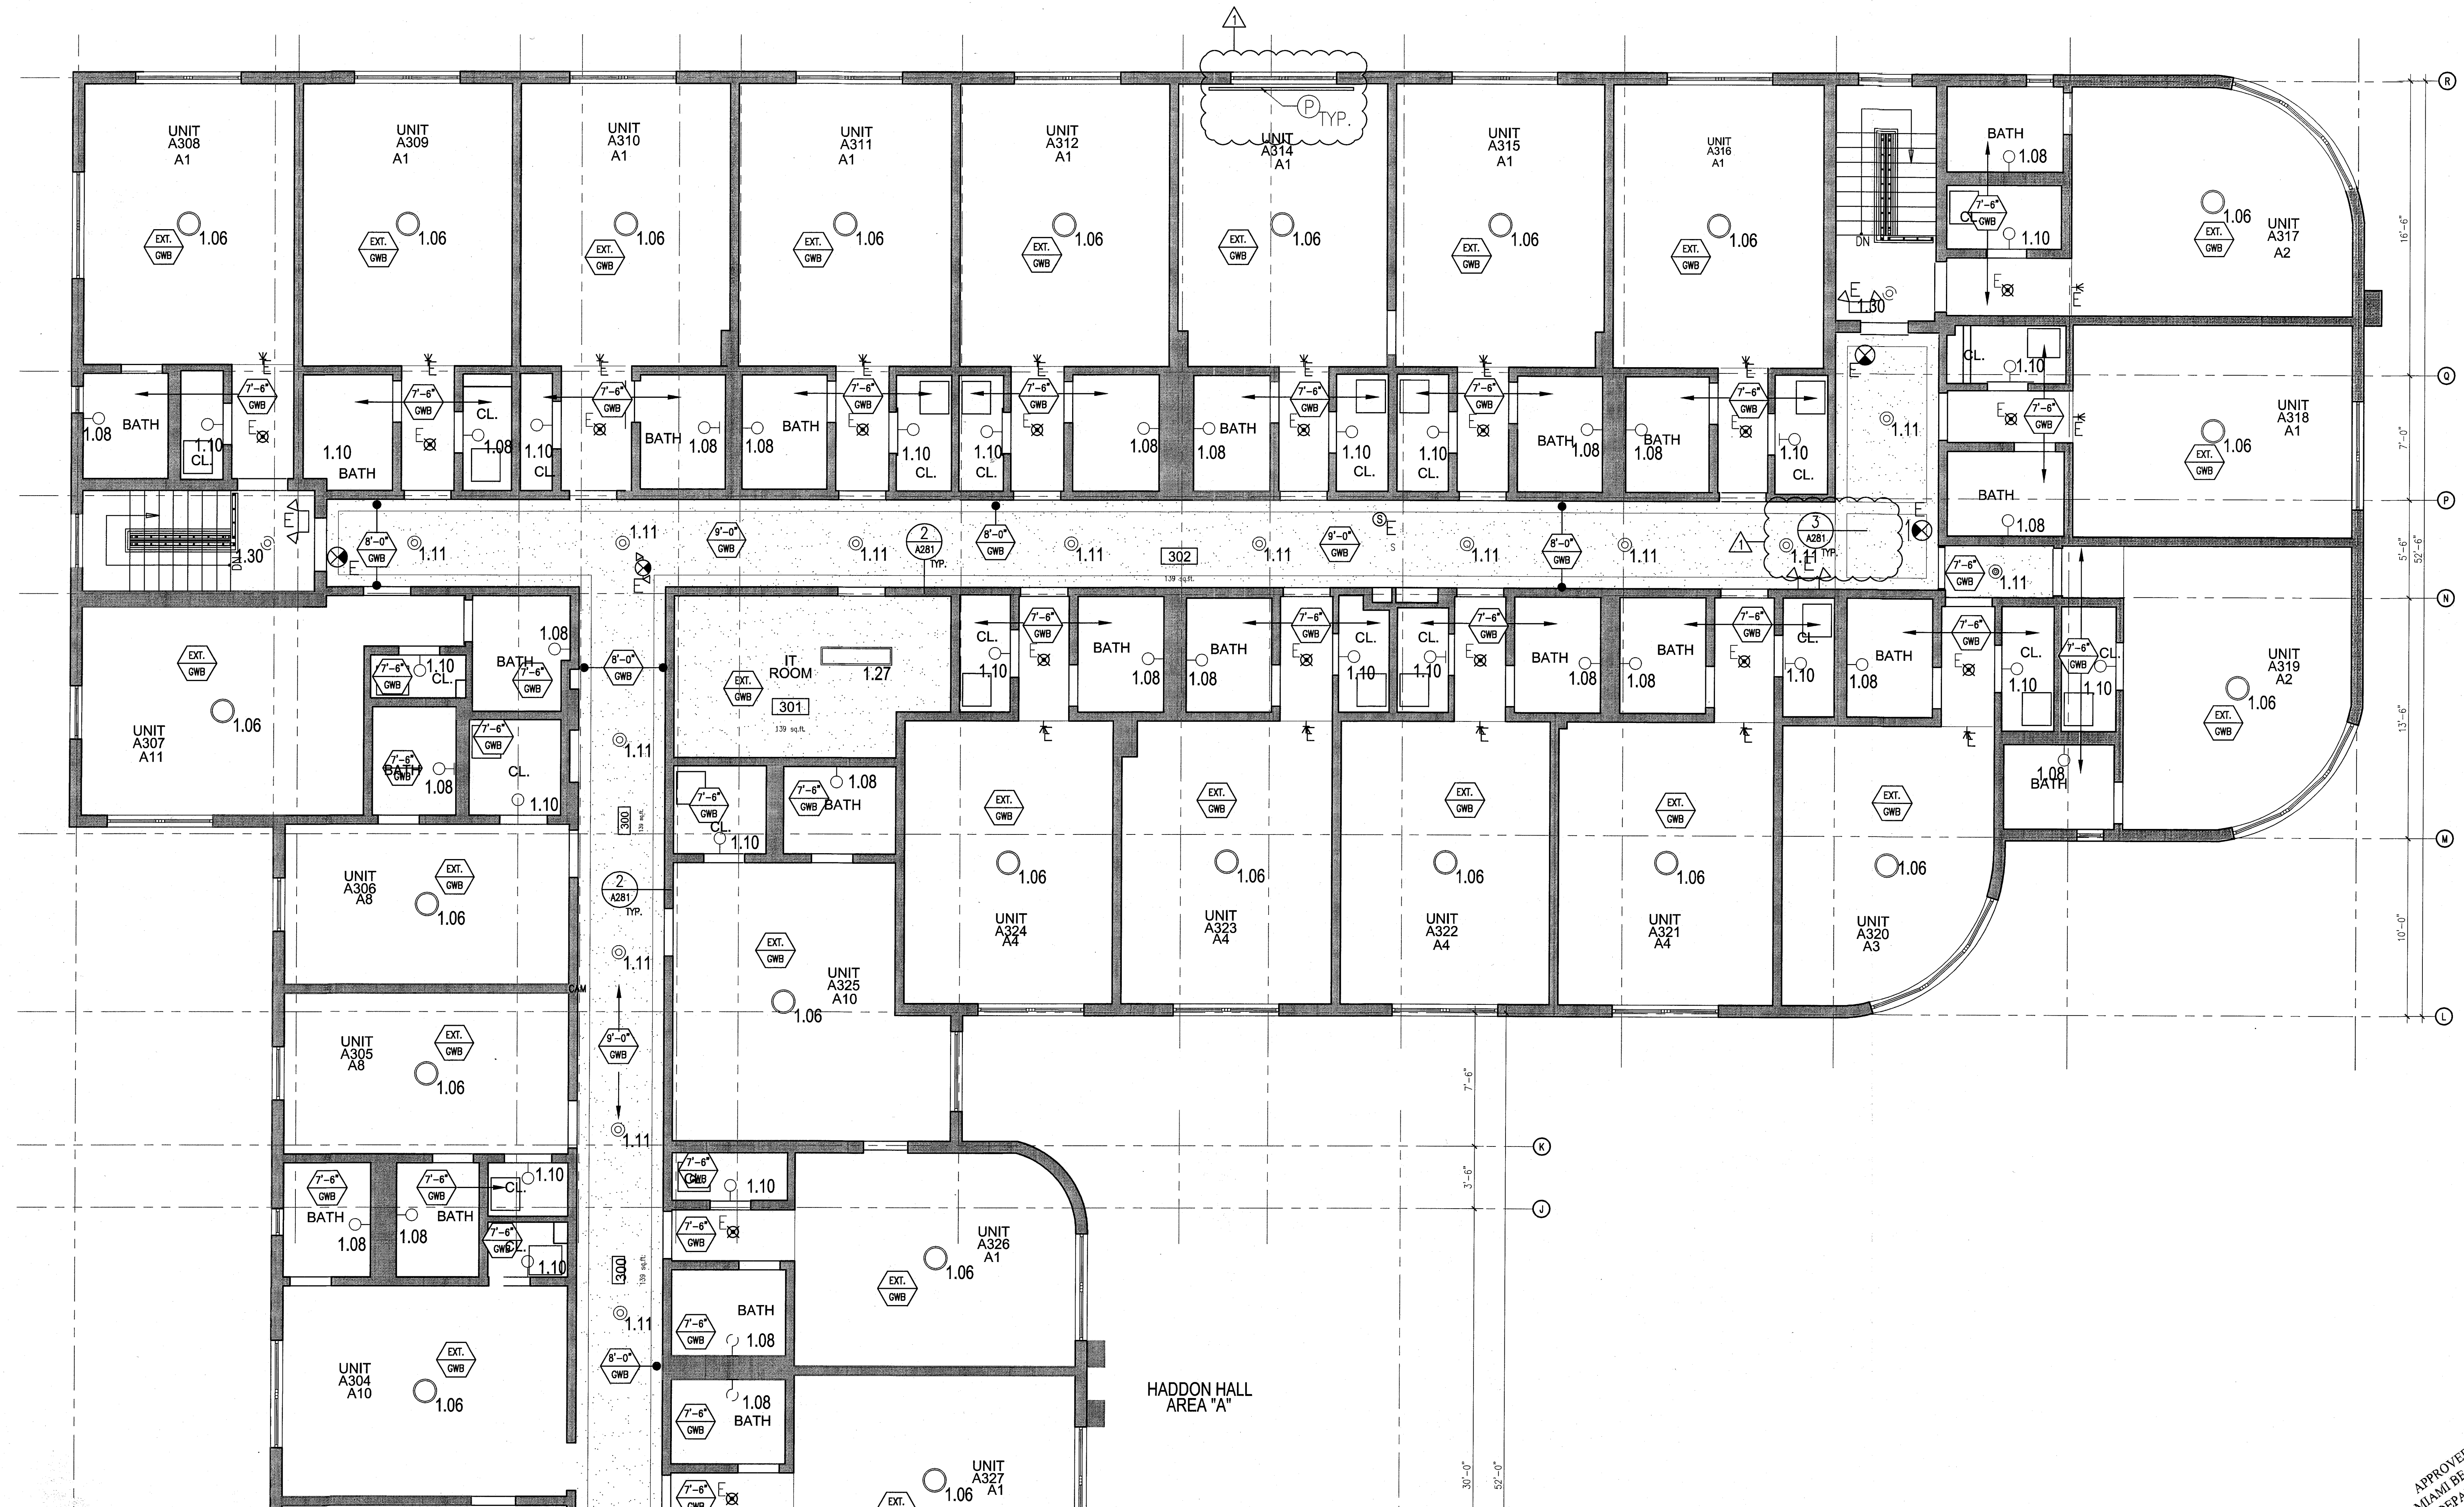

1 ENLARGED THIRD FLOOR REFLECTED CEILING PLAN/HADDON HALL NORTH
SCALE: 1/4" = 1'-0"

APPROVED
MIAMI BEACH
FIRE DEPARTMENT

GENERAL NOTES

1. NOTIFY THE ARCHITECT OF ANY UNEXPECTED FIELD CONDITION OR ANY DISCREPANCY BEFORE PROCEEDING. GENERAL CONTRACTOR IS TO COORDINATE THE COMPLETE SCOPE OF WORK WITH CONSTRUCTION DOCUMENTS.
2. NO MAINTENANCE OR STRUCTURAL WORKS ARE TO BE MOVED, ALTERED OR CUT WITH OUT THE APPROVAL OF THE ARCHITECT AND BUILDING MANAGEMENT.
3. REVIEW BUILDING STANDARD MANUAL PROVIDED BY THE BUILDING PROPERTY MANAGER BEFORE PROCEEDING WITH WORK.
4. PROVIDE TEMPORARY SECURE ACCESS TO SPACE THROUGH CONSTRUCTION AND TEMPORARY LIGHT & POWER.
5. PROVIDE STRICT CONTROL OF JOB CLEANING AND PREVENT SOOT AND DEBRIS FROM EXHAUSTING FROM CONSTRUCTION AREA.
6. DEBRIS REMOVAL MUST BE DONE USING THE FREIGHT ELEVATOR. CONTACT BUILDING MANAGEMENT OFFICE TO OBTAIN SCHEDULE FOR USE OF FREIGHT ELEVATORS PRIOR TO SUBMITTING BID. ALL DEBRIS REMOVAL MUST BE PERFORMED IN ACCORDANCE WITH BUILDING MANAGEMENT REQUIREMENTS AND PROCEDURES. CONTRACTOR TO COORDINATE WITH BUILDING MANAGEMENT TO OBTAIN MOST RECENT REQUIREMENTS FOR DEBRIS REMOVAL.
7. CAP AND SHUT OFF ALL UNUSED UTILITIES PER CITY AND STATE REQUIREMENTS, WHERE REQUIRED.
8. FIRE ALARM DEVICES (SMOKE DETECTORS, HORNS, STROBES AND EXT. SOUNDS) WITHIN DEMO SPACE SHALL REMAIN CONNECTED TO EXISTING SYSTEMS. SERVICE DEVICES AS NECESSARY TO KEEP FROM HANGING FREELY UPON REMOVAL OF WALLS/CEILINGS.
9. PROTECT ALL BASE BUILDING SERVICES, TYPICAL.
10. ALL REQUIREMENTS FOR FIRE RATINGS TO BE MAINTAINED DURING CONSTRUCTION.
11. THIS PROJECT INVOLVES CONSTRUCTION INSIDE AN EXISTING STRUCTURE. CONTRACTORS, BY SUBMITTING A BID, ARE DEEMED TO BE COMPLETELY FAMILIAR WITH THE EXISTING CONDITIONS OF THE BUILDING AS IT INFLUENCES THE WORK DESCRIBED. ABSOLUTELY NO CLAIMS FOR EXTRA COMPENSATION WILL BE CONSIDERED FOR EXISTING CONDITIONS VISIBLE OR REASONABLY INFERRABLE FROM A CAREFUL EXAMINATION OF THE EXISTING BLDG.
12. ELECTRICAL DEVICES SHALL BE TERMINATED IN A SAFE AND PROPER METHOD BY A LICENSED PROFESSIONAL.
13. ALL MEP-FP DEVICE LOCATIONS NOT SHOWN ON DRAWINGS OR IN CONFLICT WITH MEP-FP DRAWINGS, ARE TO BE COORDINATED WITH ARCHITECT PRIOR TO INSTALLATION.
14. SHUTDOWN OF EXISTING SYSTEMS FOR CONNECTION TO EXISTING SERVICES SHALL BE COORDINATED WITH THE CONSTRUCTION MANAGER AND BUILDING OWNER. THE CONTRACTOR SHALL SUBMIT REQUESTS, WHERE THEY AFFECT THE OPERATION OF THE BUILDING SYSTEMS, AT LEAST ONE WEEK IN ADVANCE OF ANY REQUIRED SHUTDOWN. THE ACTUAL SHUTDOWN PERIOD SHALL BE AS SHORT AS POSSIBLE AND AT A TIME MUTUALLY AGREEABLE TO THE BUILDING OWNER AND THE CONSTRUCTION MANAGER.
15. ALL WORK SHALL COMPLY WITH FEDERAL, STATE, AND LOCAL BUILDING CODES.
16. G.C. TO COORDINATE ALL AUDIO/VISUAL EQUIPMENT NEEDS WITH CLIENT.
17. BOTTOM OF ALL HANGING FIXTURES TO BE NO LOWER THAN 7'-0" AFF.
18. CONTRACTOR TO PROVIDE OVERLAY DRAWING OF ELECTRICAL, MECHANICAL, AND PLUMBING SYSTEMS AND COMPONENTS, LIFE SAFETY DEVICES, SMOKE DETECTORS, EMERGENCY LIGHTS AND ANY OTHER DEVICES IN CEILING TO ENSURE NO CONFLICTS.
19. SPRINKLER HEADS SHOWN FOR ARCHITECTURAL DESIGN INTENT ONLY. NOT FOR CODE DISTRIBUTION. SEE FIRE PROTECTION DRAWINGS FOR DISTRIBUTION AND CALCULATIONS.
20. CONTRACTOR WILL NOTIFY ARCHITECT IMMEDIATELY OF ANY CONFLICTS BETWEEN ARCHITECTURE AND ENGINEERING DRAWINGS.
21. THE CONTRACTOR SHALL INSPECT THE EXISTING FIELD CONDITIONS AT THE SITE PRIOR TO THE START OF ANY WORK TO DETERMINE WHAT EFFECT THE EXISTING CONDITIONS WILL HAVE ON THE WORK. POTENTIAL PROBLEM AREAS SHALL BE BROUGHT TO THE ATTN. OF THE ARCHITECT AND/OR ENGINEER IMMEDIATELY.
22. REFER TO SHEETS 100 FOR ELECTRICAL DRAWINGS AND 101 SERIES FOR FIRE SPRINKLER DRAWINGS.

SHEET NOTES

1. ALL EXISTING GYPSUM BOARD CEILINGS IN TO BE MAINTAINED AND RESTORED WHERE POSSIBLE. MINIMAL EXCAVATION FOR REMOVAL OF NEW HANG, COLLES AND SUFFIT AREAS.
2. ALL EXISTING LIGHT FIXTURES IN HADDON HALL TO BE REMOVED AND REPLACED IN SAME LOCATION UNLESS OTHERWISE NOTED.
3. FOR HOTEL ROOMS ROPS REFER TO SHEETS A301-018.
4. FOR OUTDOOR AREA LIGHTING REFER TO LANDSCAPE PLANS.
5. EXISTING HISTORIC SUFFIT AREAS IN HADDON HALL GROUND FLOOR COMMON AREA TO BE KEPT AND RESTORED.
6. EXISTING EXPOSED SPRINKLER PIPES IN HADDON HALL BUILDING TO BE COVERED WITH NEW PERIMETER SUFFIT AREA AT ALL CORRIDORS.
7. CENTER LIGHT FIXTURE IN SPACE U.O.N.
8. REFER TO A-281 FOR LIGHTING FIXTURE SCHEDULE.
9. J-BOX FOR FUTURE LED BLOWOUT FOR TUBE SCREEN.
10. COORDINATE LOCATION OF HANGING CHAIR WITH DESIGNER PRIOR TO INSTALLATION. ADDITIONAL BLUING MAY BE REQUIRED.
11. ALL GENERAL CEILING AND SUFFIT TO BE PAINTED PT-07 (FLAT FINISH) U.O.N. ALL CEILING AND PUBLIC RESTROOMS CEILING TO BE PAINTED PT-01 (EGGSHELL FINISH).
12. LED STRIP LIGHTING SHOWN ON PLAN WITH NOTE AS PLUG-IN RECEPTACLE AT ALL LOCATIONS.
13. ALL LIGHT FIXTURES IN COMMON AREAS AND POOL SUITES TO BE NEW AND COVERED IN SPACE U.O.N.
14. WALL SCAFFOLD SHOWN ON PLAN. ALL WALL CORNERS IN HADDON HALL GUESTROOMS WILL REPLACE EXISTING IN SAME LOCATION. ALL SCAFFOLD IN COMMON AND POOL SUITES WILL REPLACE EXISTING IN SAME LOCATION.
15. 17x4" MOUNTED TO CEILING IN FRONT OF WINDOWS TO ACT AS VALANCE TO CONCEAL OVERSET DOOR. 14x4" TO BE PAINTED PT-01. SIZES VARY, VERIFY IN FIELD.

LEGEND

- CEILING HEIGHT KEY
- CEILING TYPE
- CEILING HEIGHT - AFF
- 1" X 4" PENDANT
- DOWNLIGHT
- LED STRIP LIGHT
- EXTERIOR/DECORATIVE SCIENCE
- PENDANT FIXTURE
- SURFACE MOUNTED FIXTURE
- WALL SCAFFOLD
- EXISTING FIXTURE TO BE REPAIRED WITH NEW FIXTURE IN SAME LOCATION
- NEW LIGHT FIXTURE
- DEND LIGHT FIXTURE
- BATTERY POWERED WALL MOUNTED
- LINEAR DIFFUSER
- OCCUPANCY SENSOR
- EXT. SGN - WALL MOUNTED
- EXT. SGN - WALL MOUNTED
- SMOKE DETECTOR CEILING MOUNTED
- SMOKE DETECTOR WALL MOUNTED
- EXISTING CEILING MOUNTED SPRINKLER
- EXISTING WALL MOUNTED SPRINKLER
- SUPPLY DIFFUSER
- RETURN AIR GRILLE
- REPLACE EXISTING FIXTURE WITH NEW LIGHT FIXTURE
- JUNCTION BOX

NOTE: CEILINGS AT EXISTING HADDON HALL GUESTROOMS ARE EXISTING TO REMAIN AT 9'-0" A.F.F. UNLESS OTHERWISE NOTED



GENERAL NOTES

1. NOTIFY THE ARCHITECT OF ANY UNEXPECTED FIELD CONDITION OR ANY DISCREPANCY BEFORE PROCEEDING. GENERAL CONTRACTOR IS TO COORDINATE THE COMPLETE SCOPE OF WORK WITH CONSTRUCTION DOCUMENTS.
2. NO MAIN FRAMING OR STRUCTURAL MEMBERS ARE TO BE MODIFIED, ALTERED OR CUT WITH OUT THE APPROVAL OF THE ARCHITECT AND BUILDING MANAGEMENT.
3. REVIEW BUILDING STANDARD MANUAL PROVIDED BY THE BUILDING PROPERTY MANAGER BEFORE PROCEEDING WITH WORK.
4. PROVIDE TEMPORARY SECURE ACCESS TO SPACE THROUGH CONSTRUCTION AND TEMPORARY LIGHT & POWER.
5. PROVIDE STRICT CONTROL OF JOB CLEANING AND PREVENT DUST AND DEBRIS FROM DRAINING FROM CONSTRUCTION AREA.
6. DEBRIS REMOVAL MUST BE DONE USING THE FREIGHT ELEVATOR. CONTACT BUILDING MANAGEMENT OFFICE TO OBTAIN SCHEDULE FOR USE OF FREIGHT ELEVATORS PRIOR TO SHEDDING. ALL DEBRIS REMOVAL MUST BE PERFORMED IN ACCORDANCE WITH BUILDING MANAGEMENT REQUIREMENTS AND PROCEDURES. CONTRACTOR TO COORDINATE WITH BUILDING MANAGEMENT TO OBTAIN MOST RECENT REQUIREMENTS FOR DEBRIS REMOVAL.

7. CAP AND SHUT OFF ALL UNUSED UTILITIES PER CITY AND STATE REQUIREMENTS, WHERE REQUIRED.
8. FIRE ALARM DEVICES (SMOKE DETECTORS, HORNS, STROBES AND EXIT SIGNS) WITHIN DEMO SPACE SHALL REMAIN CONNECTED TO EXISTING SYSTEMS. SECURE DEVICES AS NECESSARY TO KEEP FROM HANGING FREELY UPON REMOVAL OF WALLS/CEILING.
9. PROTECT ALL BASE BUILDING SERVICES, TYPICAL.
10. ALL REQUIREMENTS FOR FIRE RATINGS TO BE MAINTAINED DURING CONSTRUCTION.
11. THIS PROJECT INVOLVES CONSTRUCTION INSIDE AN EXISTING STRUCTURE. CONTRACTORS, BY SUBMITTING A BID, ARE DEEMED TO BE COMPLETELY FAMILIAR WITH THE EXISTING CONDITION OF THE BUILDING AS IT INFLUENCES THE WORK DESCRIBED. ABSOLUTELY NO CLAIMS FOR EXTRA COMPENSATION WILL BE CONSIDERED FOR EXISTING CONDITIONS VISIBLE OR REASONABLY INFERRABLE FROM A CAREFUL EXAMINATION OF THE EXISTING BLDG.
12. ELECTRICAL DEVICES SHALL BE TERMINATED IN A SAFE AND PROPER METHOD BY A LICENSED PROFESSIONAL.

13. ALL MEP-FP DEVICE LOCATIONS NOT SHOWN ON DRAWINGS OR IN CONTACT WITH MEP-FP DRAWINGS, ARE TO BE COORDINATED WITH ARCHITECT PRIOR TO INSTALLATION.
14. SHUTDOWN OF EXISTING SYSTEMS FOR CONNECTION TO EXISTING SERVICES SHALL BE COORDINATED WITH THE CONSTRUCTION MANAGER AND BUILDING OWNER. THE CONTRACTOR SHALL SUBMIT REQUESTS, WHERE THEY AFFECT THE OPERATION OF THE BUILDING SYSTEMS, AT LEAST ONE WEEK IN ADVANCE OF ANY REQUIRED SHUTDOWN. THE ACTUAL SHUTDOWN PERIOD SHALL BE AS SHORT AS POSSIBLE AND AT A TIME MUTUALLY AGREEABLE TO THE BUILDING OWNER AND THE CONSTRUCTION MANAGER.
15. ALL WORK SHALL COMPLY WITH FEDERAL STATE, AND LOCAL BUILDING CODES.
16. C.C. TO COORDINATE ALL AUDIO/VISUAL EQUIPMENT NEEDS WITH CLIENT.
17. BOTTOM OF ALL HANGING FIXTURES TO BE NO LOWER THAN 7'-0" AFF.

18. CONTRACTOR TO PROVIDE OVERLAY DRAWING OF ELECTRICAL FIXTURES, MECH. SYSTEMS AND COMPONENTS, LIFE SAFETY DEVICES, SMOKE DETECTORS, EMERGENCY LIGHTS AND ANY OTHER DEVICES IN ORDER TO ENSURE NO CONFLICTS.
19. SPRINKLER HEADS SHOWN FOR ARCHITECTURAL DESIGN INTENT ONLY. NOT FOR CODE DISTRIBUTION. SEE FIRE PROTECTION DRAWINGS FOR DISTRIBUTION AND CALCULATIONS.
20. CONTRACTOR WILL NOTIFY ARCHITECT IMMEDIATELY OF ANY CONFLICTS BETWEEN ARCHITECTURE AND ENGINEERING DRAWINGS.
21. THE CONTRACTOR SHALL INSPECT THE EXISTING FIELD CONDITIONS AT THE SITE PRIOR TO THE START OF ANY WORK TO DETERMINE WHAT EFFECT THE EXISTING CONDITIONS WILL HAVE ON HIS WORK. POTENTIAL PROBLEM AREAS SHALL BE BROUGHT TO THE ATTN. OF THE ARCHITECT AND/OR ENGINEER IMMEDIATELY.
22. REFER TO SHEETS E1-00 FOR ELECTRICAL DRAWINGS AND F1-00 SERIES FOR FIRE SPRINKLER DRAWINGS.

23. ALL EXISTING CRYSTAL BOARD CEILING IN TO BE MAINTAINED AND RESTORED WHERE POSSIBLE. MINIMAL DEMOLITION FOR ADDITION OF NEW HVAC GRILLES AND SMOKE DETECTORS.
24. ALL EXISTING LIGHT FIXTURES IN HADDON HALL TO BE REMOVED AND REPLACED IN SAME LOCATION UNLESS OTHERWISE NOTED.
25. FOR HOTEL ROOMS ROPS REFER TO SHEETS A001-010.
26. FOR OUTDOOR AREA LIGHTING REFER TO LANDSCAPE PLANS.
27. EXISTING HISTORIC LIGHTING AREAS IN HADDON HALL GROUND FLOOR COMMON AREA TO BE KEPT AND RESTORED.
28. EXISTING EXPOSED SPRINKLER PIPES IN HADDON HALL BUILDING TO BE COVERED WITH NEW PERIMETER SOTTI AREA AT ALL CORRIDORS.
29. CENTER LIGHT FIXTURE IN SPACE U.O.N.
30. REFER TO A-201 FOR LIGHTING FIXTURE SCHEDULE.
31. 4-BOX FOR FUTURE LED BACKLIGHT FOR TUBE SCORE.

32. COORDINATE LOCATION OF HANGING CHAIR WITH DESIGNER PRIOR TO INSTALLATION. ADDITIONAL BLOCKING MAY BE REQUIRED.
33. ALL GENERAL CEILING AND SOTTI TO BE PAINTED PT-07 (FLAT FINISH), U.O.N. ALL GUESTROOM AND PUBLIC RESTROOMS CEILING TO BE PAINTED PT-01 (EGGSHELL FINISH).
34. LED STRIP LIGHTING SHOWN ON PLAN WITH NOTE AS PLUG-IN RECEPTACLE AT ALL.
35. ALL LIGHT FIXTURES IN CHAMPION APARTMENTS AND POOL SUITES TO BE NEW AND CENTERED IN SPACE U.O.N.
36. WALL SCONCES SHOWN ON PLAN. ALL WALL SCONES IN HADDON HALL GUESTROOMS WILL REPLACE EXISTING IN SAME LOCATION. ALL SCONES IN CHAMPION AND POOL SUITES NEW. REFER TO GUESTROOM ELEVATIONS FOR SCONES AREAS.
37. 1"X4" MOUNTED TO CEILING IN FRONT OF WINDOWS TO ACT AS VANTAGE TO CONSIDER DRAPEY BOLD. 1"X4 TO BE PAINTED PT-07. SIZES VARY, VARY IN FIELD.

38. 1"X4" MOUNTED TO CEILING IN FRONT OF WINDOWS TO ACT AS VANTAGE TO CONSIDER DRAPEY BOLD. 1"X4 TO BE PAINTED PT-07. SIZES VARY, VARY IN FIELD.
39. 1"X4" MOUNTED TO CEILING IN FRONT OF WINDOWS TO ACT AS VANTAGE TO CONSIDER DRAPEY BOLD. 1"X4 TO BE PAINTED PT-07. SIZES VARY, VARY IN FIELD.
40. 1"X4" MOUNTED TO CEILING IN FRONT OF WINDOWS TO ACT AS VANTAGE TO CONSIDER DRAPEY BOLD. 1"X4 TO BE PAINTED PT-07. SIZES VARY, VARY IN FIELD.
41. 1"X4" MOUNTED TO CEILING IN FRONT OF WINDOWS TO ACT AS VANTAGE TO CONSIDER DRAPEY BOLD. 1"X4 TO BE PAINTED PT-07. SIZES VARY, VARY IN FIELD.
42. 1"X4" MOUNTED TO CEILING IN FRONT OF WINDOWS TO ACT AS VANTAGE TO CONSIDER DRAPEY BOLD. 1"X4 TO BE PAINTED PT-07. SIZES VARY, VARY IN FIELD.

43. 1"X4" MOUNTED TO CEILING IN FRONT OF WINDOWS TO ACT AS VANTAGE TO CONSIDER DRAPEY BOLD. 1"X4 TO BE PAINTED PT-07. SIZES VARY, VARY IN FIELD.
44. 1"X4" MOUNTED TO CEILING IN FRONT OF WINDOWS TO ACT AS VANTAGE TO CONSIDER DRAPEY BOLD. 1"X4 TO BE PAINTED PT-07. SIZES VARY, VARY IN FIELD.
45. 1"X4" MOUNTED TO CEILING IN FRONT OF WINDOWS TO ACT AS VANTAGE TO CONSIDER DRAPEY BOLD. 1"X4 TO BE PAINTED PT-07. SIZES VARY, VARY IN FIELD.
46. 1"X4" MOUNTED TO CEILING IN FRONT OF WINDOWS TO ACT AS VANTAGE TO CONSIDER DRAPEY BOLD. 1"X4 TO BE PAINTED PT-07. SIZES VARY, VARY IN FIELD.
47. 1"X4" MOUNTED TO CEILING IN FRONT OF WINDOWS TO ACT AS VANTAGE TO CONSIDER DRAPEY BOLD. 1"X4 TO BE PAINTED PT-07. SIZES VARY, VARY IN FIELD.

48. 1"X4" MOUNTED TO CEILING IN FRONT OF WINDOWS TO ACT AS VANTAGE TO CONSIDER DRAPEY BOLD. 1"X4 TO BE PAINTED PT-07. SIZES VARY, VARY IN FIELD.
49. 1"X4" MOUNTED TO CEILING IN FRONT OF WINDOWS TO ACT AS VANTAGE TO CONSIDER DRAPEY BOLD. 1"X4 TO BE PAINTED PT-07. SIZES VARY, VARY IN FIELD.
50. 1"X4" MOUNTED TO CEILING IN FRONT OF WINDOWS TO ACT AS VANTAGE TO CONSIDER DRAPEY BOLD. 1"X4 TO BE PAINTED PT-07. SIZES VARY, VARY IN FIELD.
51. 1"X4" MOUNTED TO CEILING IN FRONT OF WINDOWS TO ACT AS VANTAGE TO CONSIDER DRAPEY BOLD. 1"X4 TO BE PAINTED PT-07. SIZES VARY, VARY IN FIELD.
52. 1"X4" MOUNTED TO CEILING IN FRONT OF WINDOWS TO ACT AS VANTAGE TO CONSIDER DRAPEY BOLD. 1"X4 TO BE PAINTED PT-07. SIZES VARY, VARY IN FIELD.

53. 1"X4" MOUNTED TO CEILING IN FRONT OF WINDOWS TO ACT AS VANTAGE TO CONSIDER DRAPEY BOLD. 1"X4 TO BE PAINTED PT-07. SIZES VARY, VARY IN FIELD.
54. 1"X4" MOUNTED TO CEILING IN FRONT OF WINDOWS TO ACT AS VANTAGE TO CONSIDER DRAPEY BOLD. 1"X4 TO BE PAINTED PT-07. SIZES VARY, VARY IN FIELD.
55. 1"X4" MOUNTED TO CEILING IN FRONT OF WINDOWS TO ACT AS VANTAGE TO CONSIDER DRAPEY BOLD. 1"X4 TO BE PAINTED PT-07. SIZES VARY, VARY IN FIELD.
56. 1"X4" MOUNTED TO CEILING IN FRONT OF WINDOWS TO ACT AS VANTAGE TO CONSIDER DRAPEY BOLD. 1"X4 TO BE PAINTED PT-07. SIZES VARY, VARY IN FIELD.
57. 1"X4" MOUNTED TO CEILING IN FRONT OF WINDOWS TO ACT AS VANTAGE TO CONSIDER DRAPEY BOLD. 1"X4 TO BE PAINTED PT-07. SIZES VARY, VARY IN FIELD.

58. 1"X4" MOUNTED TO CEILING IN FRONT OF WINDOWS TO ACT AS VANTAGE TO CONSIDER DRAPEY BOLD. 1"X4 TO BE PAINTED PT-07. SIZES VARY, VARY IN FIELD.
59. 1"X4" MOUNTED TO CEILING IN FRONT OF WINDOWS TO ACT AS VANTAGE TO CONSIDER DRAPEY BOLD. 1"X4 TO BE PAINTED PT-07. SIZES VARY, VARY IN FIELD.
60. 1"X4" MOUNTED TO CEILING IN FRONT OF WINDOWS TO ACT AS VANTAGE TO CONSIDER DRAPEY BOLD. 1"X4 TO BE PAINTED PT-07. SIZES VARY, VARY IN FIELD.
61. 1"X4" MOUNTED TO CEILING IN FRONT OF WINDOWS TO ACT AS VANTAGE TO CONSIDER DRAPEY BOLD. 1"X4 TO BE PAINTED PT-07. SIZES VARY, VARY IN FIELD.
62. 1"X4" MOUNTED TO CEILING IN FRONT OF WINDOWS TO ACT AS VANTAGE TO CONSIDER DRAPEY BOLD. 1"X4 TO BE PAINTED PT-07. SIZES VARY, VARY IN FIELD.

63. 1"X4" MOUNTED TO CEILING IN FRONT OF WINDOWS TO ACT AS VANTAGE TO CONSIDER DRAPEY BOLD. 1"X4 TO BE PAINTED PT-07. SIZES VARY, VARY IN FIELD.
64. 1"X4" MOUNTED TO CEILING IN FRONT OF WINDOWS TO ACT AS VANTAGE TO CONSIDER DRAPEY BOLD. 1"X4 TO BE PAINTED PT-07. SIZES VARY, VARY IN FIELD.
65. 1"X4" MOUNTED TO CEILING IN FRONT OF WINDOWS TO ACT AS VANTAGE TO CONSIDER DRAPEY BOLD. 1"X4 TO BE PAINTED PT-07. SIZES VARY, VARY IN FIELD.
66. 1"X4" MOUNTED TO CEILING IN FRONT OF WINDOWS TO ACT AS VANTAGE TO CONSIDER DRAPEY BOLD. 1"X4 TO BE PAINTED PT-07. SIZES VARY, VARY IN FIELD.
67. 1"X4" MOUNTED TO CEILING IN FRONT OF WINDOWS TO ACT AS VANTAGE TO CONSIDER DRAPEY BOLD. 1"X4 TO BE PAINTED PT-07. SIZES VARY, VARY IN FIELD.

68. 1"X4" MOUNTED TO CEILING IN FRONT OF WINDOWS TO ACT AS VANTAGE TO CONSIDER DRAPEY BOLD. 1"X4 TO BE PAINTED PT-07. SIZES VARY, VARY IN FIELD.
69. 1"X4" MOUNTED TO CEILING IN FRONT OF WINDOWS TO ACT AS VANTAGE TO CONSIDER DRAPEY BOLD. 1"X4 TO BE PAINTED PT-07. SIZES VARY, VARY IN FIELD.
70. 1"X4" MOUNTED TO CEILING IN FRONT OF WINDOWS TO ACT AS VANTAGE TO CONSIDER DRAPEY BOLD. 1"X4 TO BE PAINTED PT-07. SIZES VARY, VARY IN FIELD.
71. 1"X4" MOUNTED TO CEILING IN FRONT OF WINDOWS TO ACT AS VANTAGE TO CONSIDER DRAPEY BOLD. 1"X4 TO BE PAINTED PT-07. SIZES VARY, VARY IN FIELD.
72. 1"X4" MOUNTED TO CEILING IN FRONT OF WINDOWS TO ACT AS VANTAGE TO CONSIDER DRAPEY BOLD. 1"X4 TO BE PAINTED PT-07. SIZES VARY, VARY IN FIELD.

73. 1"X4" MOUNTED TO CEILING IN FRONT OF WINDOWS TO ACT AS VANTAGE TO CONSIDER DRAPEY BOLD. 1"X4 TO BE PAINTED PT-07. SIZES VARY, VARY IN FIELD.
74. 1"X4" MOUNTED TO CEILING IN FRONT OF WINDOWS TO ACT AS VANTAGE TO CONSIDER DRAPEY BOLD. 1"X4 TO BE PAINTED PT-07. SIZES VARY, VARY IN FIELD.
75. 1"X4" MOUNTED TO CEILING IN FRONT OF WINDOWS TO ACT AS VANTAGE TO CONSIDER DRAPEY BOLD. 1"X4 TO BE PAINTED PT-07. SIZES VARY, VARY IN FIELD.
76. 1"X4" MOUNTED TO CEILING IN FRONT OF WINDOWS TO ACT AS VANTAGE TO CONSIDER DRAPEY BOLD. 1"X4 TO BE PAINTED PT-07. SIZES VARY, VARY IN FIELD.
77. 1"X4" MOUNTED TO CEILING IN FRONT OF WINDOWS TO ACT AS VANTAGE TO CONSIDER DRAPEY BOLD. 1"X4 TO BE PAINTED PT-07. SIZES VARY, VARY IN FIELD.

78. 1"X4" MOUNTED TO CEILING IN FRONT OF WINDOWS TO ACT AS VANTAGE TO CONSIDER DRAPEY BOLD. 1"X4 TO BE PAINTED PT-07. SIZES VARY, VARY IN FIELD.
79. 1"X4" MOUNTED TO CEILING IN FRONT OF WINDOWS TO ACT AS VANTAGE TO CONSIDER DRAPEY BOLD. 1"X4 TO BE PAINTED PT-07. SIZES VARY, VARY IN FIELD.
80. 1"X4" MOUNTED TO CEILING IN FRONT OF WINDOWS TO ACT AS VANTAGE TO CONSIDER DRAPEY BOLD. 1"X4 TO BE PAINTED PT-07. SIZES VARY, VARY IN FIELD.
81. 1"X4" MOUNTED TO CEILING IN FRONT OF WINDOWS TO ACT AS VANTAGE TO CONSIDER DRAPEY BOLD. 1"X4 TO BE PAINTED PT-07. SIZES VARY, VARY IN FIELD.
82. 1"X4" MOUNTED TO CEILING IN FRONT OF WINDOWS TO ACT AS VANTAGE TO CONSIDER DRAPEY BOLD. 1"X4 TO BE PAINTED PT-07. SIZES VARY, VARY IN FIELD.

SHEET NOTES

1. ALL EXISTING CRYSTAL BOARD CEILING IN TO BE MAINTAINED AND RESTORED WHERE POSSIBLE. MINIMAL DEMOLITION FOR ADDITION OF NEW HVAC GRILLES AND SMOKE DETECTORS.
2. ALL EXISTING LIGHT FIXTURES IN HADDON HALL TO BE REMOVED AND REPLACED IN SAME LOCATION UNLESS OTHERWISE NOTED.
3. FOR HOTEL ROOMS ROPS REFER TO SHEETS A001-010.
4. FOR OUTDOOR AREA LIGHTING REFER TO LANDSCAPE PLANS.
5. EXISTING HISTORIC LIGHTING AREAS IN HADDON HALL GROUND FLOOR COMMON AREA TO BE KEPT AND RESTORED.
6. EXISTING EXPOSED SPRINKLER PIPES IN HADDON HALL BUILDING TO BE COVERED WITH NEW PERIMETER SOTTI AREA AT ALL CORRIDORS.
7. CENTER LIGHT FIXTURE IN SPACE U.O.N.
8. REFER TO A-201 FOR LIGHTING FIXTURE SCHEDULE.
9. 4-BOX FOR FUTURE LED BACKLIGHT FOR TUBE SCORE.

10. COORDINATE LOCATION OF HANGING CHAIR WITH DESIGNER PRIOR TO INSTALLATION. ADDITIONAL BLOCKING MAY BE REQUIRED.
11. ALL GENERAL CEILING AND SOTTI TO BE PAINTED PT-07 (FLAT FINISH), U.O.N. ALL GUESTROOM AND PUBLIC RESTROOMS CEILING TO BE PAINTED PT-01 (EGGSHELL FINISH).
12. LED STRIP LIGHTING SHOWN ON PLAN WITH NOTE AS PLUG-IN RECEPTACLE AT ALL.
13. ALL LIGHT FIXTURES IN CHAMPION APARTMENTS AND POOL SUITES TO BE NEW AND CENTERED IN SPACE U.O.N.
14. WALL SCONCES SHOWN ON PLAN. ALL WALL SCONES IN HADDON HALL GUESTROOMS WILL REPLACE EXISTING IN SAME LOCATION. ALL SCONES IN CHAMPION AND POOL SUITES NEW. REFER TO GUESTROOM ELEVATIONS FOR SCONES AREAS.
15. 1"X4" MOUNTED TO CEILING IN FRONT OF WINDOWS TO ACT AS VANTAGE TO CONSIDER DRAPEY BOLD. 1"X4 TO BE PAINTED PT-07. SIZES VARY, VARY IN FIELD.

16. 1"X4" MOUNTED TO CEILING IN FRONT OF WINDOWS TO ACT AS VANTAGE TO CONSIDER DRAPEY BOLD. 1"X4 TO BE PAINTED PT-07. SIZES VARY, VARY IN FIELD.
17. 1"X4" MOUNTED TO CEILING IN FRONT OF WINDOWS TO ACT AS VANTAGE TO CONSIDER DRAPEY BOLD. 1"X4 TO BE PAINTED PT-07. SIZES VARY, VARY IN FIELD.
18. 1"X4" MOUNTED TO CEILING IN FRONT OF WINDOWS TO ACT AS VANTAGE TO CONSIDER DRAPEY BOLD. 1"X4 TO BE PAINTED PT-07. SIZES VARY, VARY IN FIELD.
19. 1"X4" MOUNTED TO CEILING IN FRONT OF WINDOWS TO ACT AS VANTAGE TO CONSIDER DRAPEY BOLD. 1"X4 TO BE PAINTED PT-07. SIZES VARY, VARY IN FIELD.
20. 1"X4" MOUNTED TO CEILING IN FRONT OF WINDOWS TO ACT AS VANTAGE TO CONSIDER DRAPEY BOLD. 1"X4 TO BE PAINTED PT-07. SIZES VARY, VARY IN FIELD.

21. 1"X4" MOUNTED TO CEILING IN FRONT OF WINDOWS TO ACT AS VANTAGE TO CONSIDER DRAPEY BOLD. 1"X4 TO BE PAINTED PT-07. SIZES VARY, VARY IN FIELD.
22. 1"X4" MOUNTED TO CEILING IN FRONT OF WINDOWS TO ACT AS VANTAGE TO CONSIDER DRAPEY BOLD. 1"X4 TO BE PAINTED PT-07. SIZES VARY, VARY IN FIELD.
23. 1"X4" MOUNTED TO CEILING IN FRONT OF WINDOWS TO ACT AS VANTAGE TO CONSIDER DRAPEY BOLD. 1"X4 TO BE PAINTED PT-07. SIZES VARY, VARY IN FIELD.
24. 1"X4" MOUNTED TO CEILING IN FRONT OF WINDOWS TO ACT AS VANTAGE TO CONSIDER DRAPEY BOLD. 1"X4 TO BE PAINTED PT-07. SIZES VARY, VARY IN FIELD.
25. 1"X4" MOUNTED TO CEILING IN FRONT OF WINDOWS TO ACT AS VANTAGE TO CONSIDER DRAPEY BOLD. 1"X4 TO BE PAINTED PT-07. SIZES VARY, VARY IN FIELD.

26. 1"X4" MOUNTED TO CEILING IN FRONT OF WINDOWS TO ACT AS VANTAGE TO CONSIDER DRAPEY BOLD. 1"X4 TO BE PAINTED PT-07. SIZES VARY, VARY IN FIELD.
27. 1"X4" MOUNTED TO CEILING IN FRONT OF WINDOWS TO ACT AS VANTAGE TO CONSIDER DRAPEY BOLD. 1"X4 TO BE PAINTED PT-07. SIZES VARY, VARY IN FIELD.
28. 1"X4" MOUNTED TO CEILING IN FRONT OF WINDOWS TO ACT AS VANTAGE TO CONSIDER DRAPEY BOLD. 1"X4 TO BE PAINTED PT-07. SIZES VARY, VARY IN FIELD.
29. 1"X4" MOUNTED TO CEILING IN FRONT OF WINDOWS TO ACT AS VANTAGE TO CONSIDER DRAPEY BOLD. 1"X4 TO BE PAINTED PT-07. SIZES VARY, VARY IN FIELD.
30. 1"X4" MOUNTED TO CEILING IN FRONT OF WINDOWS TO ACT AS VANTAGE TO CONSIDER DRAPEY BOLD. 1"X4 TO BE PAINTED PT-07. SIZES VARY, VARY IN FIELD.

31. 1"X4" MOUNTED TO CEILING IN FRONT OF WINDOWS TO ACT AS VANTAGE TO CONSIDER DRAPEY BOLD. 1"X4 TO BE PAINTED PT-07. SIZES VARY, VARY IN FIELD.
32. 1"X4" MOUNTED TO CEILING IN FRONT OF WINDOWS TO ACT AS VANTAGE TO CONSIDER DRAPEY BOLD. 1"X4 TO BE PAINTED PT-07. SIZES VARY, VARY IN FIELD.
33. 1"X4" MOUNTED TO CEILING IN FRONT OF WINDOWS TO ACT AS VANTAGE TO CONSIDER DRAPEY BOLD. 1"X4 TO BE PAINTED PT-07. SIZES VARY, VARY IN FIELD.
34. 1"X4" MOUNTED TO CEILING IN FRONT OF WINDOWS TO ACT AS VANTAGE TO CONSIDER DRAPEY BOLD. 1"X4 TO BE PAINTED PT-07. SIZES VARY, VARY IN FIELD.
35. 1"X4" MOUNTED TO CEILING IN FRONT OF WINDOWS TO ACT AS VANTAGE TO CONSIDER DRAPEY BOLD. 1"X4 TO BE PAINTED PT-07. SIZES VARY, VARY IN FIELD.

36. 1"X4" MOUNTED TO CEILING IN FRONT OF WINDOWS TO ACT AS VANTAGE TO CONSIDER DRAPEY BOLD. 1"X4 TO BE PAINTED PT-07. SIZES VARY, VARY IN FIELD.
37. 1"X4" MOUNTED TO CEILING IN FRONT OF WINDOWS TO ACT AS VANTAGE TO CONSIDER DRAPEY BOLD. 1"X4 TO BE PAINTED PT-07. SIZES VARY, VARY IN FIELD.
38. 1"X4" MOUNTED TO CEILING IN FRONT OF WINDOWS TO ACT AS VANTAGE TO CONSIDER DRAPEY BOLD. 1"X4 TO BE PAINTED PT-07. SIZES VARY, VARY IN FIELD.
39. 1"X4" MOUNTED TO CEILING IN FRONT OF WINDOWS TO ACT AS VANTAGE TO CONSIDER DRAPEY BOLD. 1"X4 TO BE PAINTED PT-07. SIZES VARY, VARY IN FIELD.
40. 1"X4" MOUNTED TO CEILING IN FRONT OF WINDOWS TO ACT AS VANTAGE TO CONSIDER DRAPEY BOLD. 1"X4 TO BE PAINTED PT-07. SIZES VARY, VARY IN FIELD.


41. 1"X4" MOUNTED TO CEILING IN FRONT OF WINDOWS TO ACT AS VANTAGE TO CONSIDER DRAPEY BOLD. 1"X4 TO BE PAINTED PT-07. SIZES VARY, VARY IN FIELD.
42. 1"X4" MOUNTED TO CEILING IN FRONT OF WINDOWS TO ACT AS VANTAGE TO CONSIDER DRAPEY BOLD. 1"X4 TO BE PAINTED PT-07. SIZES VARY, VARY IN FIELD.
43. 1"X4" MOUNTED TO CEILING IN FRONT OF WINDOWS TO ACT AS VANTAGE TO CONSIDER DRAPEY BOLD. 1"X4 TO BE PAINTED PT-07. SIZES VARY, VARY IN FIELD.
44. 1"X4" MOUNTED TO CEILING IN FRONT OF WINDOWS TO ACT AS VANTAGE TO CONSIDER DRAPEY BOLD. 1"X4 TO BE PAINTED PT-07. SIZES VARY, VARY IN FIELD.
45. 1"X4" MOUNTED TO CEILING IN FRONT OF WINDOWS TO ACT AS VANTAGE TO CONSIDER DRAPEY BOLD. 1"X4 TO BE PAINTED PT-07. SIZES VARY, VARY IN FIELD.

46. 1"X4" MOUNTED TO CEILING IN FRONT OF WINDOWS TO ACT AS VANTAGE TO CONSIDER DRAPEY BOLD. 1"X4 TO BE PAINTED PT-07. SIZES VARY, VARY IN FIELD.
47. 1"X4" MOUNTED TO CEILING IN FRONT OF WINDOWS TO ACT AS VANTAGE TO CONSIDER DRAPEY BOLD. 1"X4 TO BE PAINTED PT-07. SIZES VARY, VARY IN FIELD.
48. 1"X4" MOUNTED TO CEILING IN FRONT OF WINDOWS TO ACT AS VANTAGE TO CONSIDER DRAPEY BOLD. 1"X4 TO BE PAINTED PT-07. SIZES VARY, VARY IN FIELD.
49. 1"X4" MOUNTED TO CEILING IN FRONT OF WINDOWS TO ACT AS VANTAGE TO CONSIDER DRAPEY BOLD. 1"X4 TO BE PAINTED PT-07. SIZES VARY, VARY IN FIELD.
50. 1"X4" MOUNTED TO CEILING IN FRONT OF WINDOWS TO ACT AS VANTAGE TO CONSIDER DRAPEY BOLD. 1"X4 TO BE PAINTED PT-07. SIZES VARY, VARY IN FIELD.

LEGEND

1. CMB CEILING/SOTTI
2. CEILING HEIGHT KEY
3. CEILING TYPE
4. CEILING HEIGHT - AFF
5. DOWNLIGHT
6. LED STRIP LIGHT
7. EXTERIOR/DECORATIVE SCONCE
8. PENDANT FIXTURE
9. SURFACE MOUNTED FIXTURE
10. WALL SCONCE
11. EXISTING FIXTURE TO BE REPLACED WITH NEW FIXTURE IN SAME LOCATION
12. DEMO FIXTURE - PATCH AND REPAIR CEILING
13. NEW LIGHT FIXTURE
14. DEMO LIGHT FIXTURE

15. BATTERY POWERED WALL MOUNTED ULTRASONIC DETECTOR
16. LIBRARY DEFUSER
17. EXIT SIGN - WALL MOUNTED ARROWS INDICATE DIRECTION
18. EXIT SIGN - WALL MOUNTED ARROWS INDICATE DIRECTION
19. SMOKE DETECTOR CEILING MOUNTED
20. SMOKE DETECTOR WALL MOUNTED
21. EXISTING CEILING MOUNTED SPRINKLER
22. SPRINKLER
23. EXISTING WALL MOUNTED SPRINKLER
24. RETURN AIR GRILLE
25. REPLACE EXISTING FIXTURE WITH NEW LIGHT FIXTURE, JUNCTION BOX

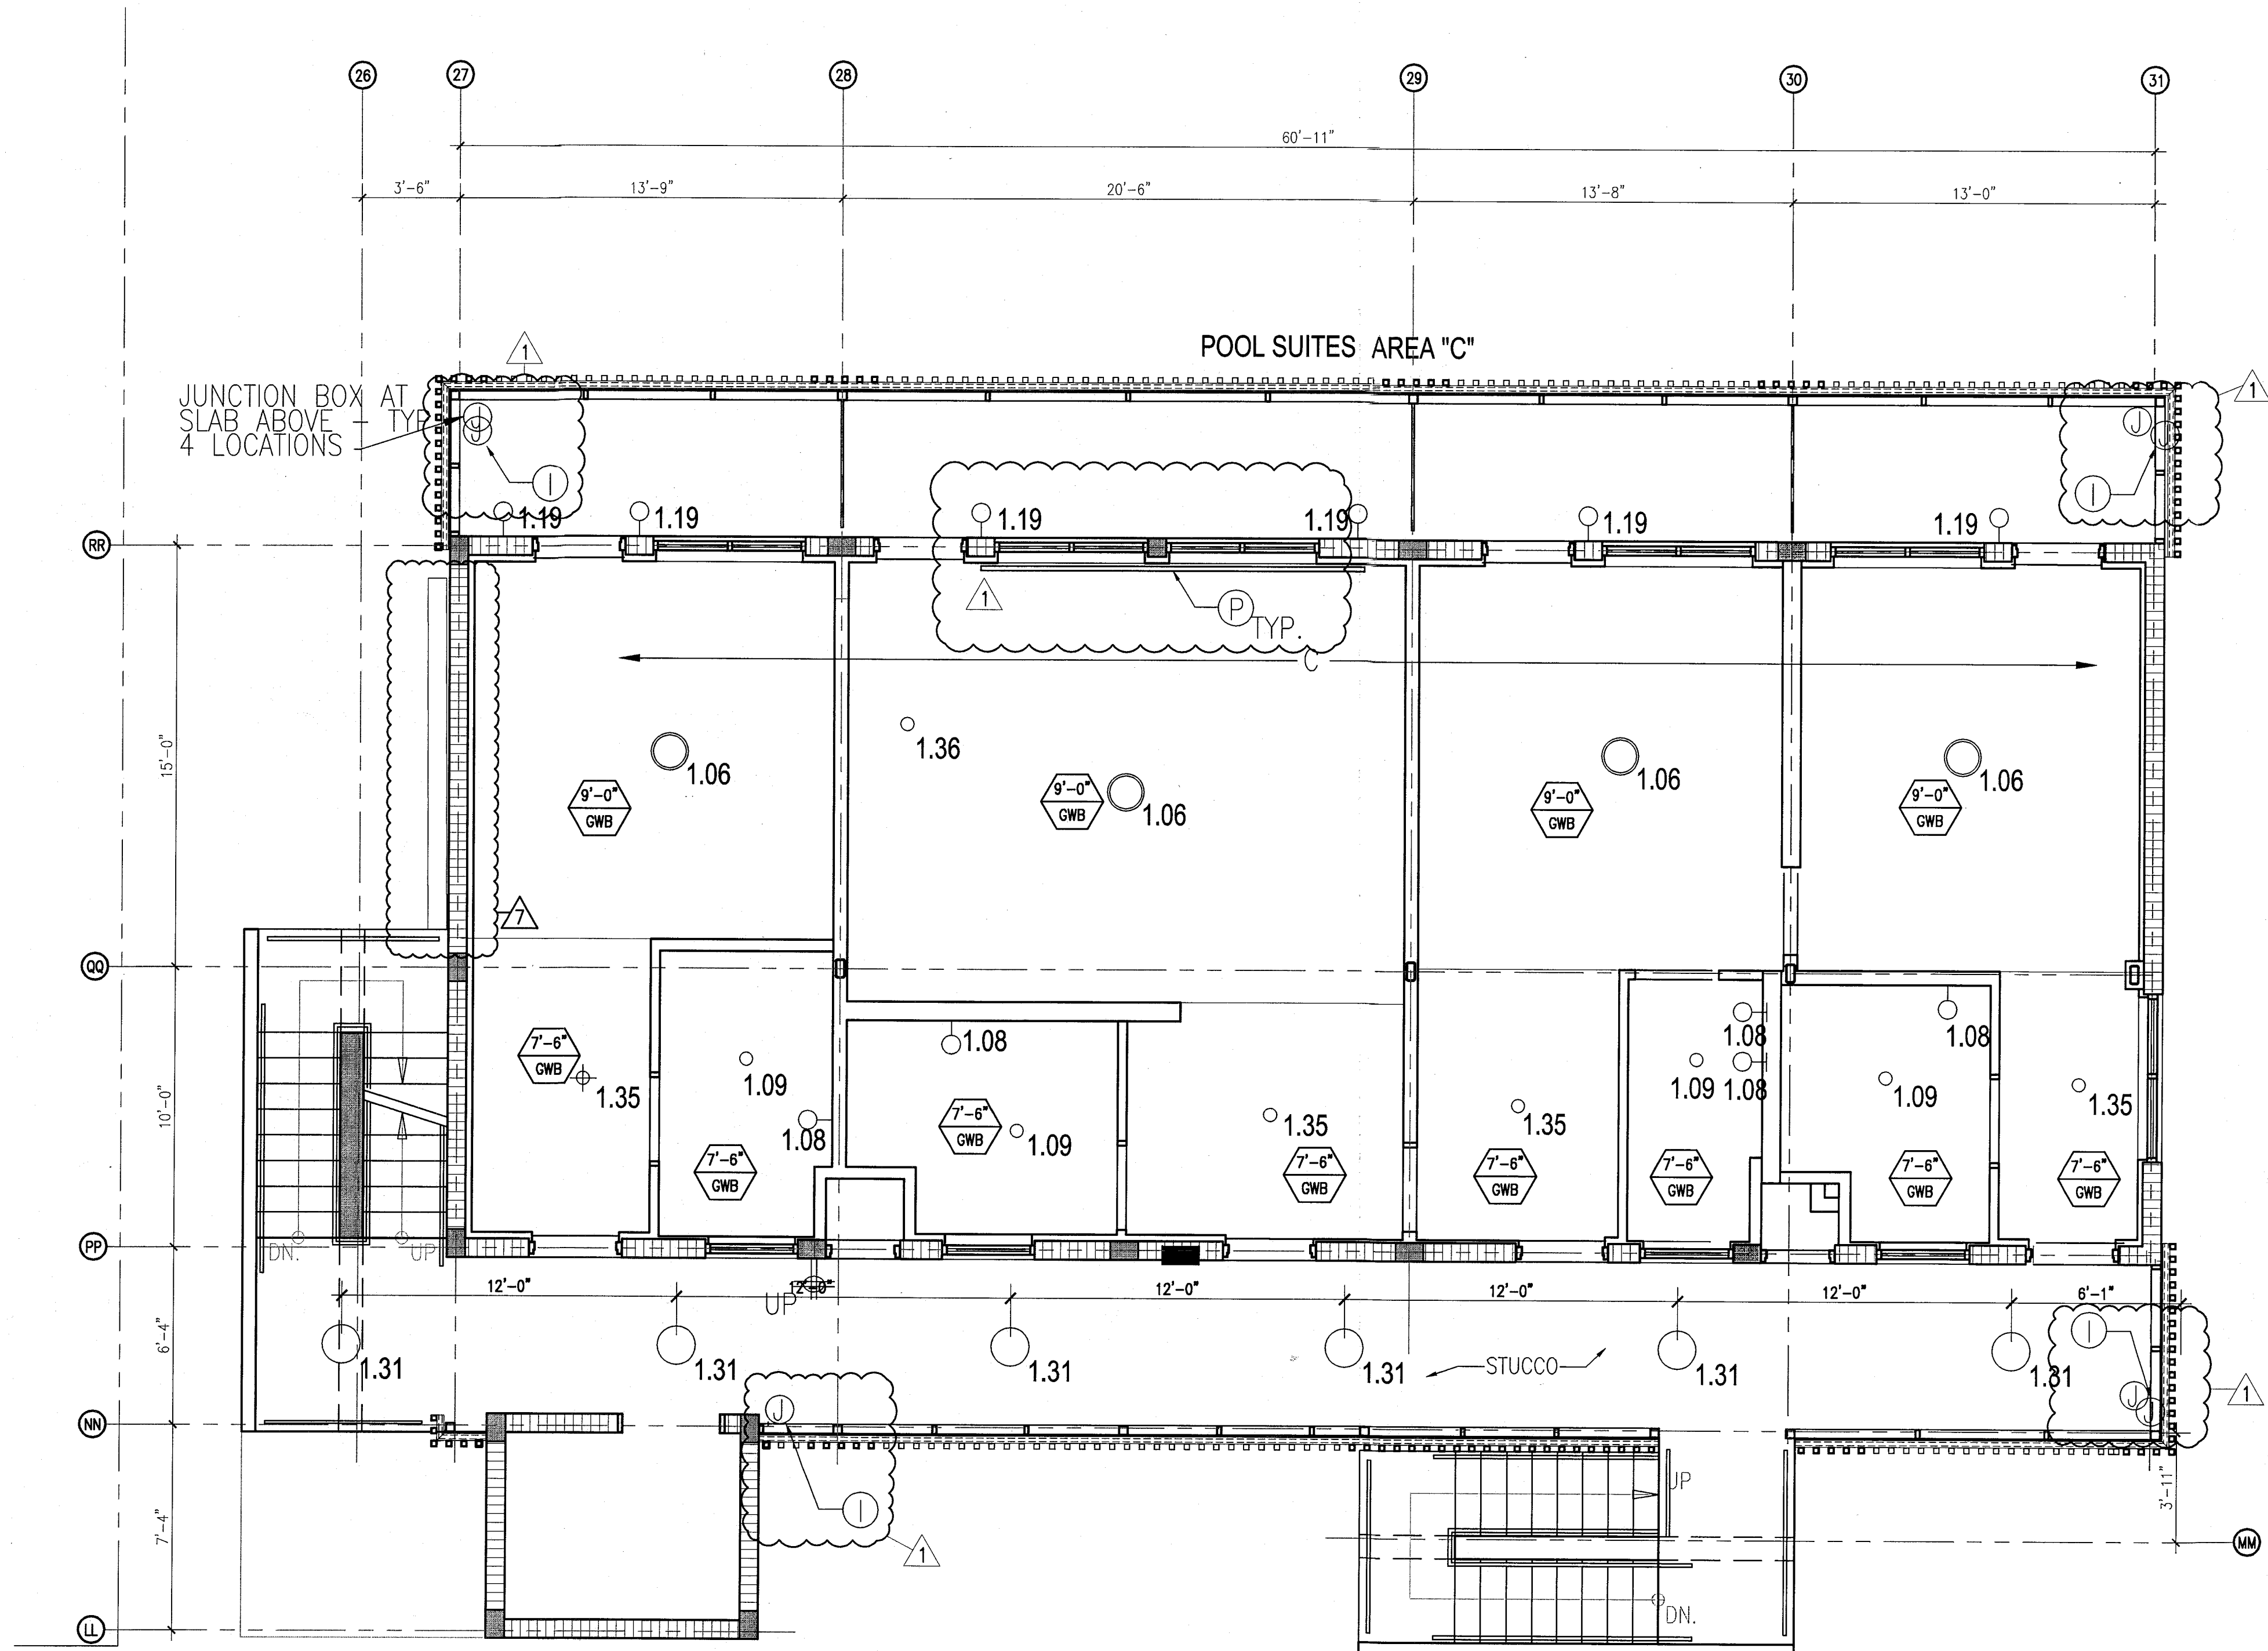

1. NOTIFY THE ARCHITECT OF ANY UNEXPECTED FIELD CONDITION OR ANY DISCREPANCY BEFORE PROCEEDING. GENERAL CONTRACTOR TO COORDINATE WITH ARCHITECT TO COMPLETE SCOPE OF WORK WITH CONSTRUCTION DOCUMENTS.
2. NO MAIN FRAMING OR STRUCTURAL MEMBERS ARE TO BE REMOVED, ALTERED OR CUT OUT WITH OUT THE APPROVAL OF THE SOCIETY OF BUILDING OFFICIALS.
3. REWORK BUILDING STANDARD MANUAL PROVIDED BY THE BUILDING PROPERTY MANAGER BEFORE PROCEEDING WITH WORK.
4. PROVIDE TEMPORARY SECURE ACCESS TO SPACE THROUGH CONSTRUCTION AND TEMPORARY LIGHT & POWER.
5. PROVIDE STRICT CONTROL OF JOG CLEANING AND PREVENT DUST AND DEBRIS FROM EMANATING FROM CONSTRUCTION AREA.
6. DEBRIS REMOVAL MUST BE DONE USING THE FREIGHT ELEVATOR. CONTACT BUILDING MANAGEMENT OFFICE TO OBTAIN PERMIT TO USE OF FREIGHT ELEVATOR FOR DEBRIS REMOVAL. SUBMITTING BID, ALL DEBRIS REMOVAL MUST BE PERFORMED IN ACCORDANCE WITH BUILDING MANAGEMENT OFFICE POLICIES AND PROCEDURES. CONTRACTOR TO COORDINATE WITH BUILDING MANAGEMENT TO OBTAIN MOST RECENT REQUIREMENTS FOR DEBRIS REMOVAL.

- | | |
|----|--|
| 7 | CAP AND SHUT OFF ALL UNUSED UTILITY PER CITY AND STATE REQUIREMENTS, WHERE REQUIRED. |
| 8 | FIRE ALARM ALARMS (SMOKE DETECTORS, HEAVY, SMOKE DETECTORS) WITH DEMO SPACE SHALL REMAIN CONNECTED TO EXISTING SYSTEMS. SECURE DEVICES AS NECESSARY TO KEEP FROM HANDING FREELY USED SOURCE OF MISCELLANEOUS INFORMATION. |
| 9 | PROTECT ALL BASE BUILDING SYSTEMS, TYPICAL. |
| 10 | ALL REQUIREMENTS FOR FIRE RATINGS TO BE MAINTAINED TO BE COMPLETELY FULFILLED. |
| 11 | THIS PROJECT INVOLVES CONSTRUCTION INSIDE AN EXISTING STRUCTURE. CONTRACTORS, BY SUBMITTING A BID, ARE DEEMED TO BE COMPLETELY FAMILIAR WITH THE EXISTING CONDITION OF THE BUILDING AS IT INFLUENCES THE WORK DESCRIBED. ABSOLUTELY NO CLAIMS FOR EXTRA COMPENSATION WILL BE ALLOWED FOR ANY UNEXPECTED CONDITIONS VISIBLE OR REASONABLY INFERRABLE FROM EXISTING RECORDS. |
| 12 | ELECTRICAL DEVICES SHALL BE TERMINATED IN A SAFE AND PROPER MANNER BY A LICENSED PROFESSIONAL. |

13. ALL MEP-HP DEVICE LOCATIONS NOT SHOWN ON DRAWINGS OR IN CONNECTION WITH MEP-HP DRAWINGS, ARE TO BE COORDINATED WITH ARCHITECT PRIOR TO INSTALLATION.
14. SHUTDOWN OF EXISTING SYSTEMS FOR CONNECTION TO EXISTING SERVICES SHALL BE COORDINATED WITH THE ARCHITECT, MANUFACTURER AND BUILDING OWNER. THE CONTRACTOR SHALL SUGGEST REPAIRS, WHERE NECESSARY, TO PREVENT THE OPERATION OF THE BUILDING SYSTEMS, AT LEAST ONE WEEK IN ADVANCE OF ANY SYSTEM SHUTDOWN. THE SHUTDOWN PERIOD SHALL BE AS SHORT AS POSSIBLE AND AT A TIME NATURALLY ACCORDING TO THE BUILDING OWNER AND THE CONSTRUCTION MANAGER.
15. ALL WORK SHALL COMPLY WITH FEDERAL, STATE, AND LOCAL BUILDING CODES.
16. G.C. TO COORDINATE ALL AUDIO/VISUAL EQUIPMENT NEEDS WITH CLIENT.
17. BOTTOM OF ALL HANGING FIXTURES TO BE NO LOWER THAN 7'-0" AFF.


18. CONTRACTOR TO PROVIDE OVERLAY DRAWING OF ELECTRICAL FIXTURES, MISC. SYSTEMS AND COMPONENTS, LIFE SAFETY DEVICES, SMOKE DETECTORS, EMERGENCY LIGHTS AND AIR OUTLETS IN CEILING TO ENSURE NO CONFLICTS.
19. SPRINKLER HEADS SHOWN FOR ARCHITECTURAL DESIGN IN ONLY. NOT FOR CODE DISTRIBUTION. SEE FIRE PROTECT ENGINEER FOR DISTRIBUTION AND CALCULATIONS.
20. CONTRACTOR WILL NOTIFY ARCHITECT IMMEDIATELY OF ANY CONFLICTS BETWEEN ARCHITECTURE AND ENGINEERING DRAWINGS.
21. THE CONTRACTOR SHALL INSPECT THE EXISTING FIELD CONDITIONS AT THE SITE PRIOR TO THE START OF ANY WORK TO DETERMINE WHAT EFFECT THE EXISTING CONDITIONS WILL HAVE ON HIS WORK. IMMEDIATELY, PROBLEM AREAS SHALL BE BROUGHT TO THE ATTN. OF THE ARCHIT AND/OR/ENGINEER IMMEDIATELY.
22. REFER TO SHEETS E-1.00 FOR ELECTRICAL DRAWINGS AND SERIES FOR FIRE SPRINKLER DRAWINGS.

OTHER	11 ALL EXISTING CROWN BOARD CELEBRIS TO BE MAINTAINED AND RESTORED WHERE POSSIBLE. MINIMAL SOLUTION FOR ADDITION OF NEW HADCO GRILLES AND SLOTTED GRILLES.
VENT	12 ALL EXISTING LIGHT FIXTURES IN HADCOON HALL TO BE REMOVED AND REPLACED IN SAME LOCATION UNLESS OTHERWISE NOTED.
	13 FOR HALL ROOMS REFER TO SHEETS A901-918.
	14 FOR OUTDOOR AREA LIGHTING REFER TO LANDSCAPE PLANS.
	15 EXISTING HIGHLIGHT SLOTTED AREAS IN HADCOON HALL FLOOR COMMON AREA TO BE KEPT AND RESTORED.
JECT	EXISTING EXPOSED SPRINKLER PIPES IN HADCOON HALL BUILDING TO BE COVERED WITH NEW PENDENT SLOTTED AREA ALL CORRIDORS.
	16 CENTER LIGHT FIXTURES IN SPACE U.D.
	17 REFER TO A-281 FOR LIGHTING FIXTURE SCHEDULE.
	18 LOW END CEILING LOW END BAYVIEW END SHEET SUBSTITUTION

- ① COORDINATE LOCATION OF HANGING CHAIR WITH DESIGNER PRIOR TO INSTALLATION. ADDITIONAL BLOCKING MAY BE REQUIRED.
- ② ALL GENERAL CEILING AND SCAFFOLDS TO BE PAINTED 02 (FLAT PINK). ALL QUESTROOM AND PUBLIC RESTROOMS CEILING TO BE PAINTED 01 (EGGSHELL PINK).
- ③ LED STRIP LIGHTING SHOWN ON PLAN WITH WATER AS AN ACCESSORY.
- ④ ALL LIGHT FIXTURES ON CAMPUS APARTMENTS AND POOL SITES TO BE NEW AND CENTERED IN SPACE U.O.A.
- ⑤ WALL SCHEMES SHOWN ON PLAN. ALL WALL COLOR AS INDICATED. HALL QUESTROOMS WILL REPLACE EXISTING IN SAME LOCATION. ALL SCHOICES IN CAMPUS AND POOL SITES NEW. HALL QUESTROOM ELEVATIONS FOR SOURCE HEIGHT.
- ⑥ 1"X4" MOUNTED TO CEILING IN FRONT OF WINDOW AS AN ACCESSORY. HALL QUESTROOM DRESSERY ROOF, 1"X4 TO BE PAINTED PT-07.

	OWN CEILING/SWITCH		BATTERY POWERED WALL MOUNTED
	CEILING HANG TYPE		LINEAR DIFFUSER
	CEILING HANG TYPE - HET		OCCUPANCY SENSOR
	1' x 4' PENDANT		END STOP
	DOWNLIGHT		ARROWS INDICATE DIRECTION
	LED STRIP LIGHT		SMOKE DETECTOR - WALL MOUNTED
	EXTERIOR/DECORATIVE SCENE		SMOKE DETECTOR CEILING MOUNTED
	PENDANT FIXTURE		SPRINKLER
	SURFACE MOUNTED FIXTURE		END STOP
	WALL SCENE		END STOP
	EXISTING FIXTURE TO BE REPLACED WITH NEW FIXTURE IN SAME LOCATION		END STOP
	EXISTING FIXTURE TO BE REPLACED WITH NEW FIXTURE IN SAME LOCATION		END STOP
	EXISTING FIXTURE TO BE REPLACED WITH NEW FIXTURE IN SAME LOCATION		

KEYPLAN N.T.S.

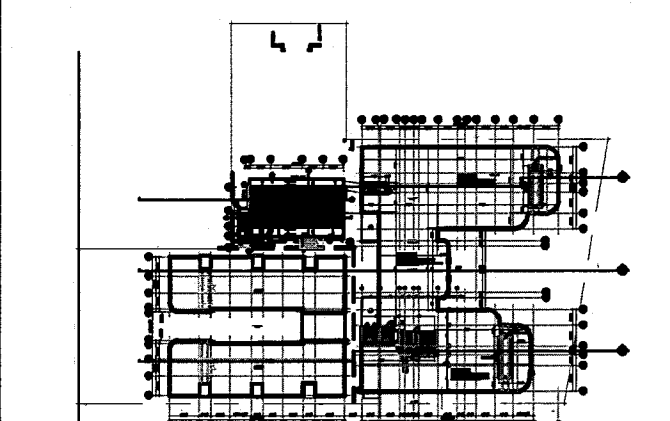[illegible]

MTCI
PRIVATE PROVIDER SERVICES, LLC
Construction Plans Review, Inspection, Bidding & Consulting

	REVIEWER INITIALS	DATE REVIEWED
BUILDING	EM	11-10-14
STRUCTURAL		
MECHANICAL		
ELECTRICAL		
PLUMBING		
SITE CIVIL		

ADD Inc Architecture Interiors Planning

One Biscayne Tower
Suite 1670
Two South
Biscayne Boulevard
Miami, Fl 33131
T. 305.482.8700
F. 305.482.8770
www.addinc.com
Lic. # AA26001507

Boston Miami

JOB NUMBER: 13036.0

CHECKED BY: _____

ISSUE DATE: FEBRUARY 18, 2014

SCALE: $1/4" = 1'-0"$

SHEET TITLE

ENLARGED ROOF DECK REFLECTED CEILING PLAN


SHEET NUMBER _____

A214

COPYRIGHT ADD, INC. 2011

APPROVED
MIAMI BEACH
FIRE DEPARTMENT

KEYPLAN N.T.S.

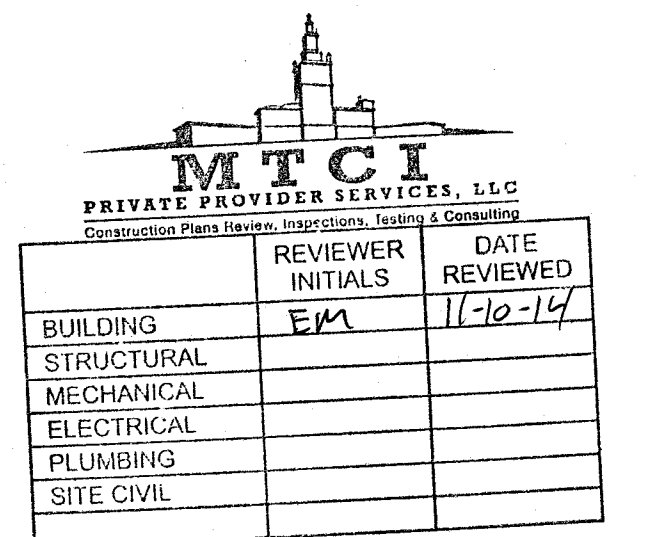[illegible]

SEAL

One Biscayne Tower
Suite 1670
Two South
Biscayne Boulevard
Miami, FL 33131
T. 305.482.8700
F. 305.482.8770
www.addinc.com
Lic. # AA26001507


Boston Miami

SCALE: NO SCALE


LIGHTING SCHEDULE & CEILING DETAILS

A281


COPYRIGHT ADD INC 2011

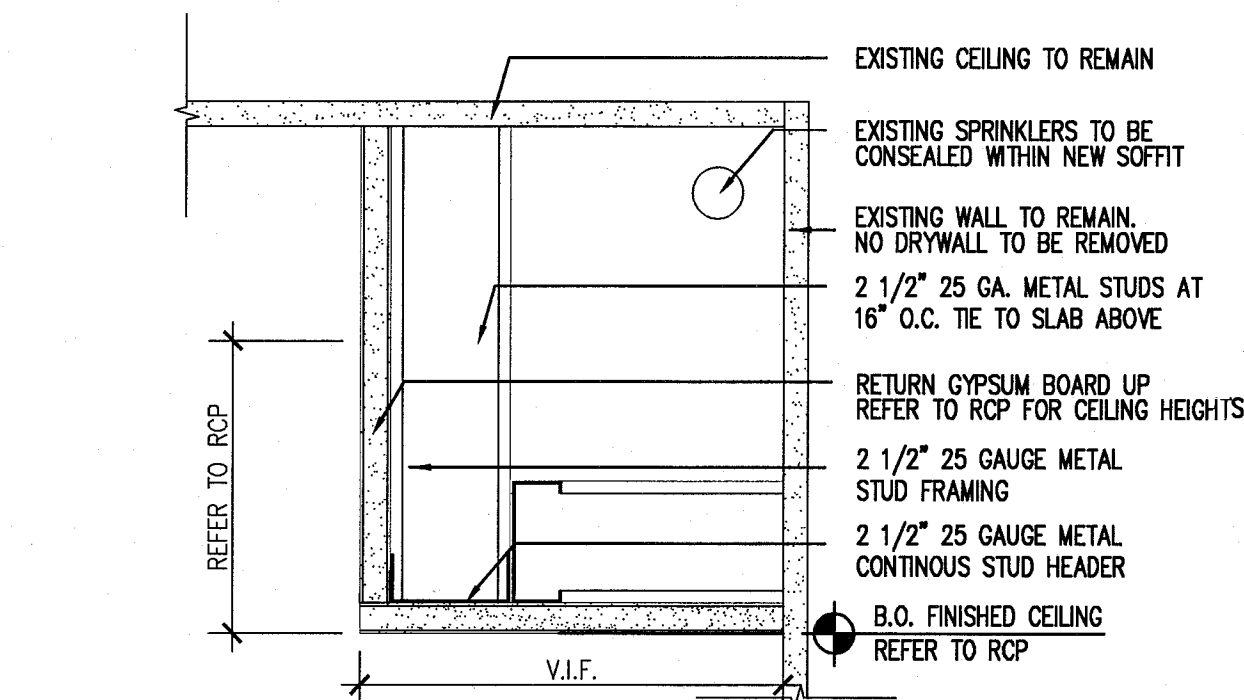

4 SOFFITS AT GUESTROOMS
SCALE: 3"=1'-0"

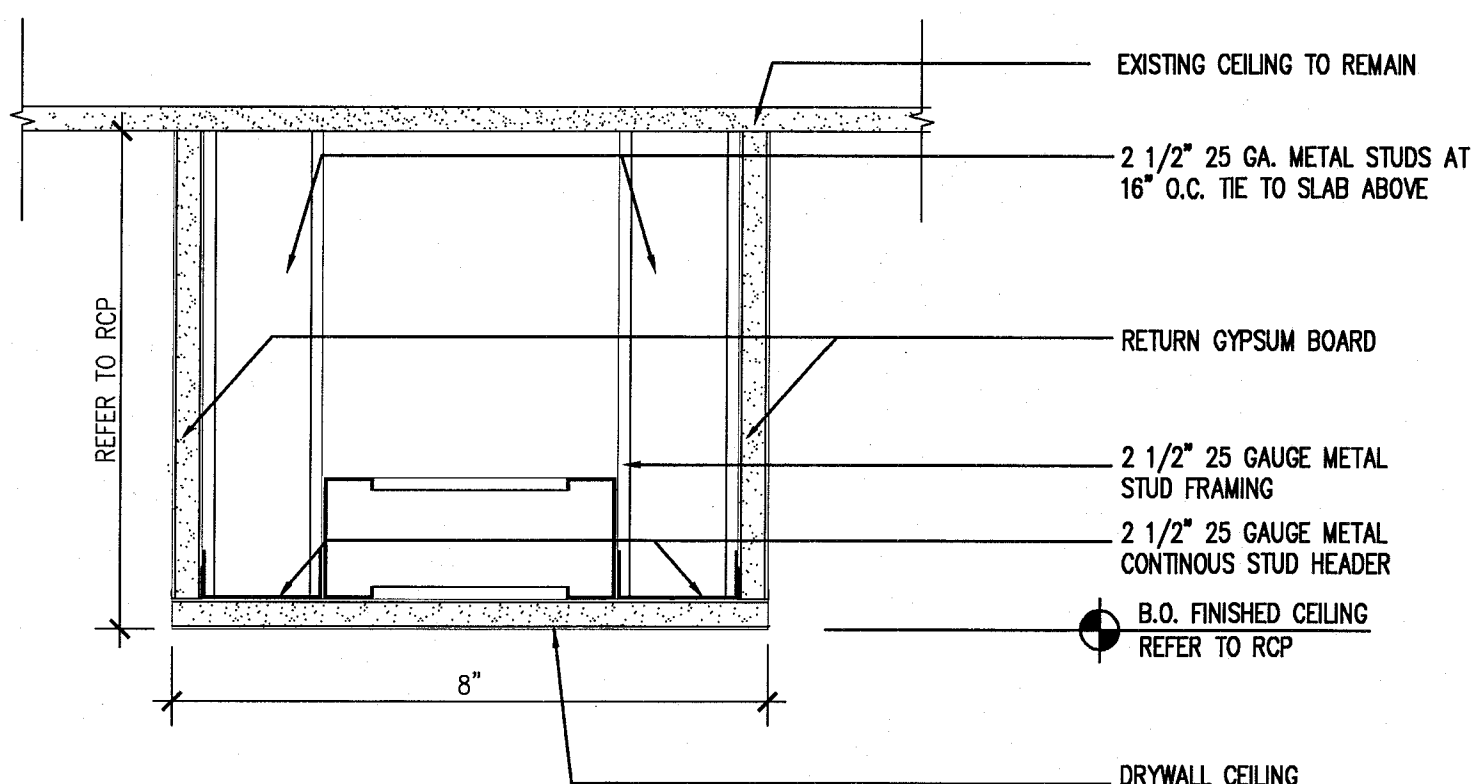

3 TYPICAL SOFFIT DETAIL AT HADDON CORRIDORS
SCALE: 3"=1'-0"

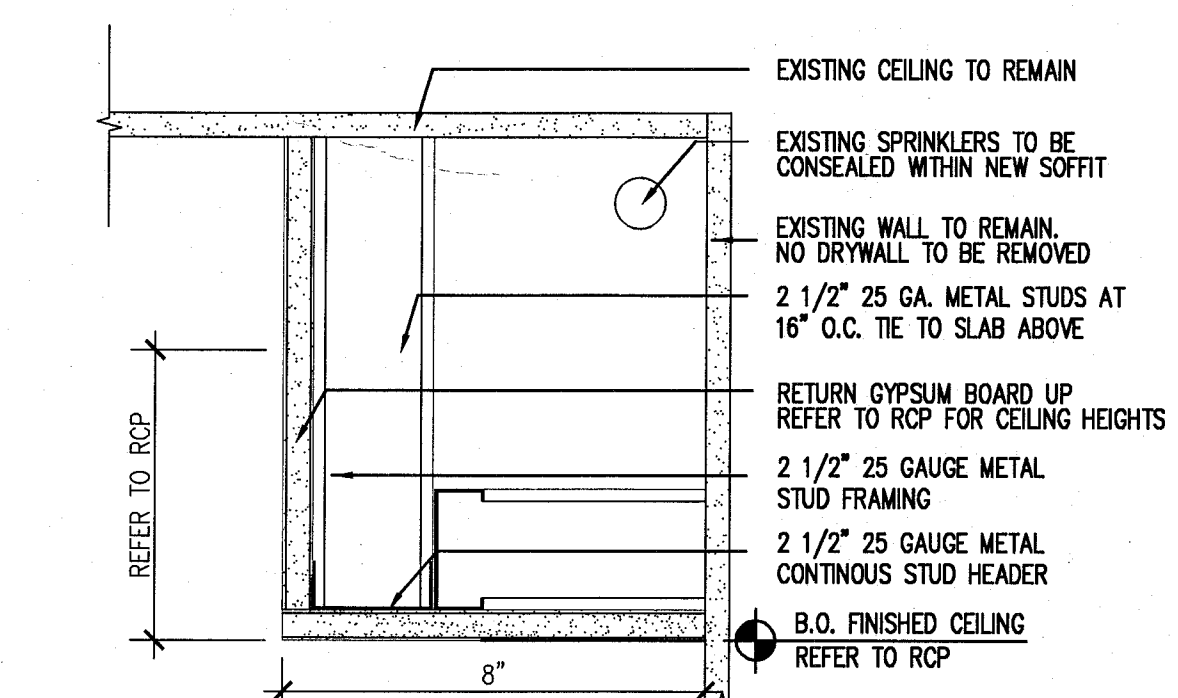

2 TYPICAL SOFFIT DETAIL AT HADDON CORRIDORS
SCALE: 3"=1'-0"

LIGHTING					
LT 1.00	RECESSED LIGHTS	LUCIFER LIGHTING CO.	# DL12P-NC-W-1-9510-27-2-DH-NC-ZF-1-9510-UNIVA VINTAGE ROTAFLEX LANTERN, One 100 Watt 120 Volt A19 E26 Medium Base Incandescent lamp, UL Listed	WHITE TRIM ON DIMMER	LOBBY
LT 1.01	PENDANT	VINTAGE		ON DIMMER, FURNISH BY OWNER, INSTALL BY CONTRACTOR	LOBBY
LT 1.02	DIRECTIONAL	HIP HAVEN	TRIPLE BULLET CEILING FIXTURE, SIZE: MEDIUM CUSTOMIZE: HIP HAVEN TO ADD STEMS	MATTE WHITE ON DIMMER, FURNISH BY OWNER, INSTALL BY CONTRACTOR	LOBBY
LT 1.03	LED STRIP	FLEXTEC	White 2700K - 160 Lumens - 24 Volt - High Output - Dimmable LED Tape Light 3M Taped Backing - LED Driver and Power Connector Cord Sold Separately - Indoor Use Only, with aluminum channel and frosted lense	REFURCE EXISTING COVE LIGHTS W/ LED STRIPS, WARMTH TO BE APPROVED BY RMCS ON DIMMER, GEL LIGHT WITH LEE FILTER 108 ENGLISH ROSE, APPLY	MSC
LT 1.04	PENDANT	BARNLIGHT ELECTRIC	THE ART DECO ROUND GLOBE SCHOOLHOUSE LIGHT SIZE: MEDIUM CODE: 118811	FINISHED, Aged BRASS ON DIMMER, FURNISH BY OWNER, INSTALL BY CONTRACTOR	LOBBY BAR
LT 1.05	LED STRIP	FLEXTEC	(12 inch) 4.5 Watt - Very Warm White 2700K - 160 Lumens - 24 Volt - High Output - Dimmable LED Tape Light 3M Taped Backing - LED Driver and Power Connector Cord Sold Separately - Indoor Use Only, with aluminum or flexible angle and frosted lense	MILLWORK LED STRIPS GELS TO BE SPECIFIED & APPROVED BY RMCS ON A DIMMER, GEL LIGHT WITH LEE FILTER 108 ENGLISH ROSE, APPLY UNDERNEATH LENS.	MSC
LT 1.06	CEILING FIXTURE		3M Taped Backing - LED Driver and Power Connector Cord Sold Separately - Indoor Use Only, with aluminum channel and frosted lense	ON DIMMER, FURNISH BY OWNER, INSTALL BY CONTRACTOR	GUESTROOMS
LT 1.07	BEDSIDE LIGHT FIXTURE	CUSTOM	60 W, TAKES 120 Volt G16 Bulb/ 25-60W, UL LISTED,	FURNISH BY OWNER, INSTALL BY CONTRACTOR	GUESTROOMS
LT 1.08	BATHROOM SCONCE	REJUVENATION	#A8260 HANNAH SCONCE, CLASSIC WALL BRACKET ITEM WHITE PORCELAIN, 100W	WHITE, FURNISH BY OWNER, INSTALL BY CONTRACTOR	GUESTROOMS
LT 1.09	BATHROOM LIGHT	LUCIFER LIGHTING CO.	DL21ZCP FOR WET LOCATION	WHITE TRIM, FURNISH BY OWNER, INSTALL BY CONTRACTOR	GUESTROOMS
LT 1.10	CLOSET SCONCE	ACCESS LIGHTING	NAUTICUS OVAL CEILING/WALL LIGHT	WHITE, FURNISH BY OWNER, INSTALL BY CONTRACTOR	GUESTROOMS
LT 1.11	CEILING LIGHT	SCHOOL HOUSE ELECTRIC	ALABAX LARGE, 150W, L 7" x W 8.25"	WHITE ON DIMMER, FURNISH BY OWNER, INSTALL BY CONTRACTOR	HALLWAYS
LT 1.12	SCONCE	SCHOOL HOUSE ELECTRIC	TRUMAN SCONCE	WHITE, FURNISH BY OWNER, INSTALL BY CONTRACTOR	PUBLIC RESTROOMS
LT 1.13	PICTURE LIGHT	HOUSE OF TROY	TRADITIONAL PLUG IN PICTURE LIGHT	TBD, PLUG, FURNISH BY OWNER, INSTALL BY CONTRACTOR	JUICE BAR
LT 1.14	PICTURE LIGHT	HOUSE OF TROY	TRADITIONAL PLUG IN PICTURE LIGHT	TBD, PLUG, FURNISH BY OWNER, INSTALL BY CONTRACTOR	JUICE BAR
LT 1.15	PICTURE LIGHT	HOUSE OF TROY	TRADITIONAL PLUG IN PICTURE LIGHT	TBD, PLUG, FURNISH BY OWNER, INSTALL BY CONTRACTOR	JUICE BAR
LT 1.16	PICTURE LIGHT	HOUSE OF TROY	TRADITIONAL PLUG IN PICTURE LIGHT	TBD, PLUG, FURNISH BY OWNER, INSTALL BY CONTRACTOR	JUICE BAR
LT 1.17	WALL MOUNTED	INFURN	INSPIRED PROOVE POTENCE LAMP, 60 W	BLACK POWDERCOAT, FURNISH BY OWNER, INSTALL BY CONTRACTOR	LOBBY CONCIERGE
LT 1.18	RECESSED LIGHTS	LUCIFER LIGHTING CO.	# DL12P-NC-W-1-9510-27-2-DH-NC-ZF-1-9510-UNIVA	WHITE TRIM ON DIMMER	LOBBY BAR
LT 1.19	SCONCE	MNKA LAVERY	#9836 1 LIGHT OUTDOOR TIERED SCONCE, 100 W, 120 V, CERAMIC	WHITE, FURNISH BY OWNER, INSTALL BY CONTRACTOR	OUTDOOR RESTAURANT
LT 1.20	RECESSED LIGHTS	LUCIFER LIGHTING CO.	# DL12P-NC-W-1-9510-27-2-DH-NC-ZF-1-9510-UNIVA	WHITE TRIM ON DIMMER	LIBRARY
LT 1.21	RECESSED LIGHTS	LUCIFER LIGHTING CO.	# DL12P-NC-W-1-9510-27-2-DH-NC-ZF-1-9510-UNIVA	WHITE TRIM ON DIMMER	OUTDOOR RESTAURANT
LT 1.22	WALL LIGHT SCULPTURE	TBD	CUSTOM PER DRAWINGS BY RMCS	TBD, FURNISH BY OWNER, INSTALL BY CONTRACTOR	OUTDOOR RESTAURANT
LT 1.23	STRING LIGHTS	OOGALIGHTS.COM	SKU#: LS115-WHT, 330' Commercial Linear Light String Strand - Intermediate Base - White	WHITE, FURNISH BY OWNER, INSTALL BY CONTRACTOR	OUTDOOR RESTAURANT
LT 1.24	PENDANT LIGHTS OVER BAR	VINTAGE	INDUSTRIAL PENDANT LIGHTS, One 100 Watt 120 Volt A19 E26 Medium Base Incandescent lamp, UL Listed	TBD ON DIMMER, FURNISH BY OWNER, INSTALL BY CONTRACTOR	JUICE BAR
LT 1.25	PICTURE LIGHT	HOUSE OF TROY	TRADITIONAL PLUG IN PICTURE LIGHT	TBD, PLUG, FURNISH BY OWNER, INSTALL BY CONTRACTOR	JUICE BAR
LT 1.26	PENDANT	TBD	CUSTOM PER DRAWINGS BY RMCS (PICTURE FOR INSPIRATION), One 100 Watt 120 Volt A19 E26 Medium Base Incandescent lamp, UL Listed	TBD ON DIMMER, FURNISH BY OWNER, INSTALL BY CONTRACTOR	LIBRARY
LT 1.27	LINEAR FLOURESCENT - SUSPENDED	FOCAL POINT LIGHTS	TAB EVOLUTION, 1' x 4'	CLEAR SHIELD, FURNISH BY OWNER, INSTALL BY CONTRACTOR	BACK OF HOUSE AREAS
LT 1.27A	SURFACE MOUNTED LINEAR	SIMPLESEAL	HASESI SERIES; 1'x4'		BACK OF HOUSE AREAS
LT 1.28	SCHOOL HOUSE ELECTRIC	ALABAX LARGE, 150W, L 7" x W 8.25", UL DAMP LISTED, WHITE	TBD	FURNISH BY OWNER, INSTALL BY CONTRACTOR	INTERIOR CAMPTON CORRIDORS
LT 1.29	SCHOOL HOUSE ELECTRIC	ALABAX LARGE, 150W, L 7" x W 8.25", UL DAMP LISTED, WHITE	TBD	FURNISH BY OWNER, INSTALL BY CONTRACTOR	EXTERIOR CAMPTON STAIRS
LT 1.30	SCHOOL HOUSE ELECTRIC	ALABAX LARGE, 150W, L 7" x W 8.25", UL DAMP LISTED, WHITE	TBD	FURNISH BY OWNER, INSTALL BY CONTRACTOR	HADDON STAIRS
LT 1.31	SCHOOL HOUSE ELECTRIC	ALABAX LARGE, 150W, L 7" x W 8.25", UL DAMP LISTED, WHITE	TBD	FURNISH BY OWNER, INSTALL BY CONTRACTOR	POOL SUITES CORRIDOR
LT 1.32	PENDANT LIGHTS	SOLAVANTI LIGHTING RMCS TO PROVIDE	CAP 10.353	SILVER, FURNISH BY OWNER, INSTALL BY CONTRACTOR	GYM
LT 1.33	EXISTING LIGHT FIXTURES TO REMAIN				SHOP/MULTIFUNCTION
LT 1.34	EXTERIOR SCONCE			FURNISH BY OWNER, INSTALL BY CONTRACTOR	CAMPTON LOBBY
LT 1.35	RECESSED LIGHTS	LUCIFER LIGHTING CO.	# DL12P-NC-W-1-9510-27-2-DH-NC-ZF-1-9510-UNIVA	WHITE TRIM ON DIMMER	POOL SUITES
LT 1.36	PENDANT	TBD	CUSTOM PER DRAWINGS BY RMCS, One 100 Watt 120 Volt A19 E26 Medium Base Incandescent lamp, UL Listed	TBD ON DIMMER, FURNISH BY OWNER, INSTALL BY CONTRACTOR	POOL SUITES

1 LIGHTING SCHEDULE
SCALE: NO SCALE

APPROVED
MIAMI BEACH
FIRE DEPARTMENT

Figure 1 shows a 4x4 grid of 16 small squares. Each small square contains a unique pattern of black dots. The patterns are as follows (row by row, left to right):

- Row 1: 4 dots in a 2x2 square; 3 dots in a horizontal row; 3 dots in a vertical column; 2 dots in a horizontal row.
- Row 2: 2 dots in a horizontal row; 2 dots in a vertical column; 1 dot; 1 dot.
- Row 3: 1 dot; 1 dot; 1 dot; 1 dot.
- Row 4: 1 dot; 1 dot; 1 dot; 1 dot.

These patterns represent the four basic shapes and their combinations, used for the dot pattern matching task.

[illegible]

**100% CONSTRUCTION
DOCUMENT SET**

Jonathan Cardello
Lic # AR93391

One Biscayne Tower
Suite 1670
Two South
Biscayne Boulevard
Miami, FL 33131
T. 305.482.8700
F. 305.482.8770
www.addinc.com
Lic. # AA26001507

Boston Miami

CHECKED BY: _____
 ISSUE DATE: FEBRUARY 18, 2014
 SCALE: $1/8" = 1'-0"$

 
EXTERIOR
ELEVATIONS WEST
EAST & ROOFTOP

A301

APPROVED
MIAMI BEACH
FIRE DEPARTMENT



NOTE: ALL WINDOWS AT EAST HADDON HALL ELEVATION WILL HAVE VISIBLE TRANSMISSION OF 34% DUE TO EASTERN EXPOSURE. SEE SHEET A431.






1. REPLICATE ORIGINAL DECORATIVE SCREEN AT ALL PARAPET LOCATIONS (HADDON HALL BUILDING)
2. NEW PAINT AND RESTORED FINISH AT ALL EXISTING BUILDING EXTERIORS THROUGHOUT; NEW PAINT / FINISHES AT NEW BUILDING CONSTRUCTION
3. REPLACE ALL EXTERIOR WINDOWS/FRAMES WITH NEW (CODE COMPLIANT) WITH ALL ASSOCIATED FINISHES TO BE RESTORED (SEE FINISH SCHEDULE); ALL MUNTINS/MULLIONS AT HISTORIC BUILDINGS TO MATCH ORIGINAL HISTORIC PATTERNS; NEW HORIZONTAL WINDOW SAFETY BARS AT BUILDING INTERIORS AT OPERABLE WINDOW LOCATIONS (WHERE TOP OF SILL HEIGHT IS LESS THAN 42" AFF); NEW WINDOWS/FRAMES AT NEW BUILDING CONSTRUCTION
4. ALL A/C WINDOW BOX UNITS TO BE REMOVED AT ALL BUILDINGS; ASSOCIATED WALLS TO BE BLOCKED-UP, PATCHED AND PAINTED AND ALL ADJACENT FINISHES TO BE RESTORED (SEE FINISH SCHEDULE)
5. REPLACE ALL EXTERIOR DOORS/FRAMES WITH NEW (CODE COMPLIANT); NEW DOORS/FRAMES AT NEW BUILDING CONSTRUCTION
6. REMOVE EXISTING WATERPROOFING AND PATCH, PAINT, RESTORE BUILDING EYEBROWS; PROVIDE NEW WATERPROOFING MEMBRANE SYSTEM
7. RESTORE HISTORIC SIGNAGE
8. REPLICATE HISTORIC SIGNAGE
9. NEW ARCHITECTURAL SLATTED SCREEN; PAINTED ALUMIN. (RECTANGULAR TUBULAR SECTIONS)
10. NEW ARCHITECTURAL SLATTED RAILING SYSTEM; PAINTED ALUMIN. (RECTANGULAR TUBULAR SECTIONS)
11. CLIMBING PLANT / GREEN WALL LOCATION
12. NEW SAFETY RAILING AT EXTERIOR EXISTING RAMP, STAIR, AND NEW BUILDING CONSTRUCTION LOCATIONS
13. RESTORE EXISTING HISTORIC BALUSTRADE AT SELECT LOCATIONS
14. NEW CONCRETE PLANTERS
15. NEW ROOFING SYSTEM
16. NEW ROOFTOP EQUIPMENT LOWER SCREEN / ENCLOSURE
17. RESTORE AND REPLACE AS NEEDED/ REQUIRED NEON LIGHTING AT HADDON HALL, HOTEL, EASTER FACADE



HADDON HALL 1500 COLLINS AVE MIAMI BEACH, FL

KEYPLAN N.T.S.

SEE NOTES SHEET A301

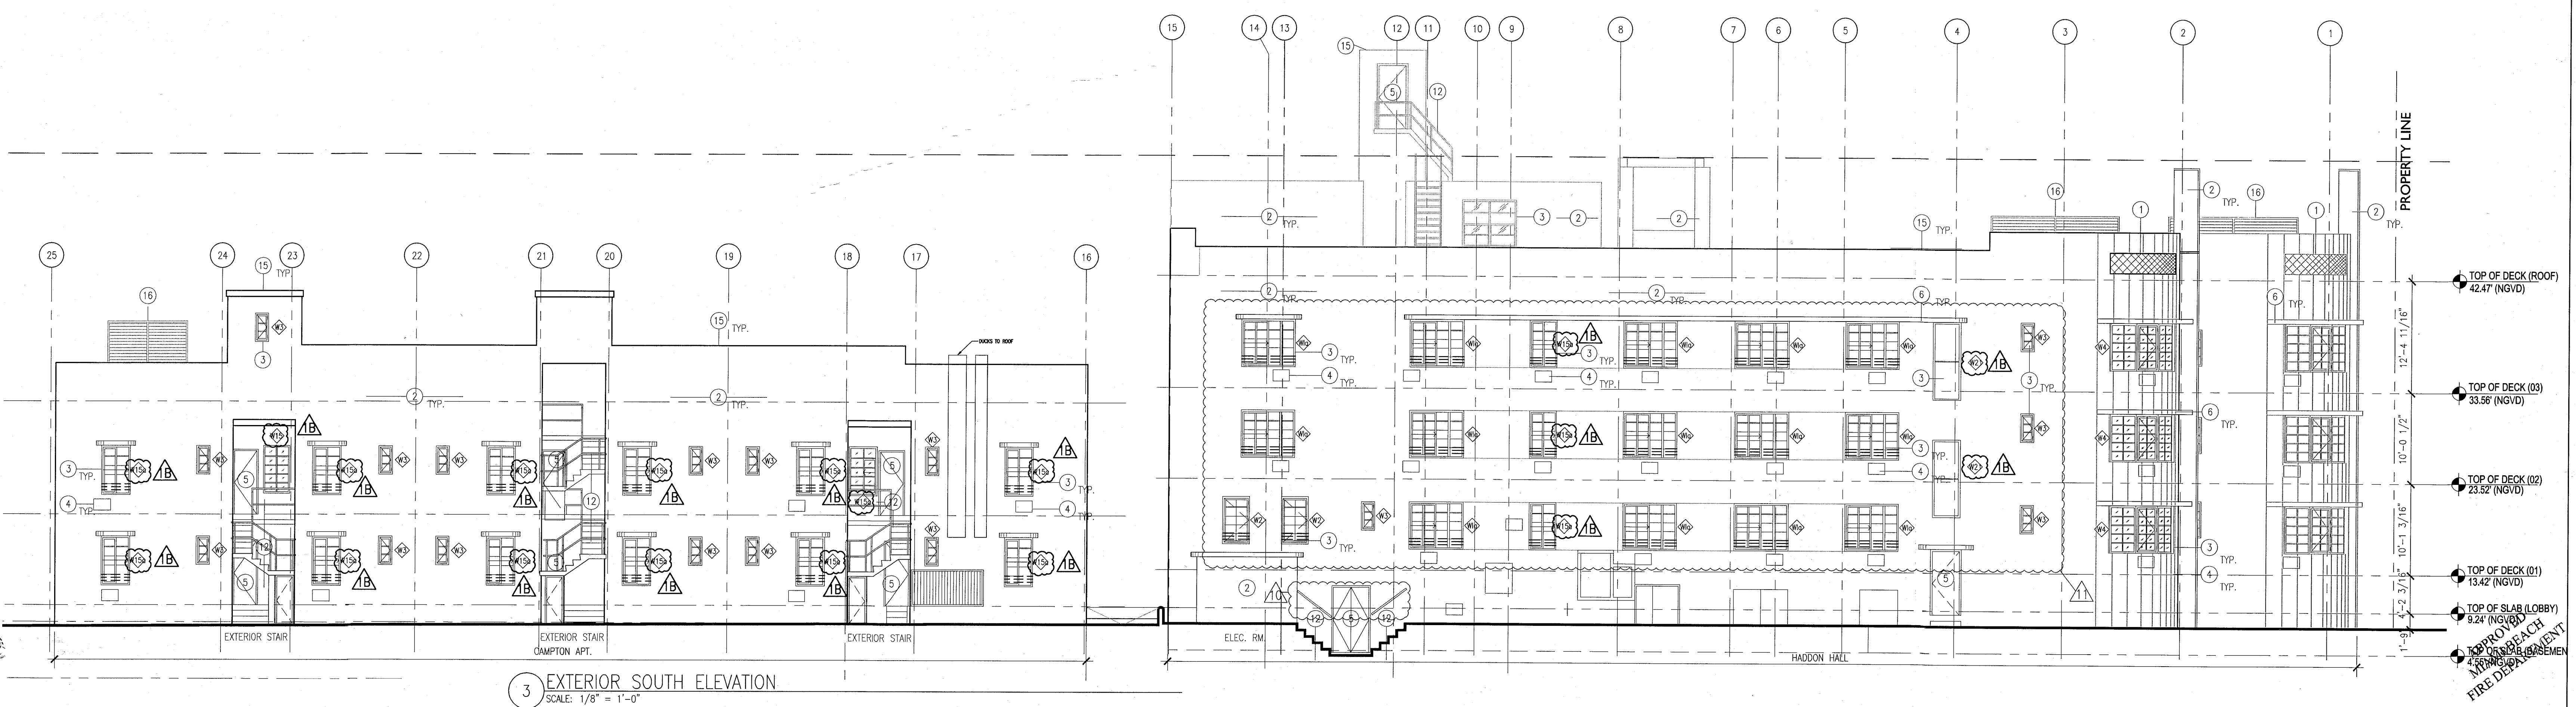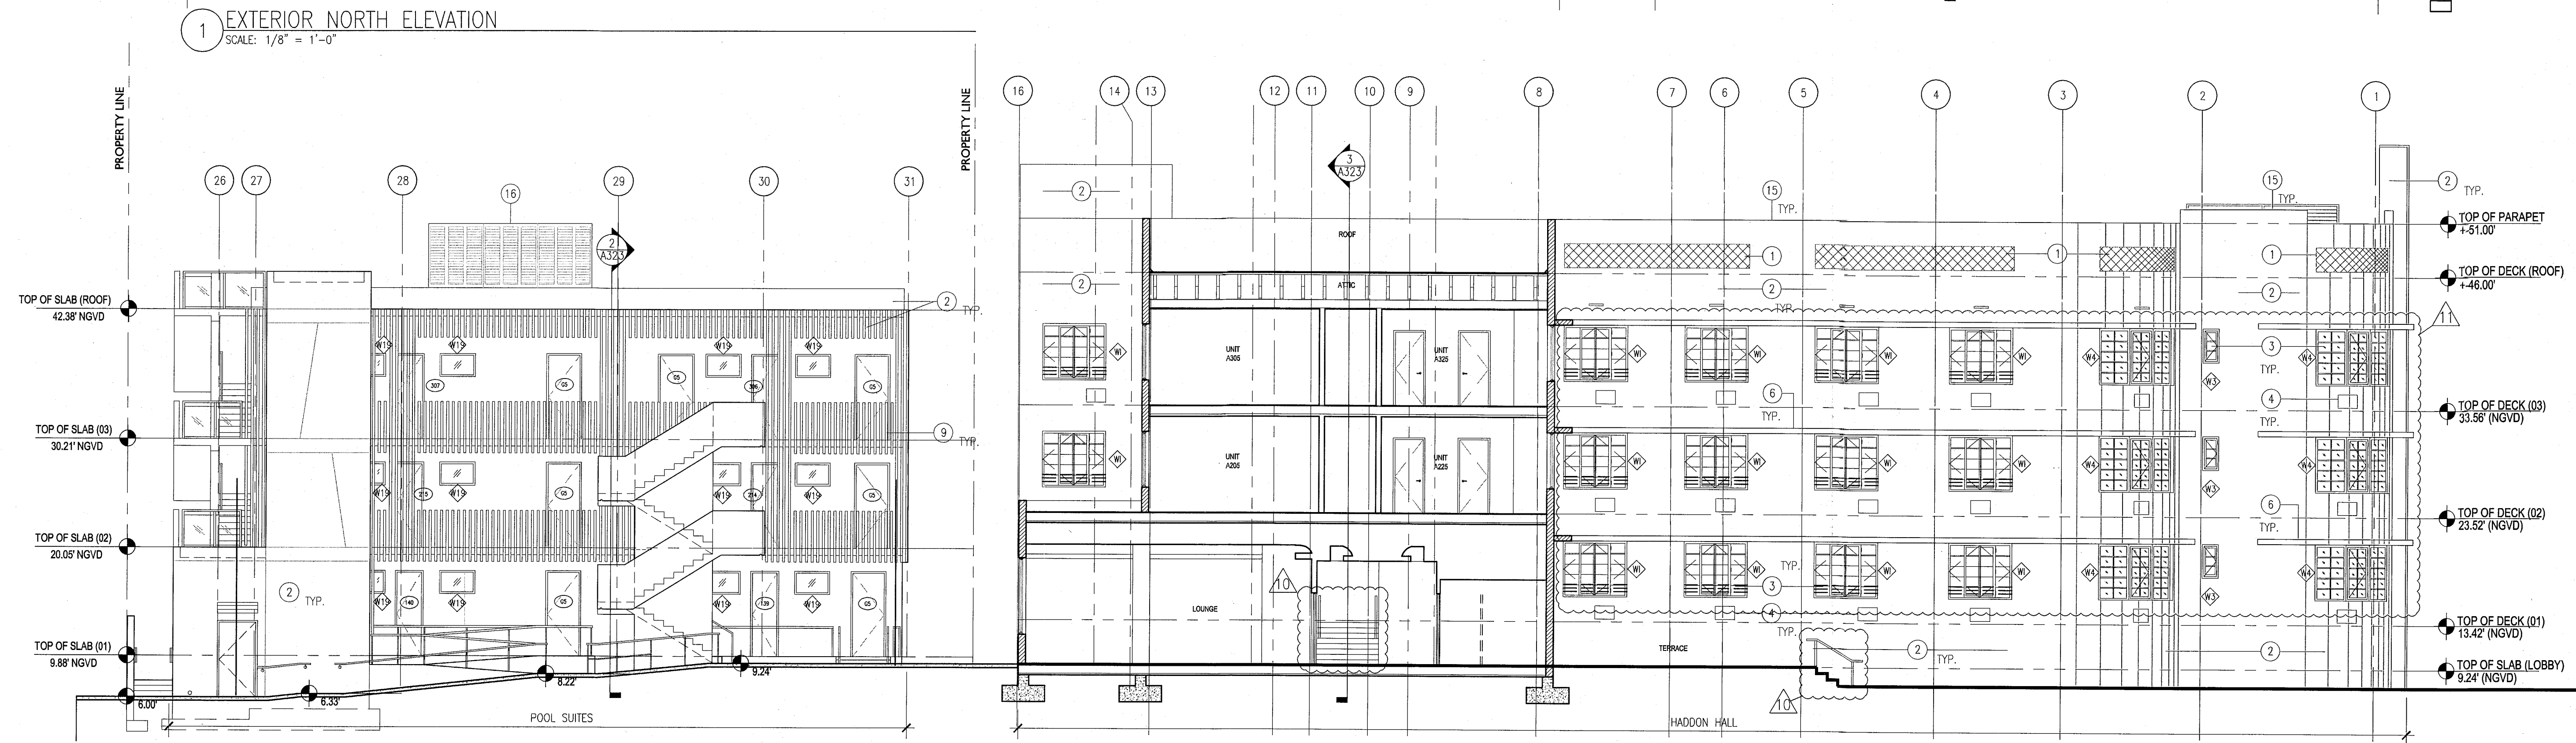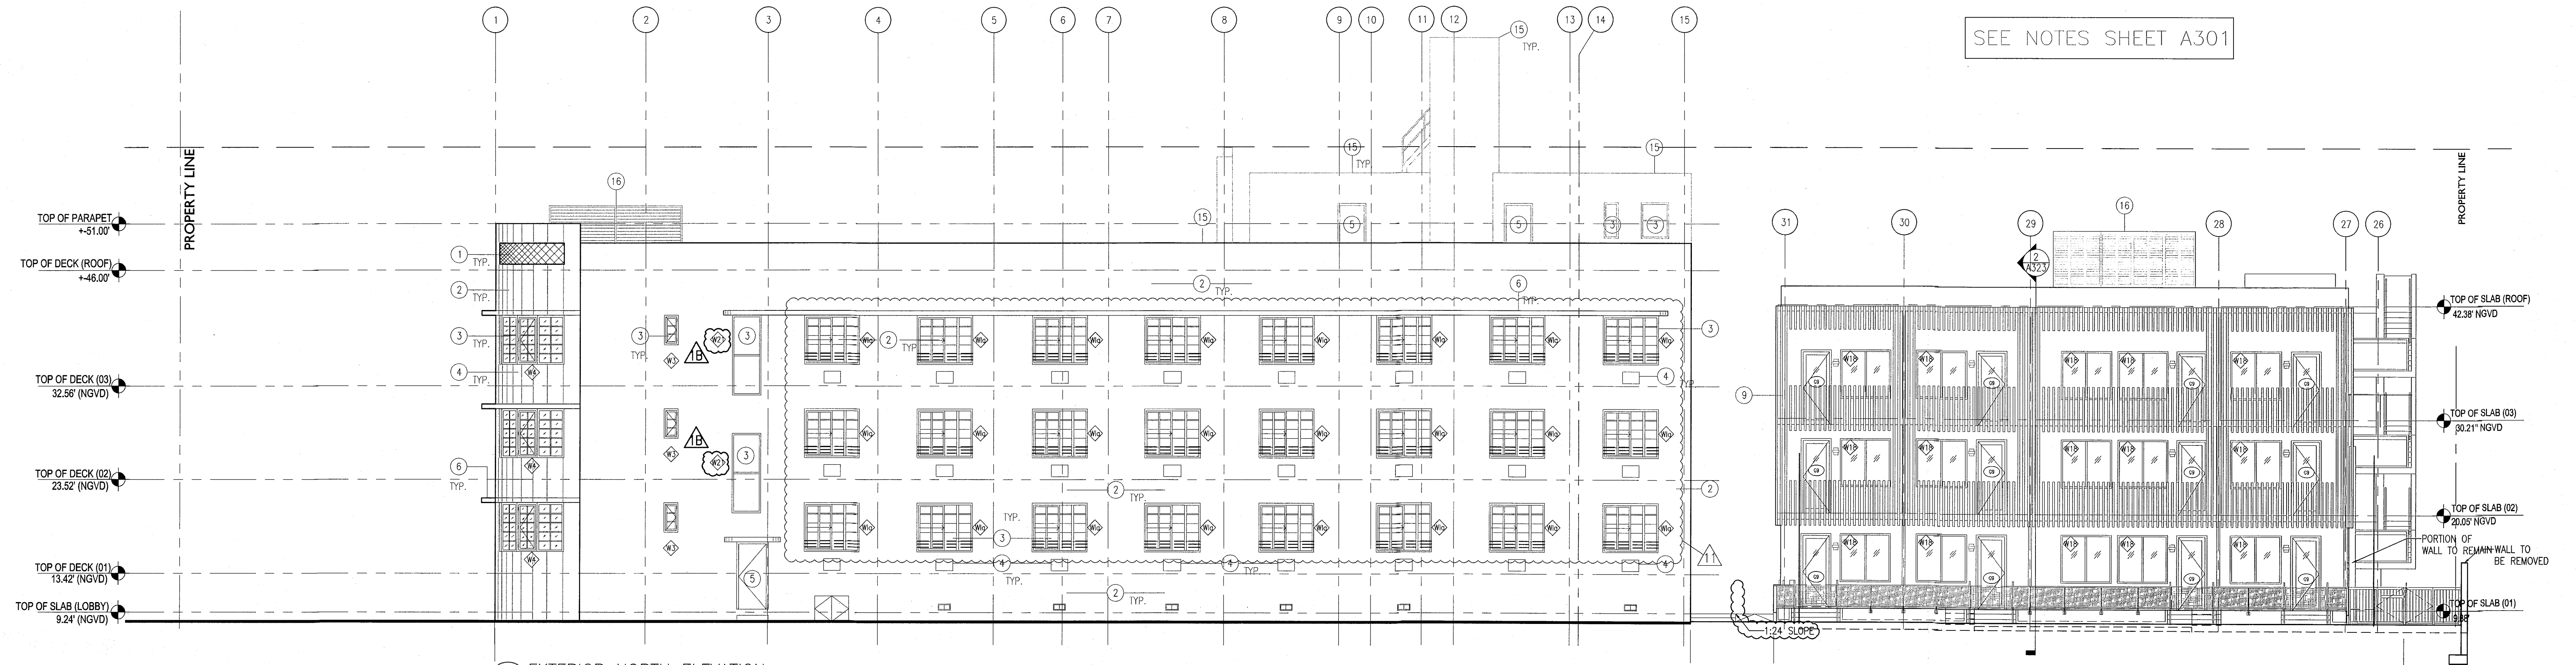

NO.	DESCRIPTION	ISSUE DATE
1B	DOOR-WINDOW COORD.	03-5-2014
1A	FIRE REVIEW COMMENTS	04-01-2014
1D	MASTER PERMIT COMMENTS	07-03-2014
11	P&Z COMMENTS	07-14-2014

MTCY PRIVATE PROVIDER SERVICES, LLC			
Construction Plans, Specifications, Materials & Estimating			
BUILDING	REVIEWER	DATE	
STRUCTURAL	INITIALS	REVIEWED	
MECHANICAL			
ELECTRICAL			
PLUMBING			
SITE CIVIL			

100% CONSTRUCTION
DOCUMENT SET

ADD Inc Architecture Interiors Planning

One Biscayne Tower
Suite 1670
Two South
Biscayne Boulevard
Miami, FL 33131
T. 305.482.8700
F. 305.482.8770
www.addinc.com
Lic. # AR25001507

JOB NUMBER: 13036.00
CHECKED BY:
ISSUE DATE: FEBRUARY 18, 2014
SCALE: 1/8" = 1'-0"

SHEET TITLE

EXTERIOR
ELEVATIONS WEST
EAST & SOUTH

SHEET NUMBER

A302

COPYRIGHT ADD INC 2011

HADDON HALL 1500 COLLINS AVE MIAMI BEACH, FL

KEYPLAN N.T.S.

NO.	DESCRIPTION	ISSUE DATE
1	DOOR-WINDOW COORD.	03-05-2014
2	FIRE REVIEW COMMENTS	04-01-2014
3	GUESTROOMS COORDINATION	04-17-2014
4	POOL SUITES WALLS	04-09-2014
5	KITCHEN REINFORCEMENT	05-30-2014
6	P&Z COMMENTS	07-14-2014

REVISIONS		
NO.	DESCRIPTION	ISSUE DATE
1	DOOR-WINDOW COORD.	03-05-2014
2	FIRE REVIEW COMMENTS	04-01-2014
3	GUESTROOMS COORDINATION	04-17-2014
4	POOL SUITES WALLS	04-09-2014
5	KITCHEN REINFORCEMENT	05-30-2014
6	P&Z COMMENTS	07-14-2014

100% CONSTRUCTION DOCUMENT SET

SEAL

Jonathan Cardello
Lic. # AR93391

ADD Inc Architecture Interiors Planning

One Biscayne Tower
Suite 1670
Two South
Biscayne Boulevard
Miami, FL 33131
T: 305.482.8700
F: 305.482.8770
www.addinc.com
Lic. # AA28001507

JOB NUMBER: 13036.00
CHECKED BY:
ISSUE DATE: FEBRUARY 18, 2014
SCALE: 1/8" = 1'-0"


SHEET TITLE

EXTERIOR ELEVATIONS NORTH EAST & WEST

SHEET NUMBER

A303

COPYRIGHT ADD INC 2011

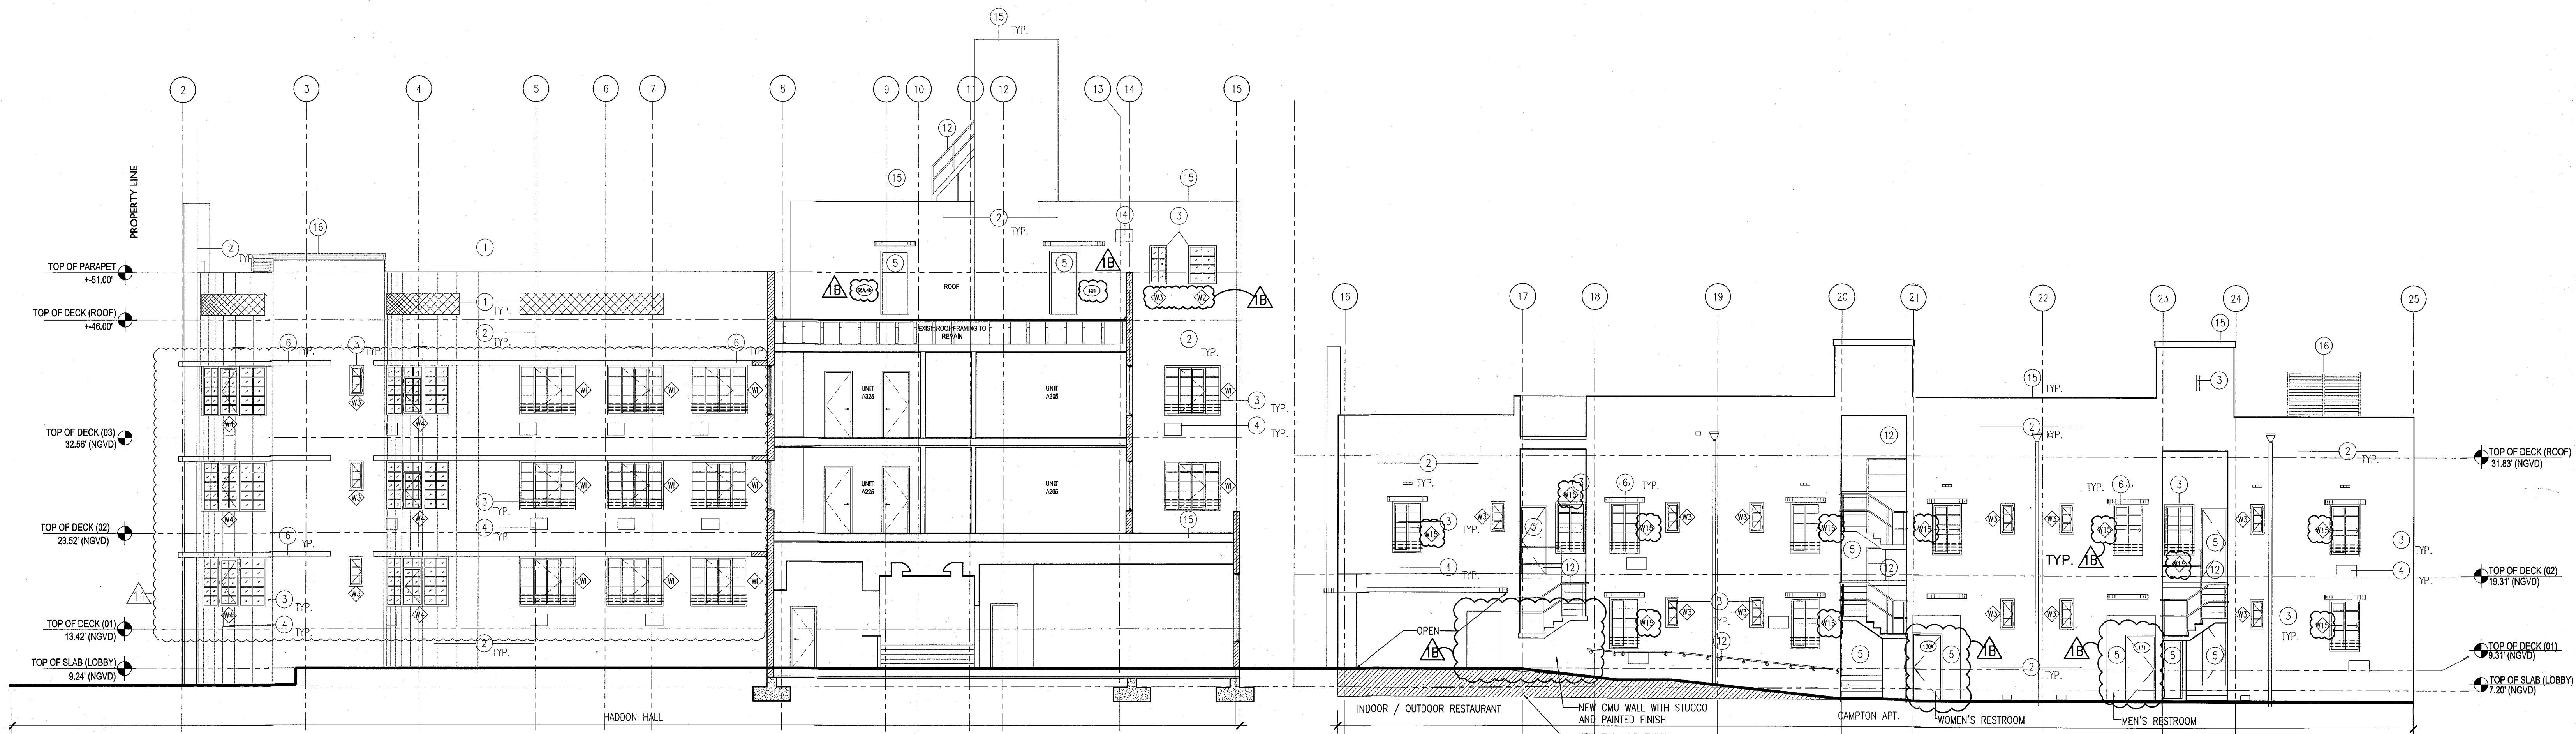


1 EXTERIOR NORTH CAMPTON ELEVATION

SCALE: 1/8" = 1'-0"


NOTES

1. REPLICATE ORIGINAL DECORATIVE SCREEN AT ALL PARAPET LOCATIONS (HADDON HALL BUILDING)
2. NEW PAINT AND RESTORED FINISH AT ALL EXISTING BUILDING EXTERIORS THROUGHOUT; NEW PAINT / FINISHES AT NEW BUILDING CONSTRUCTION
3. REPLACE ALL EXISTING WINDOWS/FRAMES WITH NEW (CODE COMPLIANT) WITH ALL ASSOCIATED FINISHES TO BE RESTORED (SEE FINISH SCHEDULE); ALL MANTLES/MULLIONS AT HISTORIC BUILDINGS TO MATCH ORIGINAL HISTORIC PATTERNS; NEW HORIZONTAL WINDOW SAFETY BARS AT BUILDING INTERIORS AT OPERABLE WINDOW LOCATIONS (WHERE TOP OF SILL HEIGHT IS LESS THAN 42" AFF); NEW WINDOWS/FRAMES AT NEW BUILDING CONSTRUCTION
4. ALL A/C WINDOW BOX UNITS TO BE REMOVED AT ALL BUILDINGS; ASSOCIATED WALLS TO BE BLOCKED-UP, PATCHED AND PAINTED AND ALL ADJACENT FINISHES TO BE RESTORED (SEE FINISH SCHEDULE)
5. REPLACE ALL EXISTING DOORS/FRAMES WITH NEW (CODE COMPLIANT); NEW DOORS/FRAMES AT NEW BUILDING CONSTRUCTION
6. REMOVE EXISTING WATERPROOFING AND PATCH, PAINT, RESTORE BUILDING EYEBROWS, PROVIDE NEW WATERPROOFING MEMBRANE SYSTEM
7. RESTORE HISTORIC SIGNAGE
8. REPLICATE HISTORIC SIGNAGE
9. NEW ARCHITECTURAL SLATED SCREEN; PAINTED ALUMINUM (RECTANGULAR TUBULAR SECTIONS)
10. NEW ARCHITECTURAL SLATED RAILING SYSTEM; PAINTED ALUMINUM (RECTANGULAR TUBULAR SECTIONS)
11. CLIMBING PLANT / GREEN WALL LOCATION
12. NEW SAFETY RAILING AT EXTERIOR EXISTING RAMP, STAIR, AND NEW BUILDING CONSTRUCTION LOCATIONS
13. RESTORE EXISTING HISTORIC BALUSTRADE AT SELECT LOCATIONS
14. NEW CONCRETE PLANTERS
15. NEW ROOFING SYSTEM
16. NEW ROOFTOP EQUIPMENT LOUVER SCREEN / ENCLOSURE
17. RESTORE AND REPLACE AS NEEDED/ REQUIRED NEON LIGHTING AT HADDON HALL HOTEL EXTERIOR FACADE

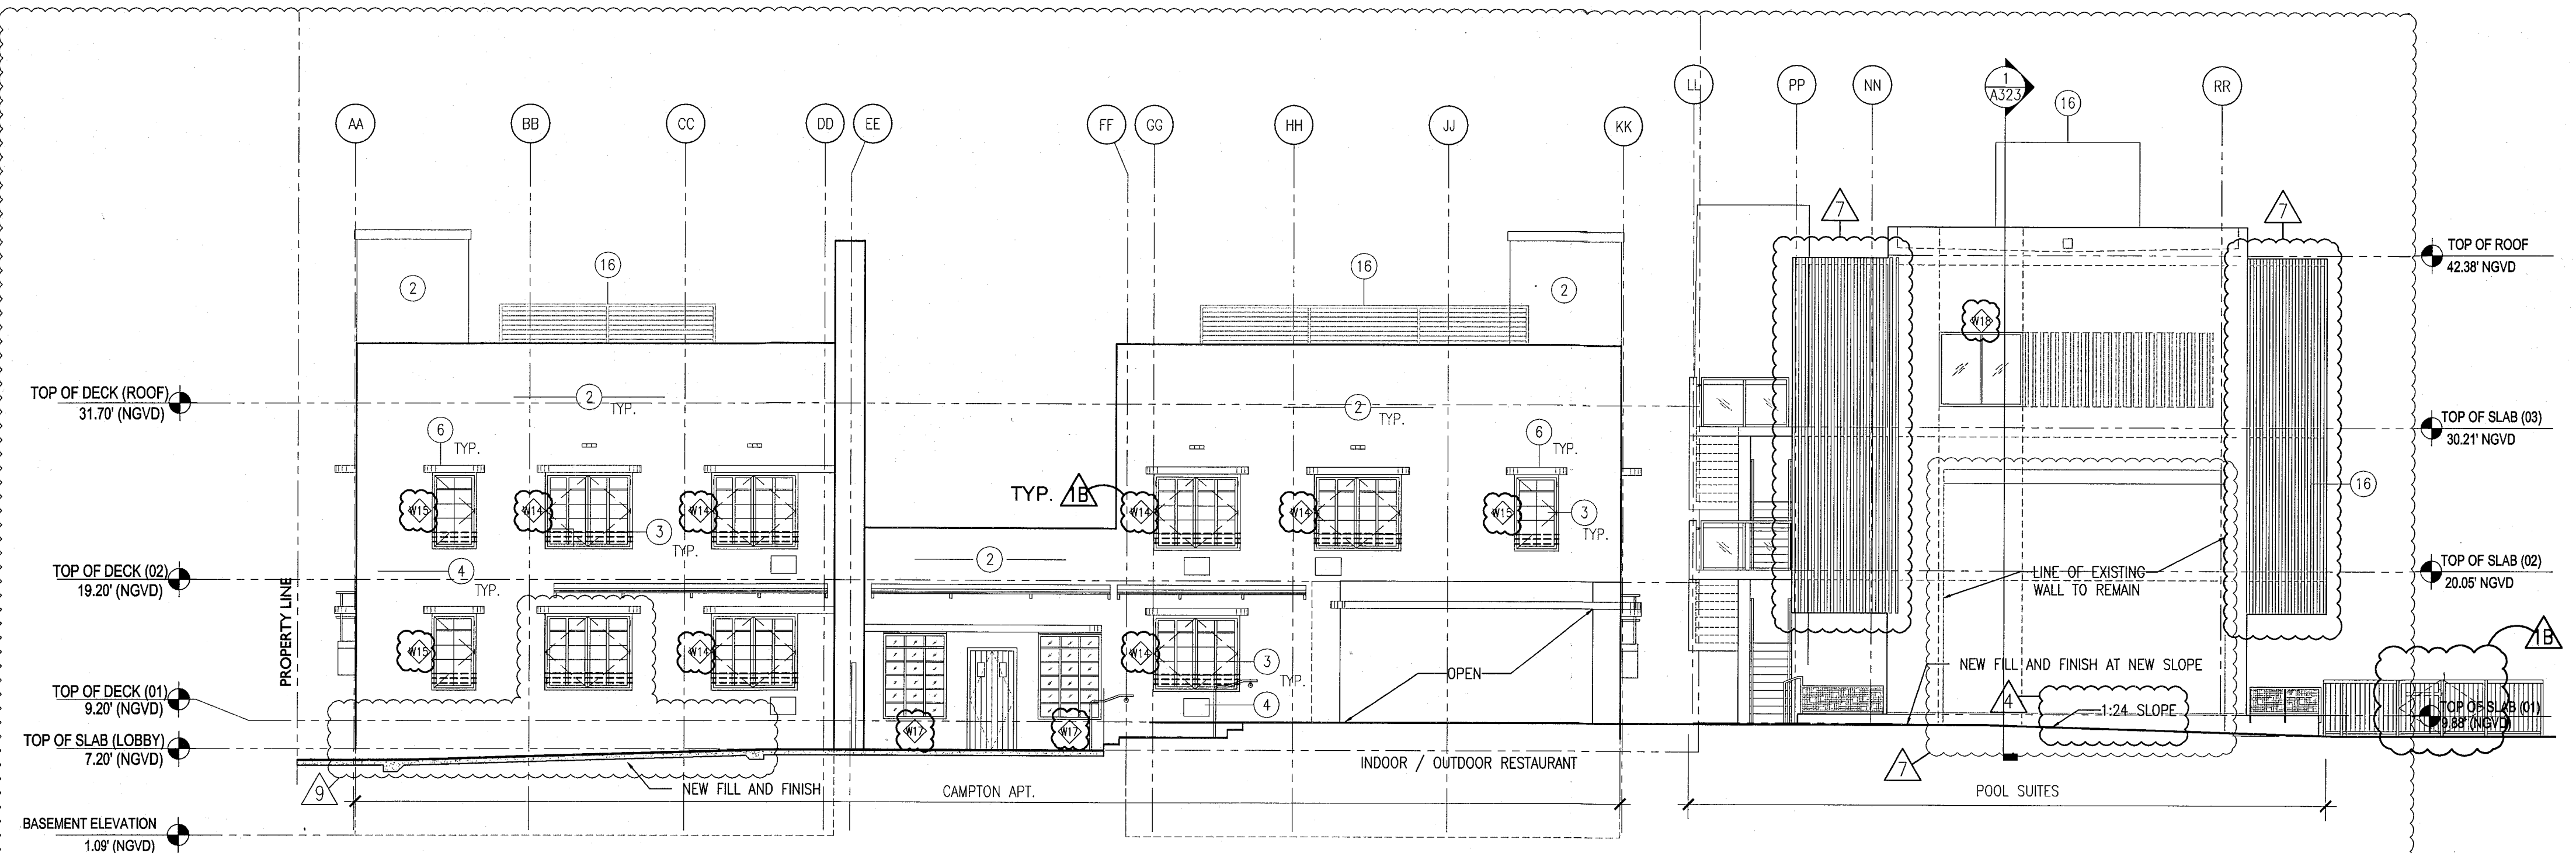

2 EXTERIOR EAST CAMPTON & POOL SUITES ELEVATION

SCALE: 1/8" = 1'-0"

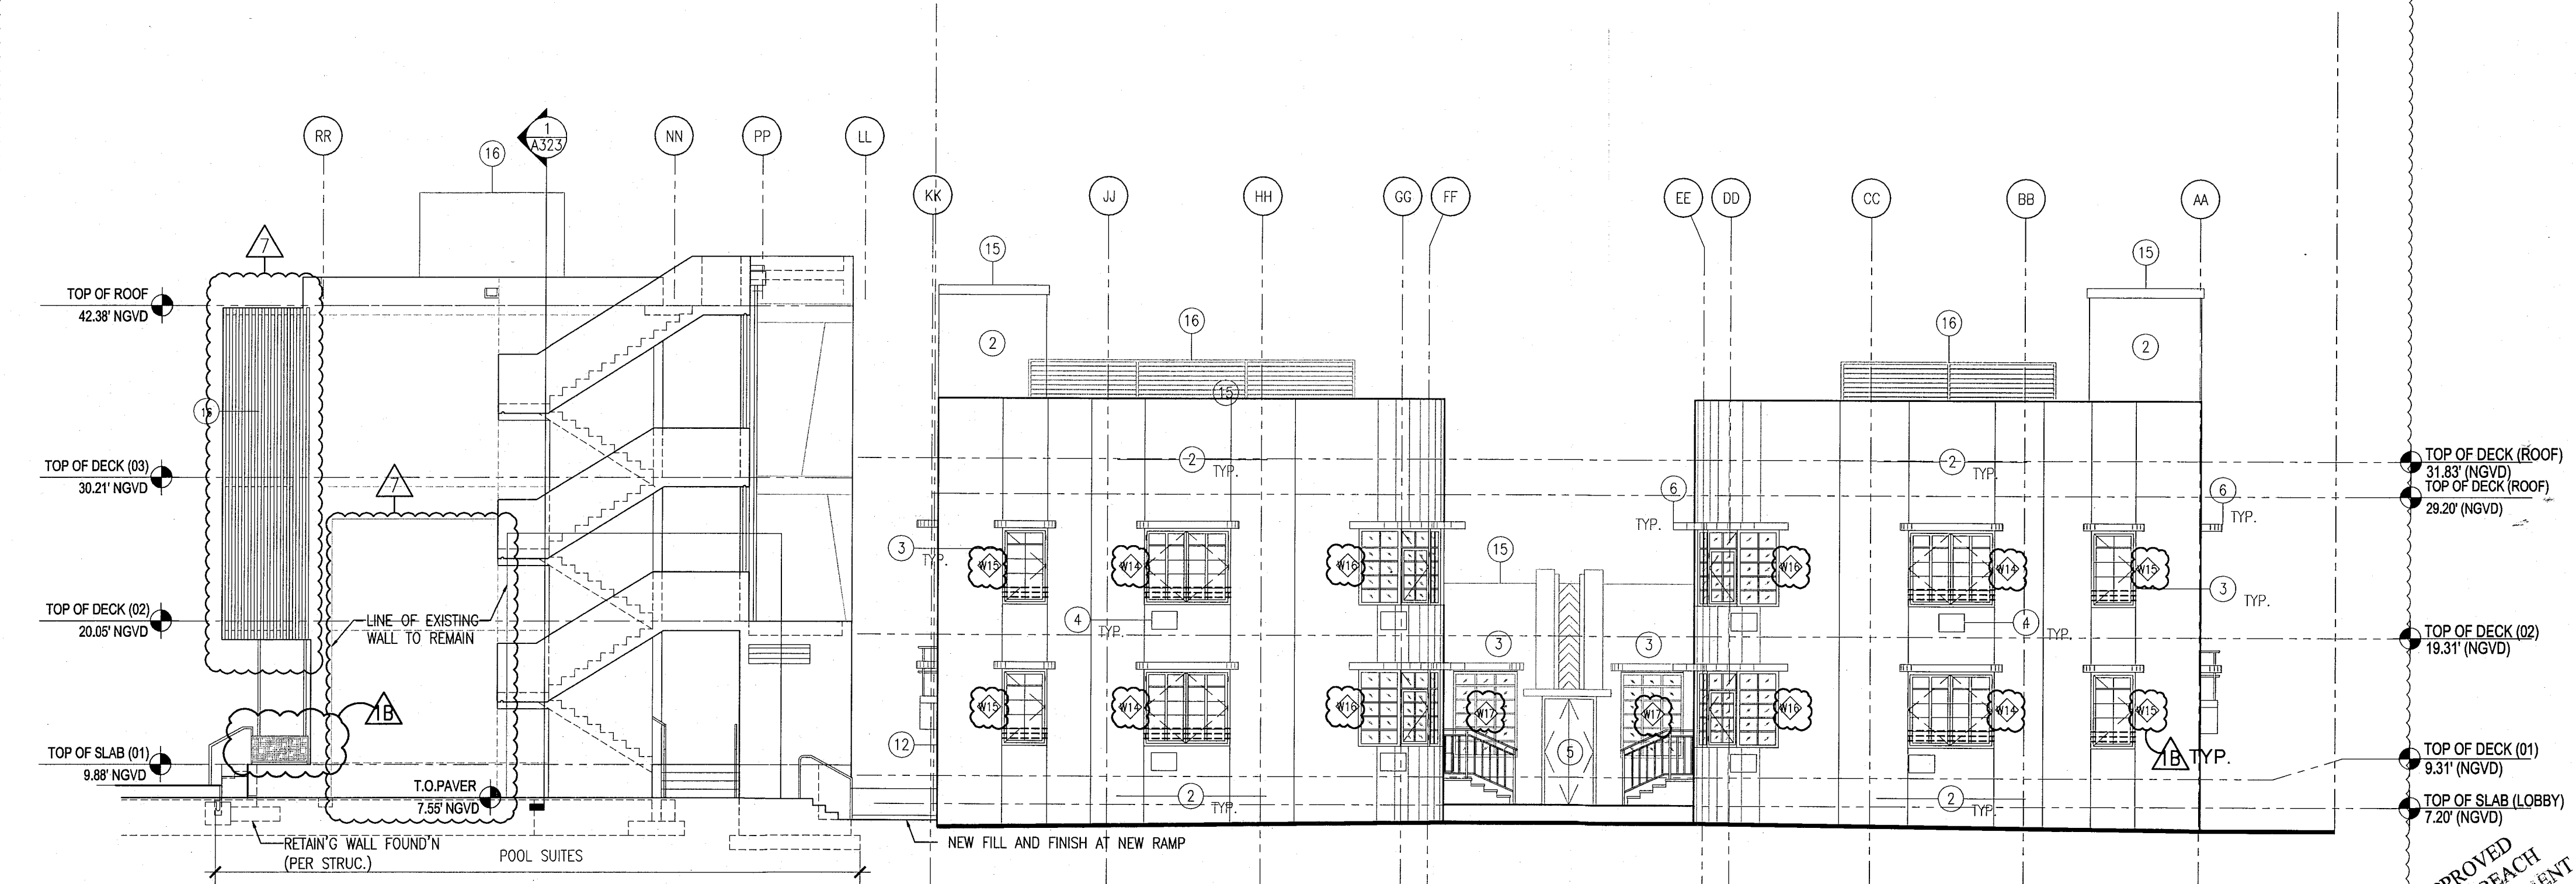

3 EXTERIOR WEST CAMPTON & POOL SUITES ELEVATION

SCALE: 1/8" = 1'-0"



APPROVED
MIAMI BEACH
FIRE DEPARTMENT

HADDON HALL 1500 COLLINS AVE MIAMI BEACH, FL

KEYPLAN N.T.S.

NOTES


1. REPLICATE ORIGINAL DECORATIVE SCREEN AT ALL PARAPET LOCATIONS (HADDON HALL BUILDING)
2. NEW PAINT AND RESTORED FINISH AT ALL EXISTING BUILDING EXTERIORS THROUGHOUT; NEW PAINT / FINISHES AT NEW BUILDING CONSTRUCTION
3. REPLACE ALL EXTERIOR WINDOWS/FRAMES WITH NEW (CODE COMPLIANT) WITH ALL ASSOCIATED FINISHES TO BE RESTORED (SEE FINISH SCHEDULE); ALL MUNTINS/MULLIONS AT HISTORIC BUILDINGS TO MATCH ORIGINAL HISTORIC PATTERNS; NEW HORIZONTAL WINDOW SAFETY BARS AT BUILDING INTERIORS AT OPERABLE WINDOW LOCATIONS (WHERE TOP OF SILL HEIGHT IS LESS THAN 42" AFF); NEW WINDOWS/FRAMES AT NEW BUILDING CONSTRUCTION
4. ALL A/C WINDOW BOX UNITS TO BE REMOVED AT ALL BUILDINGS; ASSOCIATED WALLS TO BE BLOCKED-UP, PATCHED AND PAINTED AND ALL ADJACENT FINISHES TO BE RESTORED (SEE FINISH SCHEDULE)
5. REPLACE ALL EXTERIOR DOORS/FRAMES WITH NEW (CODE COMPLIANT); NEW DOORS/FRAMES AT NEW BUILDING CONSTRUCTION
6. REMOVE EXISTING WATERPROOFING AND PATCH, PAINT, RESTORE BUILDING EYEBROWS; PROVIDE NEW WATERPROOFING MEMBRANE SYSTEM
7. RESTORE HISTORIC SIGNAGE
8. REPLICATE HISTORIC SIGNAGE
9. NEW ARCHITECTURAL SLATTED SCREEN; PAINTED ALUMIN. (RECTANGULAR TUBULAR SECTIONS)
10. NEW ARCHITECTURAL SLATTED RAILING SYSTEM; PAINTED ALUMIN. (RECTANGULAR TUBULAR SECTIONS)
11. CLIMBING PLANT / GREEN WALL LOCATION
12. NEW SAFETY RAILING AT EXTERIOR EXISTING RAMP, STAIR, AND NEW BUILDING CONSTRUCTION LOCATIONS
13. RESTORE EXISTING HISTORIC BALUSTRADE AT SELECT LOCATIONS
14. NEW CONCRETE PLANTERS
15. NEW ROOFING SYSTEM
16. NEW ROOFTOP EQUIPMENT LOUVER SCREEN / ENCLOSURE.
17. RESTORE AND REPLACE AS NEEDED/ REQUIRED NEON LIGHTING AT HADDON HALL HOTEL EASTER FACADE

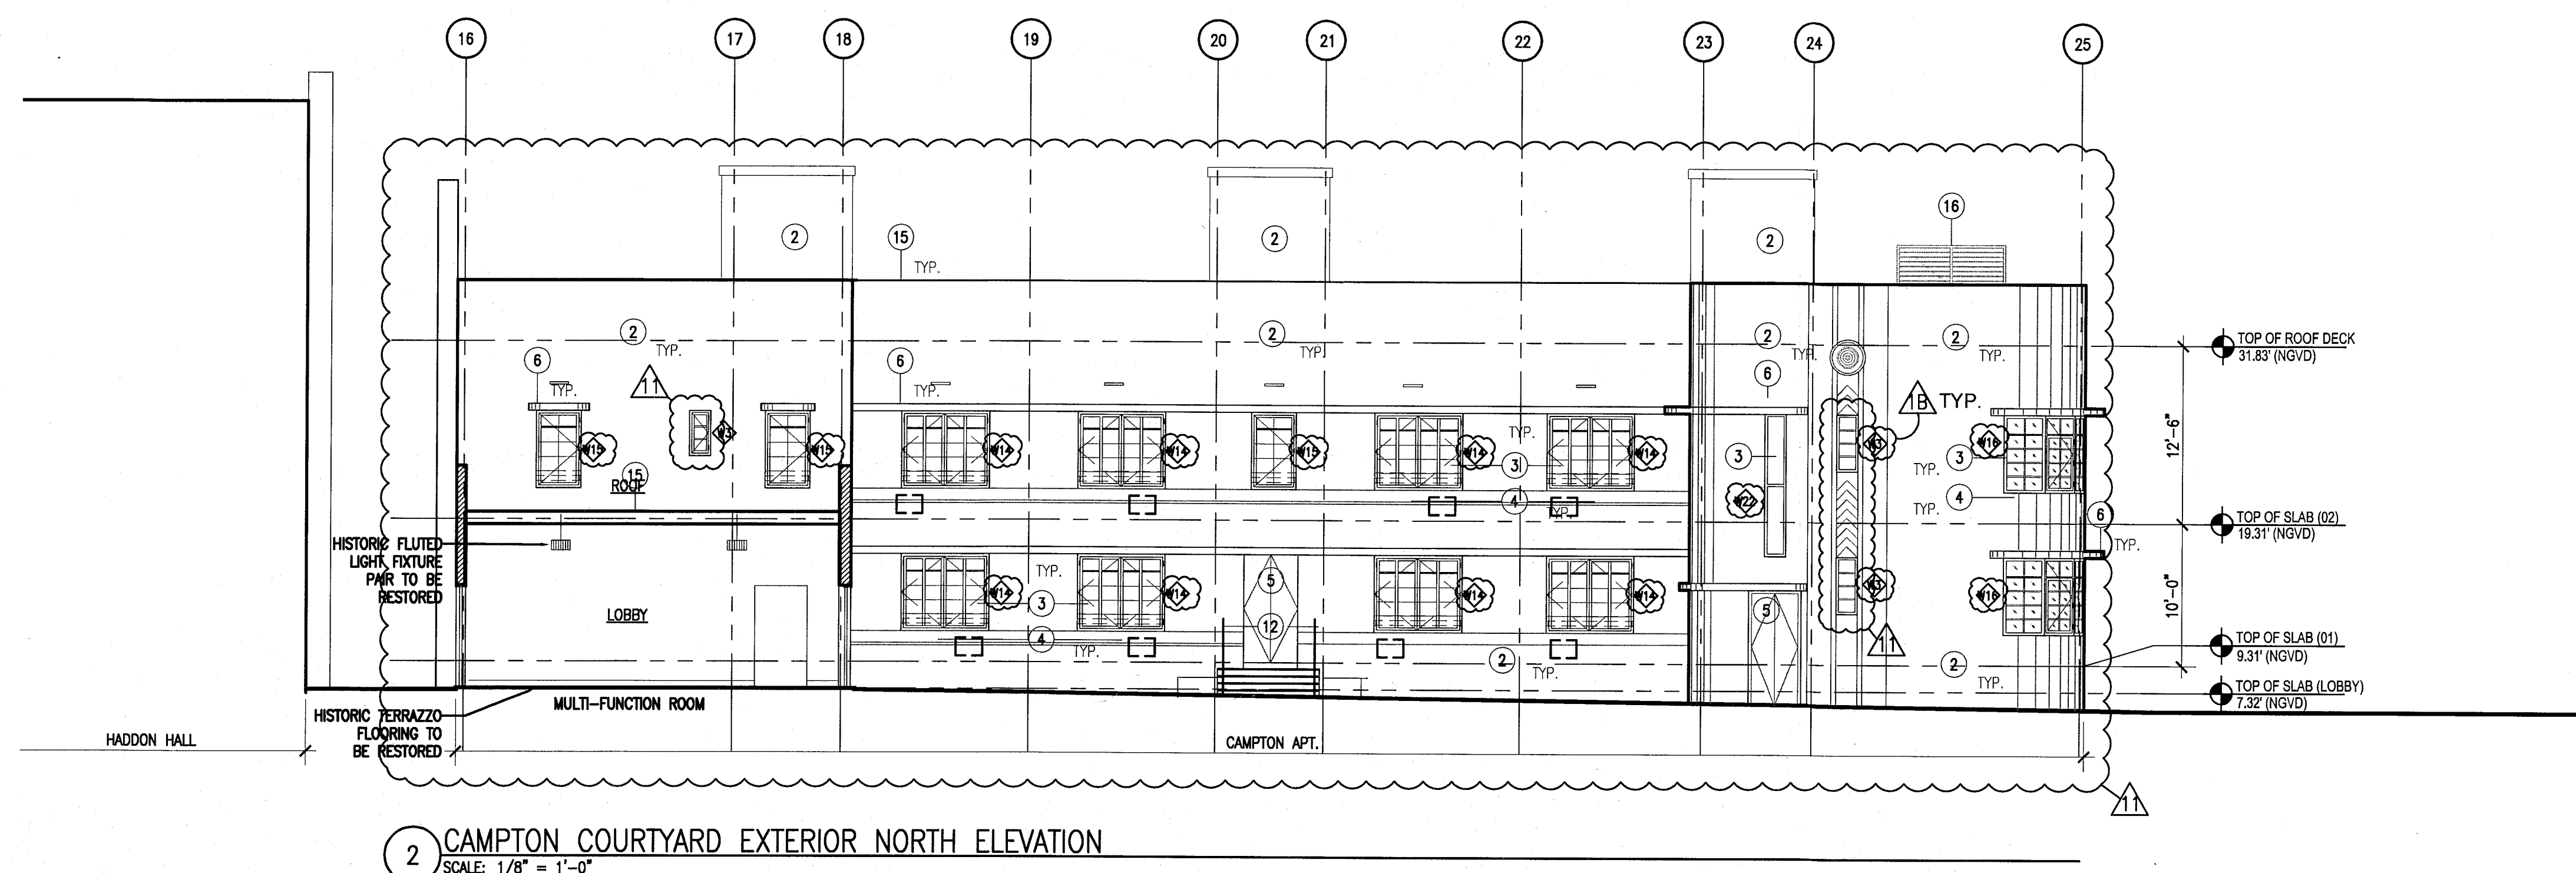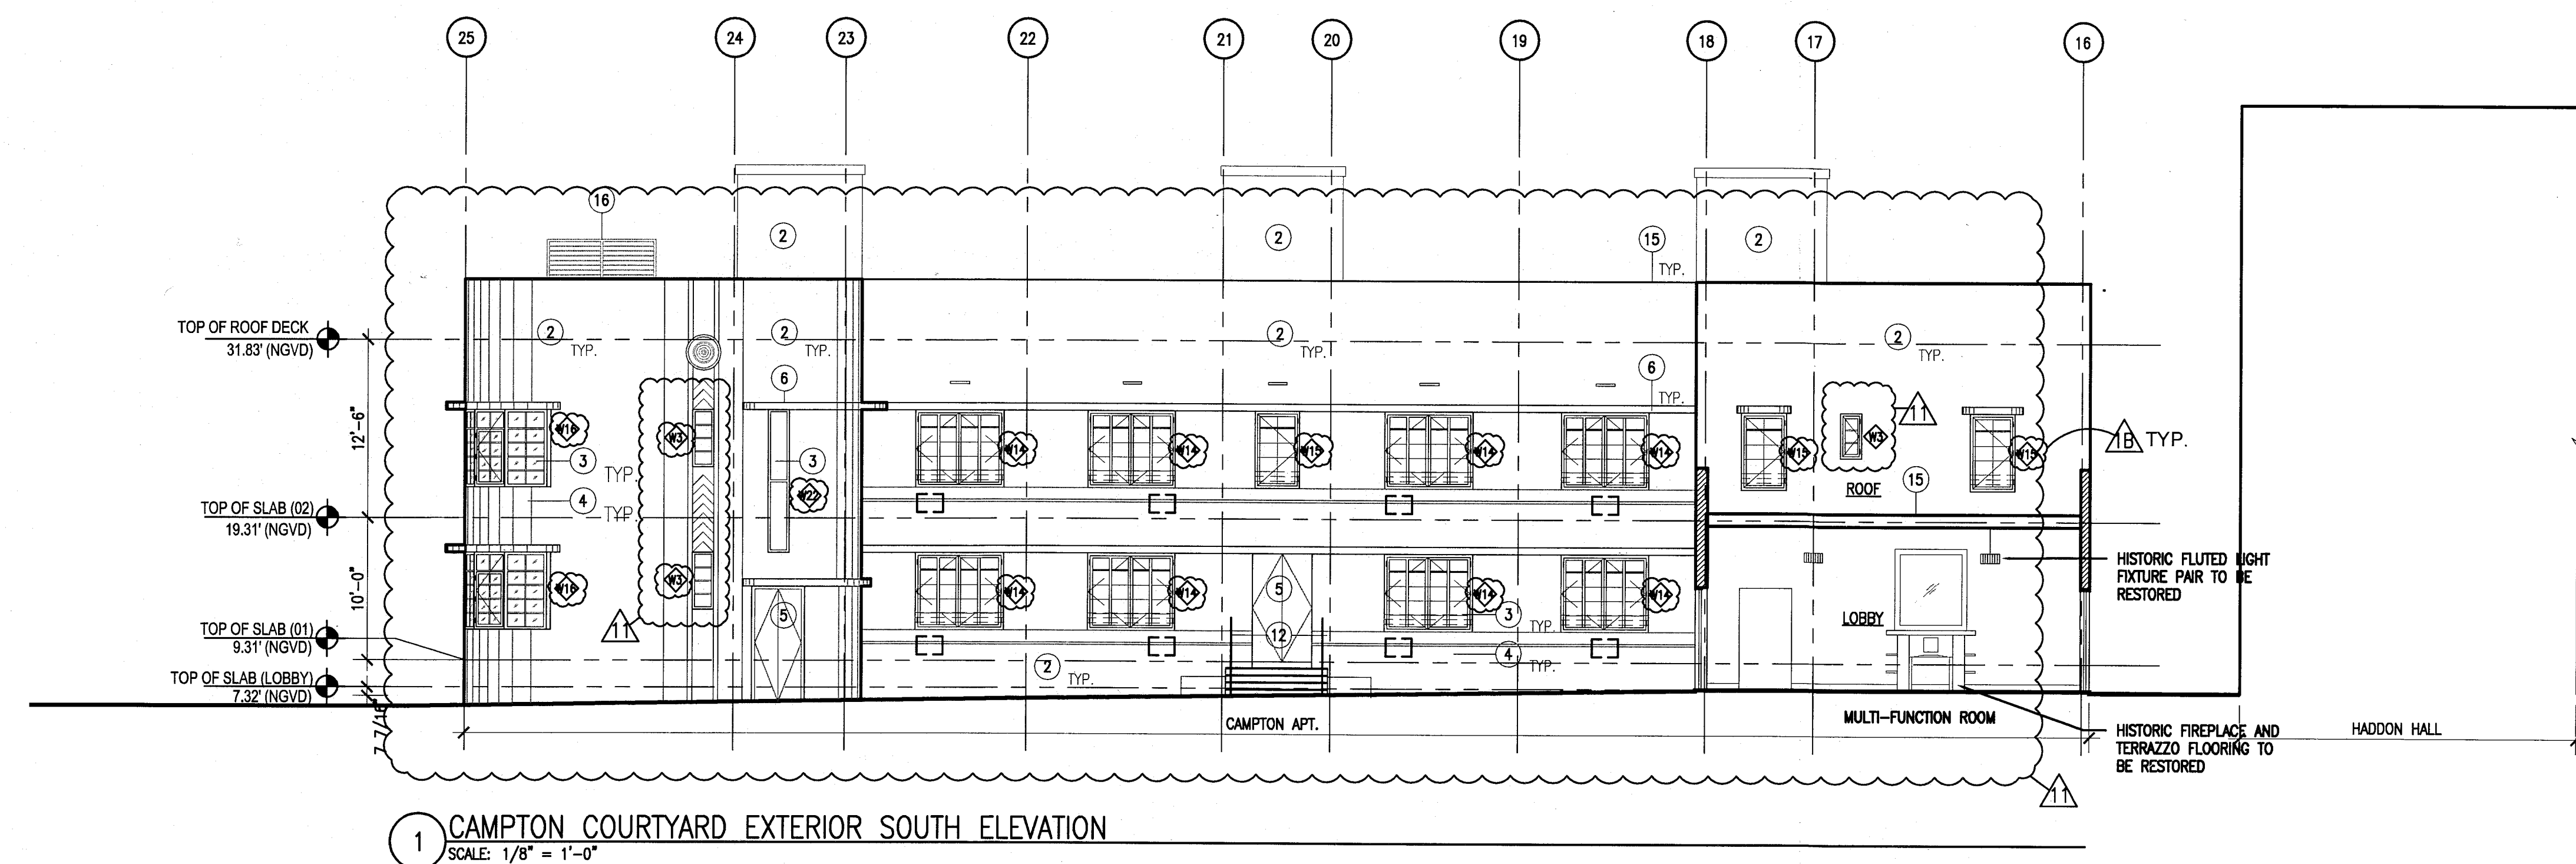

REVISIONS		
NO.	DESCRIPTION	ISSUE DATE
1B	DOOR-WINDOW COORD.	03-5-2014
1A	P&Z COMMENTS	07-14-2014

PRIVATE PROVIDER SERVICES, LLC Construction Plans, Specifications, Testing & Inspection			
BUILDING	REVIEWER INITIALS	DATE REVIEWED	
STRUCTURAL	EM	11-10-14	
MECHANICAL			
ELECTRICAL			
PLUMBING			
SITE CIVIL			

100% CONSTRUCTION DOCUMENT SET

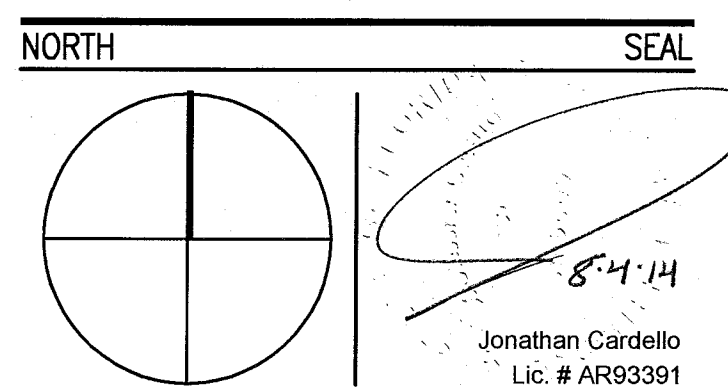

ADD Inc Architecture Interiors Planning

One Biscayne Tower
Suite 1670
Two South
Biscayne Boulevard
Miami, FL 33131
T. 305.482.8700
F. 305.482.8770
www.addinc.com
Lic. # AA26001507
Boston Miami

JOB NUMBER: 13036.00
CHECKED BY:
ISSUE DATE: FEBRUARY 18, 2014
SCALE: 1/8" = 1'-0"

SHEET TITLE

EXTERIOR ELEVATION
CAMPTON & HADDON
COURTYARD

SHEET NUMBER

A304

COPYRIGHT ADD INC 2011

APPROVED
MIAMI BEACH
FIRE DEPARTMENT


HADDON HALL
1500 COLLINS AVE
MIAMI BEACH, FL

KEYPLAN N.T.S.

REVISIONS		
NO.	DESCRIPTION	ISSUE DATE
1	FIRE & MTCI PERMIT COMMENTS	08-21-2014

MTCI PRIVATE PROVIDER SERVICES, LLC			
REVIEWER INITIALS			
BUILDING	REVIEWER	DATE	REVIEWED
STRUCTURAL	Em	11-2-14	
Mechanical			
Electrical			
Plumbing			
Site Civil			

100% CONSTRUCTION
DOCUMENT SET

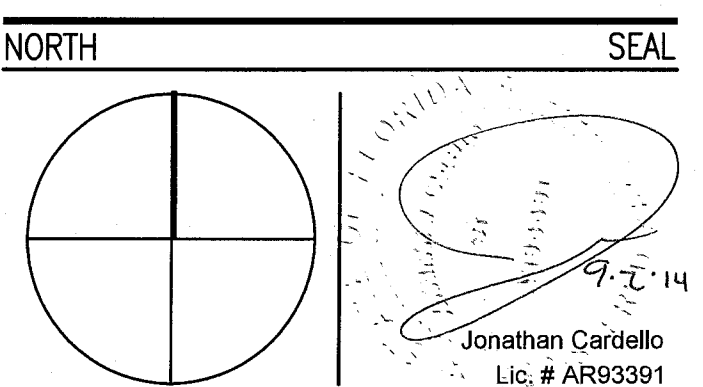

ADD Inc Architecture Interiors Planning

One Biscayne Tower
Suite 1670
Two South
Biscayne Boulevard
Miami, FL 33131
T. 305.482.8700
F. 305.482.8770
www.addinc.com
Lic. # AA26001507

JOB NUMBER: 13036.00
CHECKED BY:
ISSUE DATE: FEBRUARY 18, 2014
SCALE: 1/8" = 1'-0"

SHEET TITLE


BUILDING
SECTIONS

SHEET NUMBER


A321

COPYRIGHT ADD INC 2011

APPROVED
MIAMI BEACH
FIRE DEPARTMENT

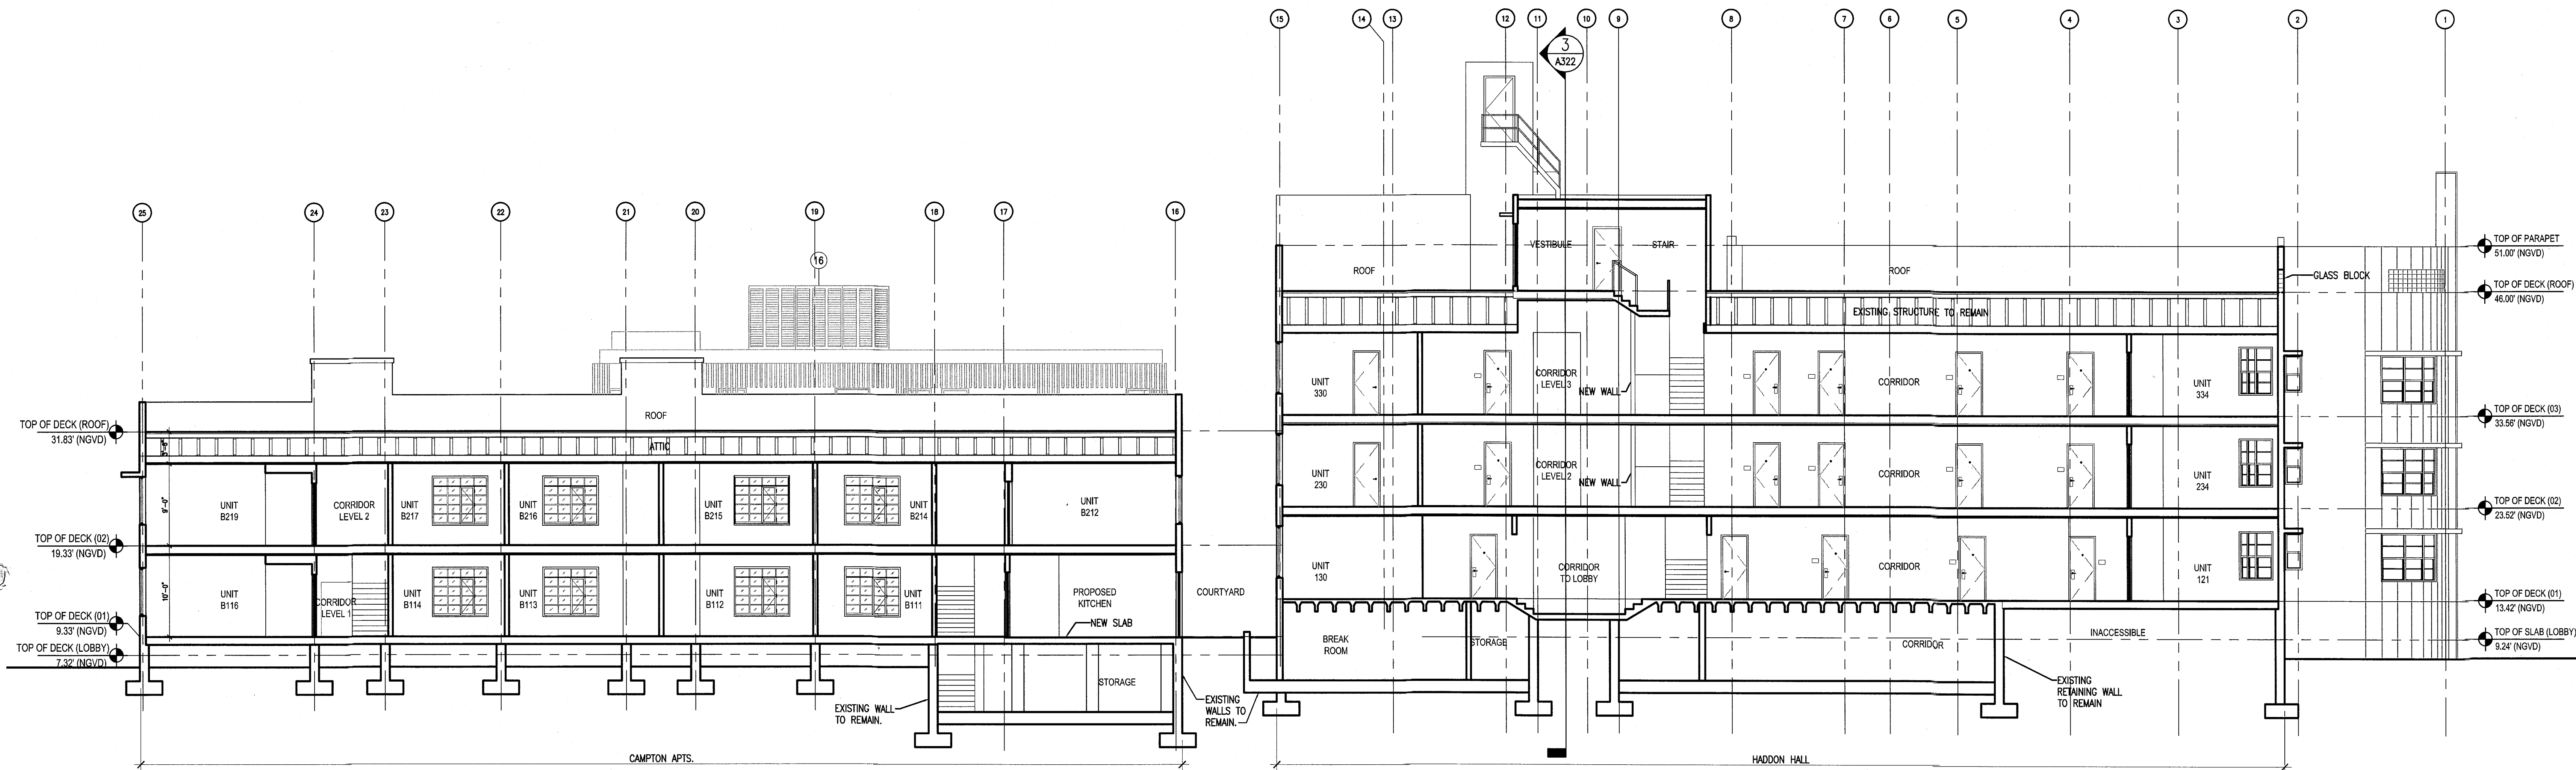

1 BUILDING SECTION - LOOKING NORTH
SCALE: 1/8" = 1'-0"

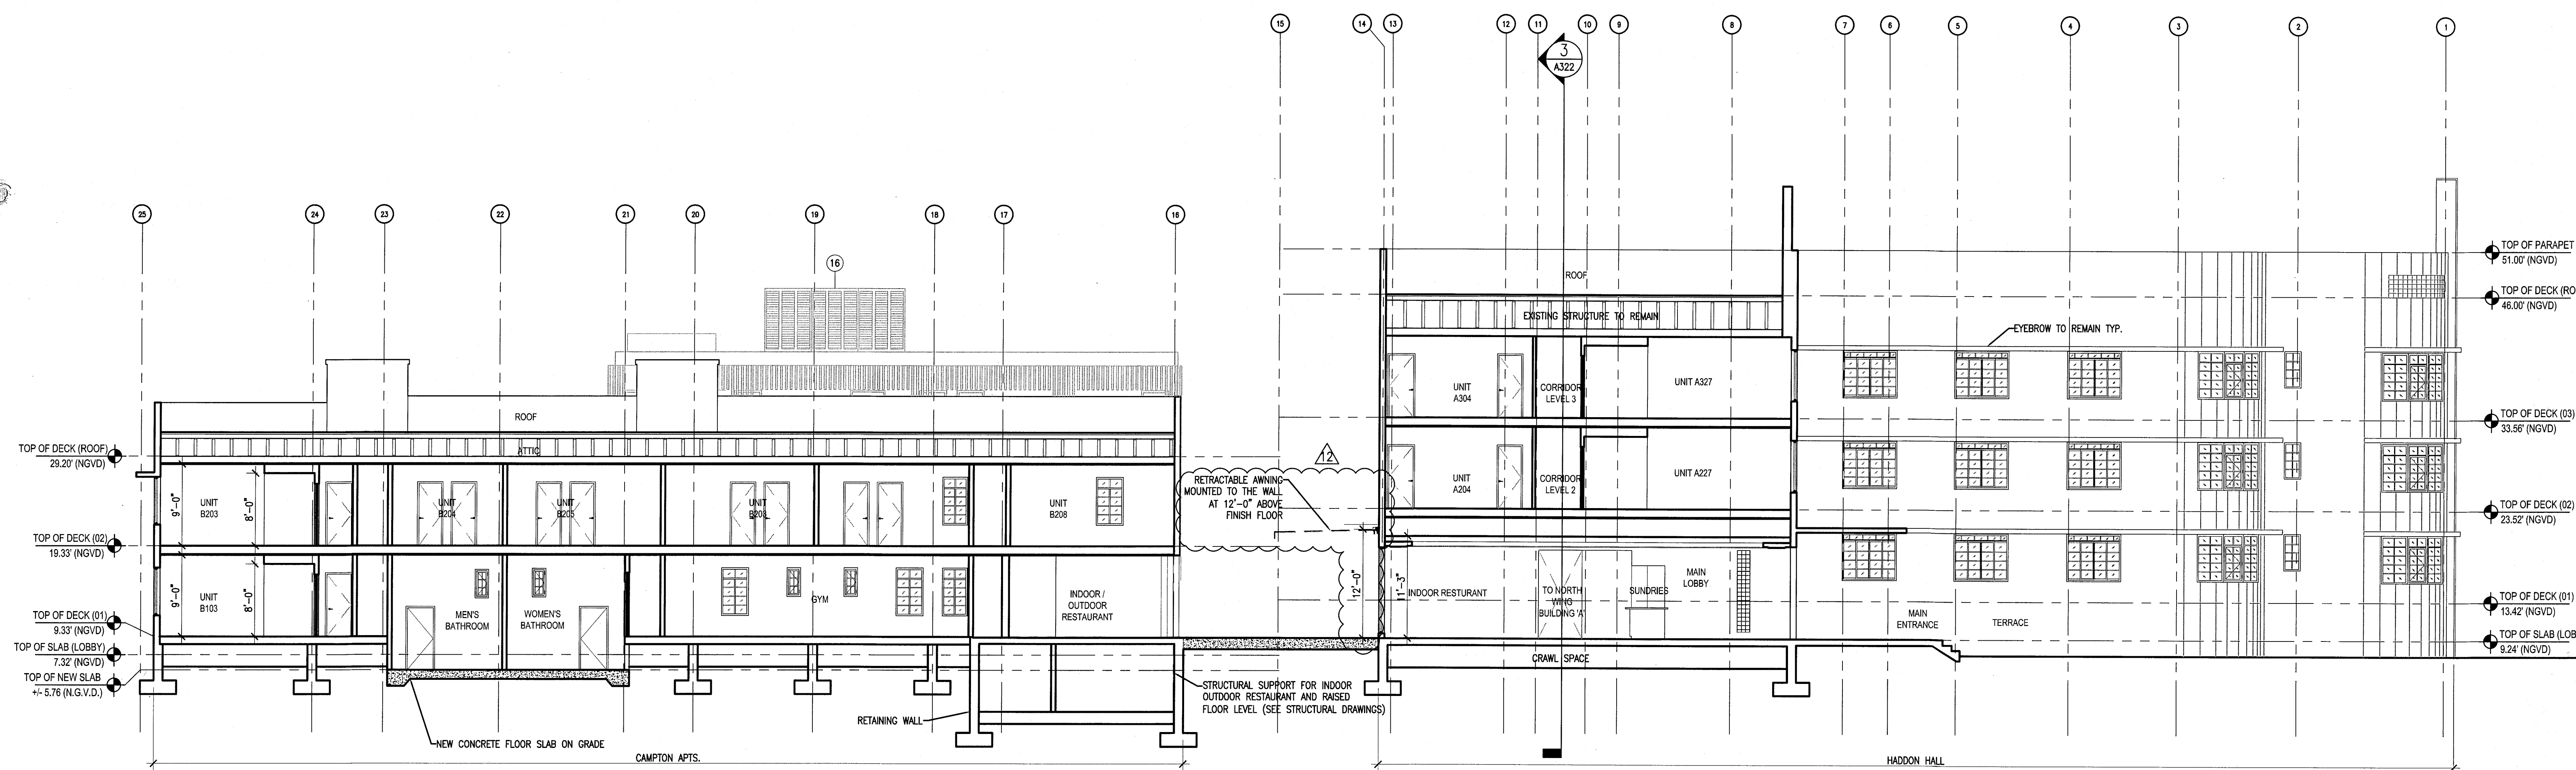

2 BUILDING SECTION - LOOKING NORTH
SCALE: 1/8" = 1'-0"


HADDON HALL
1500 COLLINS AVE
MIAMI BEACH, FL

KEYPLAN N.T.S.

REVISIONS		
NO.	DESCRIPTION	ISSUE DATE

PRIVATE PROVIDER SERVICES, LLC			
Construction Permit Review, Inspection, Testing & Consulting			
	REVIEWER INITIALS	DATE	REVIEWED
BUILDING	FM	1/24/14	
MECHANICAL			
ELECTRICAL			
PLUMBING			
SITE CIVIL			

PERMIT SET

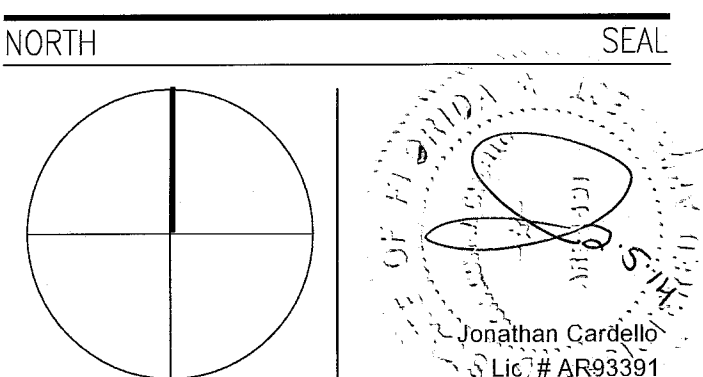

ADD Inc Architecture Interiors Planning

One Biscayne Tower
Suite 1670
Two South
Biscayne Boulevard
Miami, FL 33131
T. 305.482.8700
F. 305.482.8770
www.addinc.com
Lic. # AA26001507

Boston Miami

JOB NUMBER: 13036.00

CHECKED BY:

ISSUE DATE: JANUARY 24, 2014

SCALE: 1/8" = 1'-0"

SHEET TITLE


BUILDING
SECTIONS

SHEET NUMBER

A322

COPYRIGHT ADD INC 2011

APPROVED
MIAMI BEACH
FIRE DEPARTMENT

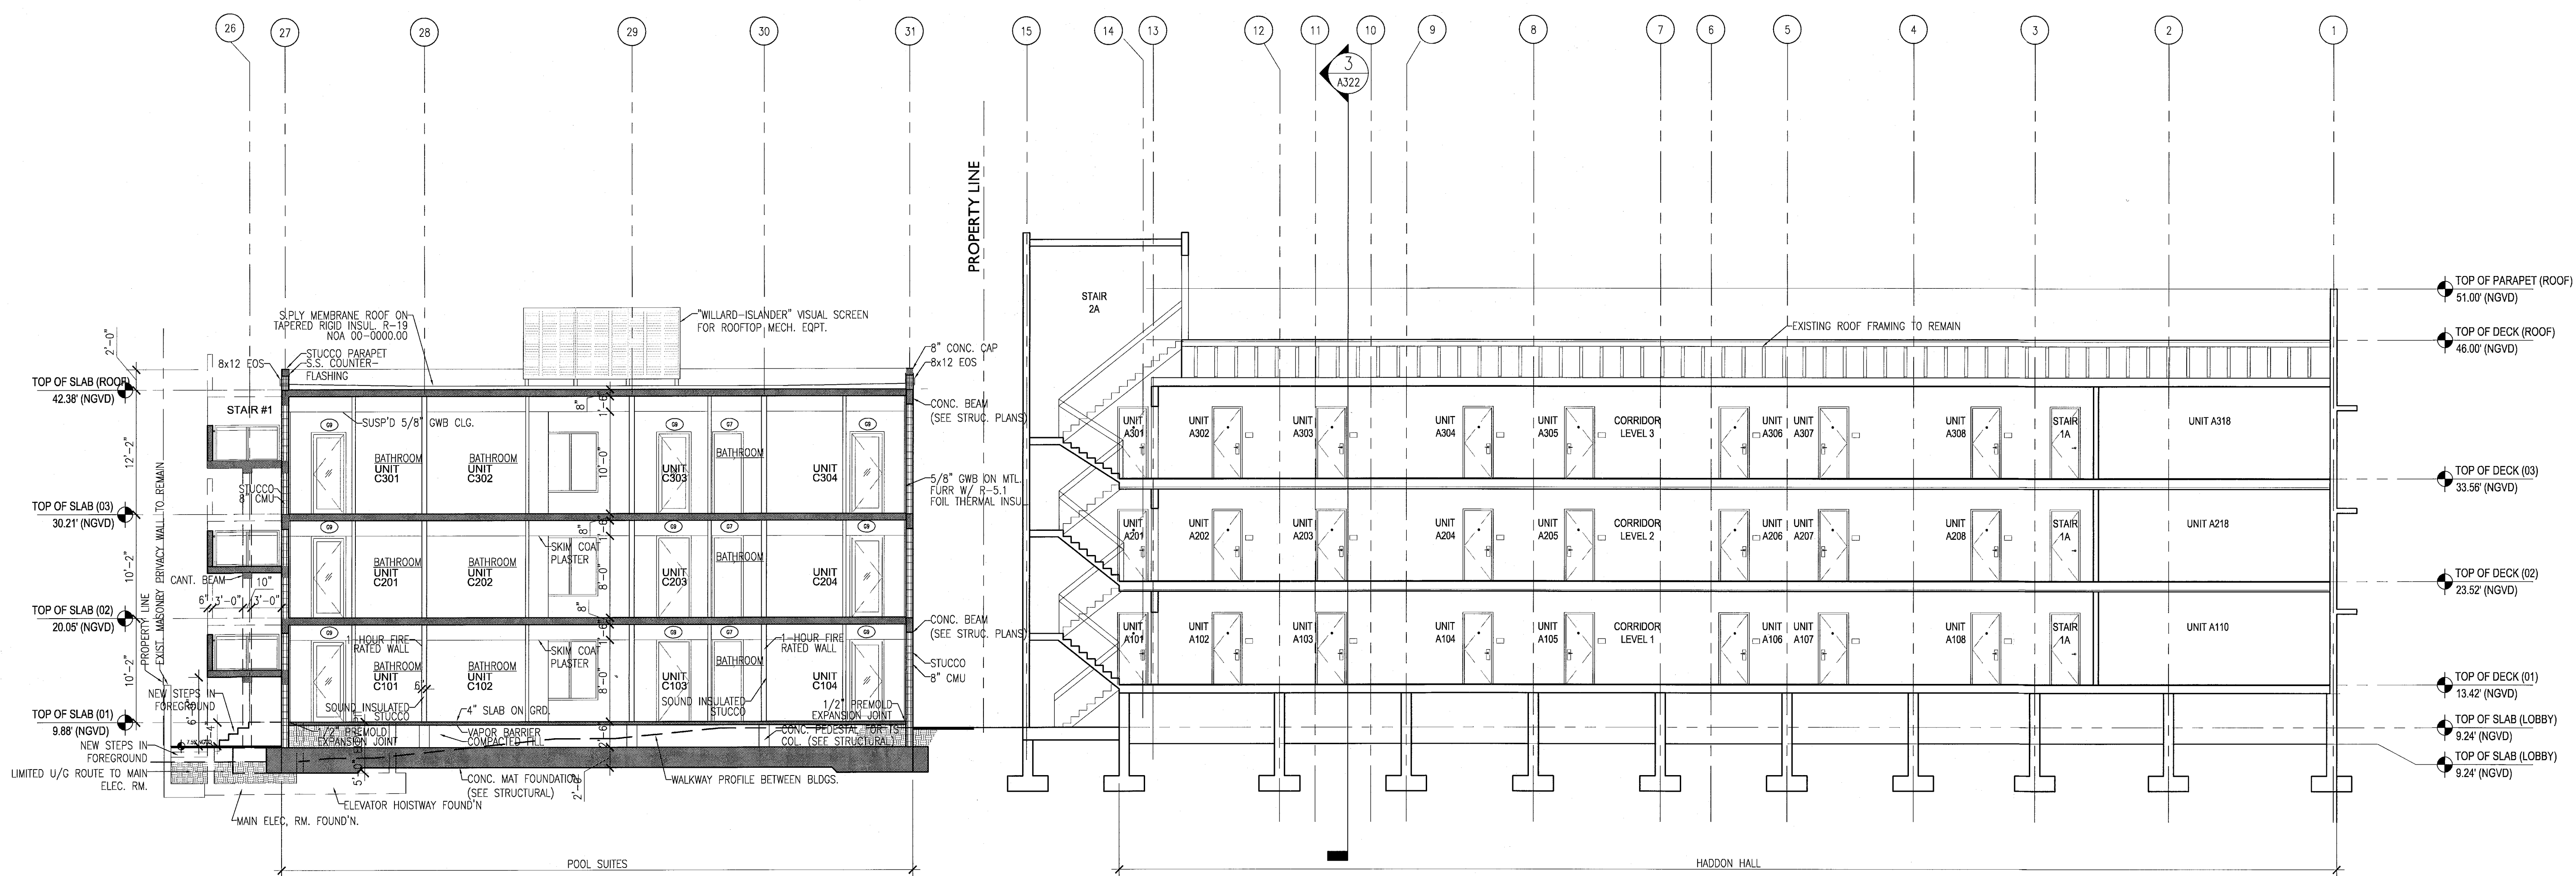


1 BUILDING SECTION
SCALE: 1/8" = 1'-0"

HADDON HALL 1500 COLLINS AVE MIAMI BEACH, FL

KEYPLAN N.T.S.

REVISIONS		
NO.	DESCRIPTION	ISSUE DATE
1	P&Z COMMENTS	07-14-2014

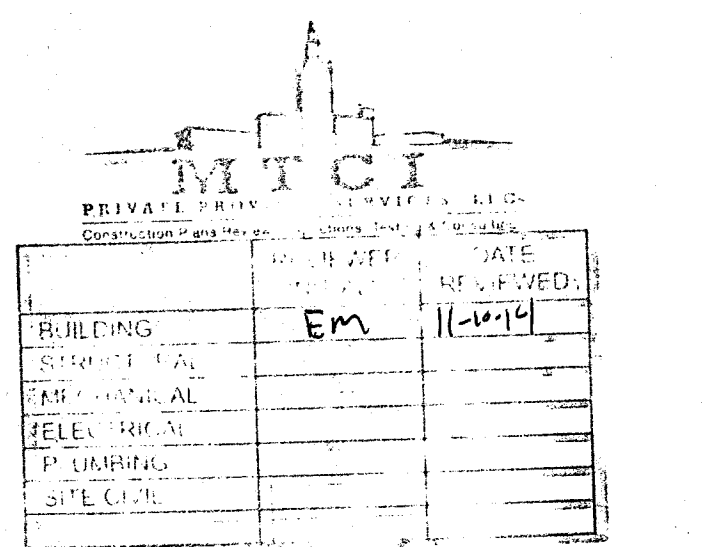

100% CONSTRUCTION DOCUMENT SET

SEAL
Jonathan Cardello
Lic. # AR83391

ADD Inc Architecture Interiors Planning

One Biscayne Tower
Suite 1670
Two South
Biscayne Boulevard
Miami, FL 33131
T: 305.482.8700
F: 305.482.8770
www.addinc.com
Lic. # AA26001507

JOB NUMBER: 13036.00
CHECKED BY:
ISSUE DATE: FEBRUARY 18, 2014
SCALE: 1/4" = 1'-0"


SHEET TITLE

BUILDING "C" SECTIONS


SHEET NUMBER

A323

COPYRIGHT ADD INC 2011

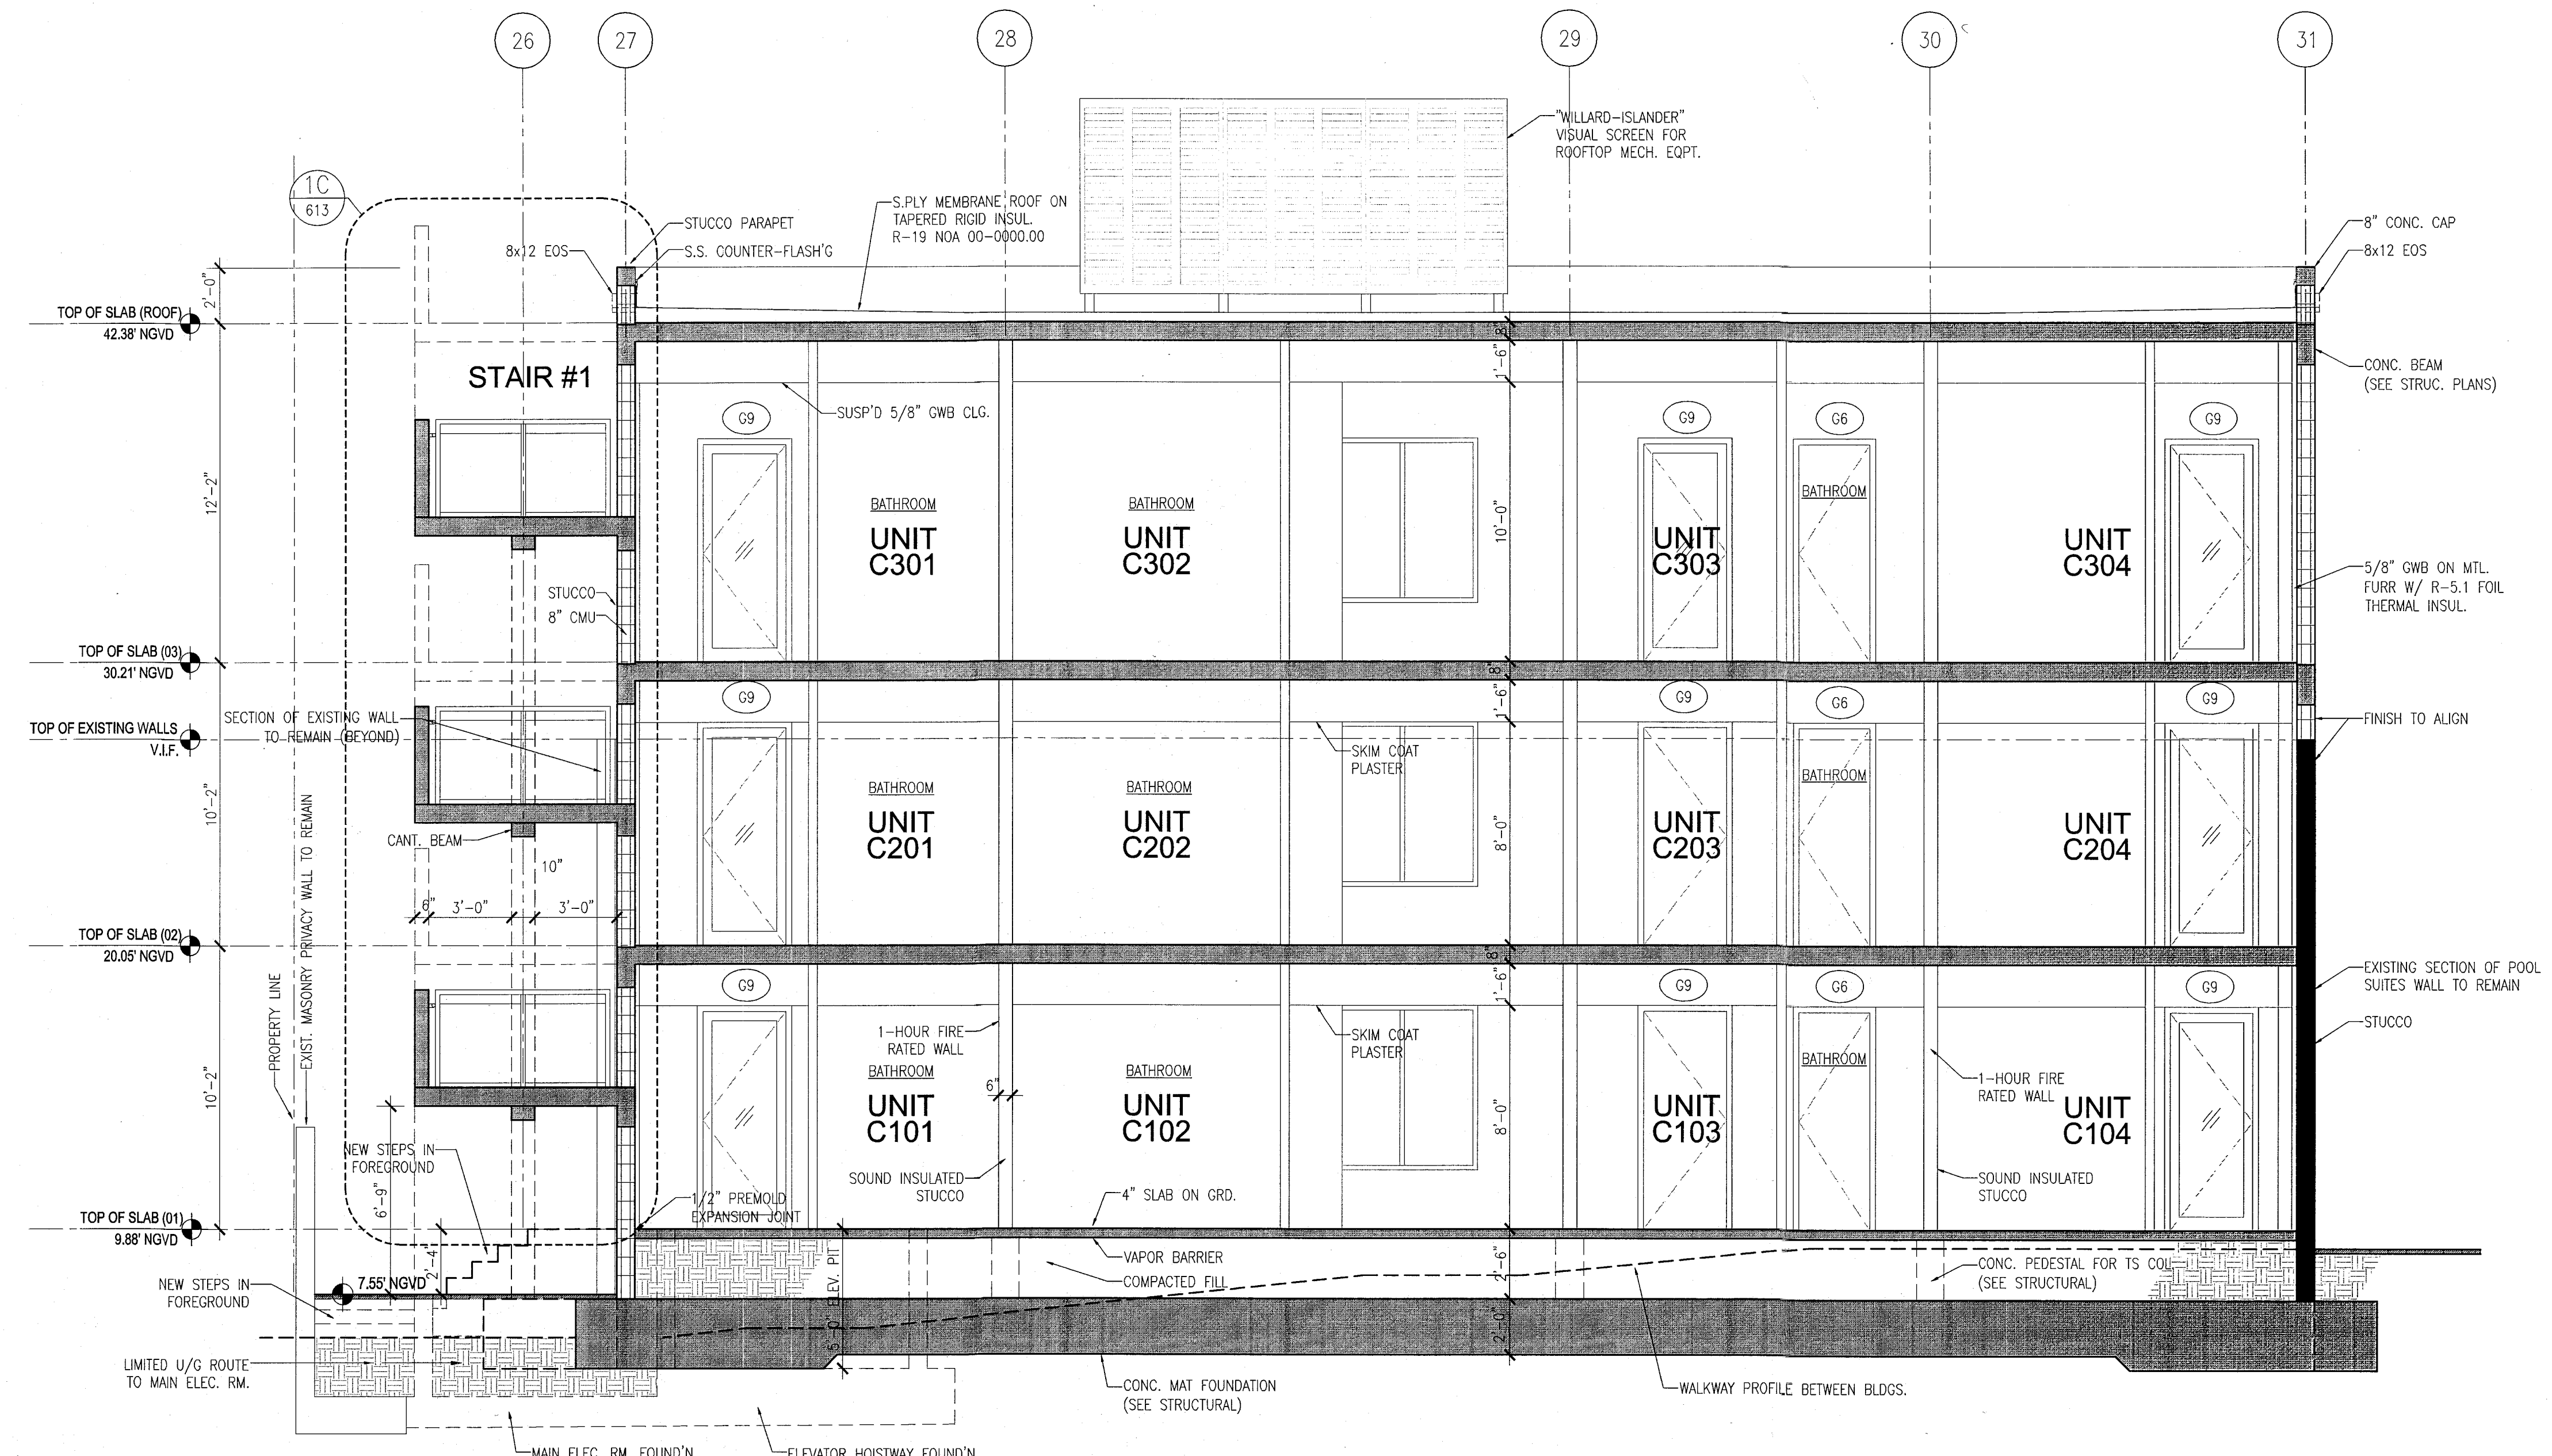

1 BUILDING LONGITUDINAL SECTION - POOL SUITES
SCALE: 1/4" = 1'-0"

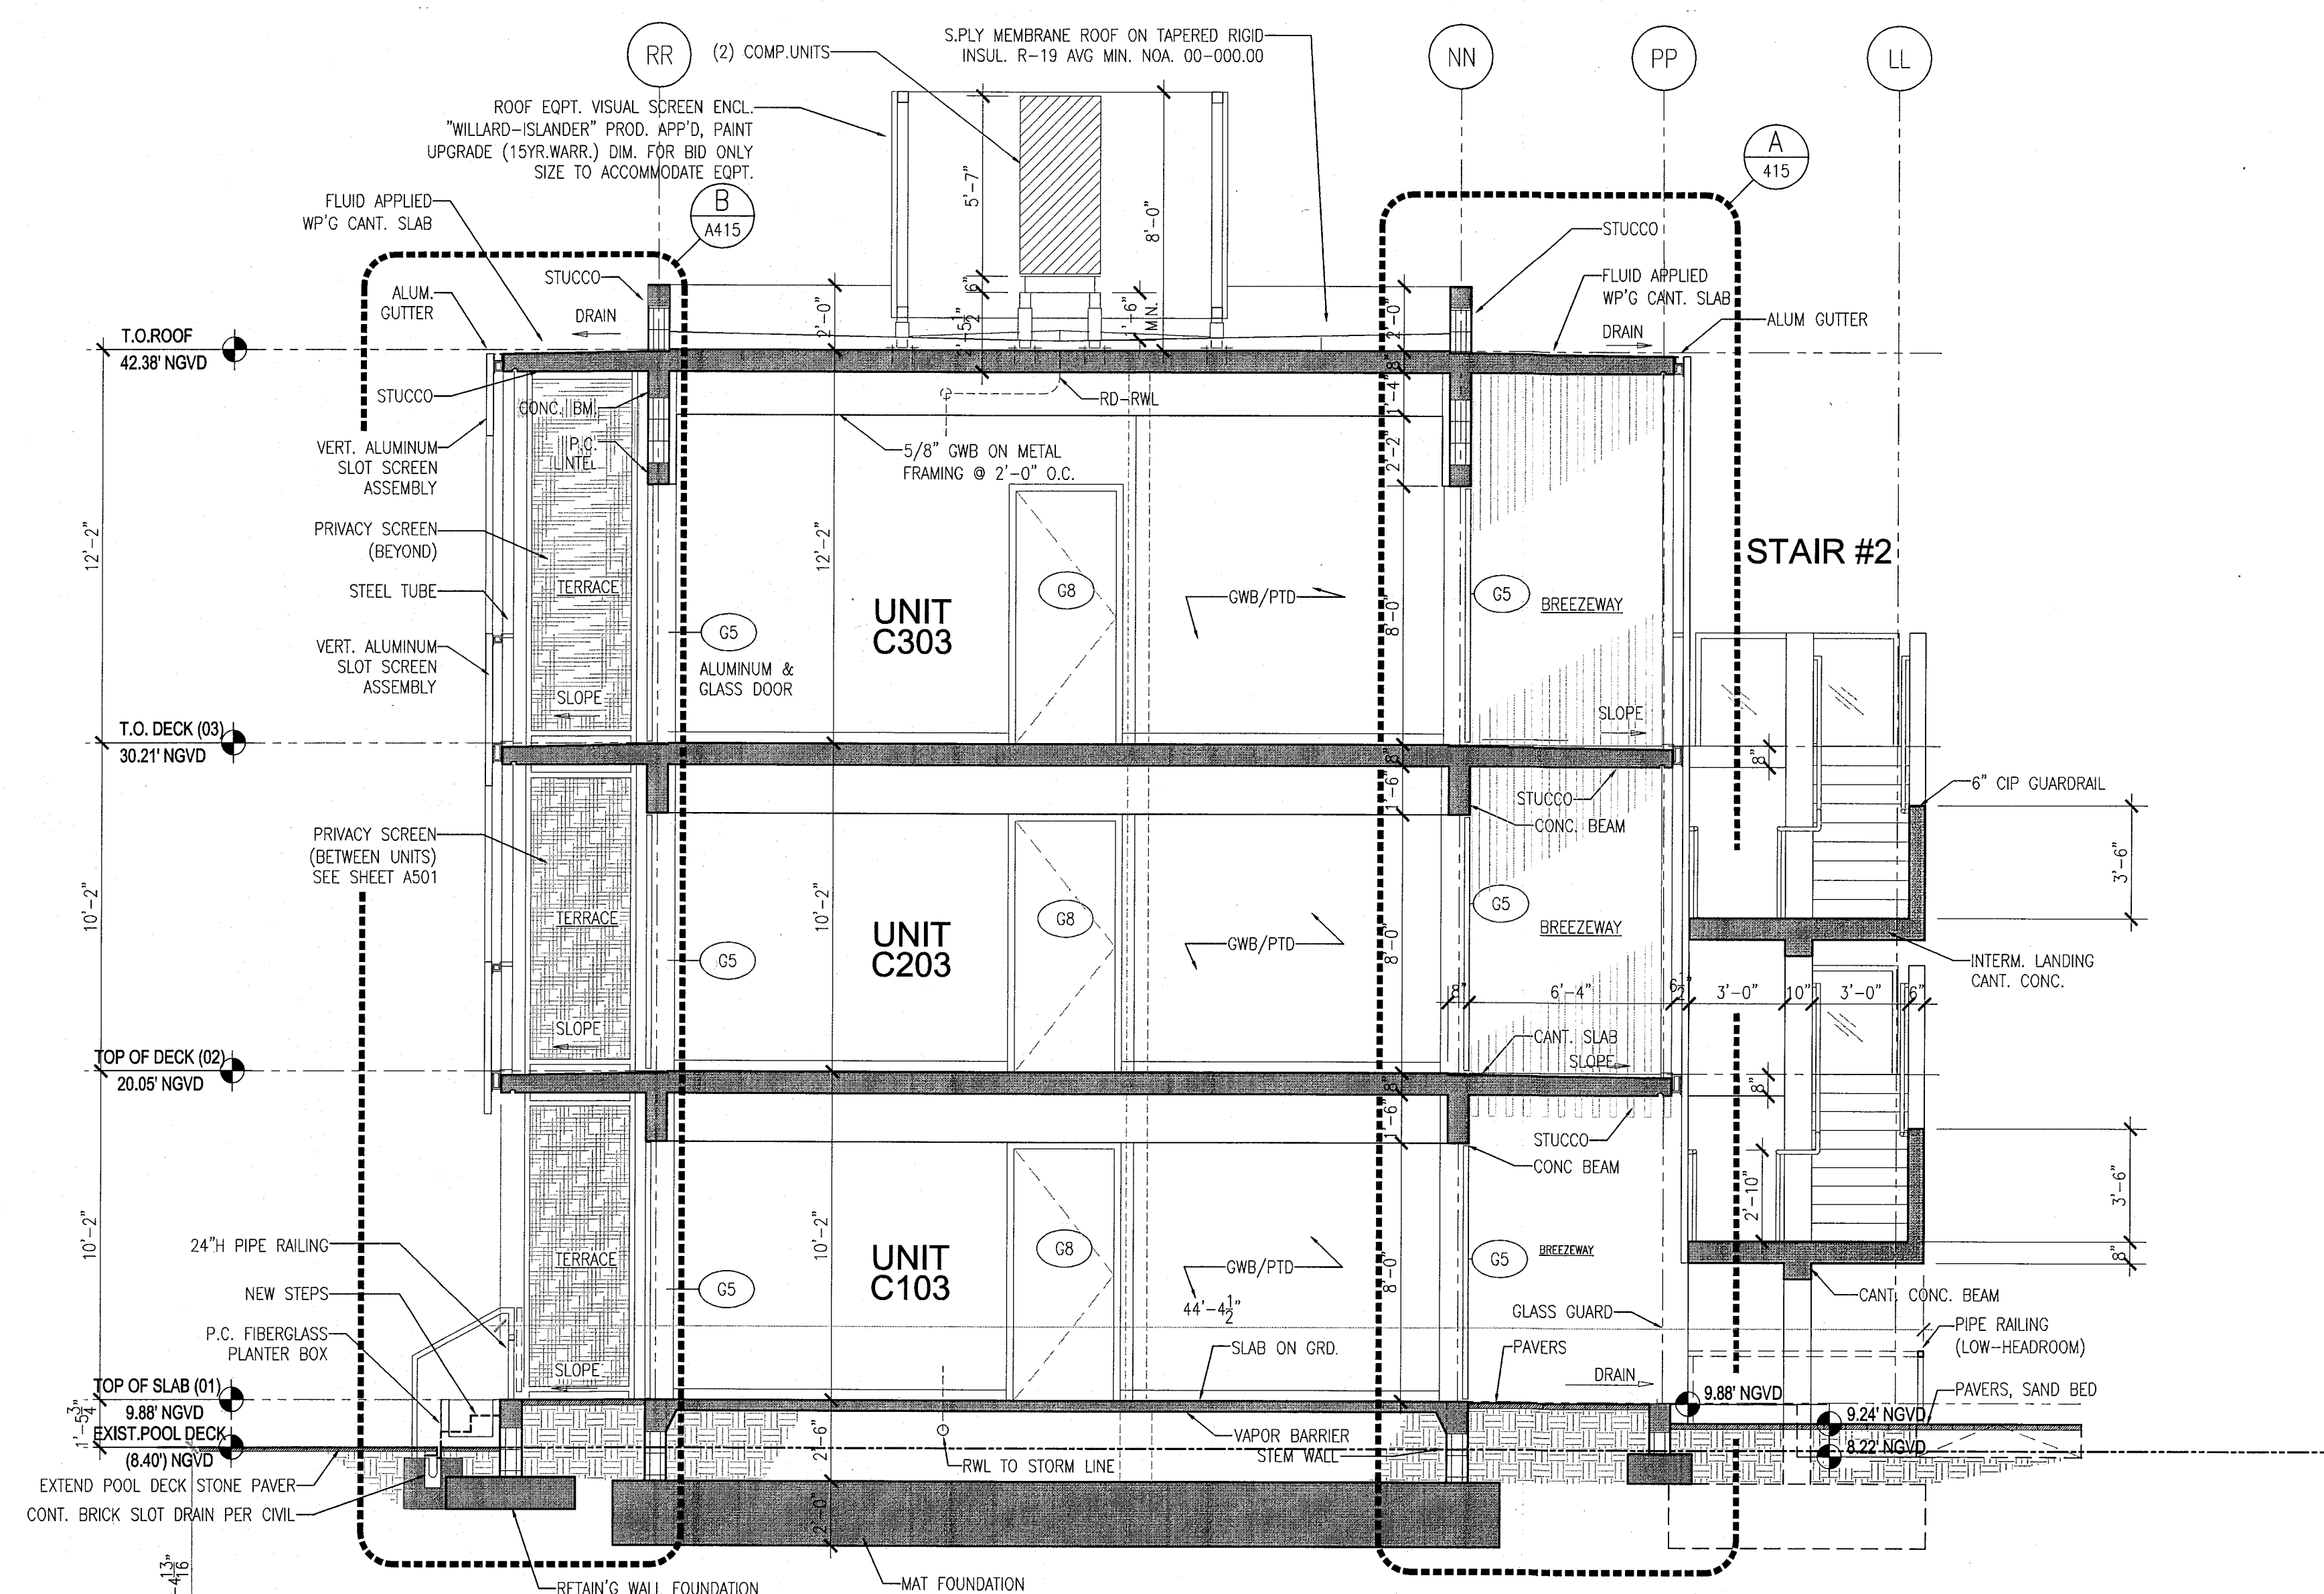

2 BUILDING CROSS-SECTION - POOL SUITES
SCALE: 1/4" = 1'-0"

APPROVED
MIAMI BEACH
FIRE DEPARTMENT

HADDON HALL 1500 COLLINS AVE MIAMI BEACH, FL

KEYPLAN N.T.S.

REVISIONS		
NO.	DESCRIPTION	ISSUE DATE
1	PROGRESS TO 100% CD	02-18-2014

M.T.C.I. PRIVATE PROVIDER SERVICES, LLC			
REVIEWER INITIALS DATE			
BUILDING	FM	11/12/14	
STRUCTURAL			
MECHANICAL			
ELECTRICAL			
PLUMBING			
SITE CIVIL			

100% CONSTRUCTION DOCUMENT SET

SEAL
S. J. J. J.
Jonathan Cardello
Lic. # AR9391

ADD Inc Architecture Interiors Planning

One Biscayne Tower
Suite 1670
Two South
Biscayne Boulevard
Miami, FL 33131
T. 305.482.8700
F. 305.482.8710
www.addinc.com
Lic. # AA26001507

JOB NUMBER: 13036.00
CHECKED BY:
ISSUE DATE: FEBRUARY 18, 2014
SCALE: AS NOTED

SHEET TITLE




TYPICAL EXTERIOR WALL SECTIONS

SHEET NUMBER

A411

COPYRIGHT ADD INC 2011


APPROVED
MIAMI BEACH
FIRE DEPARTMENT

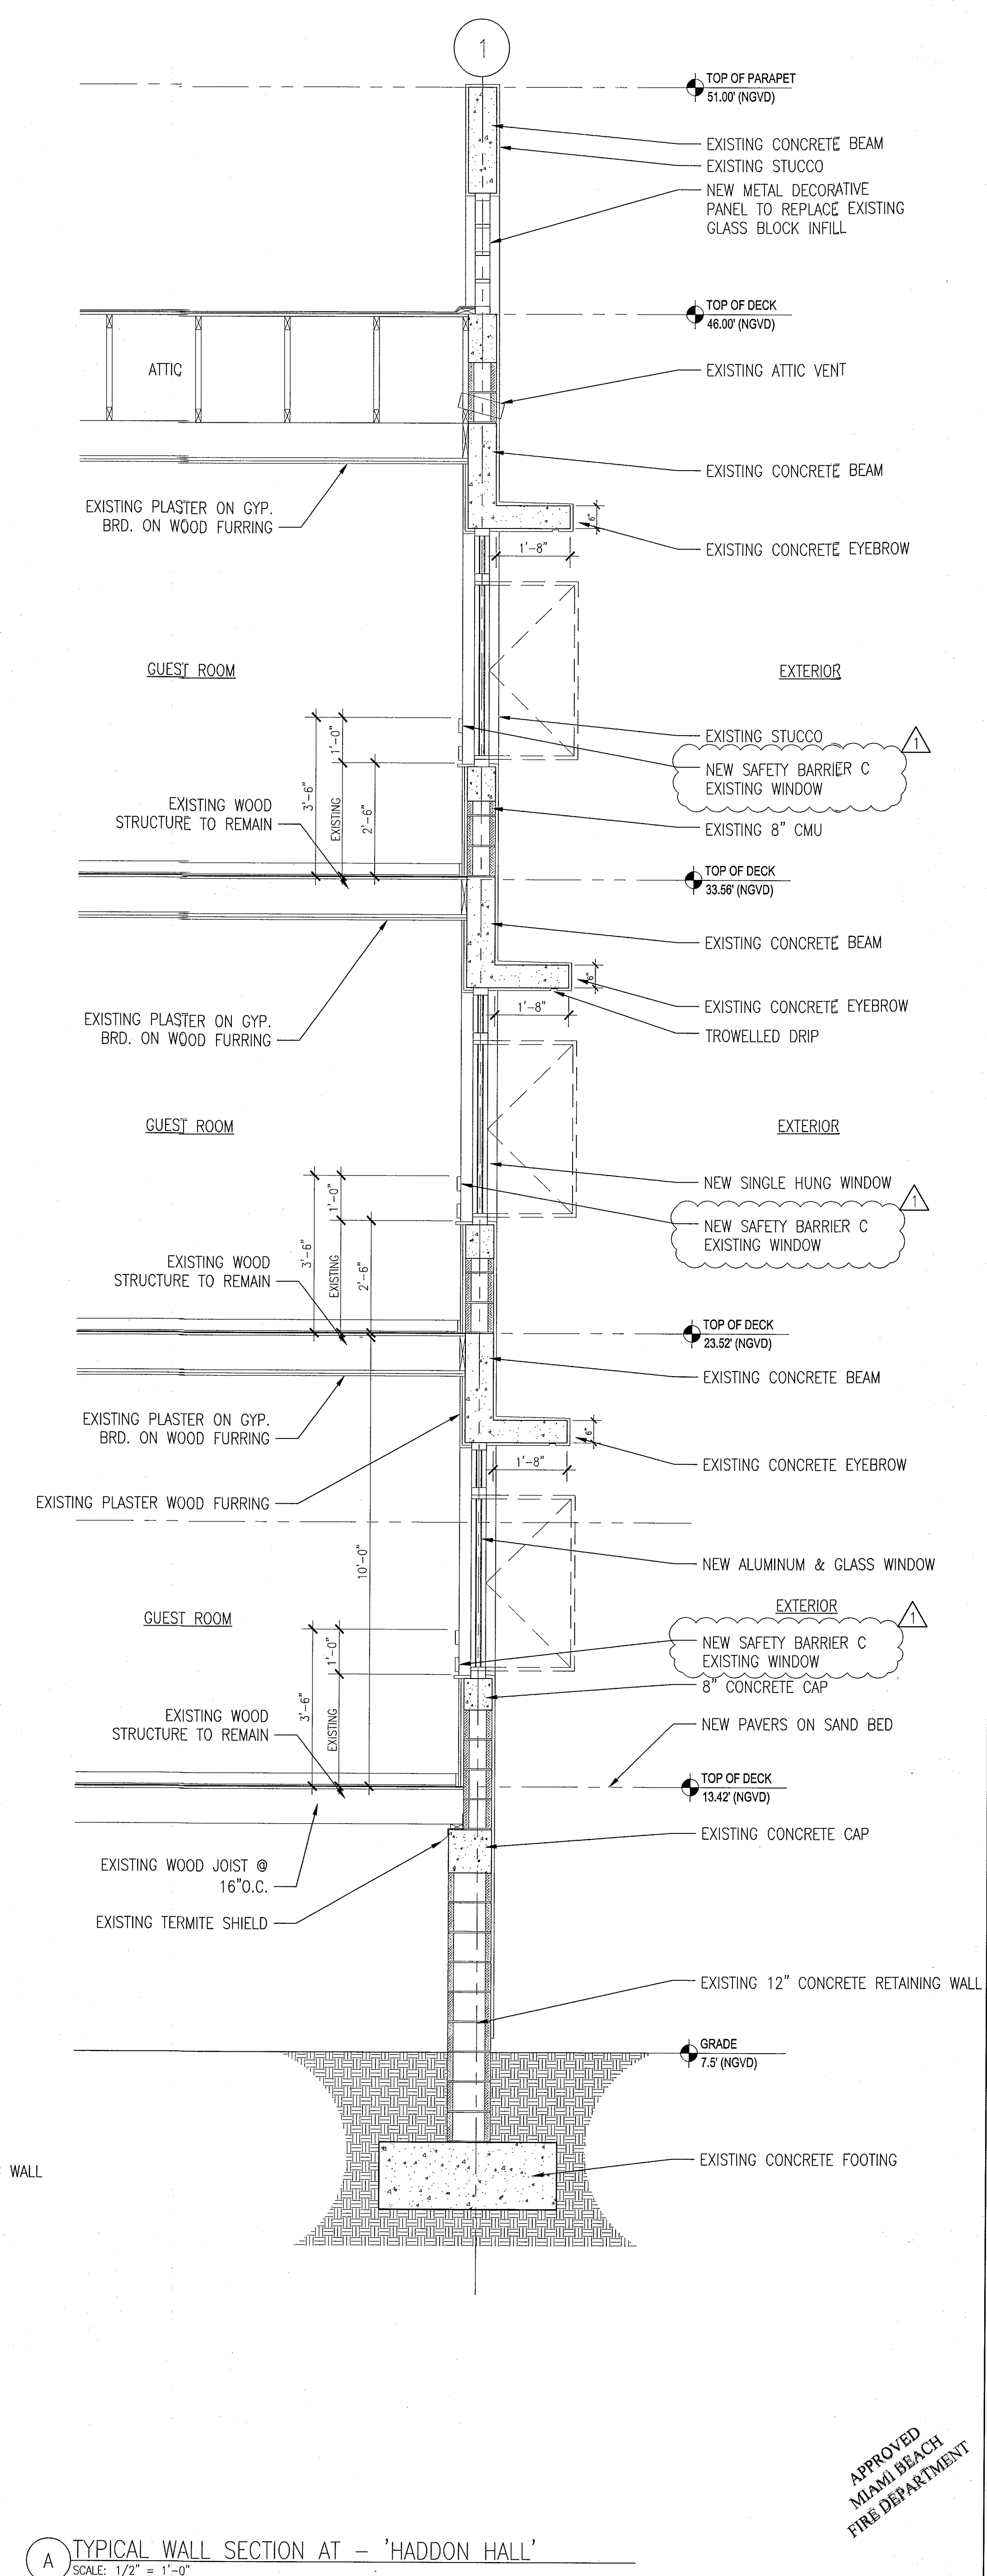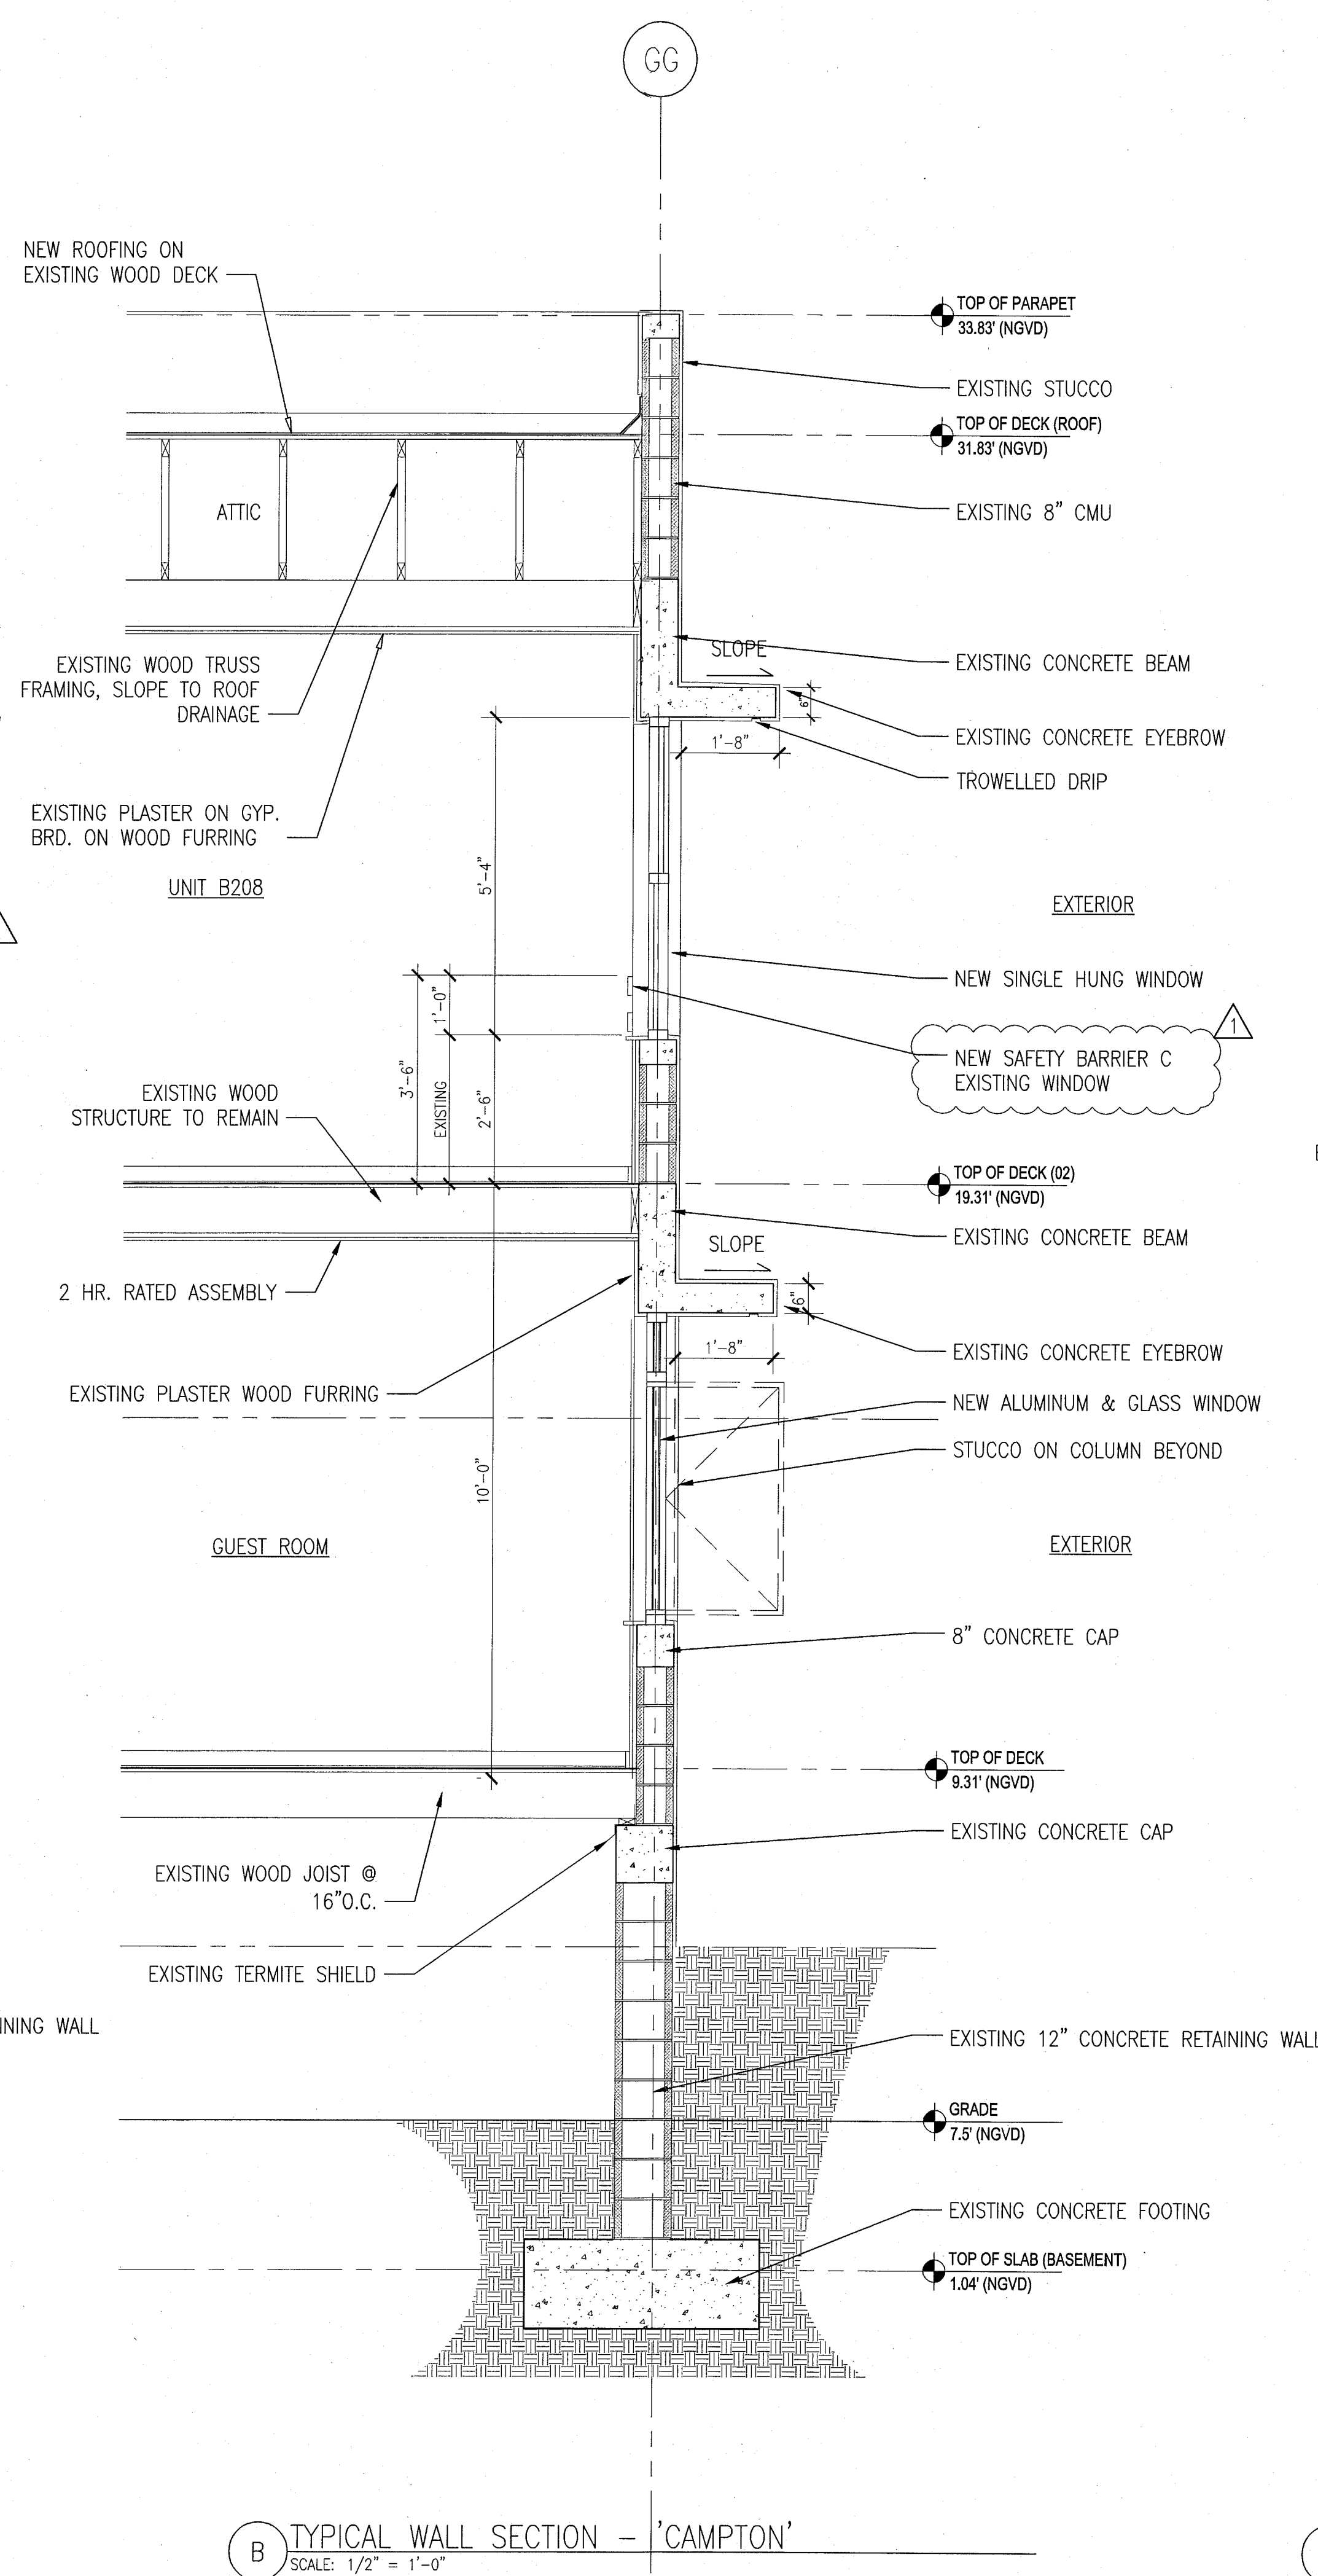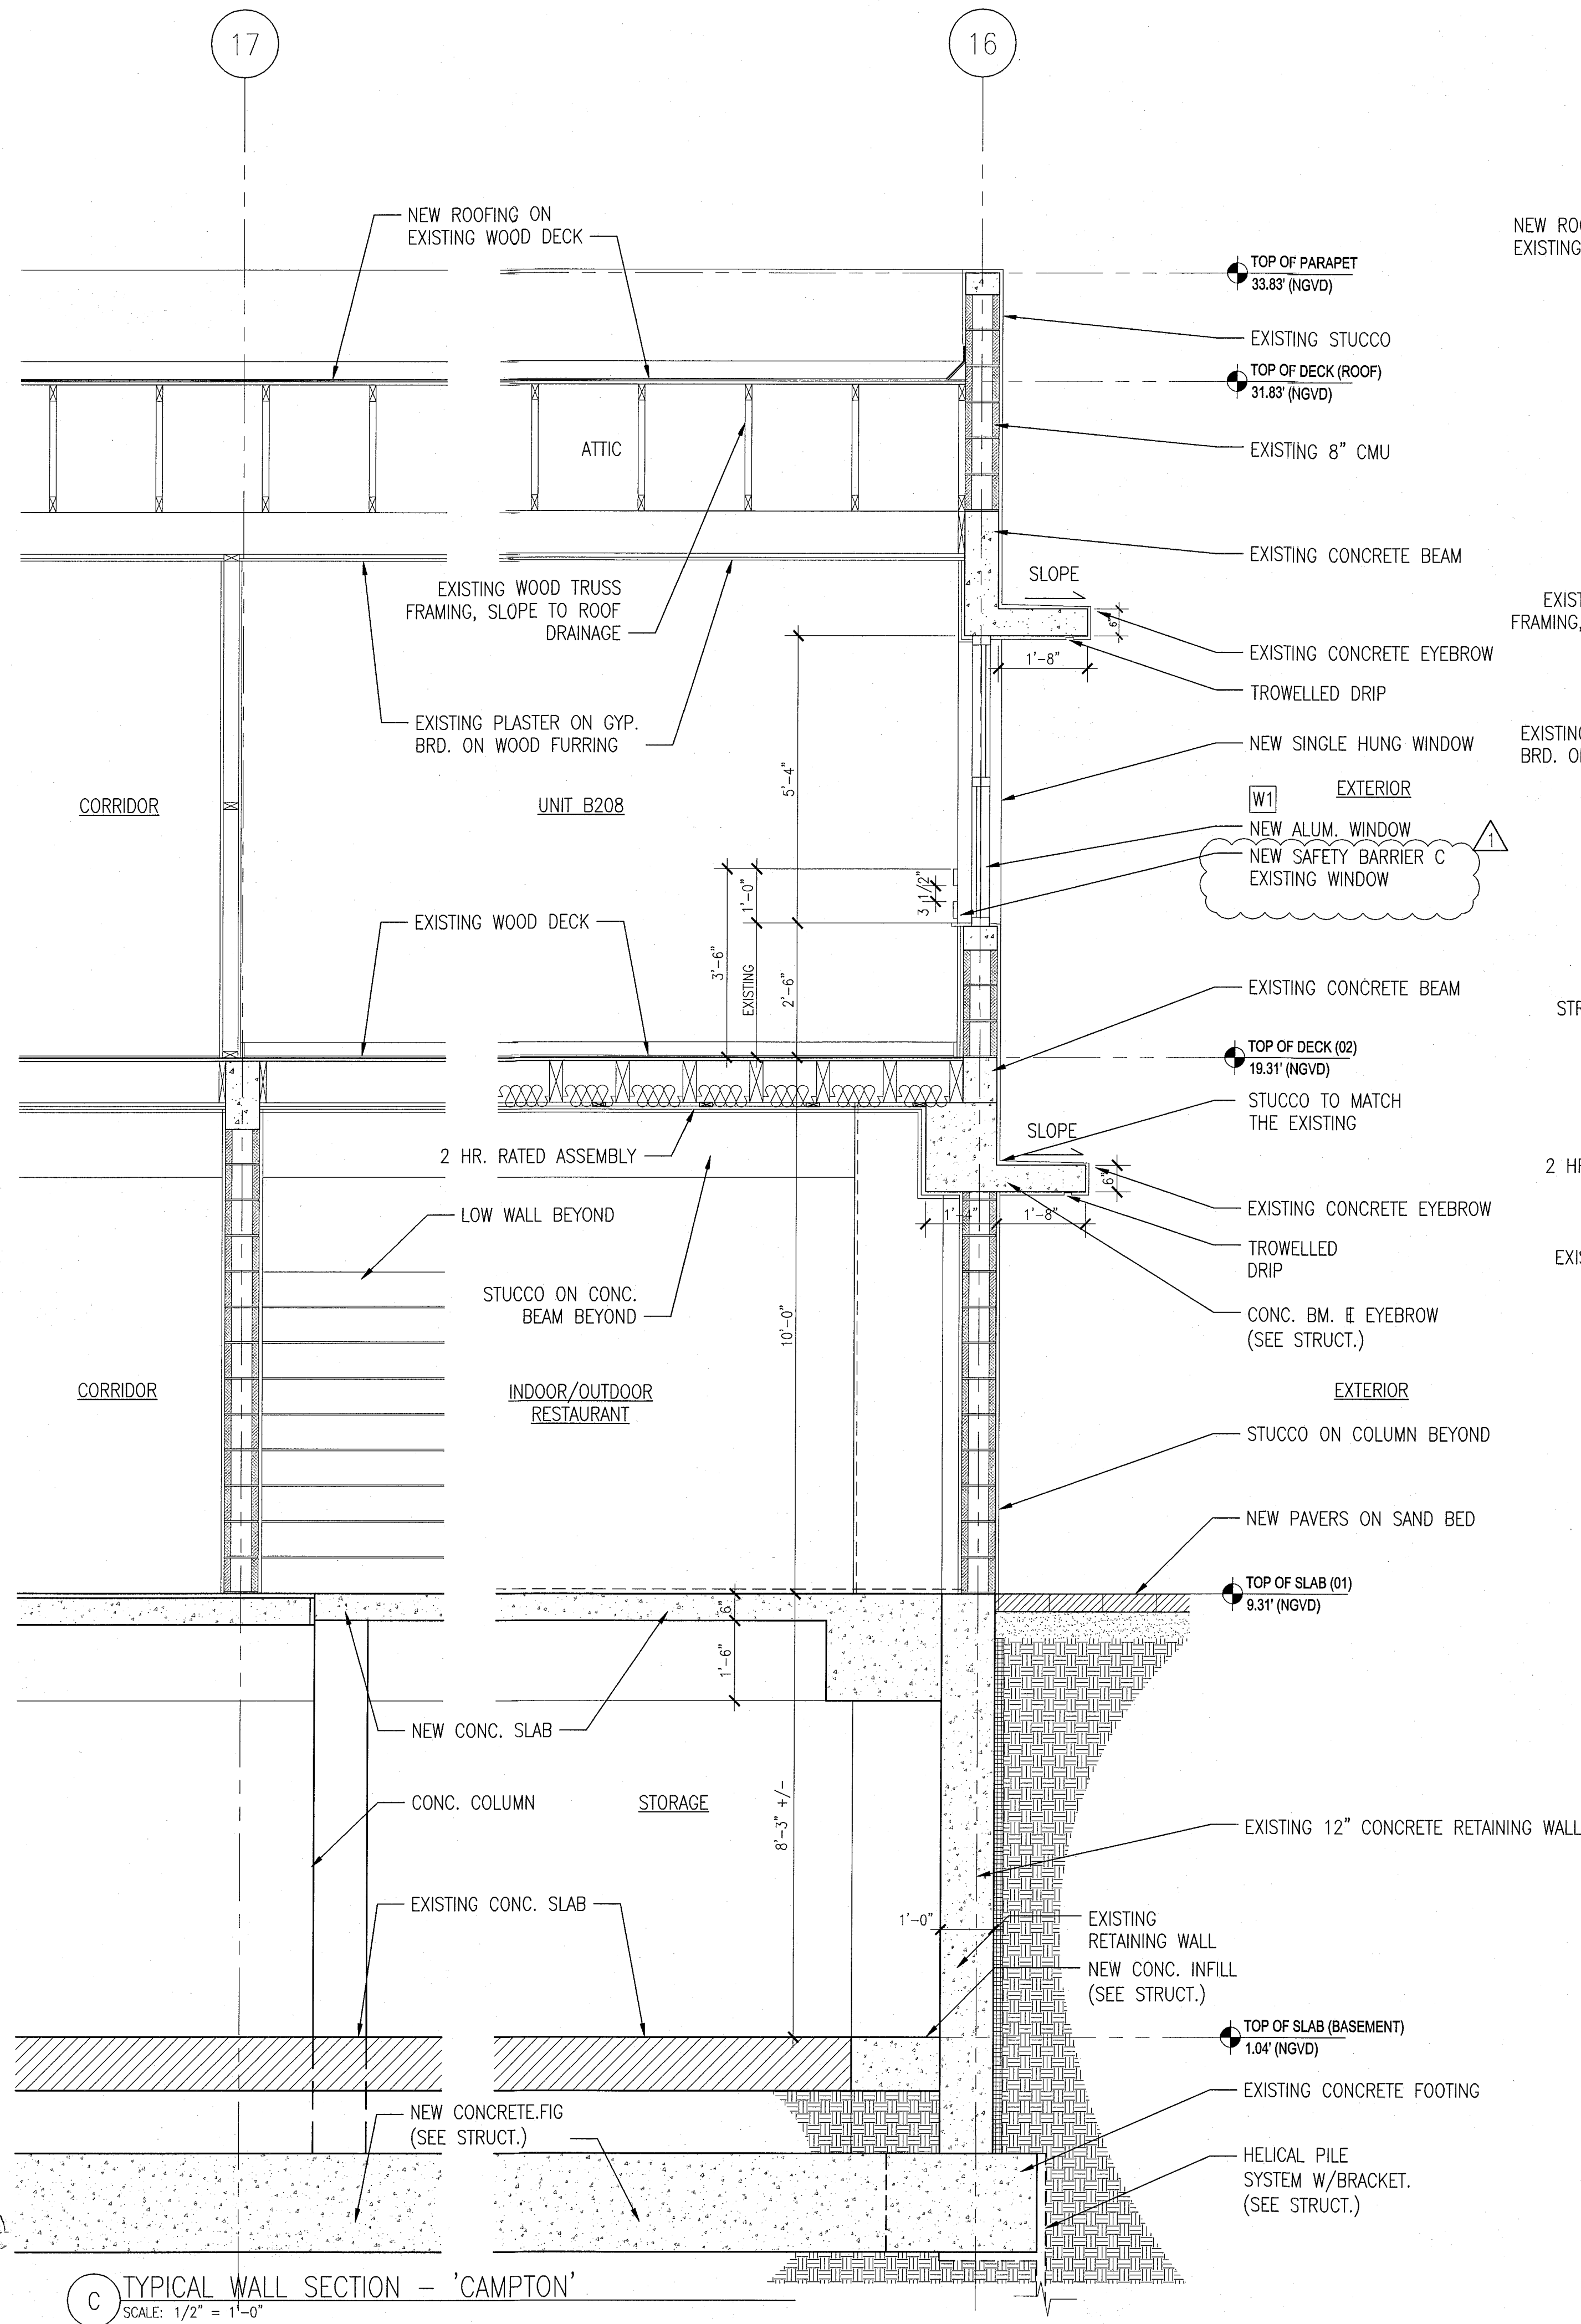


HADDON HALL
1500 COLLINS AVE
MIAMI BEACH, FL

KEYPLAN N.T.S.

REVISIONS		
NO.	DESCRIPTION	ISSUE DATE

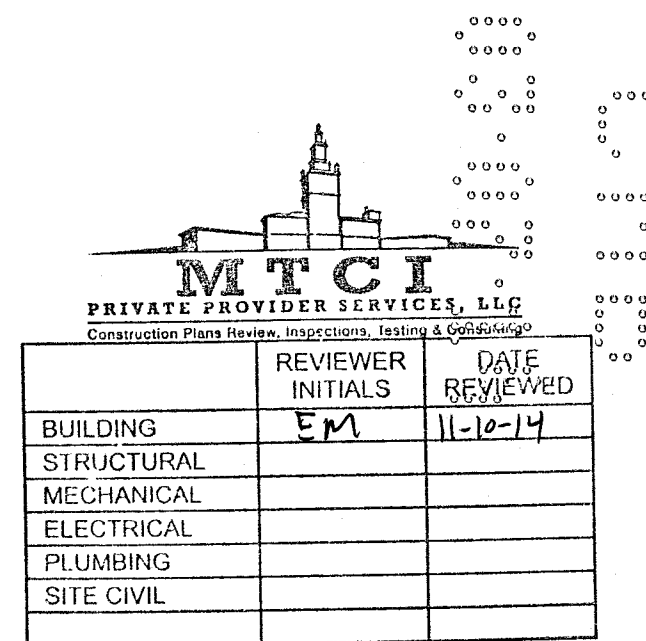

PERMIT SET

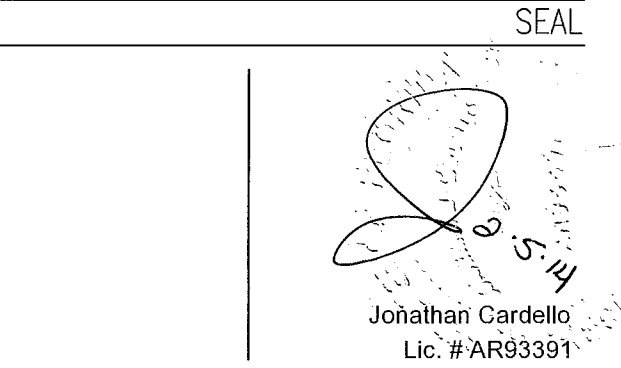

ADD Inc Architecture Interiors Planning
One Biscayne Tower
Suite 1670
Two South
Biscayne Boulevard
Miami, FL 33131
T. 305.482.8700
F. 305.482.8770
www.addinc.com
Lic. # AA25001507 Boston Miami

JOB NUMBER: 13036.00
CHECKED BY:
ISSUE DATE: JANUARY 24, 2014
SCALE: 3/4"=1'-0"


SHEET TITLE

EXISTING TYPICAL
EXTERIOR
WALL SECTIONS


SHEET NUMBER

A413

COPYRIGHT ADD INC 2011

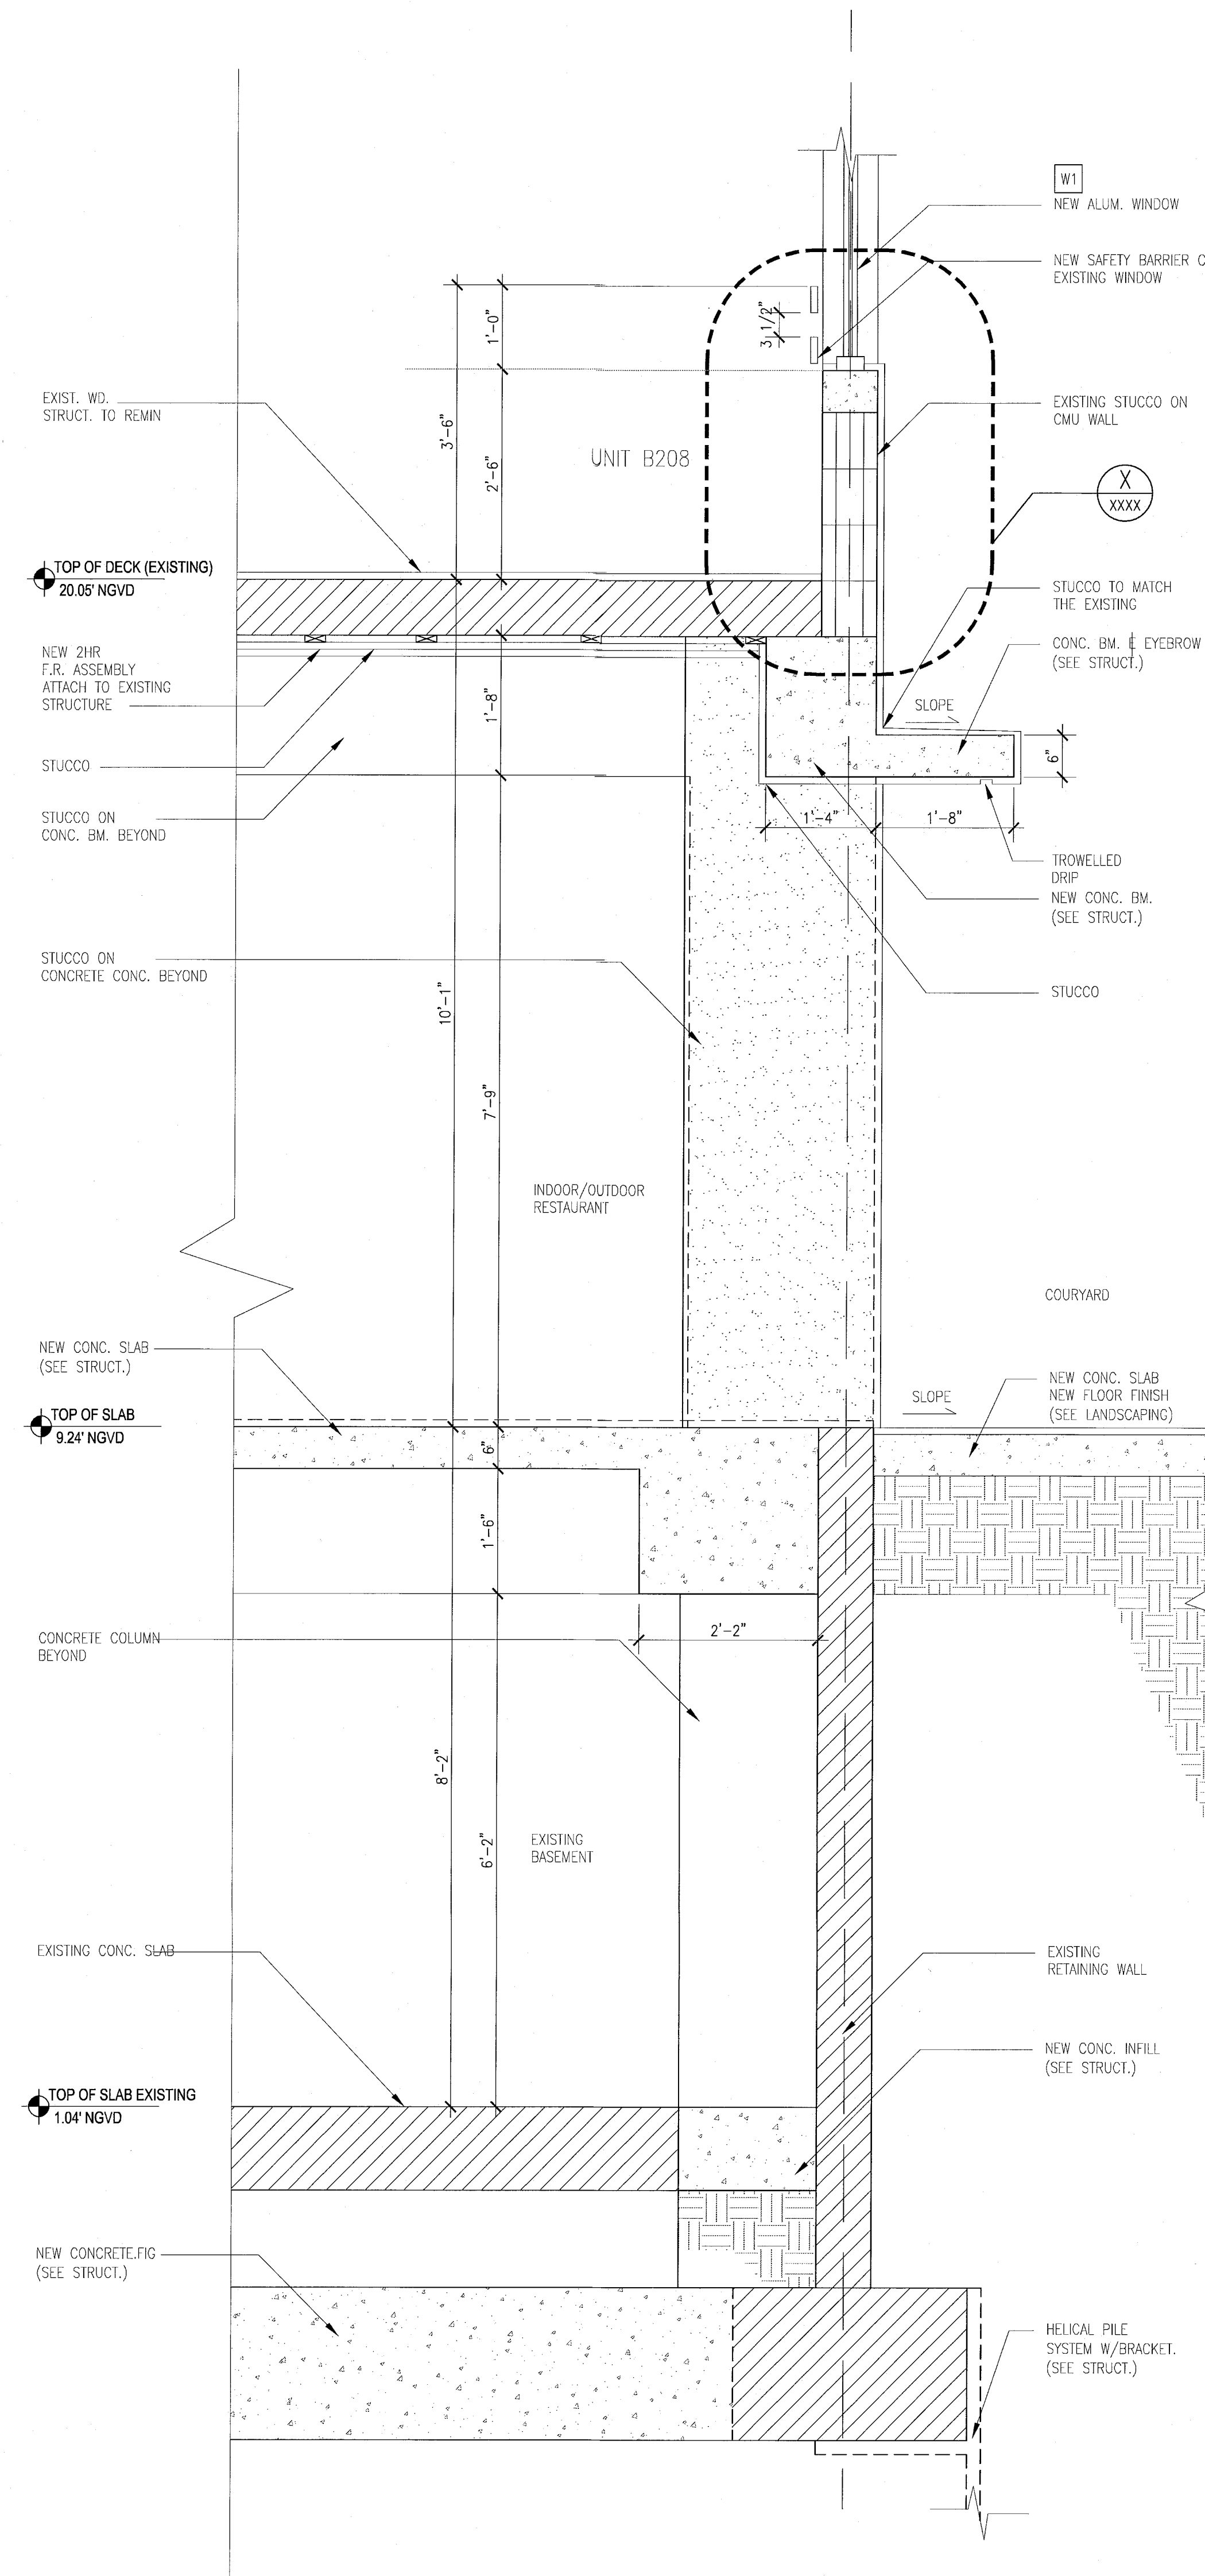

D TYPICAL WALL SECTION - 'CAMPTON'
SCALE: 3/4" = 1'-0"

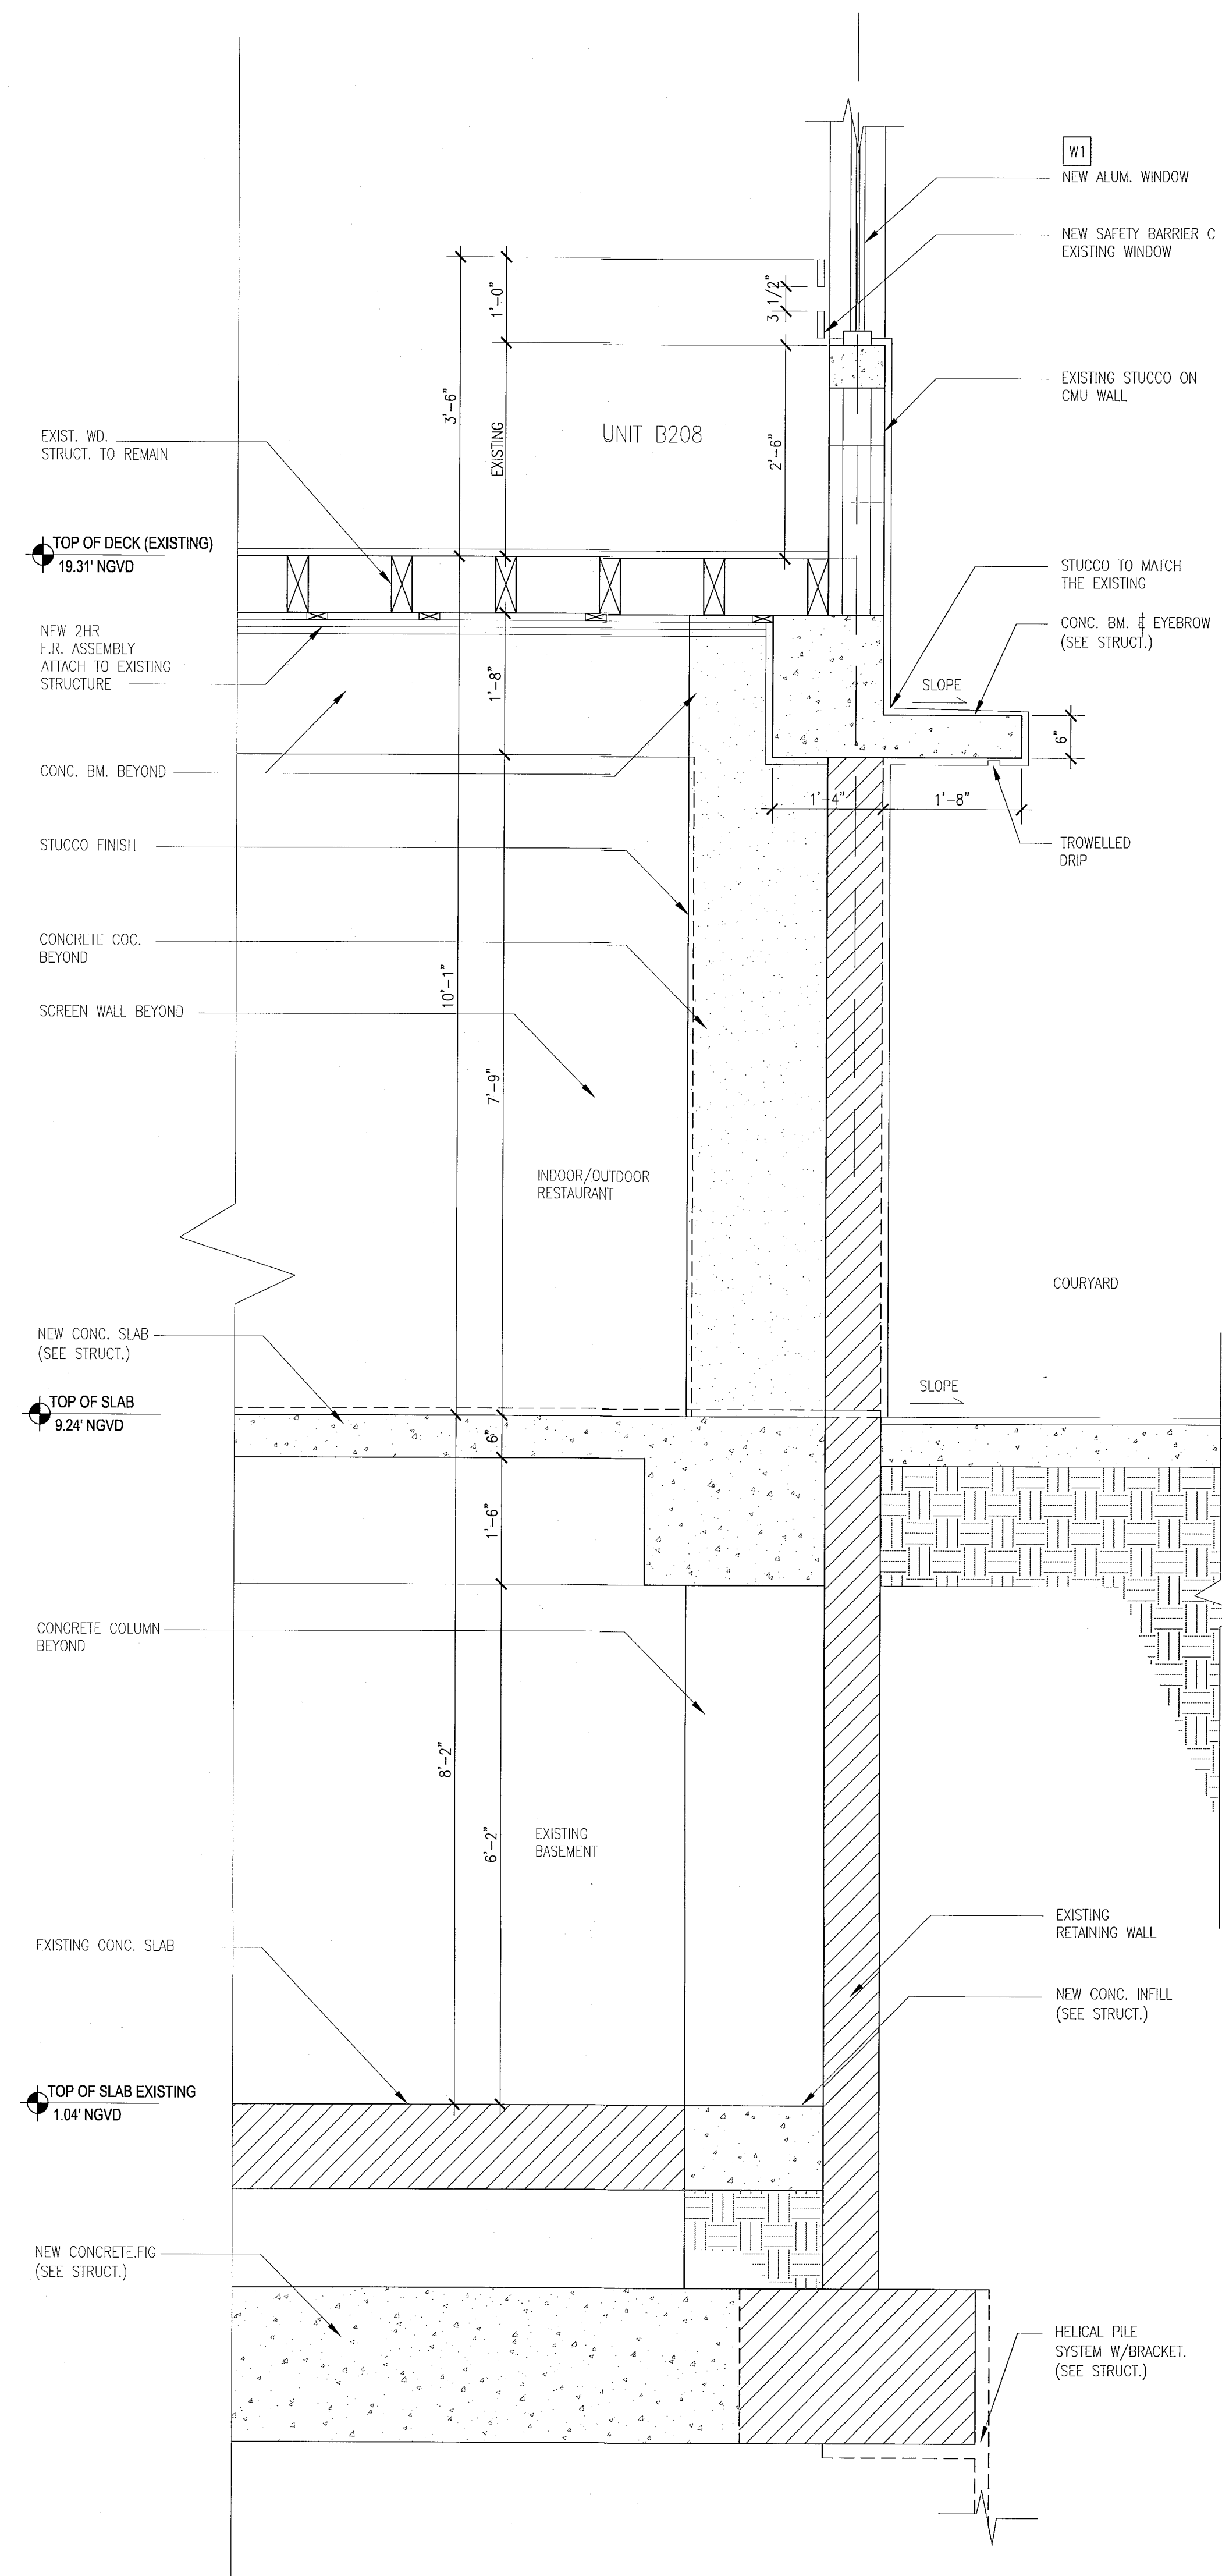

C TYPICAL WALL SECTION AT - 'HADDON HALL'
SCALE: 3/4" = 1'-0"

REVISIONS		
NO.	DESCRIPTION	ISSUE DATE

REVIEWER INITIALS		
NO.	DATE	REVIEWED

PERMIT SET

SEAL

Jonathan Cardullo
Lic. #AR93391

ADD Inc Architecture Interiors Planning

One Biscayne Tower
Suite 1670
Two South
Biscayne Boulevard
Miami, FL 33131
T. 305.482.8700
F. 305.482.8770
www.addinc.com
Lic. #AA26501507

JOB NUMBER: 13036.00
CHECKED BY:
ISSUE DATE: JANUARY 24, 2014
SCALE: 1/2" = 1'-0"


SHEET TITLE

TYPICAL EXTERIOR
WALL SECTIONS
BLDG-C
POOL SUITES


SHEET NUMBER

A415


COPYRIGHT ADD INC. 2011

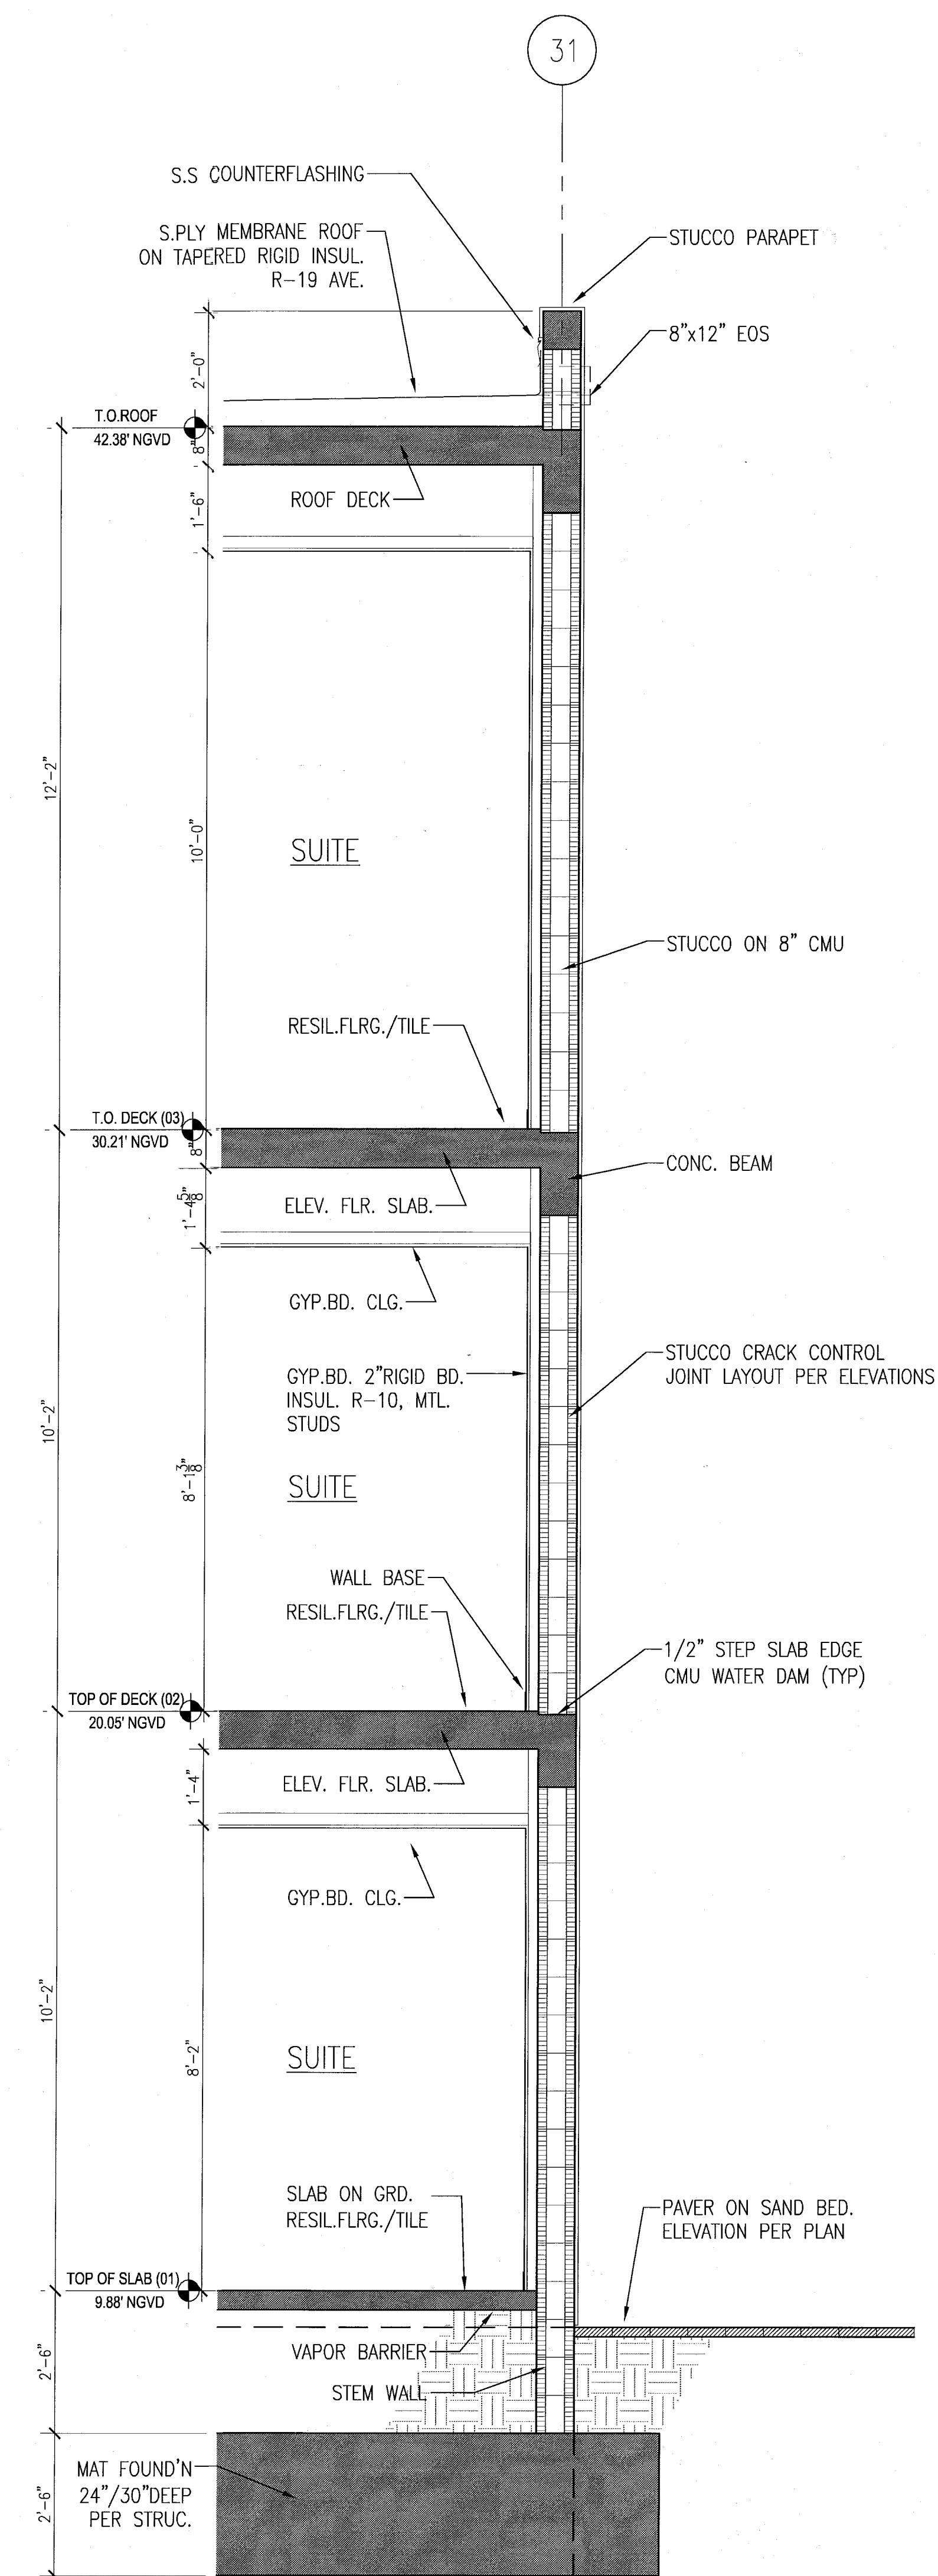

C TYPICAL WEST/EAST WALL SECTION AT POOL SUITES
SCALE: 1/2" = 1'-0"

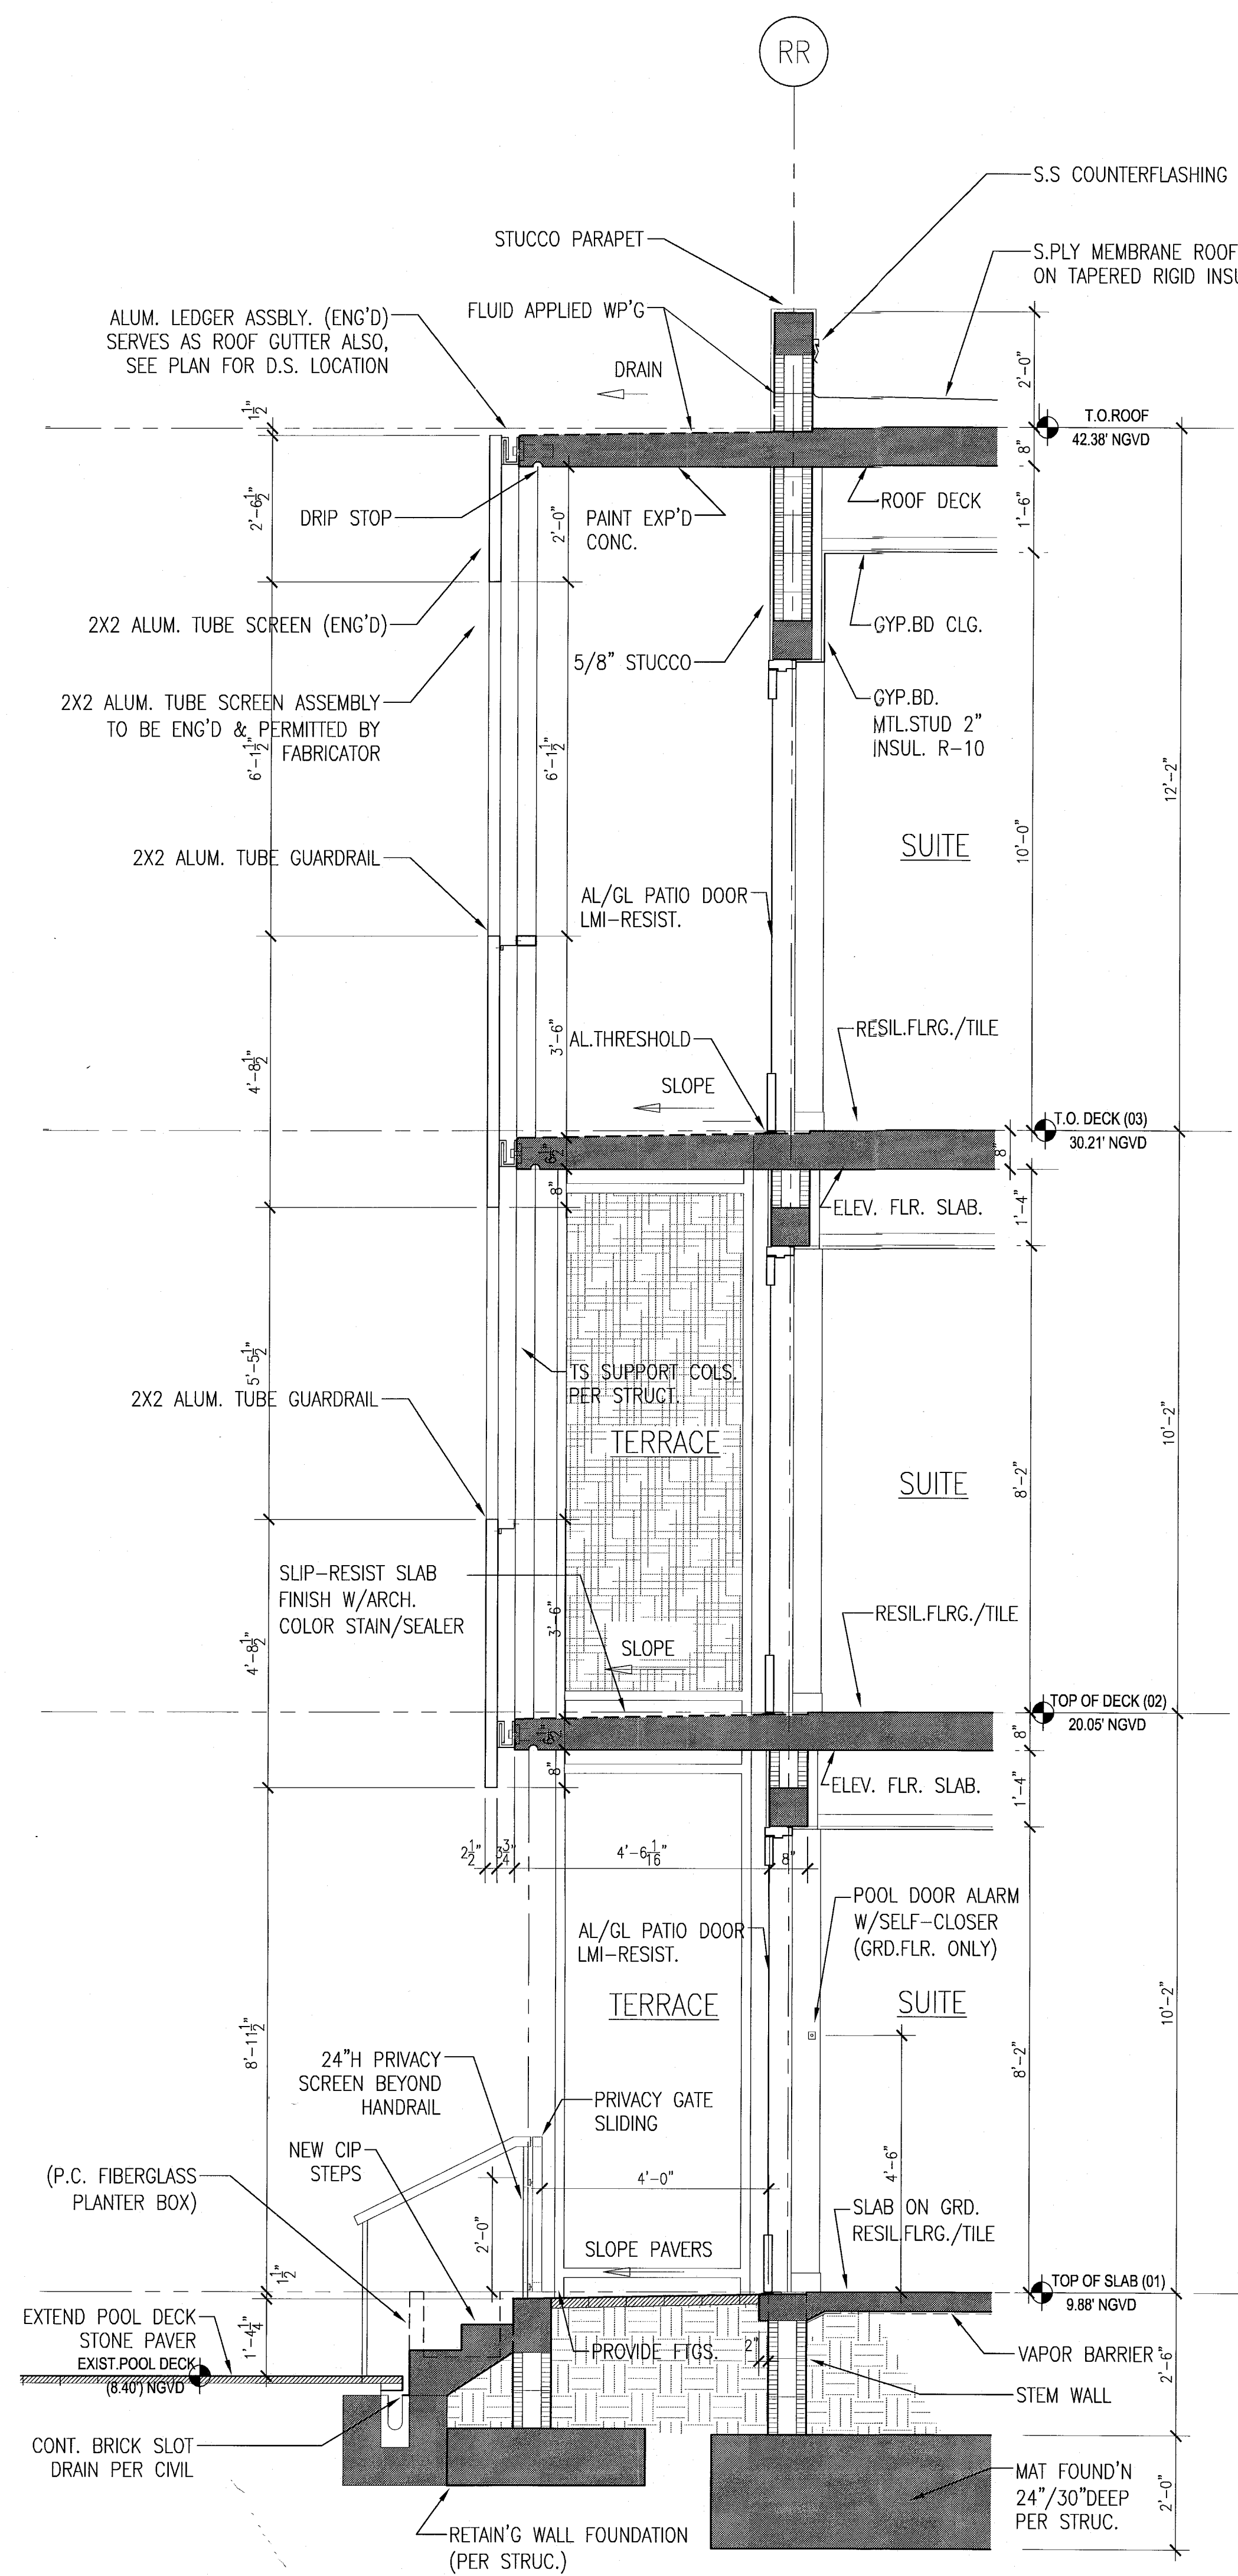


B TYPICAL SOUTH WALL SECTION AT POOL SUITES
SCALE: 1/2" = 1'-0"

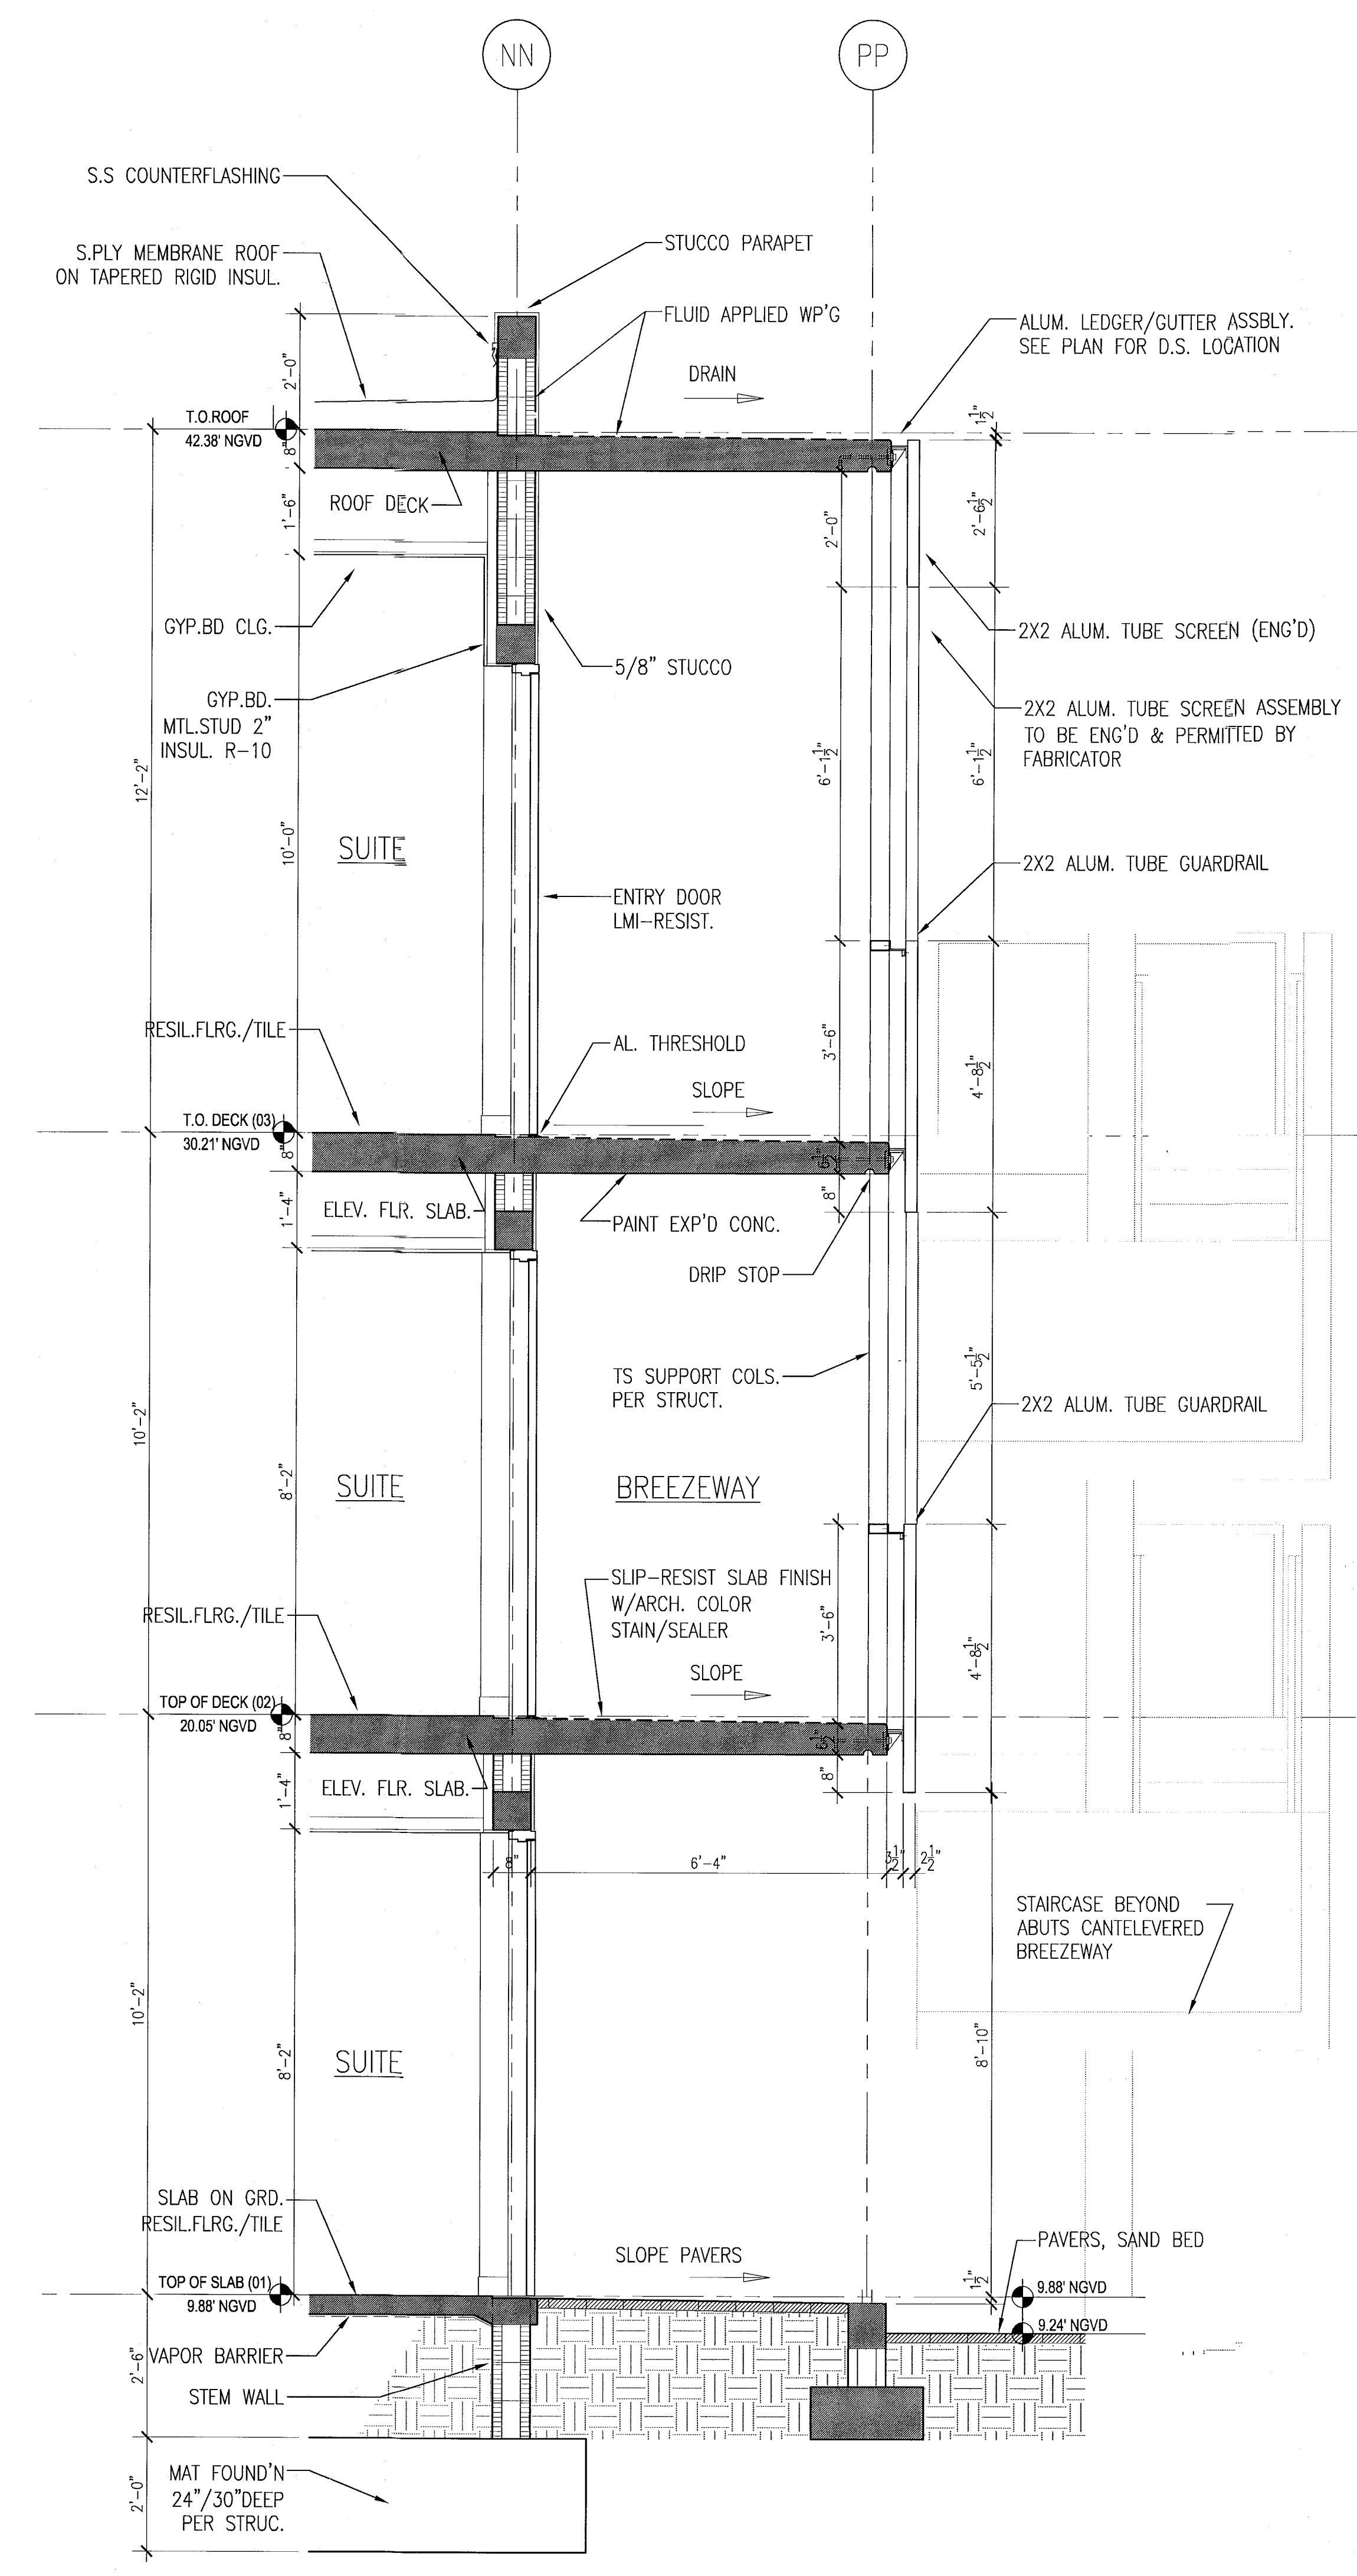


A TYP. NORTH WALL SECTION AT POOL SUITES
SCALE: 1/2" = 1'-0"

HADDON HALL
1500 COLLINS AVE
MIAMI BEACH, FL

KEY PLAN N.T.S.

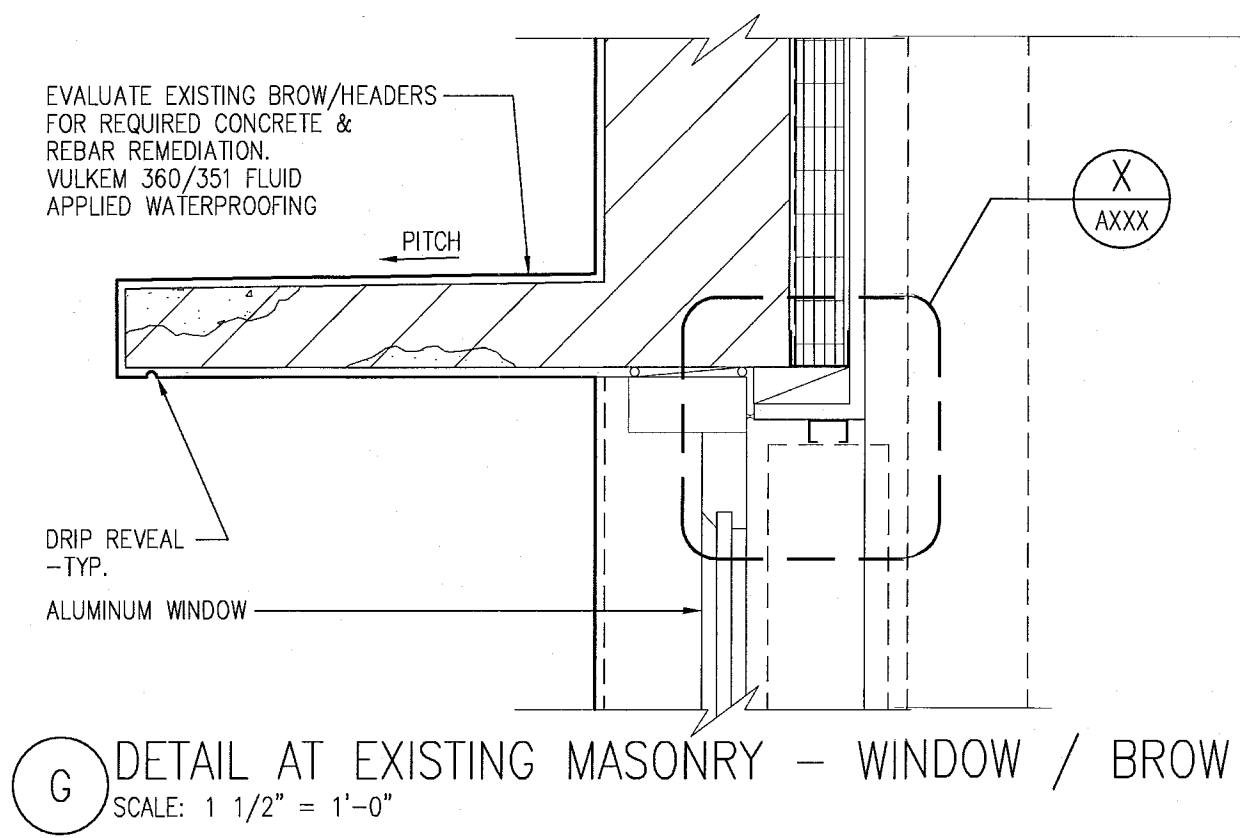

G DETAIL AT EXISTING MASONRY - WINDOW / BROW
SCALE: 1 1/2" = 1'-0"

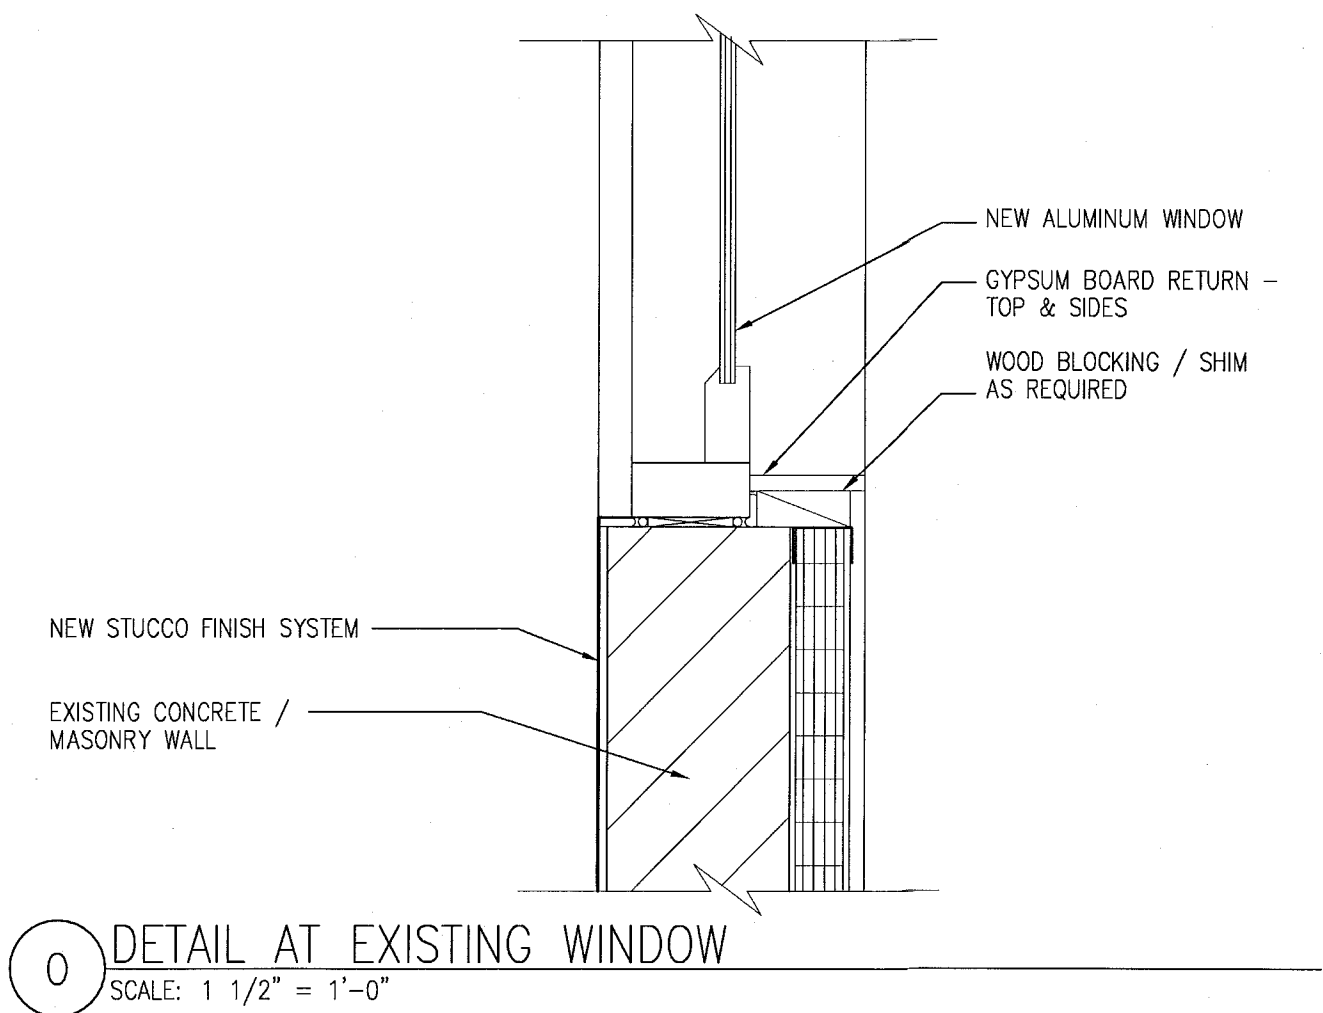

O DETAIL AT EXISTING WINDOW
SCALE: 1 1/2" = 1'-0"

REVIEWER		
INITIALS		
DATE		
REVIEWED		
BUILDING	EA	11-10-14
STRUCTURAL		
MECHANICAL		
ELECTRICAL		
PLUMBING		
SITE CIVIL		

PERMIT SET

SEAL



ADD Inc Architecture Interiors Planning

One Biscayne Tower
Suite 1670
Two South
Biscayne Boulevard
Miami, FL 33131
T. 305.482.8700
F. 305.482.8770
www.addinc.com
Lic. # AA0001507

Boston Miami

JOB NUMBER: 13036.00

CHECKED BY:

ISSUE DATE: JANUARY 24, 2014

SCALE: AS NOTED

SHEET TITLE

TYP. EXTERIOR WALL
WALL AND ROOF
DETAIL SECTIONS

SHEET NUMBER

A420

COPYRIGHT ADD INC 2011

APPROVED
MIAMI BEACH
FIRE DEPARTMENT

HADDON HALL WINDOW SCHEDULE

SIZE	DESCRIPTION	MATERIAL	GLASS	REMARKS
W1 3'-0" x 5'-3"	FIXED-TRANSOM-CASEMENT (FAUX TRANSOM)	ALUM. & GLASS	LMI-RES.	NOA 12-0820.06 PROVIDE 42" AFF. SAFETY BARS
W10 3'-0" x 5'-3"	FIXED-TRANSOM-SLIDER (FAUX TRANSOM)	ALUM. & GLASS	LMI-RES.	NOA 12-0820.06 PROVIDE 42" AFF. SAFETY BARS
W2 1'-6" x 5'-3"	CASEMENT (FAUX TRANSOM)	ALUM. & GLASS	LMI-RES.	NOA 12-0820.06 PROVIDE 42" AFF. SAFETY BARS
W3 1'-6" x 5'-3"	CASEMENT	ALUM. & GLASS	LMI-RES.	NOA 12-0820.06 PROVIDE 42" AFF. SAFETY BARS
W4 3'-3" x 1'-1"	FIXED-TRANSOM-CASEMENT (FAUX TRANSOM)	ALUM. & GLASS	LMI-RES.	NOA 13-0617.26
W5 3'-0" x 5'-6"	FIXED GLASS WINDOW	ALUM. & GLASS	LMI-RES.	NOA 13-0617.26 BEHIND EXIST. GRILLE BLOCK
W6 5'-4.5" x 7'-8"	FIXED GLASS WINDOW	ALUM. & GLASS	LMI-RES.	NOA 13-0115.06
W8 4'-6" x 5'-3"	CASEMENT-TRANSOM	ALUM. & GLASS	LMI-RES.	NOA 12-0820.06 PROVIDE 42" AFF. SAFETY BARS
S9 8'-4" x 9'-4"	FIXED GLASS WINDOW	ALUM. & GLASS	LMI-RES.	NOA 13-0115.06
S10 2'-2" x 1'-2"	DOOR-TRANSOM-SIDELITE	ALUM. & GLASS	LMI-RES.	NOA 13-0115.06
S11 9'-7" x 1'-2"	FIXED GLASS WINDOW	ALUM. & GLASS	LMI-RES.	NOA 13-0115.06
S12 9'-7" x 1'-2"	FIXED GLASS WINDOW	ALUM. & GLASS	LMI-RES.	NOA 13-0115.06
W13 1'-6" x 9'-0"	EXIST. 6x6 GLASS BLOCK OPNG.	ALUM. & GLASS	LMI-RES.	NOA 13-0617.26
W21 3'-0" x 8'-7"	FIXED GLASS WINDOW	ALUM. & GLASS	LMI-RES.	NOA 13-0617.26
W22 1'-6" x 10'-0"	FIXED GLASS WINDOW	ALUM. & GLASS	LMI-RES.	NOA 13-0617.26

FENESTRATION NOAs (Notice of Acceptance)

1 ALUMINUM FIXED WINDOW	ES WINDOWS SERIES 1500	NOA 13-0617.26
2 ALUMINUM SINGLE HUNG WINDOW	ES WINDOWS SERIES 1100	NOA 12-0410.04
3 ALUMINUM CASEMENT WINDOW	ES WINDOWS SERIES 5-5000	NOA 12-0820.06
4 ALUMINUM GUESTROOM PATIO DOOR	CGI SERIES 450	NOA 12-0706.03
5 ALUMINUM STOREFRONT ENTRY DOOR	ES WINDOWS SERIES 9000	NOA 13-0617.29
6 ALUMINUM STOREFRONT FRAMING	ES WINDOWS SERIES 8000	NOA 13-0115.06
7 HOLLOW METAL DOORS - OUTSWING	STEELCRAFT	NOA 12-0305.14
8 HOLLOW METAL DOORS - INSWING	STEELCRAFT	NOA 13-0617.31

NOTES:

- ALL GLASS TO HAVE VISIBLE LIGHT TRANSMISSION AS FOLLOWS:
 - AT HADDON EAST FACADE AT 34%
 - AT ALL OTHER HADDON ALL AND CAMPTON APARTMENT FACADES $\geq 3\%$
 - AT POOL SUITES FACADES $\geq 3\%$
- ALL WINDOW FRAMES TO HAVE A SILVER METALLIC FINISH. DURANAR COLOR TO BE SELECTED BY ARCHITECT.
- ALL SINGLE HUNG WINDOW SHALL OPERATE FROM THE TOP AT CURVED/FACETED WINDOW LOCATIONS.
- LMI - LARGE MISSILE IMPACT APPLIES TO THOSE WINDOWS INSTALLED AT 30' OR LESS ABOVE GROUND FLOOR.
- S.M.I. - SMALL MISSILE IMPACT APPLIES TO THOSE WINDOWS INSTALLED AT 30' OR MORE ABOVE GROUND FLOOR.
- AS ALLOWED BY STATE ENERGY CODE FOR EXISTING BUILDING CONDITIONS, U-VALUE=1.25 AND SHGC = 0.82

GENERAL WINDOW NOTES:

- ALL GLAZED AREAS IN HAZARDOUS LOCATIONS AS DEFINED IN SECTION 2406.4 SHALL COMPLY WITH SECTIONS 2406.1.1 - 2406.1.4

HADDON HALL
1500 COLLINS AVE.
MIAMI BEACH, FL

KEYPLAN

N.T.S.

REVISIONS

NO.	DESCRIPTION	ISSUE DATE
1	PROGRESS TO 100% CD	02-18-2014
1B	DOOR-WINDOW COORD.	03-5-2014
1A	P&Z COMMENTS	07-14-2014
1A	FIRE & MTCI PERMIT COMMENTS	08-21-2014
1A	FIRE & MTCI PERMIT COMMENTS	09-29-2014

1 HADDON HALL WINDOW TYPE ELEVATIONS


SCALE: 1/4" = 1'-0"

HADDON HALL STOREFRONT SCHEDULE

SIZE	DESCRIPTION	MATERIAL	GLASS	REMARKS
S1 6'-5" x 10'-0"	DOOR-TRANSOM	ALUM. & GLASS	LMI-RES.	NOA 13-0115.06
S2 8'-8" x 10'-0"	DOOR-TRANSOM	ALUM. & GLASS	LMI-RES.	NOA 13-0115.06
S3 12'-2.5" x 9'-4"	DOOR-TRANSOM-SIDELITES	ALUM. & GLASS	LMI-RES.	NOA 13-0115.06
S4 4'-10" x 9'-4"	FIXED GLASS WINDOW	ALUM. & GLASS	LMI-RES.	NOA 13-0115.06

CAMPTON WINDOW SCHEDULE

SIZE	DESCRIPTION	MATERIAL	GLASS	REMARKS
W3 1'-6" x 3'-2"	CASEMENT	ALUM. & GLASS	IMPACT GLASS	
W14 6'-2" x 5'-5"	FIXED/CASEMENT W/ TRANSOM ABOVE	ALUM. & GLASS	IMPACT GLASS	LIMIT CASEMENT OPENING TO 4" MAX.
W15 3'-2" x 5'-5"	CASEMENT W/ TRANSOM ABOVE	ALUM. & GLASS	IMPACT GLASS	LIMIT CASEMENT OPENING TO 4" MAX.
W15 3'-2" x 5'-5"	SLIDER W/ TRANSOM ABOVE	ALUM. & GLASS	IMPACT GLASS	
W16 3'-3" x 5'-5"	FIXED/CASEMENT/FIXED W/ TRANSOM ABOVE	ALUM. & GLASS	IMPACT GLASS	ARCHED OPENING, LIMIT CASEMENT OPENING TO 4" MAX.
W17 4'-9" x 6'-2"	FIXED/FIXED W/ TRANSOM ABOVE	ALUM. & GLASS	IMPACT GLASS	

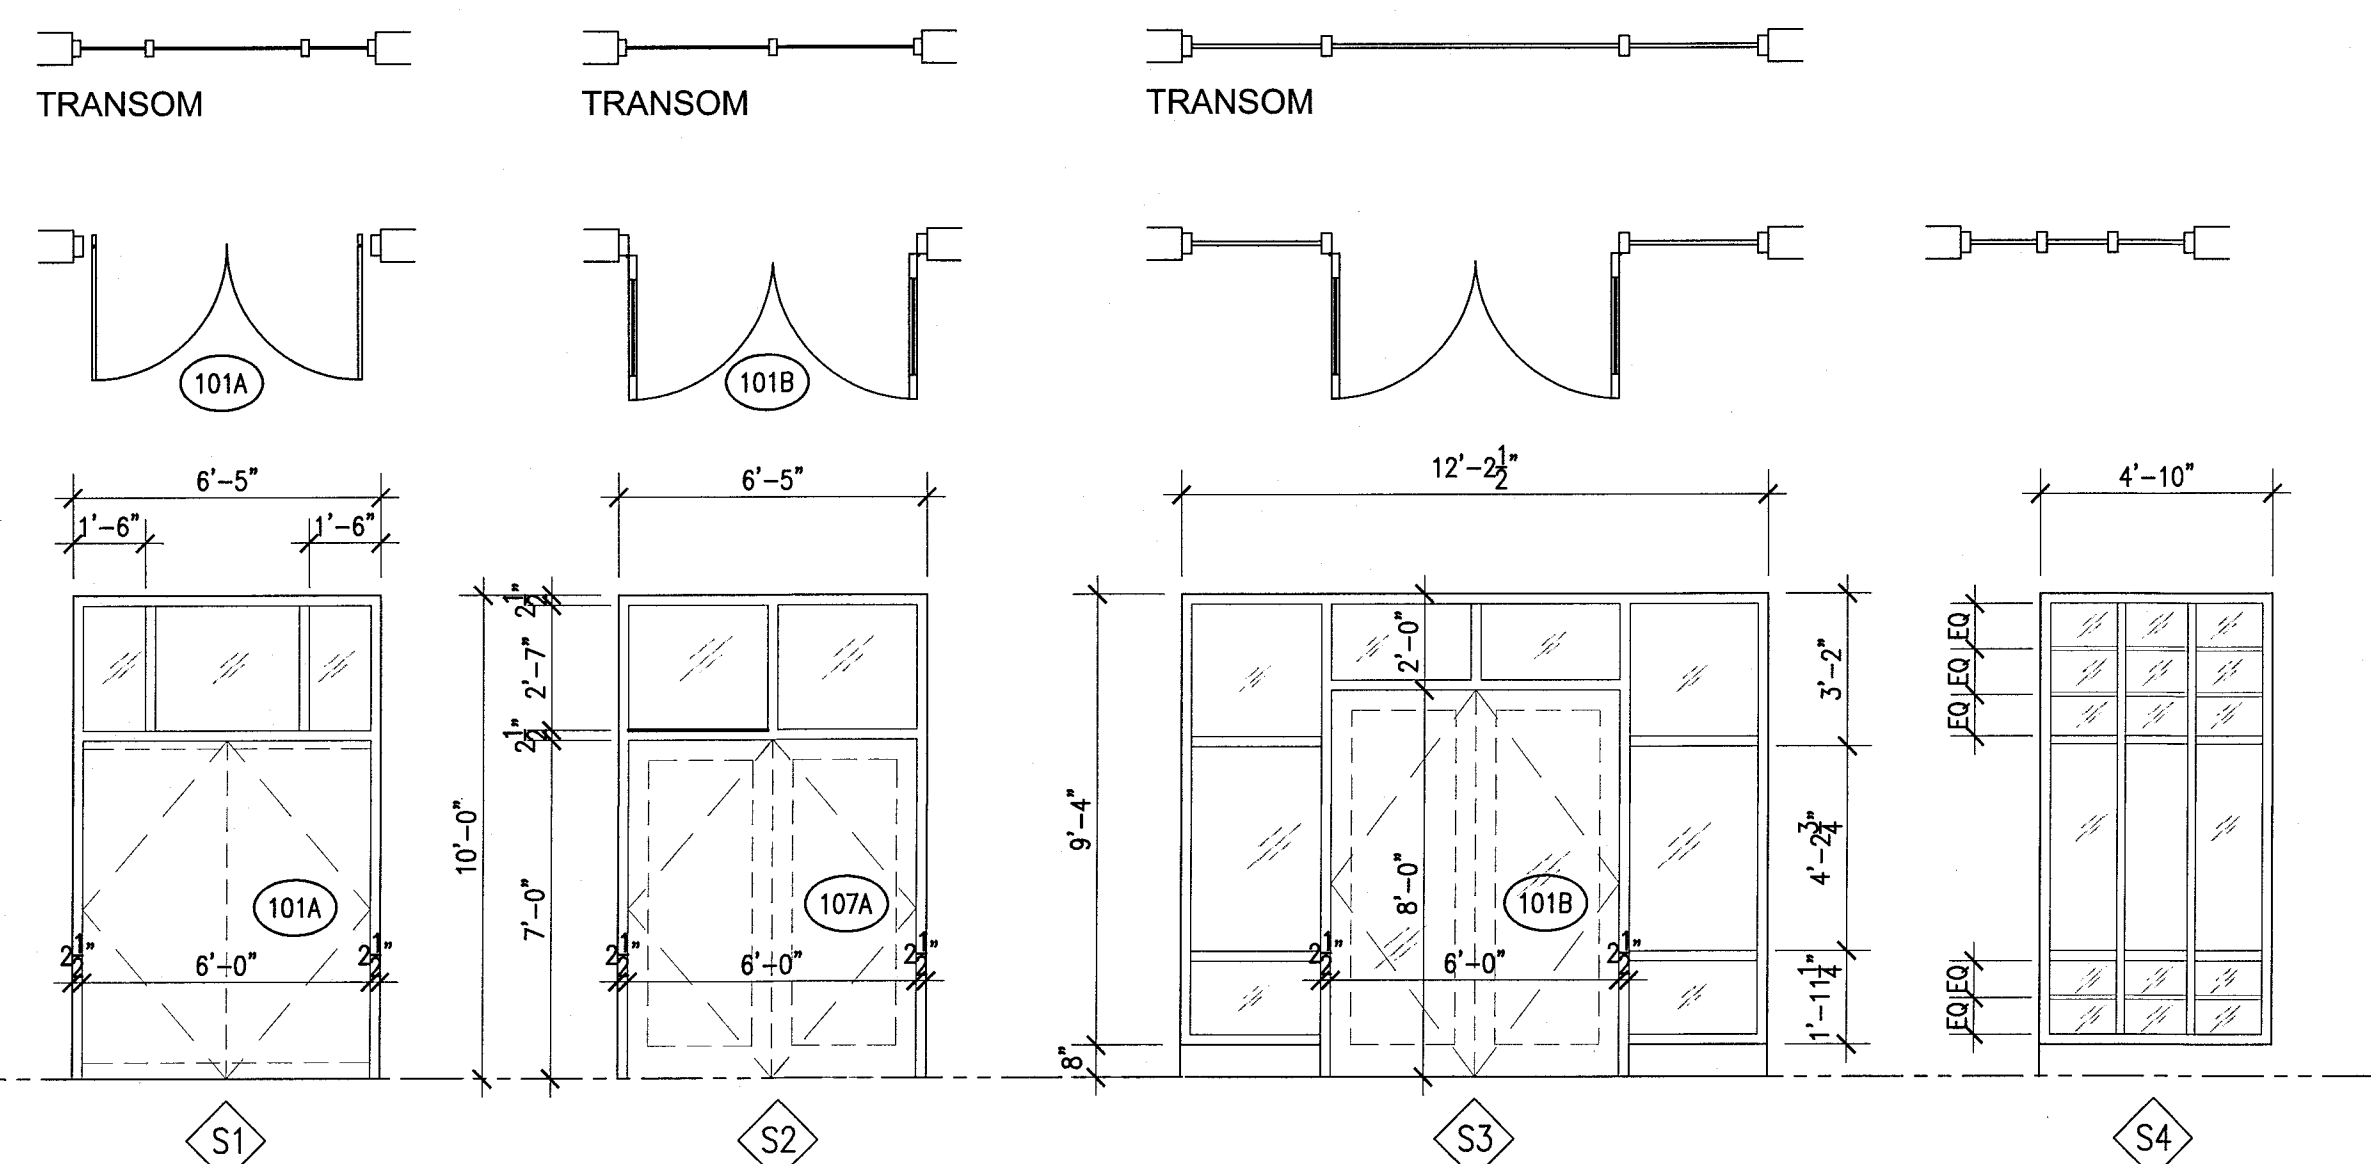


2 HADDON HALL STOREFRONT ELEVATIONS

SCALE: 1/4" = 1'-0"

POOL SUITES WINDOW SCHEDULE

SIZE	DESCRIPTION	MATERIAL	GLASS	REMARKS
W18 5'-6" x 5'-2"	FIXED GLASS WINDOW	ALUM.	IMPACT GLASS	NOA 13-0617.26
W19 3'-4" x 2'-2"	FIXED GLASS WINDOW	ALUM.	IMPACT GLASS	NOA 13-0617.26

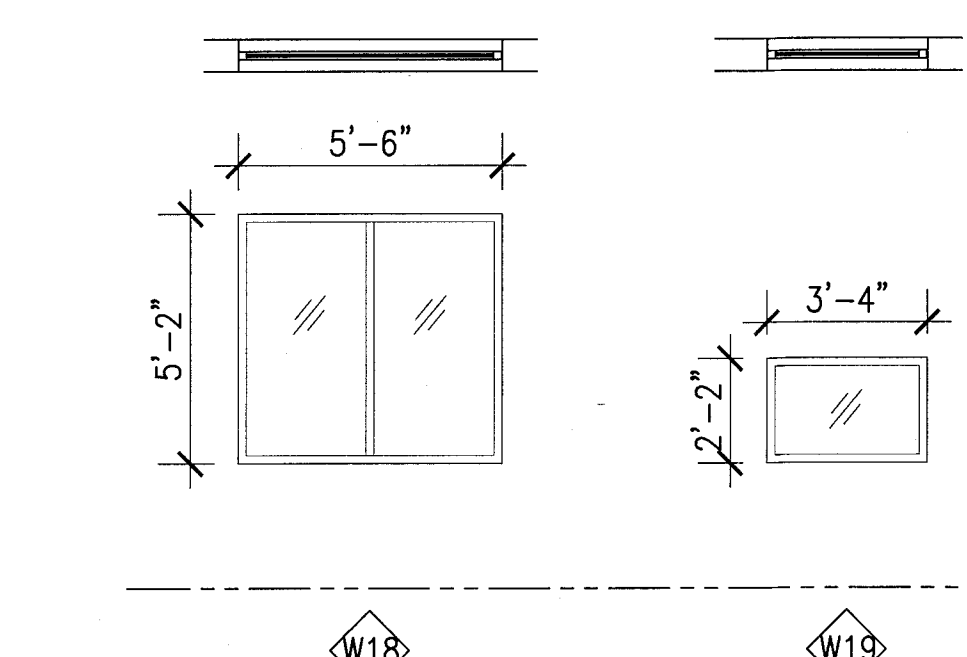


2 POOL SUITES WINDOW TYPE ELEVATIONS

SCALE: 1/4" = 1'-0"

3 CAMPTON WINDOW TYPE ELEVATIONS

SCALE: 1/4" = 1'-0"

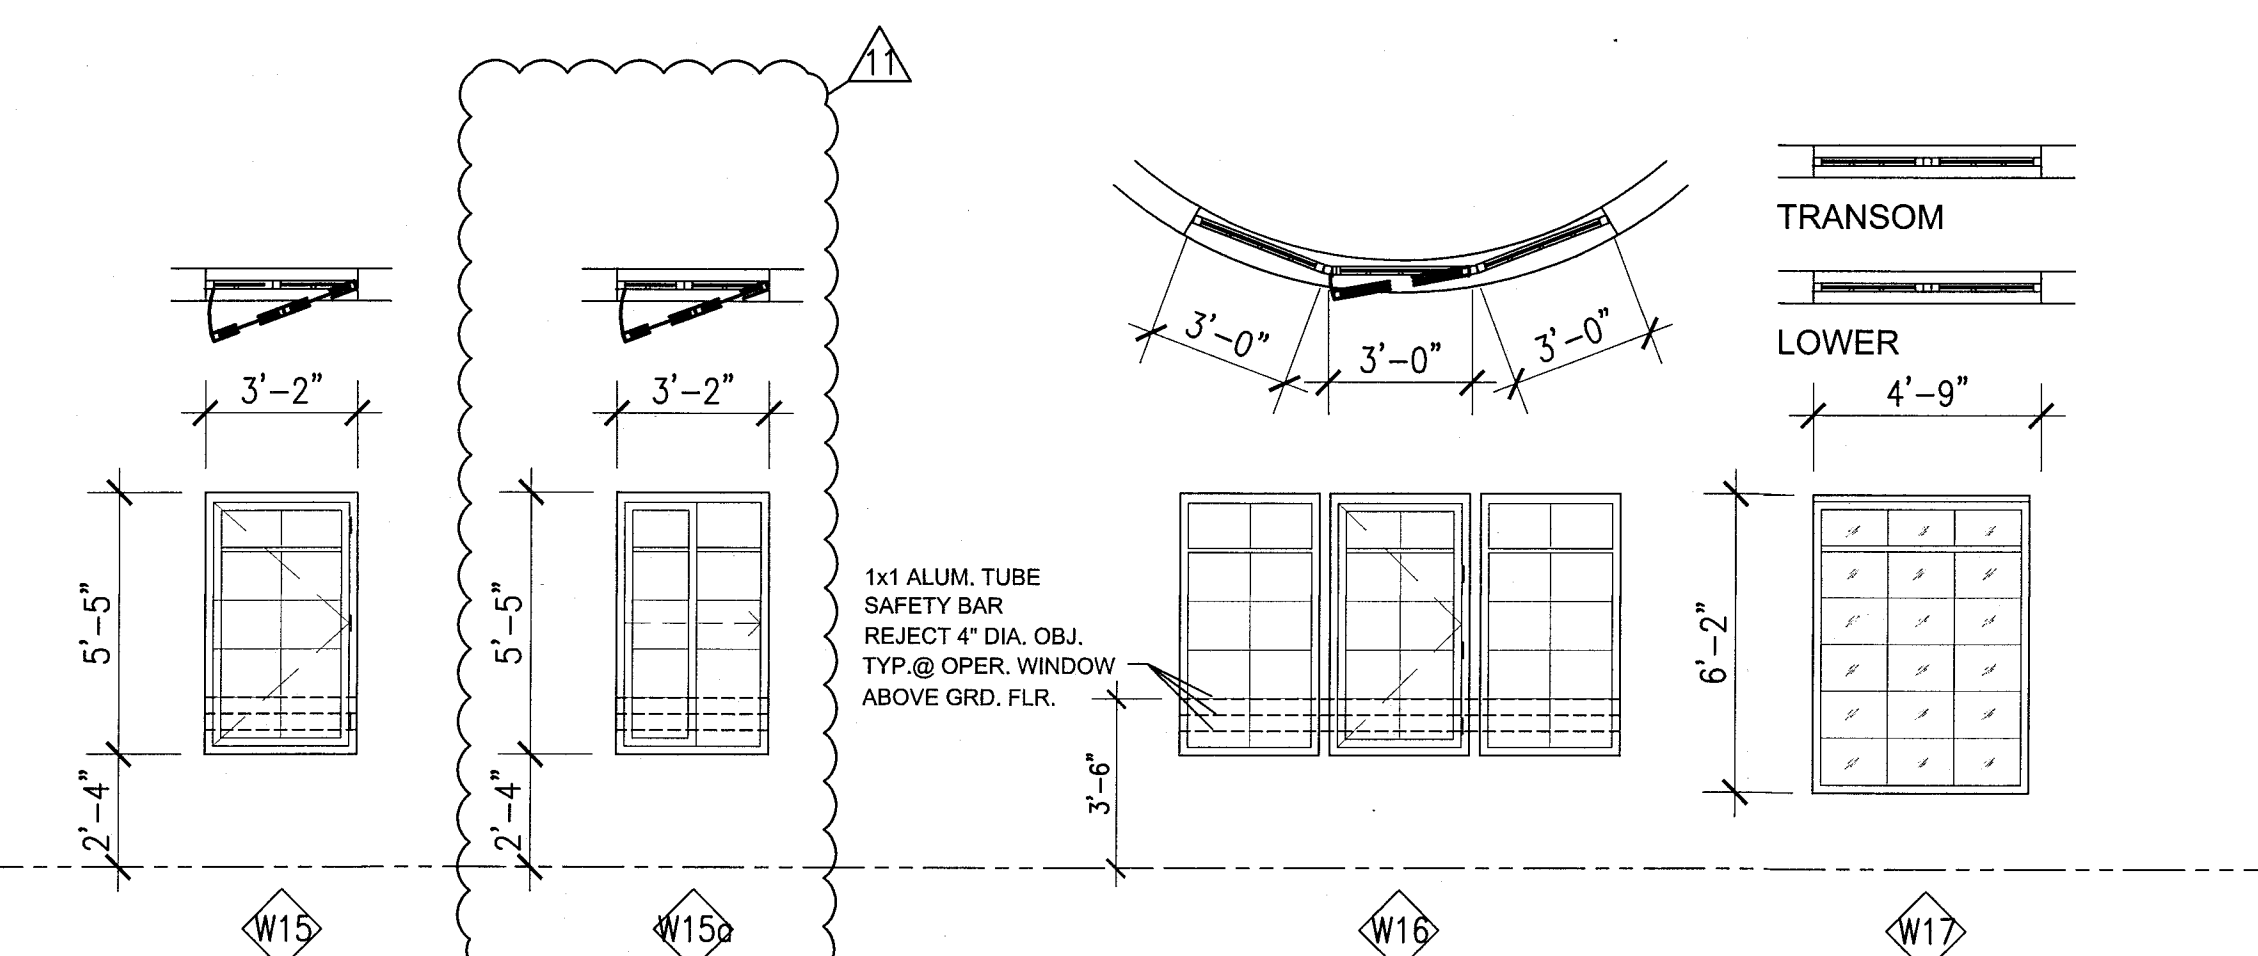

FRESH AIR VENTILATION CHART

HADDON HALL									
UNIT	UNIT AREA	EXISTING R.O. AREA	EXISTING OPEN FREE AREA	EXISTING % OPEN FREE AREA	REQUIRED 4% OPEN FREE AREA	PROPOSED WINDOW TYPE	PROPOSED OPEN FREE AREA	PROPOSED % OPEN FREE AREA	REMARKS
A105	292 SF	48.14 SF	18.9 SF	4.7 %	11.68 SF	W-1	13.80 SF	4.7 %	EXISTING AWNING WINDOW TO BE REPLACED
A121	294 SF	31.50 SF	13.8 SF	6.4 %	11.76 SF	W-4	12.57 SF	4.7 %	EXISTING AWNING WINDOW TO BE REPLACED
A126	292 SF	31.50 SF	13.8 SF	4.7 %	11.68 SF	W-1	13.80 SF	4.7 %	EXISTING AWNING WINDOW TO BE REPLACED
A127	238 SF	15.75 SF	6.5 SF	2.7 %	8.32 SF	W-2	13.00 SF	5.4 %	EXISTING AWNING WINDOW TO BE REPLACED
CAMPTON									
B107	302 SF	32.39 SF	32.39 SF	10.7 %	12.07 SF	W-1	13.80 SF		
B202	222 SF	32.39 SF	32.39 SF	14.5 %	8.80 SF	W-1	13.80 SF		EXISTING JALOUSIE WINDOW TO BE REPLACED
B206	494 SF	16.64 SF	13.8 SF			W-2	13.00 SF		EXISTING JALOUSIE WINDOW TO BE REPLACED
		4.75 SF	4.75 SF			W-3	3.00 SF		EXISTING JALOUSIE WINDOW TO BE REPLACED
			TOTAL 50.84 SF	10.2 %	19.76 SF		TOTAL 29.80 SF	6.0 %	

100% CONSTRUCTION DOCUMENT SET

SEAL

MTCI		
PRIVATE PROVIDER SERVICES, LLC		
Construction Plans Review, Inspection, Design & Construction		
BUILDING	REVIEWER	DATE
STRUCTURAL	CM	11-10-14
MECHANICAL		
ELECTRICAL		
PLUMBING		
SITE/CIVIL		

ADD Inc

Architecture Interiors Planning

One Biscayne Tower
Suite 1670
Two South
Biscayne Boulevard
Miami, FL 33131
T. 305.482.8700
F. 305.482.8770
www.addinc.com
Lic. # AA26001507

JOB NUMBER: 13036.00

CHECKED BY:

ISSUE DATE: FEBRUARY 18, 2014

SCALE: 1/8" = 1'-0"

SHEET TITLE


WINDOW SCHEDULE

SHEET NUMBER


A431

COPYRIGHT ADD INC 2011


APPROVED
MIAMI BEACH
FIRE DEPARTMENT

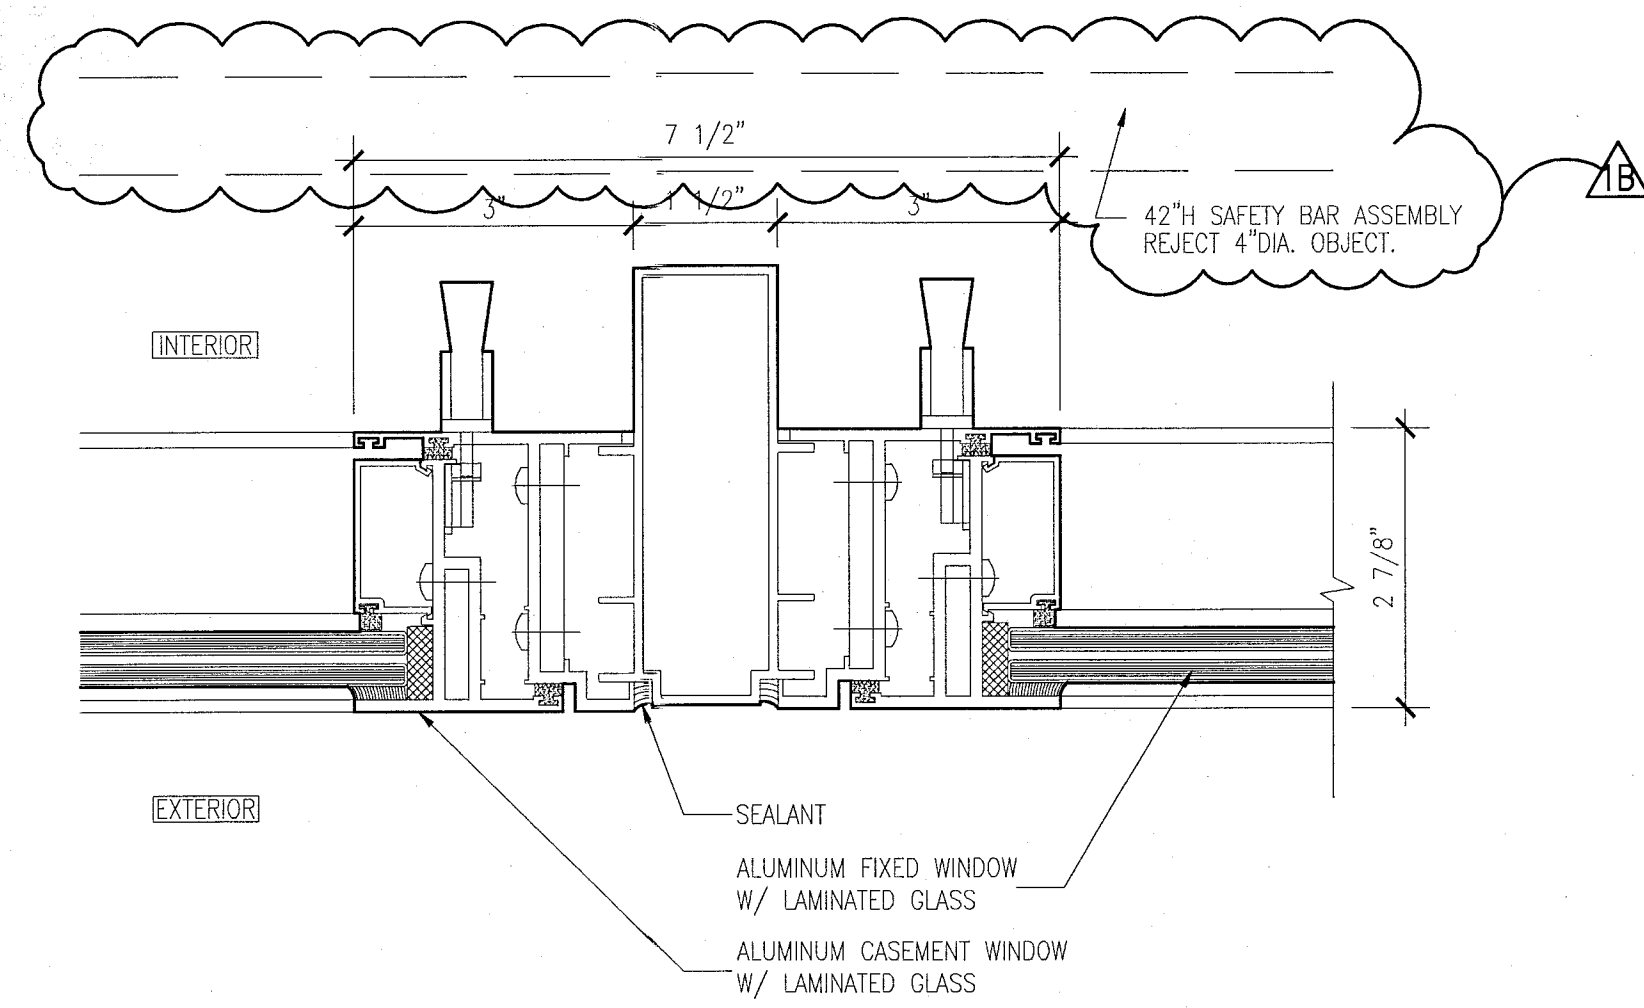


10 JAMB DETAIL AT TWO CASEMENT WINDOWS
SCALE: 6" = 1'-0"

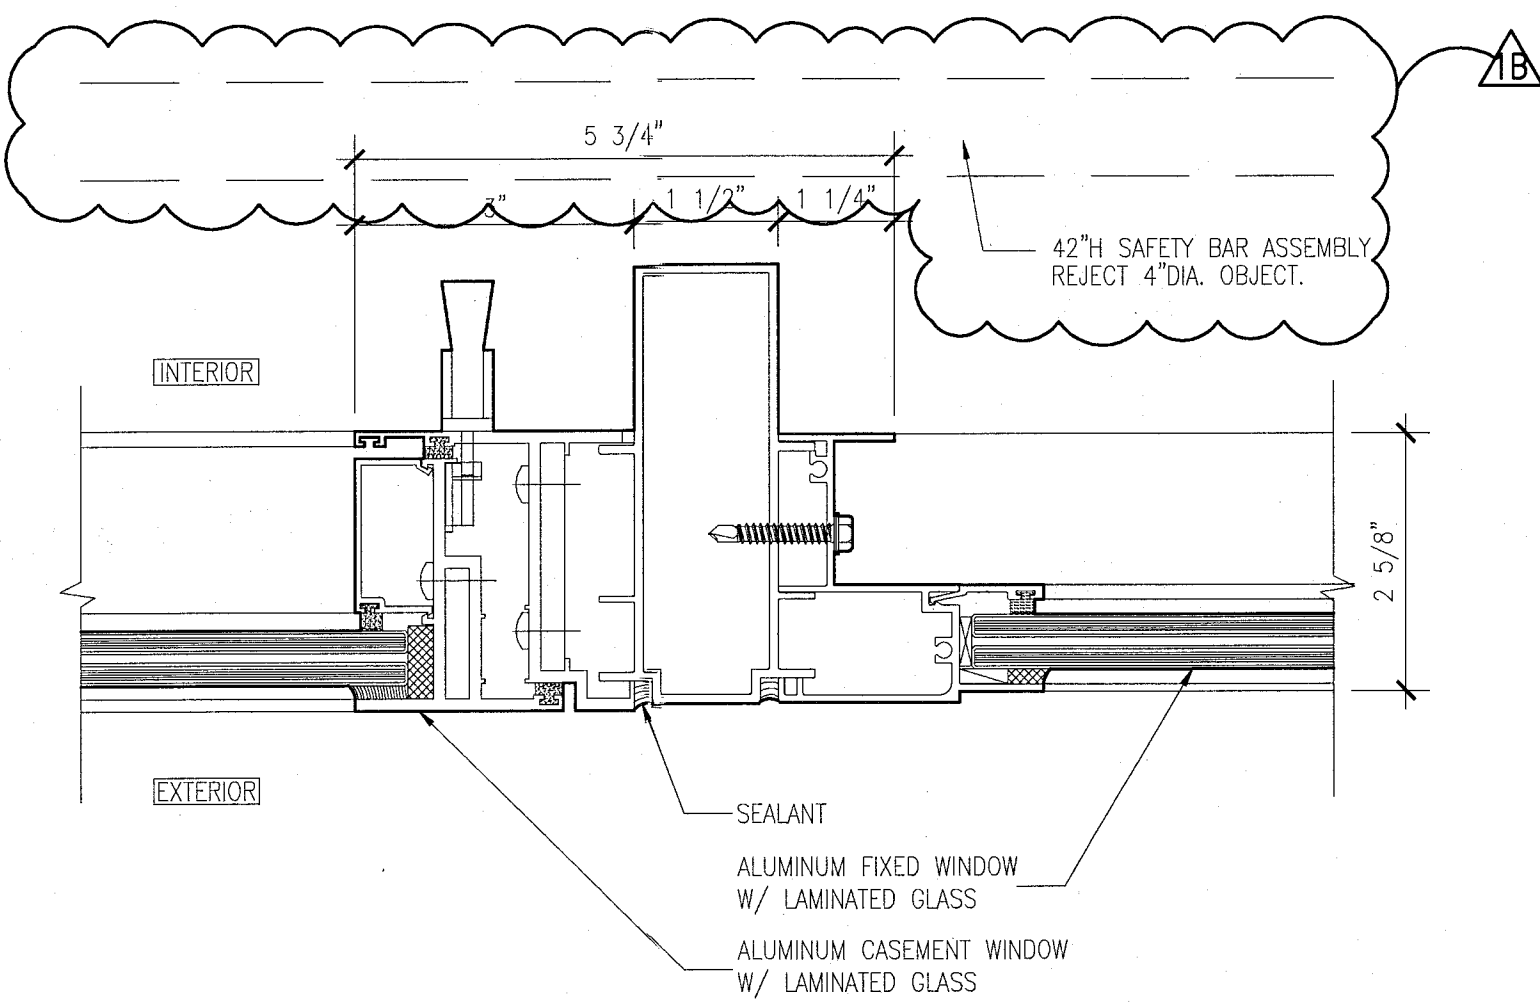


9 JAMB DETAIL AT CASEMENT WINDOWS AND FIXED WINDOWS
SCALE: 6" = 1'-0"

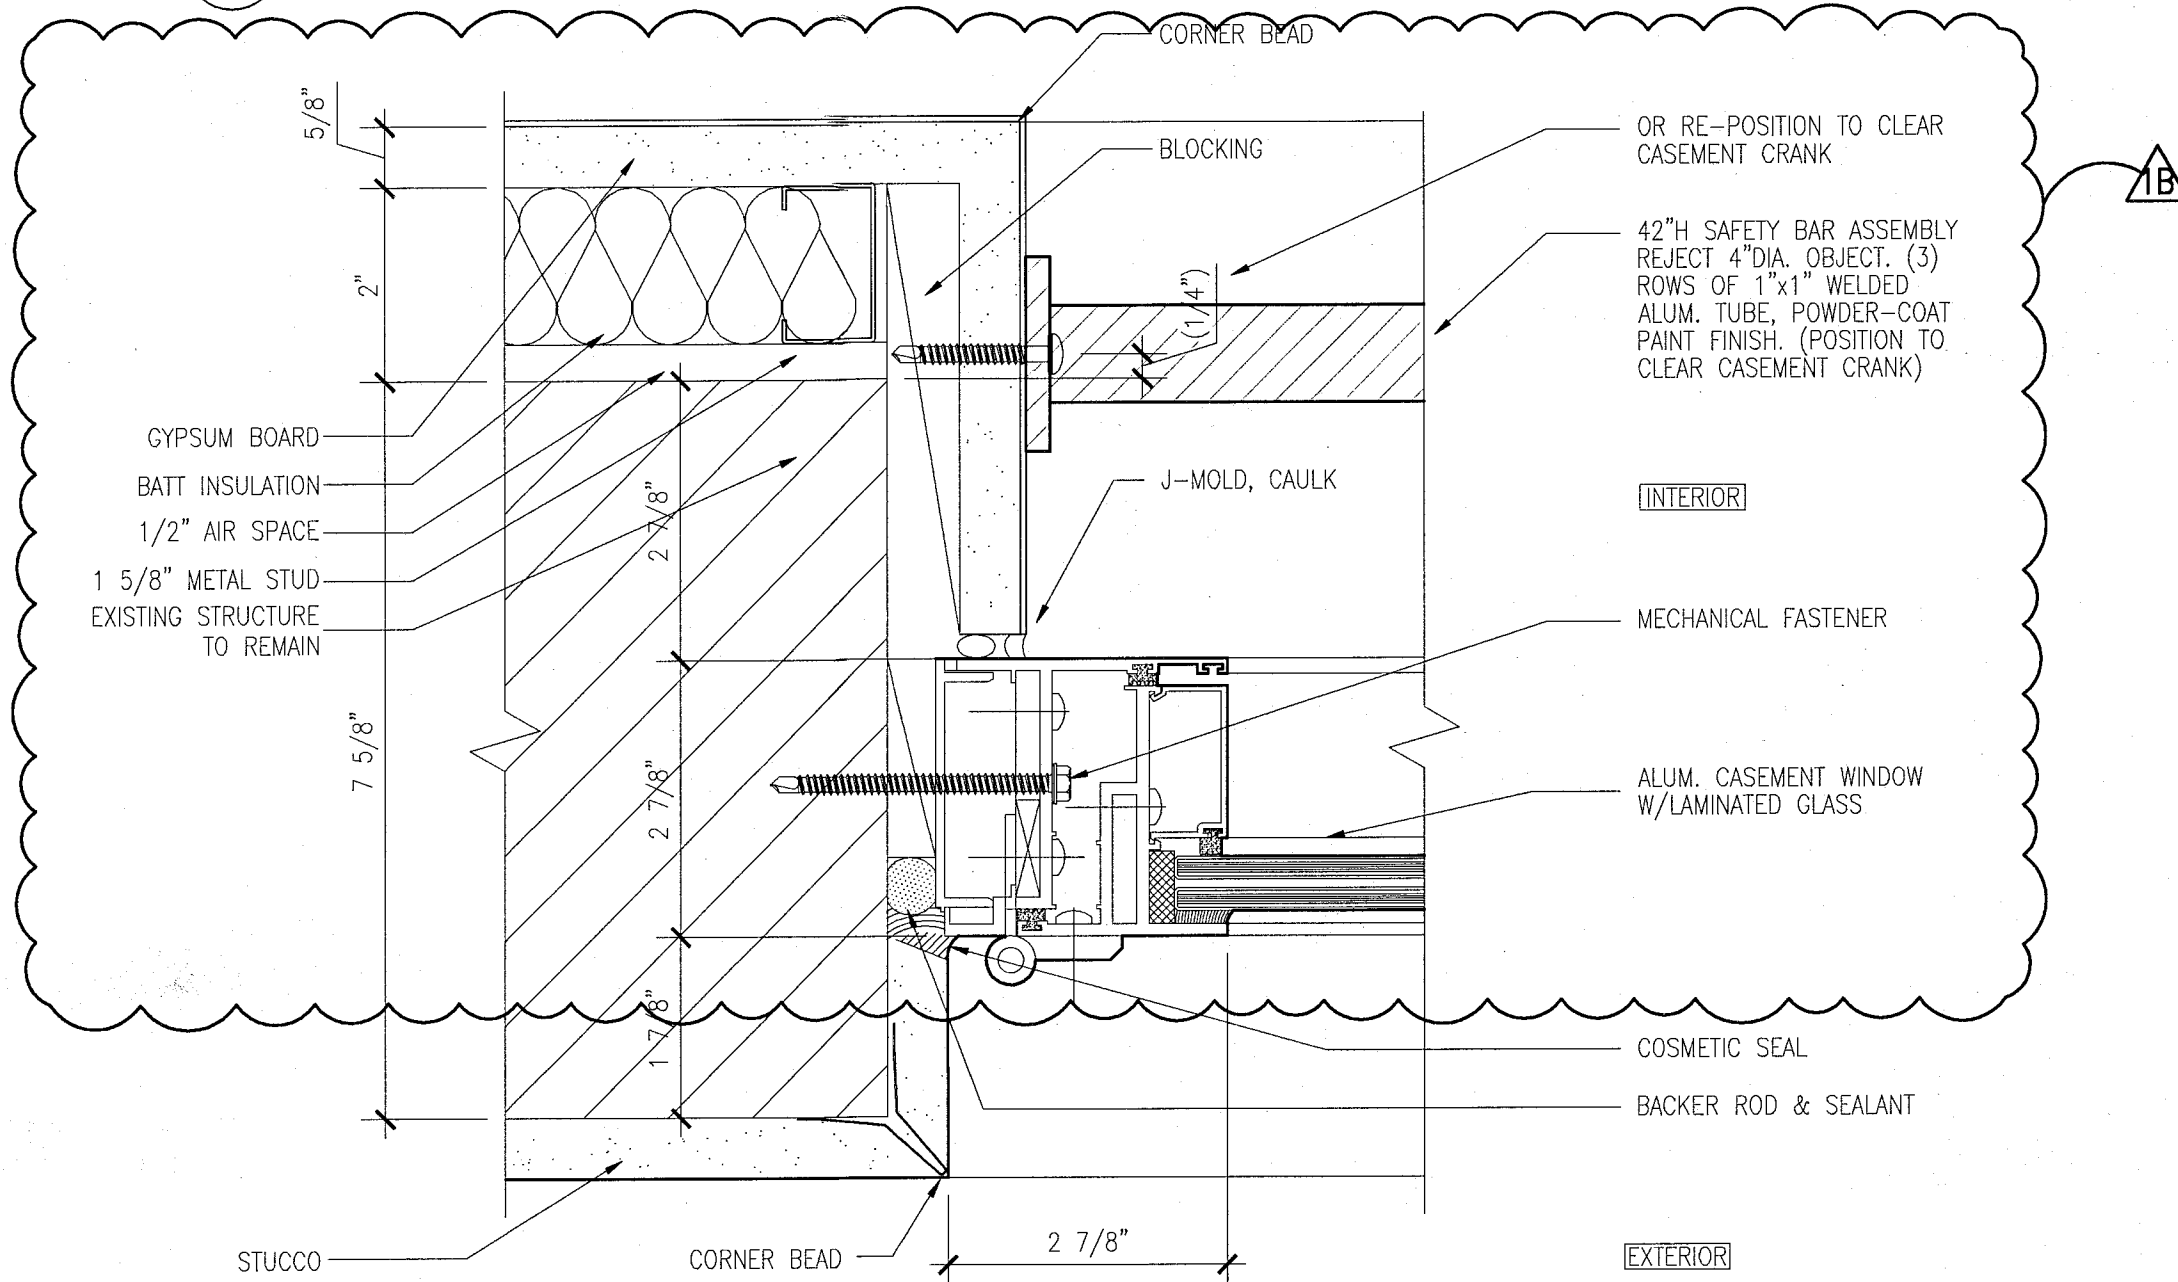


8 JAMB DETAIL AT CASEMENT WINDOWS AND WALL
SCALE: 6" = 1'-0"

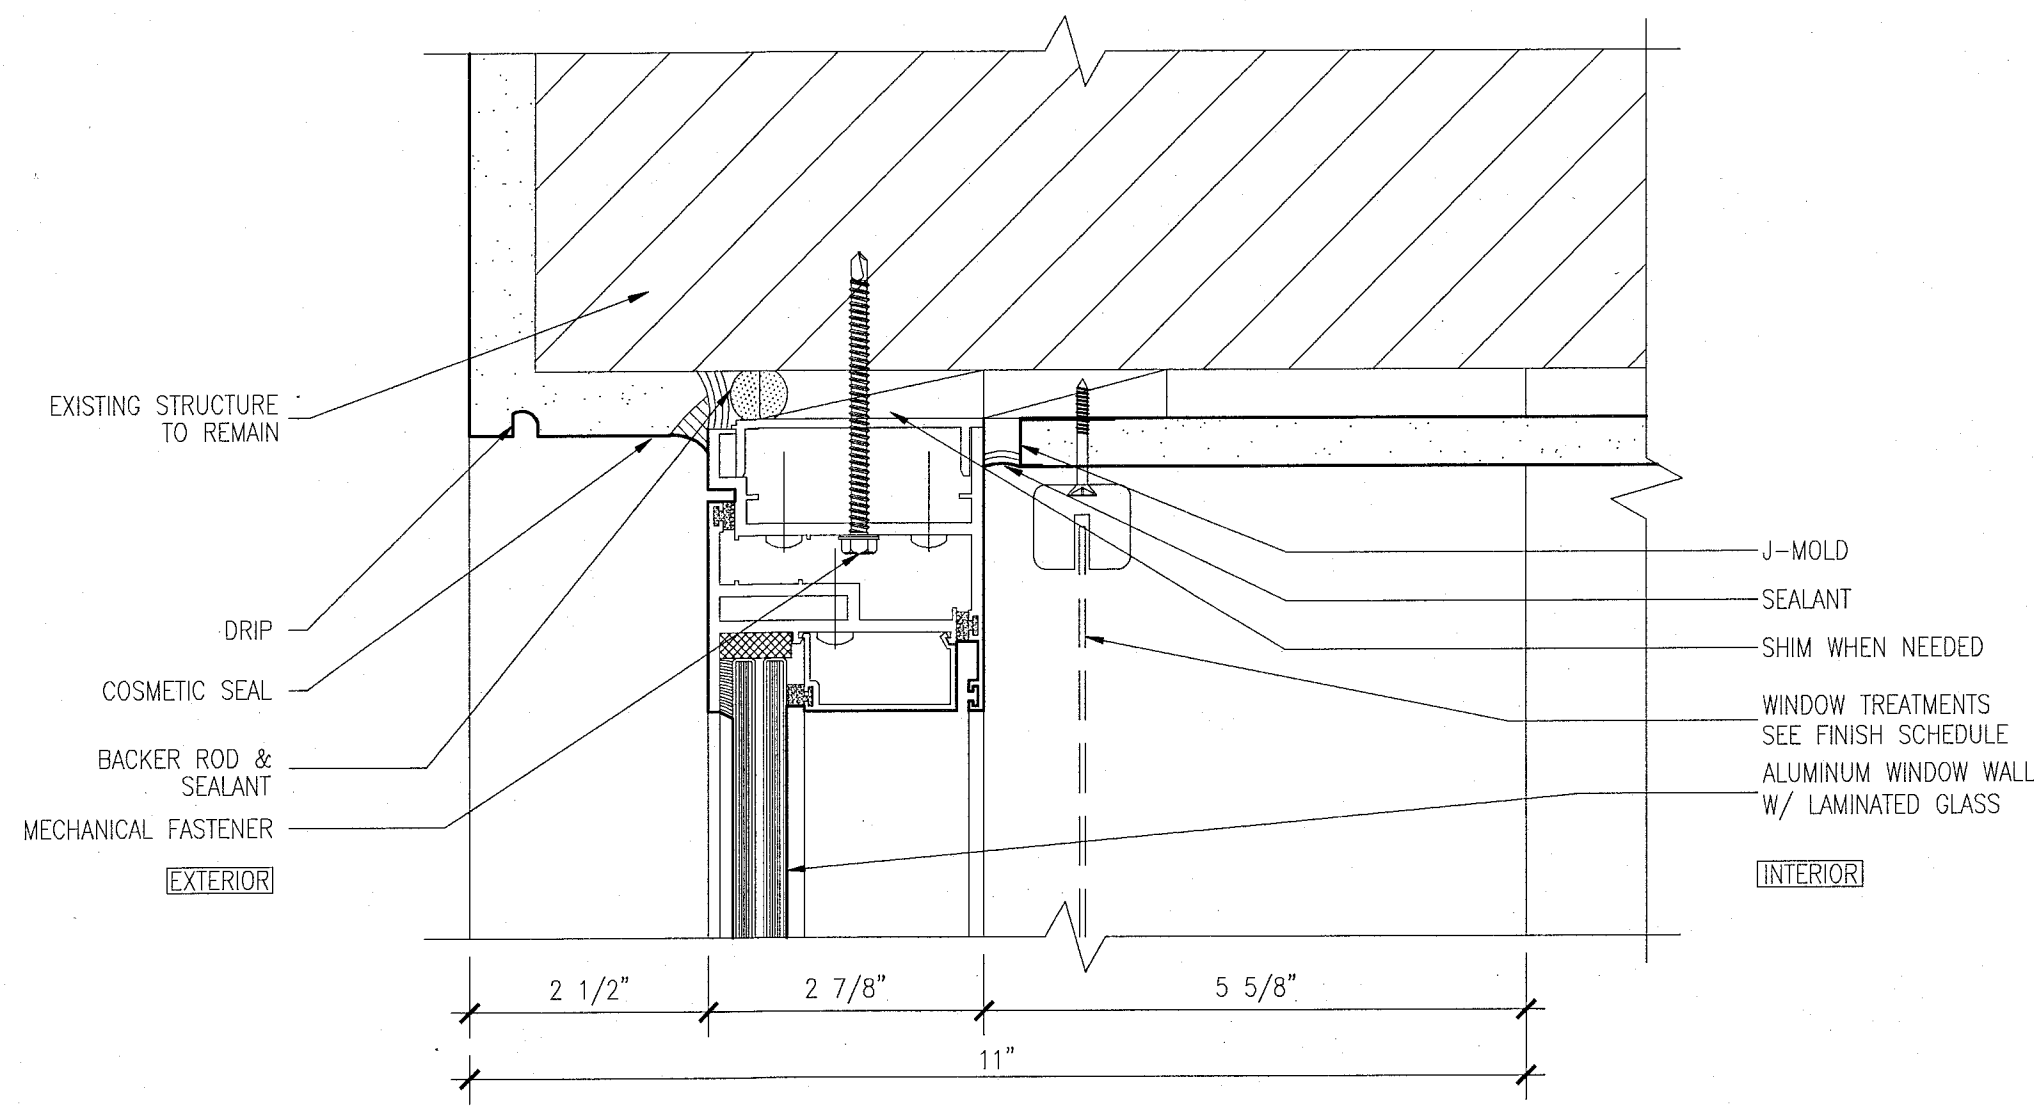


7 HEAD DETAIL AT CASEMENT WINDOWS
SCALE: 6" = 1'-0"

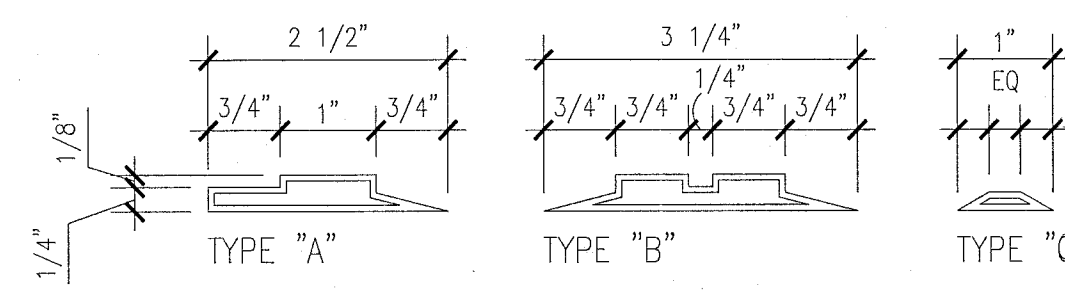


11 WINDOW MUNTIN / EXTRUSION PROFILES
SCALE: N.T.S.

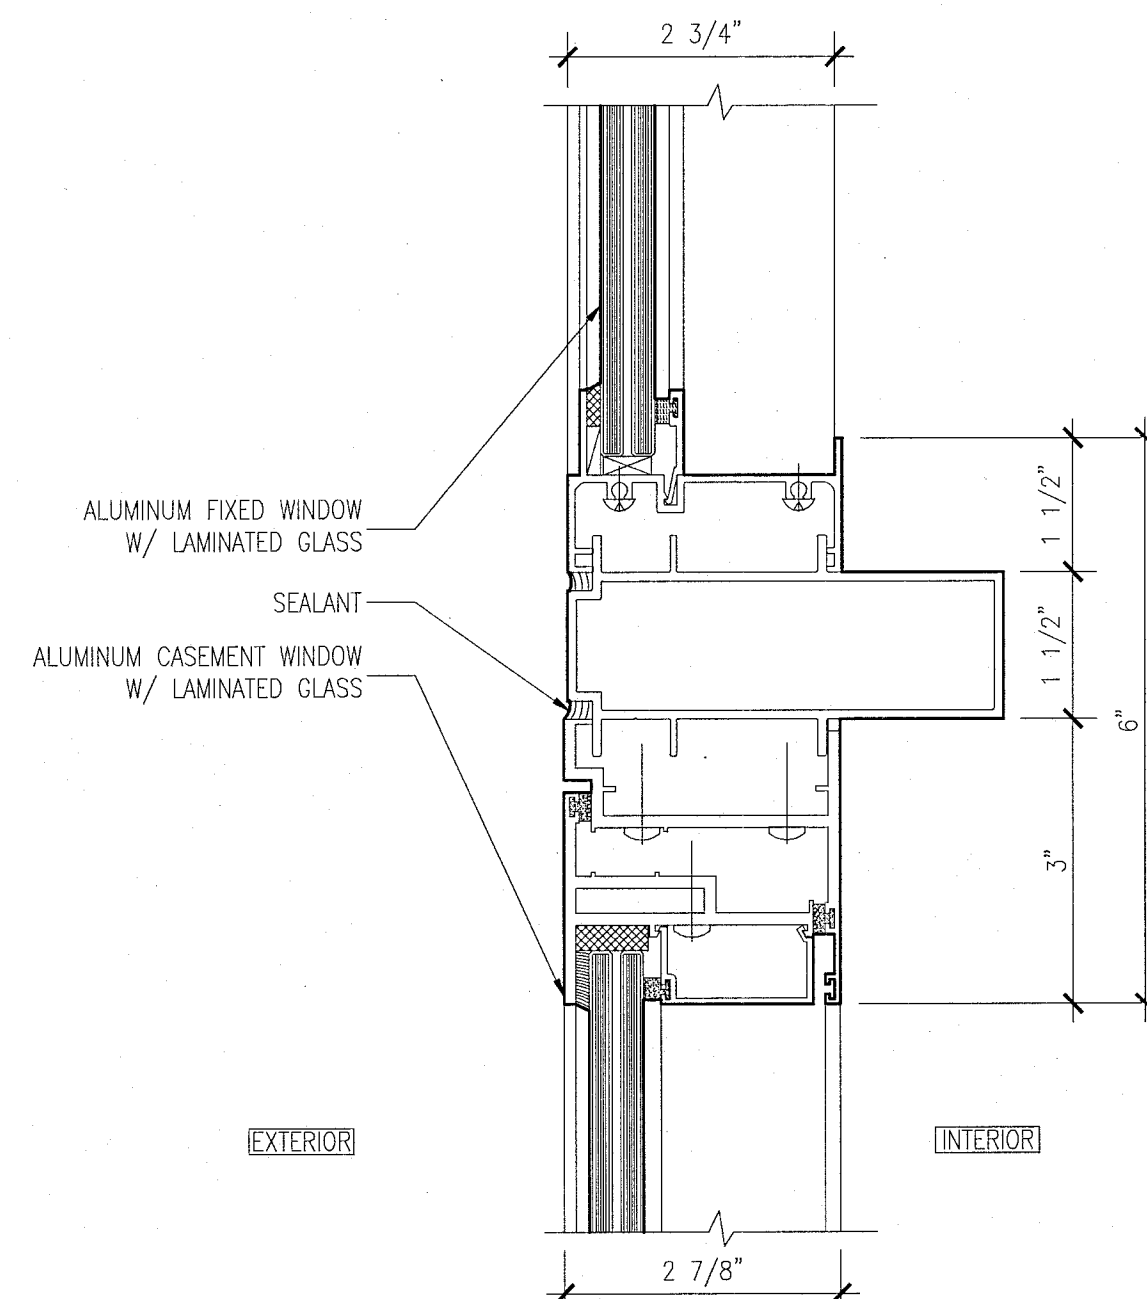


6 HEAD DETAIL AT CASEMENT WINDOWS WITH FIXED TRANSOM
SCALE: 6" = 1'-0"

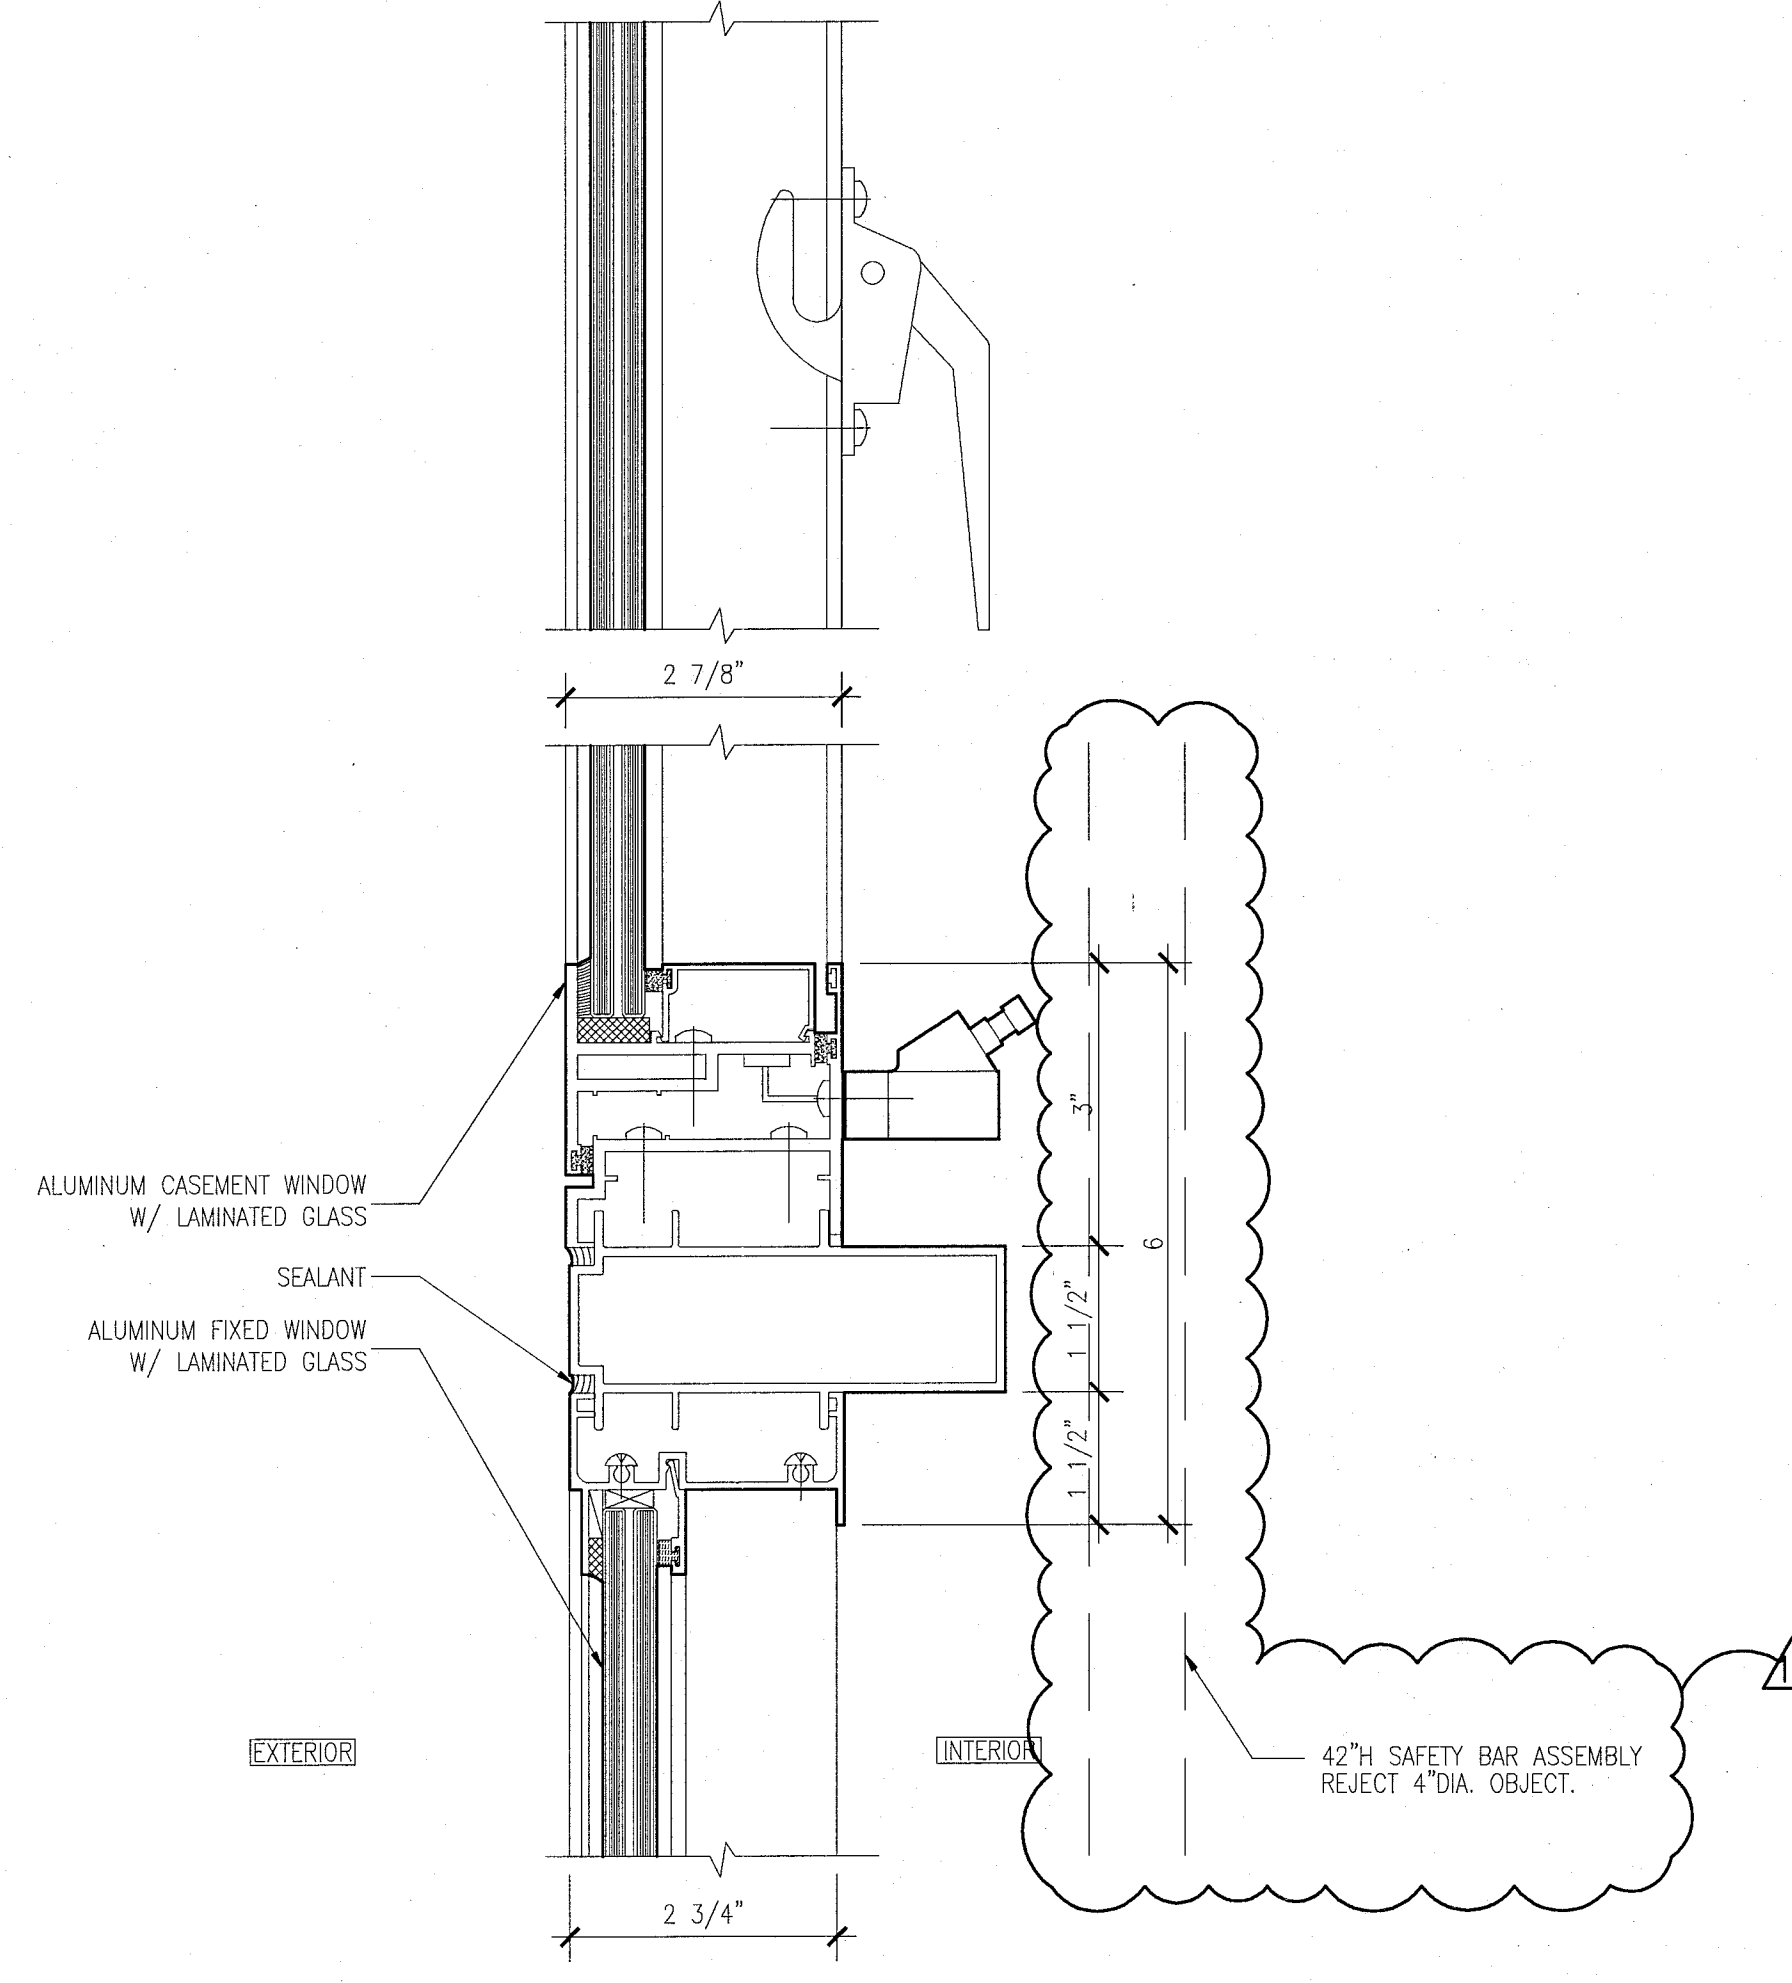


5 SILL AND LOCK DETAIL AT CASEMENT WINDOWS
SCALE: 6" = 1'-0"

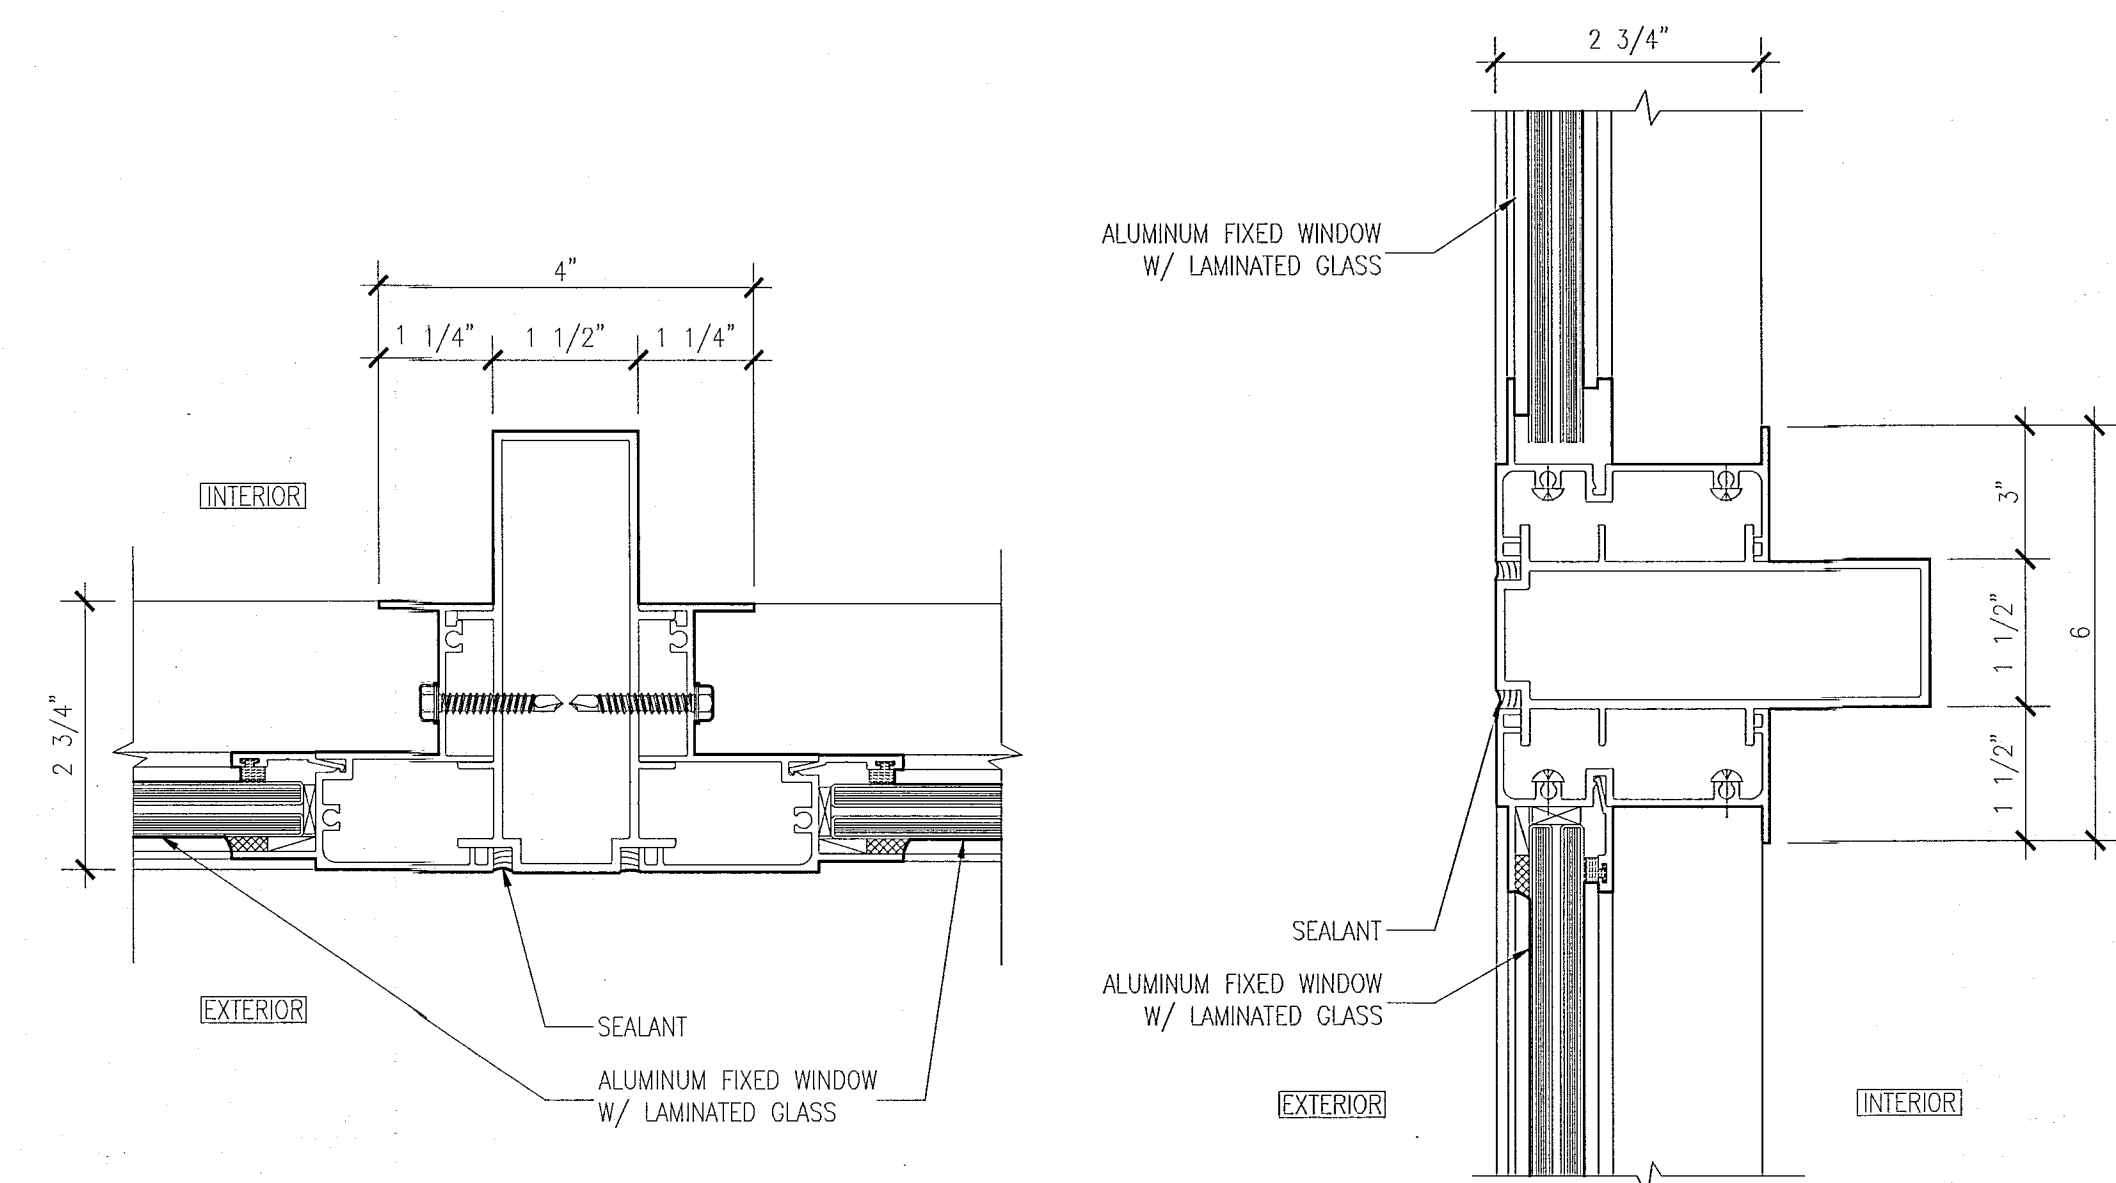


4 MULLION DETAILS AT TWO FIXED WINDOWS
SCALE: 6" = 1'-0"

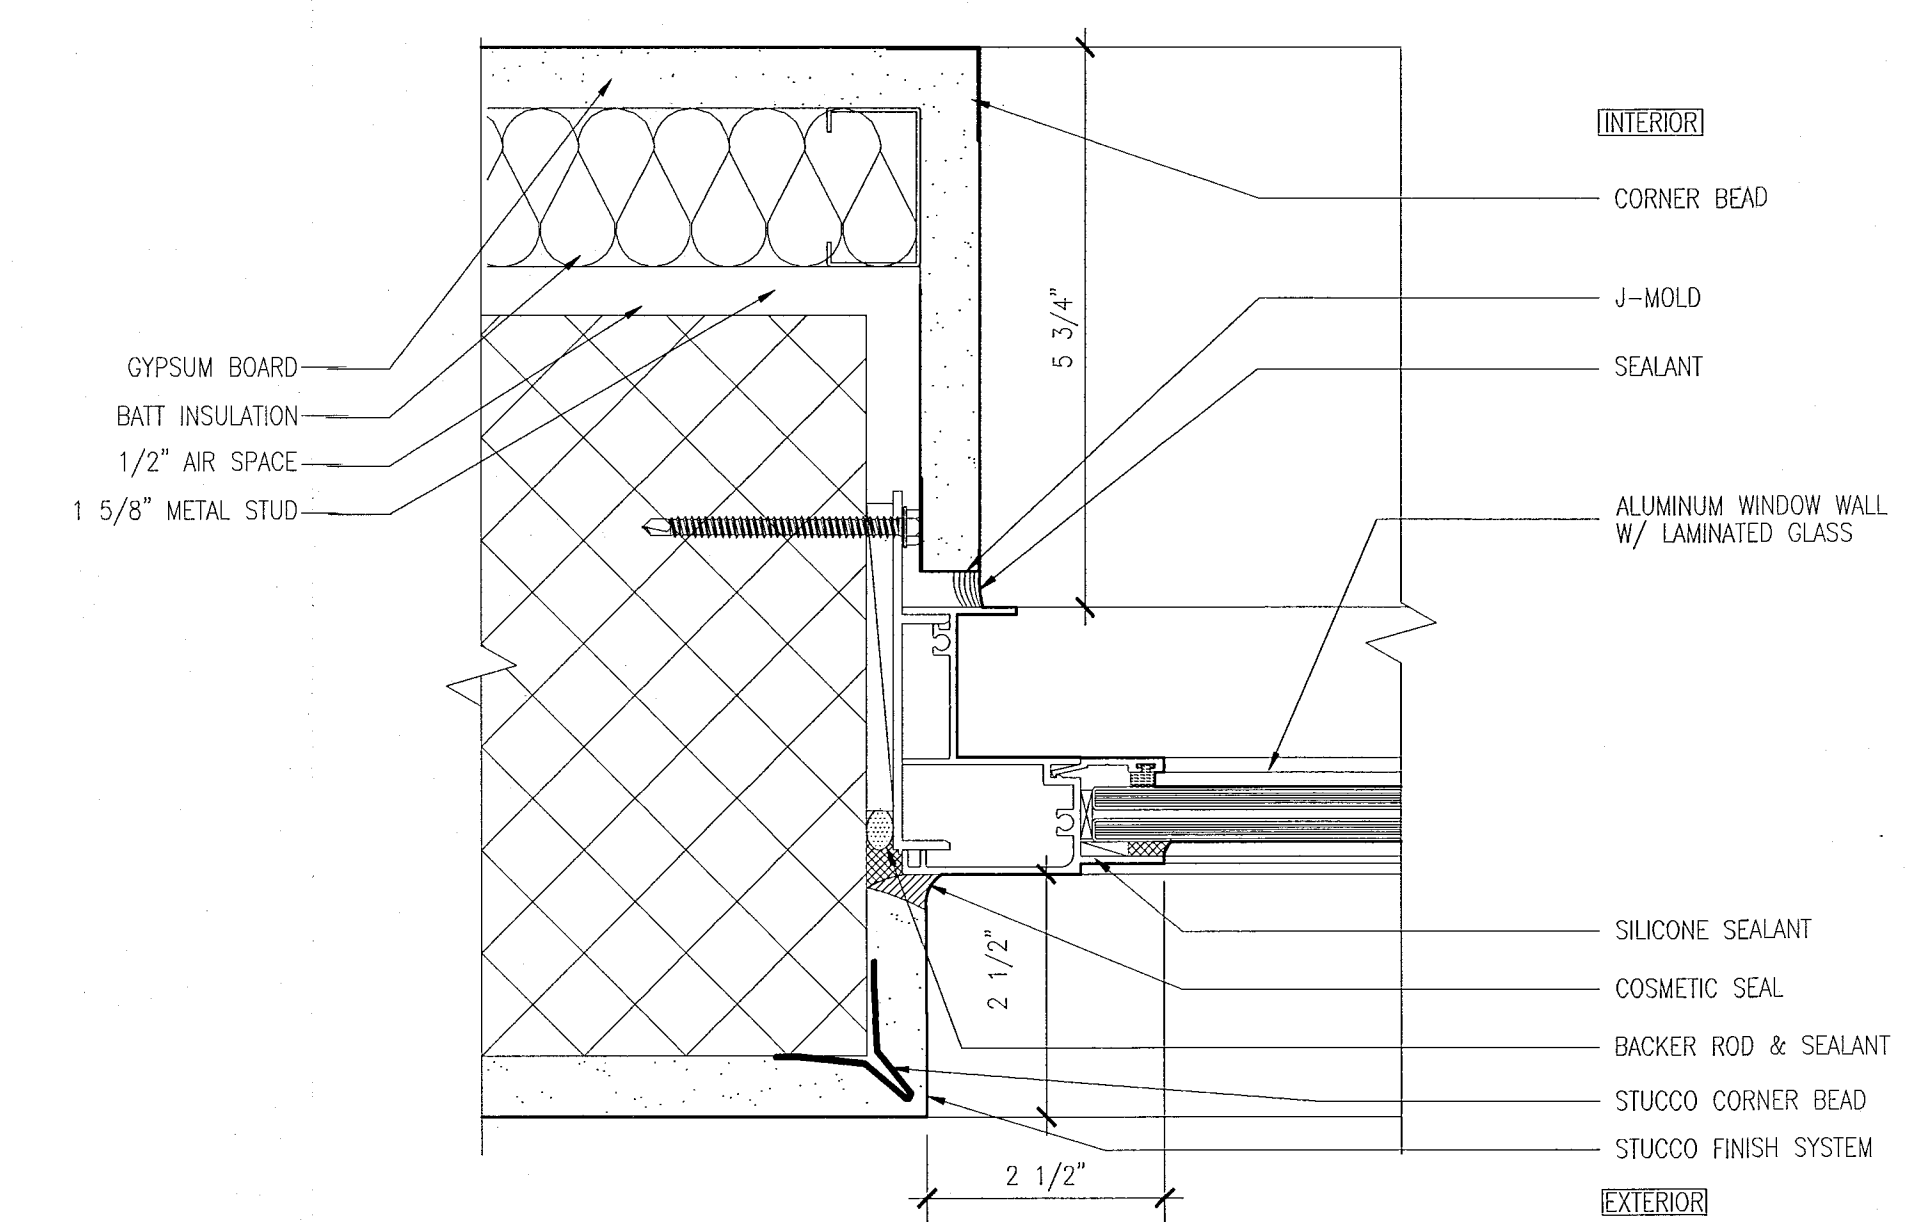

3 JAMB DETAIL AT FIXED WINDOW
SCALE: 6" = 1'-0"

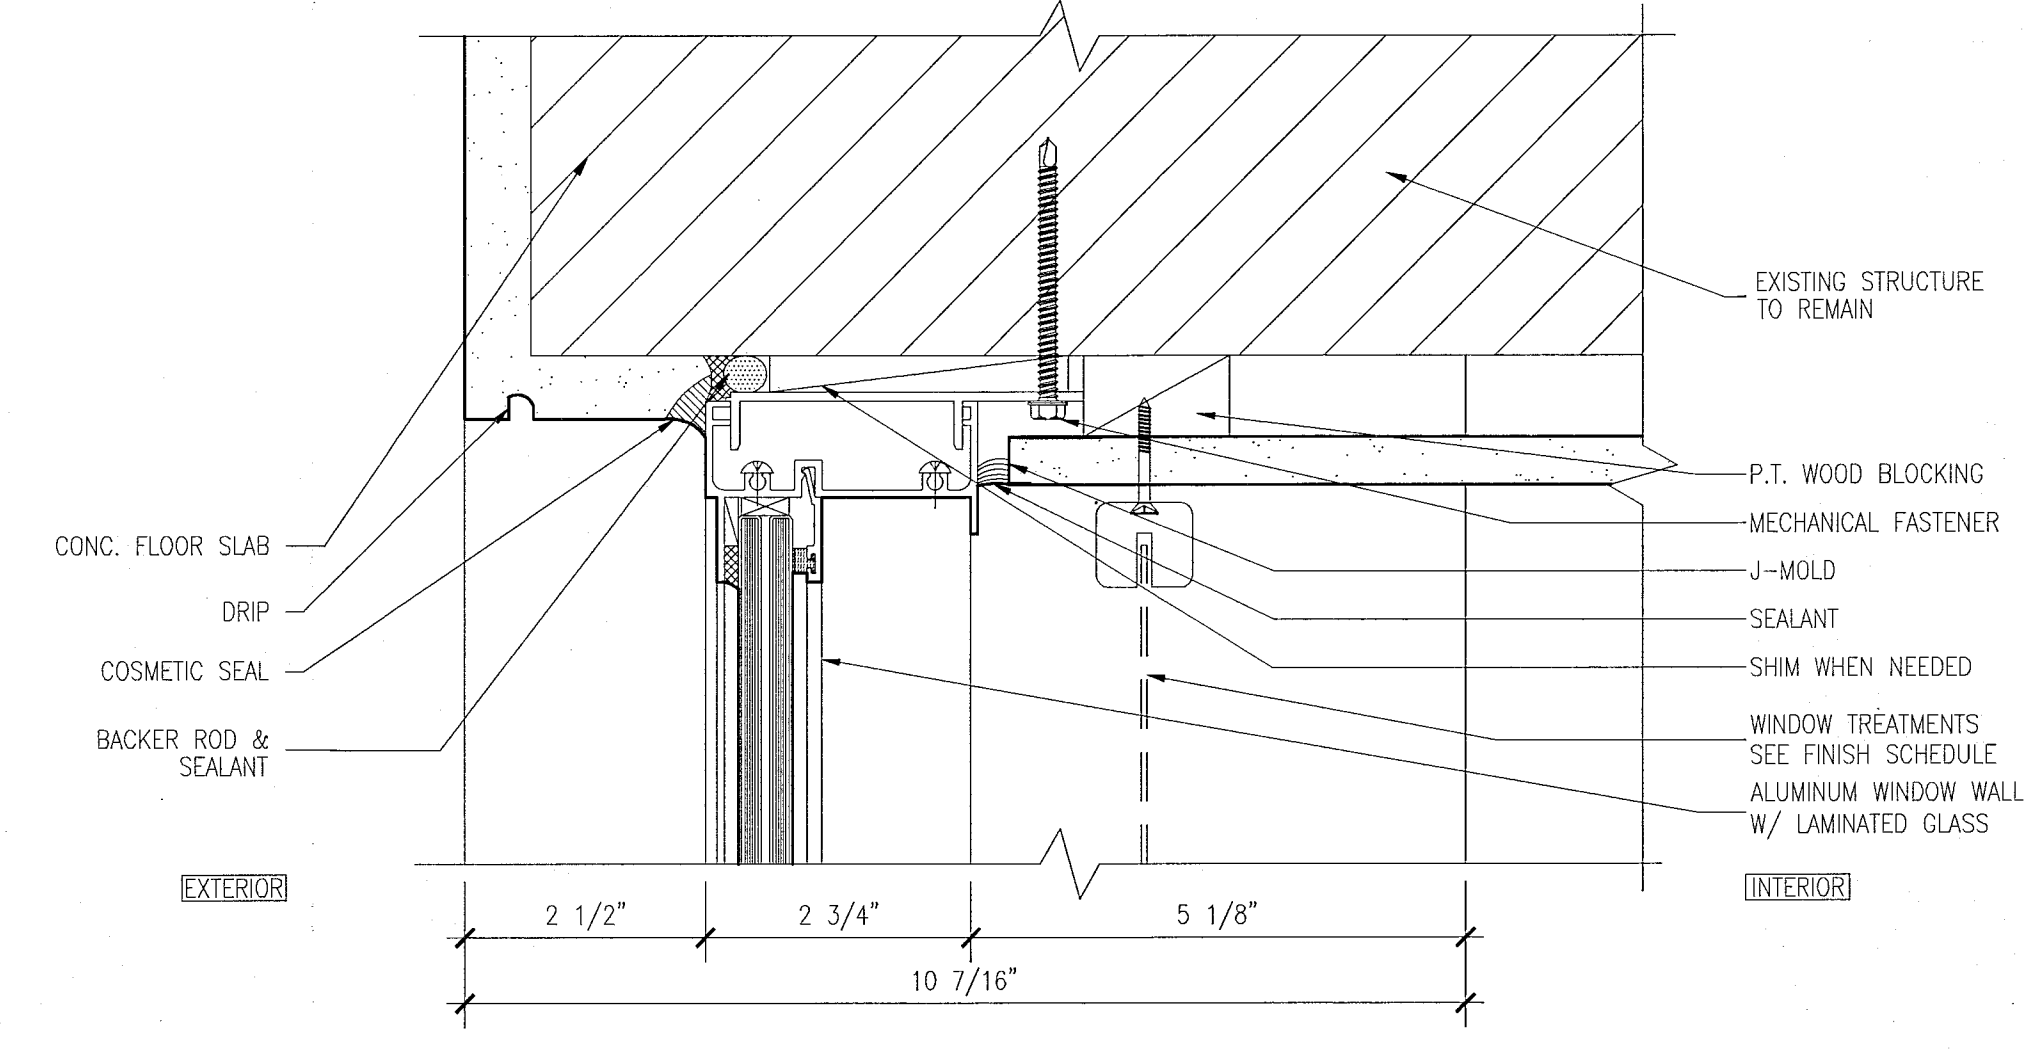

2 HEAD DETAIL AT CASEMENT WINDOWS & FIXED WINDOW
SCALE: 6" = 1'-0"

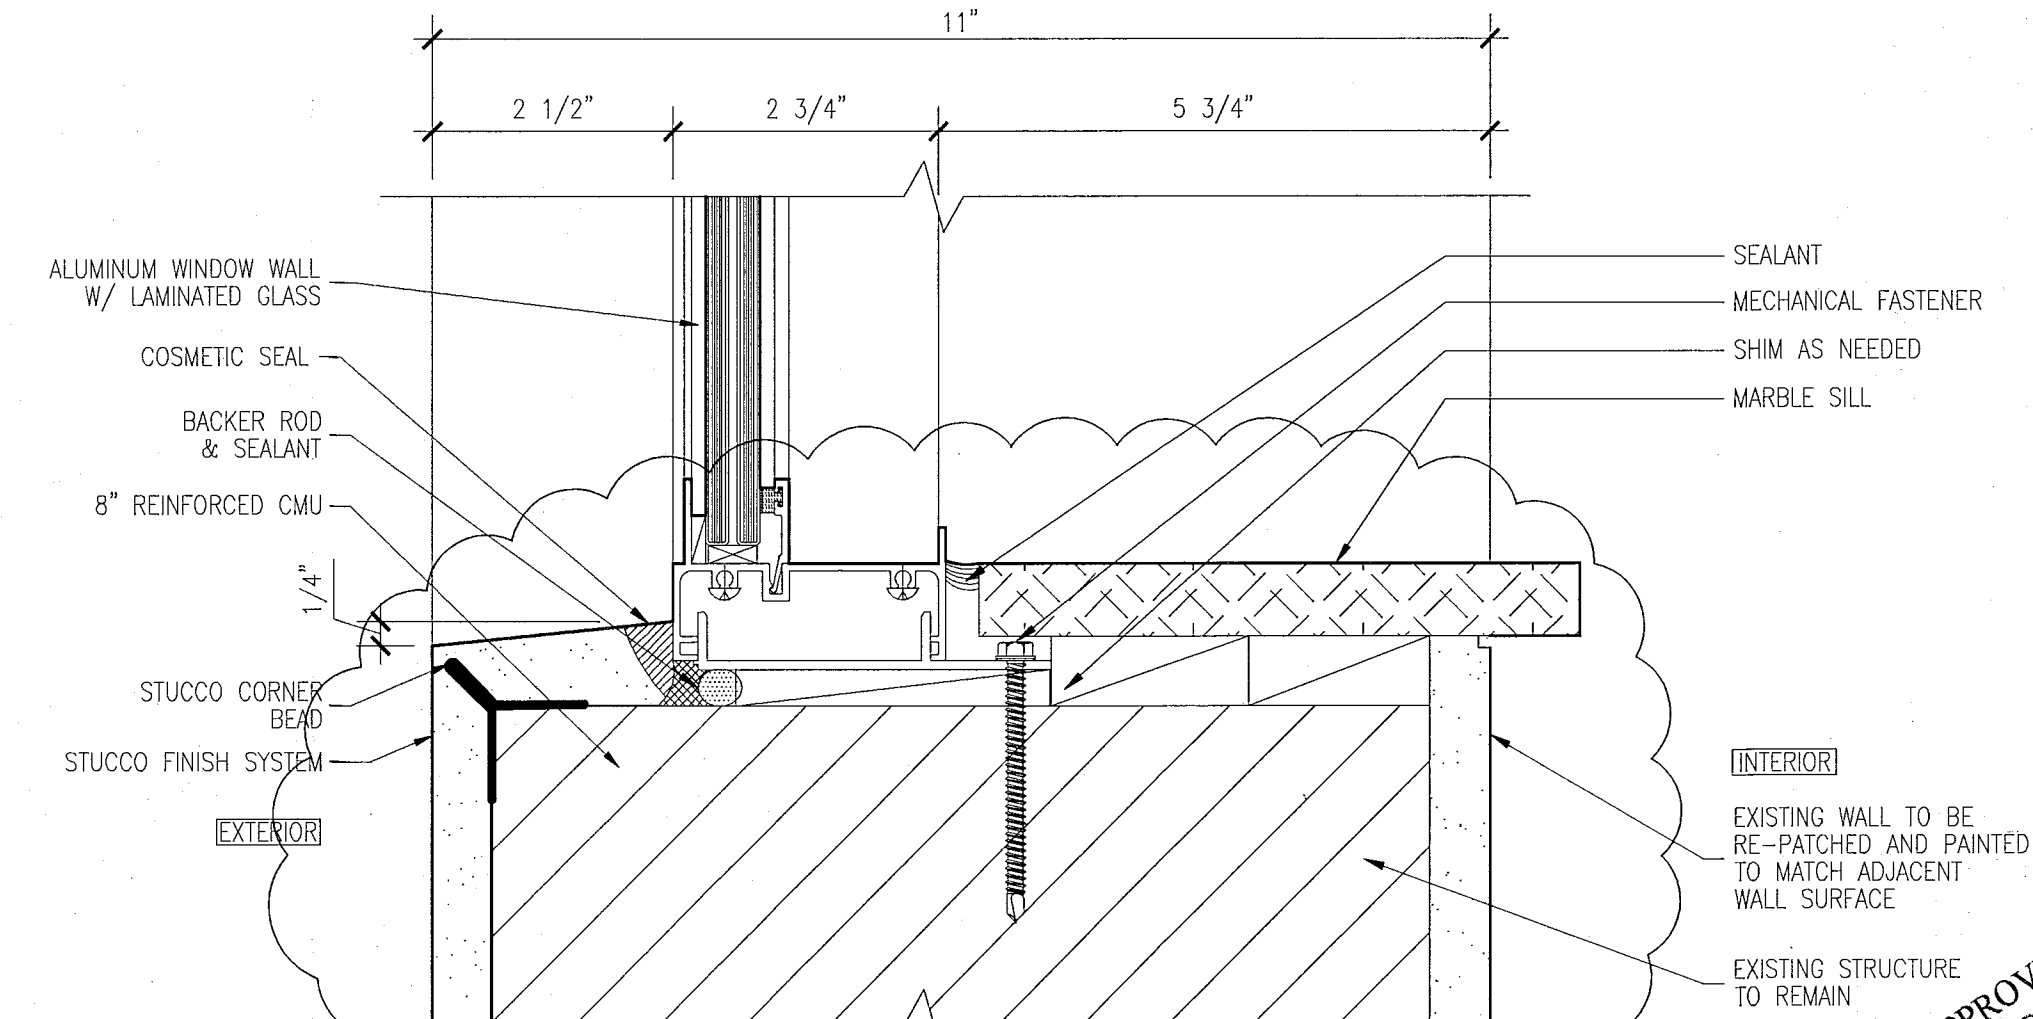

1 SILL DETAIL AT CASEMENT WINDOWS & FIXED WINDOW
SCALE: 6" = 1'-0"

HADDON HALL
1500 COLLINS AVE
MIAMI BEACH, FL

KEYPLAN N.T.S.

REVISIONS		
NO.	DESCRIPTION	ISSUE DATE
1	PROGRESS TO 100% CD	02-18-2014
1A	DOOR-WINDOW COORD.	03-5-2014

MTCI PRIVATE PROVIDER SERVICES, LLC		
BUILDING	REVIEWER INITIALS	DATE REVIEWED
STRUCTURAL	FM	11-10-14
MECHANICAL		
ELECTRICAL		
PLUMBING		
SITE CIVIL		

100% CONSTRUCTION DOCUMENT SET

ADD Inc Architecture Interiors Planning

One Biscayne Tower
Suite 1670
Two South
Biscayne Boulevard
Miami, FL 33131
T. 305.482.8700
F. 305.482.8770
www.addinc.com
Lic. # AA26001507

JOB NUMBER: 13036.00
CHECKED BY:
ISSUE DATE: FEBRUARY 18, 2014
SCALE: AS NOTED

SHEET TITLE

WINDOW AND STOREFRONT DETAILS

SHEET NUMBER

A432

COPYRIGHT ADD INC 2011

HADDON HALL
1500 COLLINS AVE
MIAMI BEACH, FL

KEYPLAN N.T.S.

REVISIONS		
NO.	DESCRIPTION	ISSUE DATE

REVIEWER INITIALS			DATE
BUILDING	FM	REVIEWED	11-18-17
STRUCTURAL			
MECHANICAL			
ELECTRICAL			
PLUMBING			
SITE CIVIL			

PERMIT SET

SEAL

Jonathan Cardello
Lic. # AR93391

ADD Inc Architecture Interiors Planning

One Biscayne Tower
Suite 1670
Two South
Biscayne Boulevard
Miami, FL 33151
T. 305.482.8700
F. 305.482.8770
www.addinc.com
Lic. # AA20001507

JOB NUMBER: 13036.00
CHECKED BY:
ISSUE DATE: JANUARY 24, 2014
SCALE: AS NOTED


SHEET TITLE

WINDOW AND
STOREFRONT
DETAILS


SHEET NUMBER

A433


COPYRIGHT ADD INC 2011

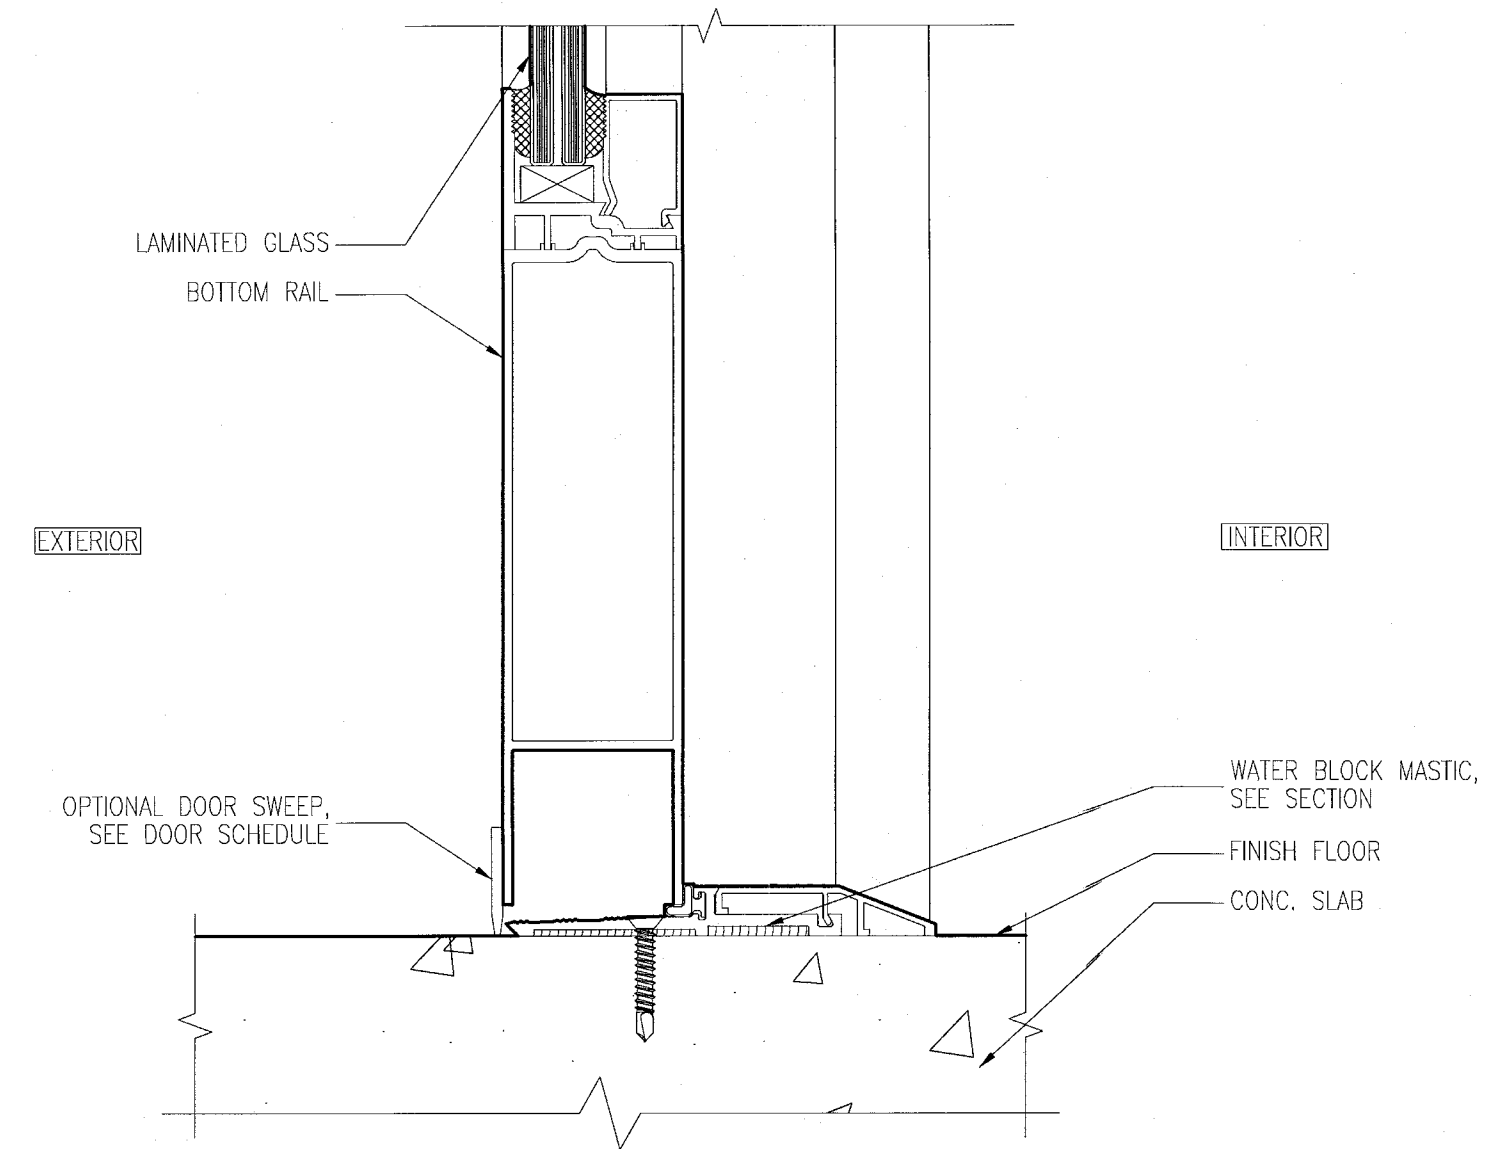


8 SILL DETAIL AT SWINGING DOOR
SCALE: 6" = 1'-0"

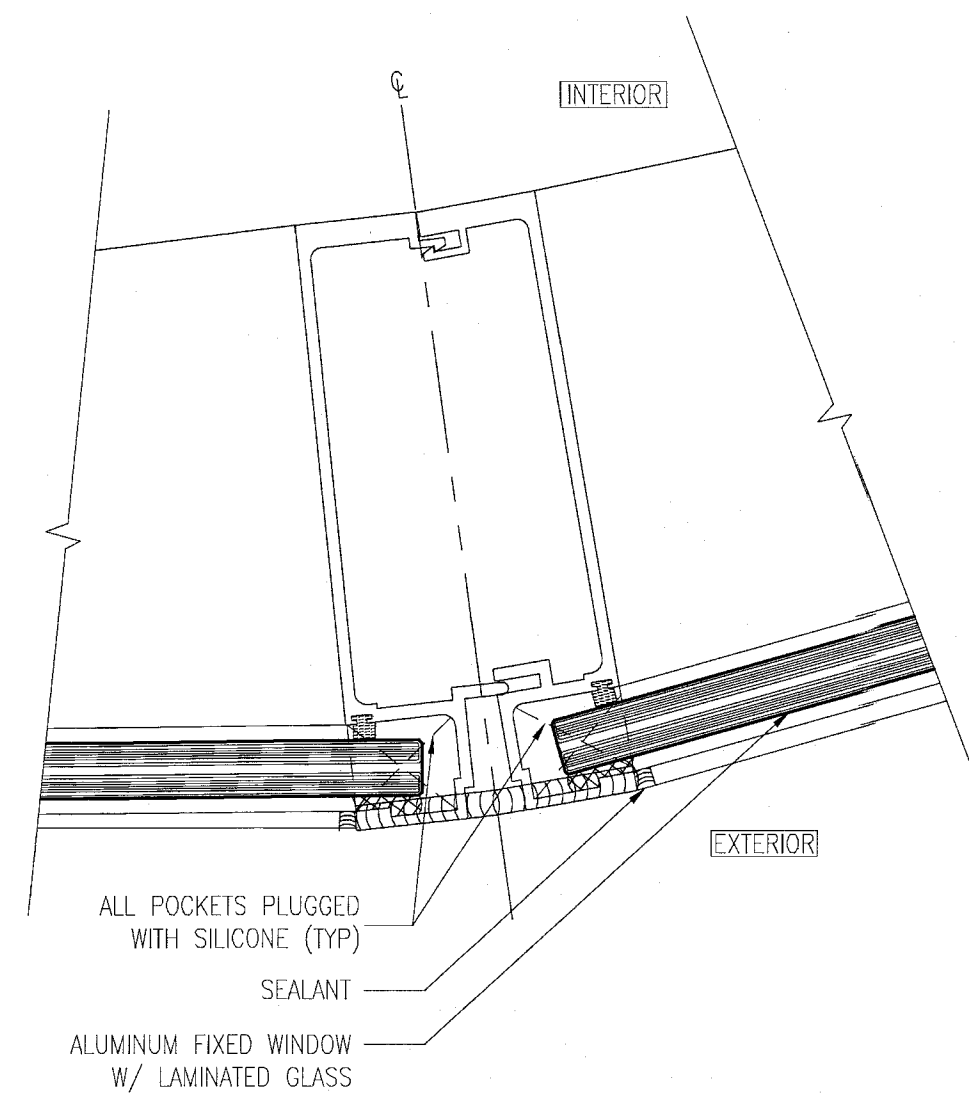


7 WINDOW WALL @ CURVED HADDON HALL CORNER UNIT
SCALE: 6" = 1'-0"

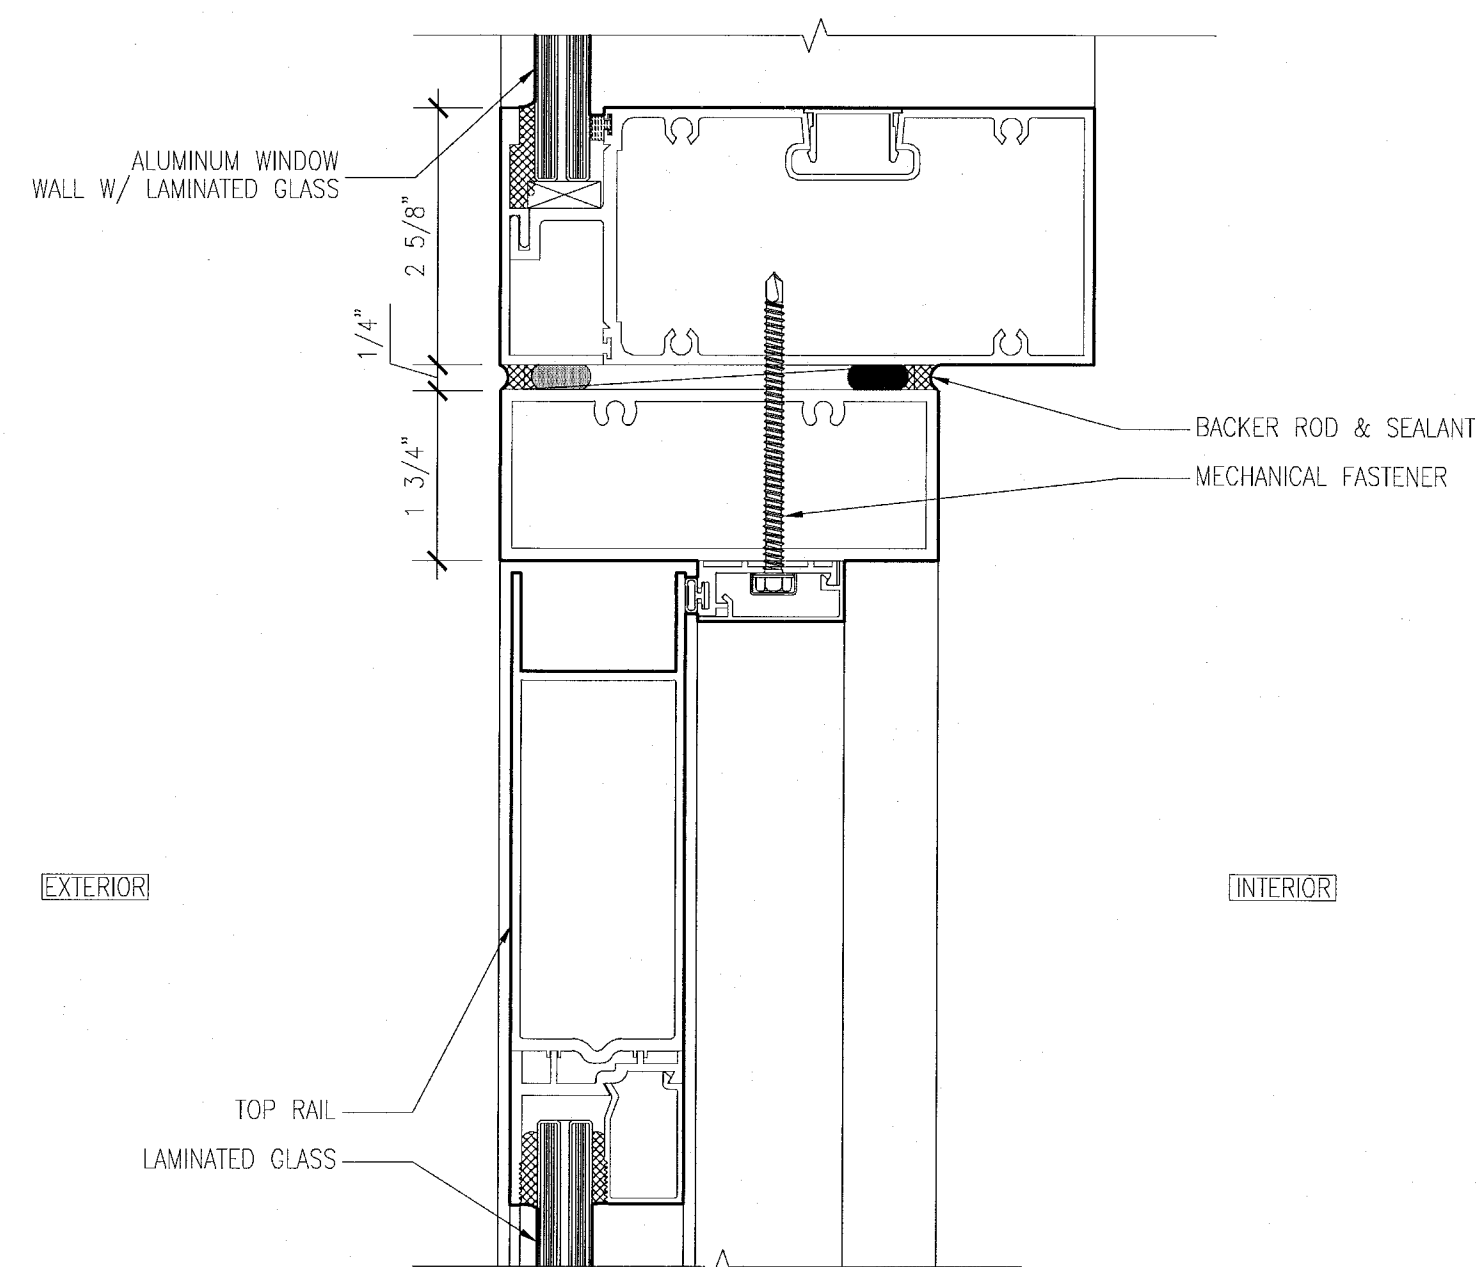


9 HEAD DETAIL AT SWINGING DOOR
SCALE: 6" = 1'-0"

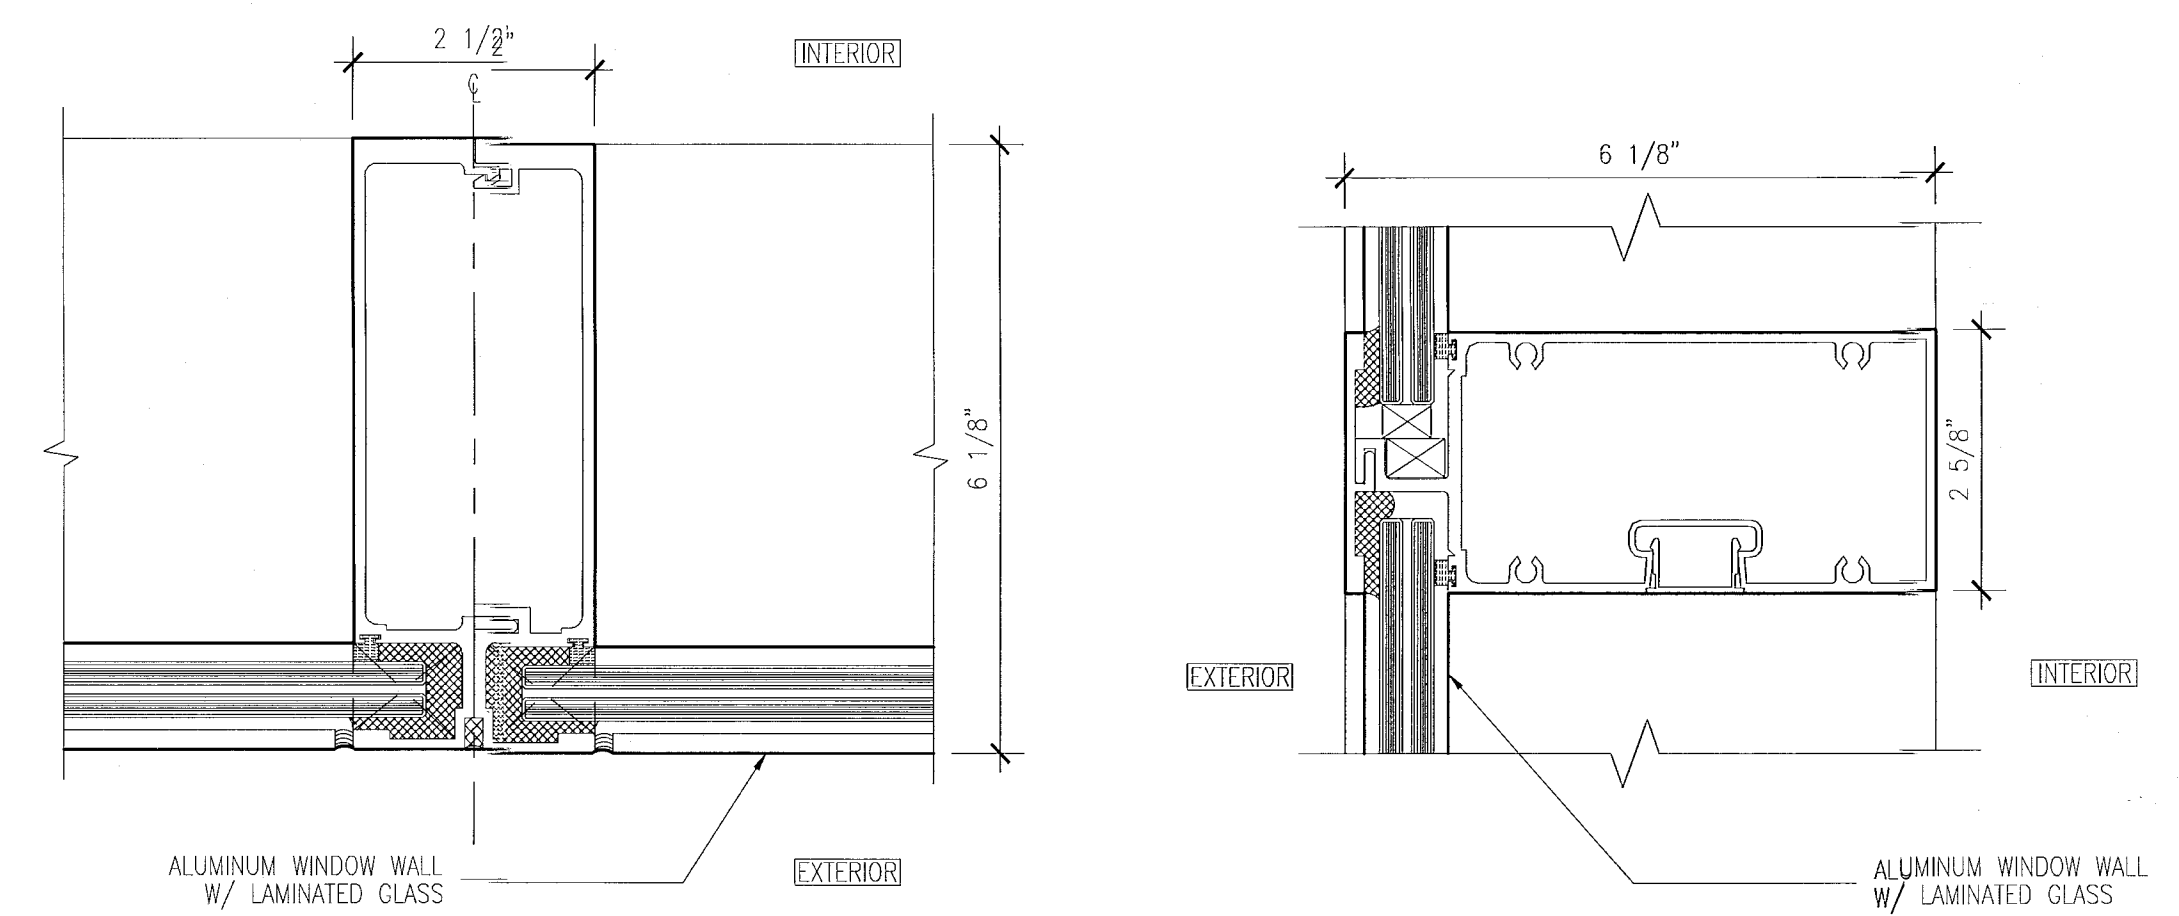


4 MULLION DETAIL AT WINDOW WALL
SCALE: 6" = 1'-0"

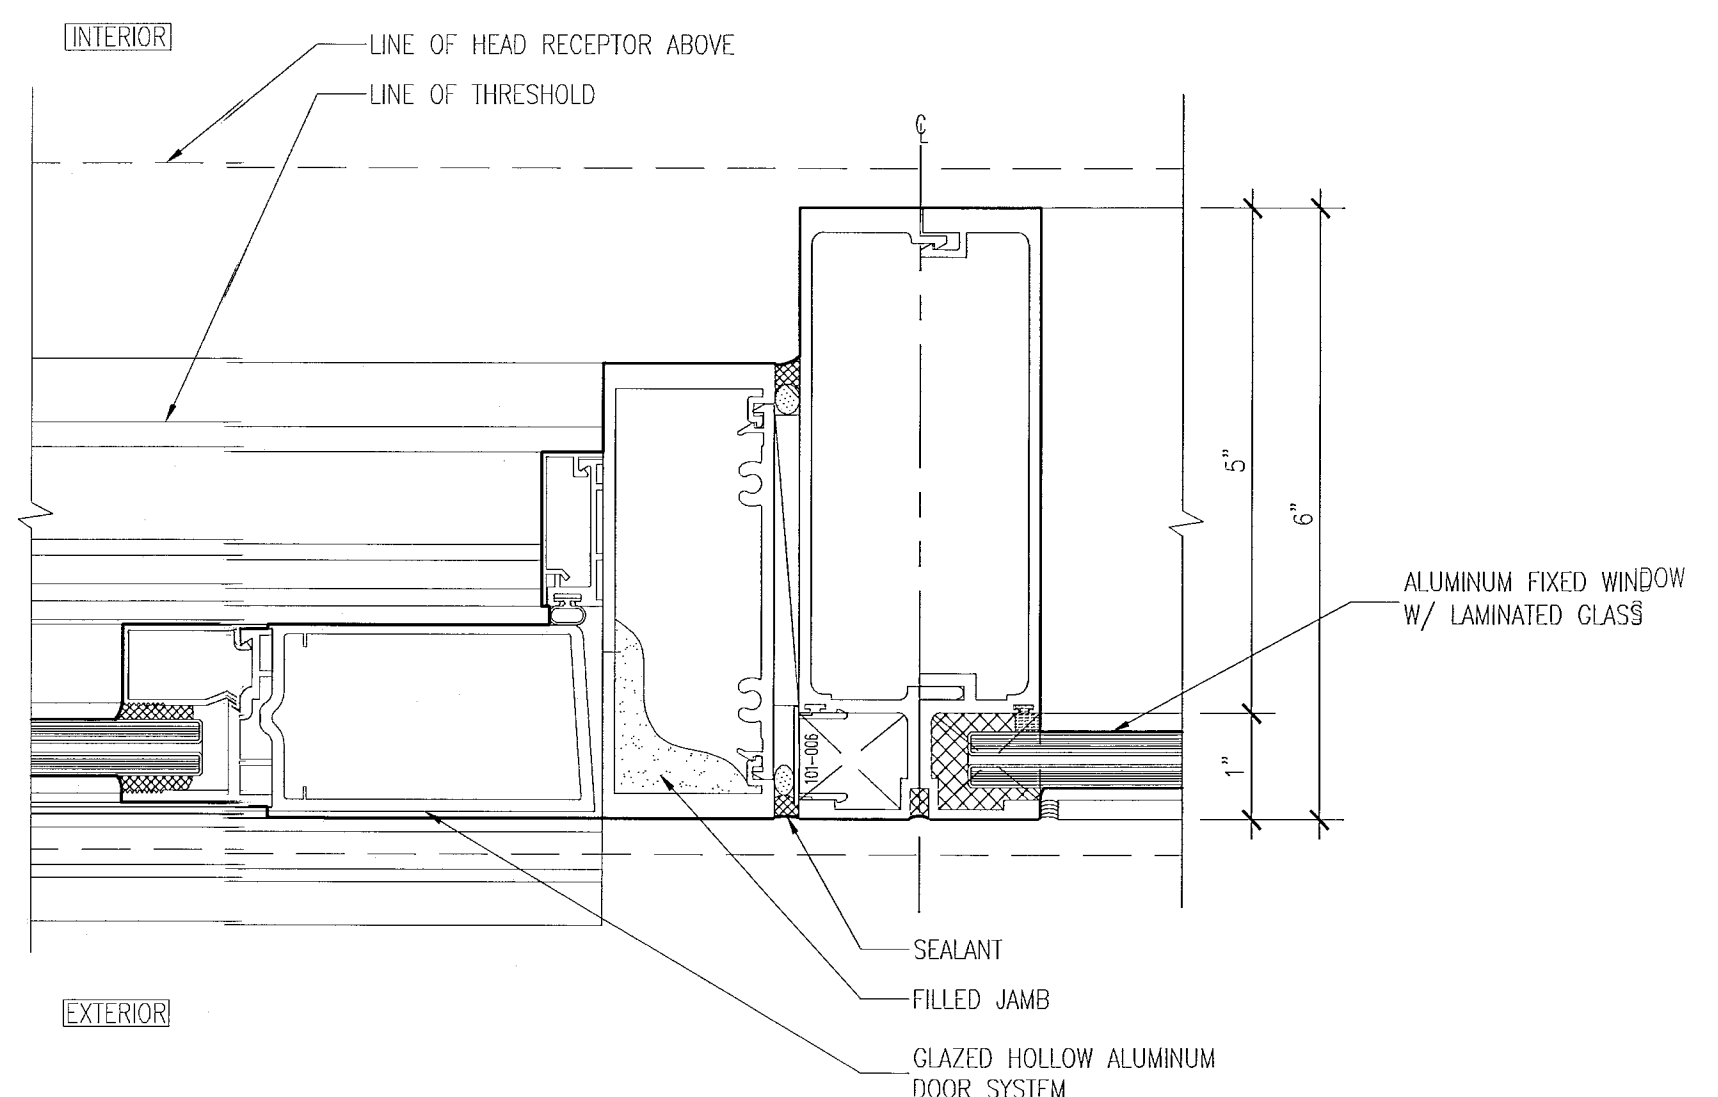

3 SWINGING DOOR AND FIXED WINDOW
SCALE: 6" = 1'-0"

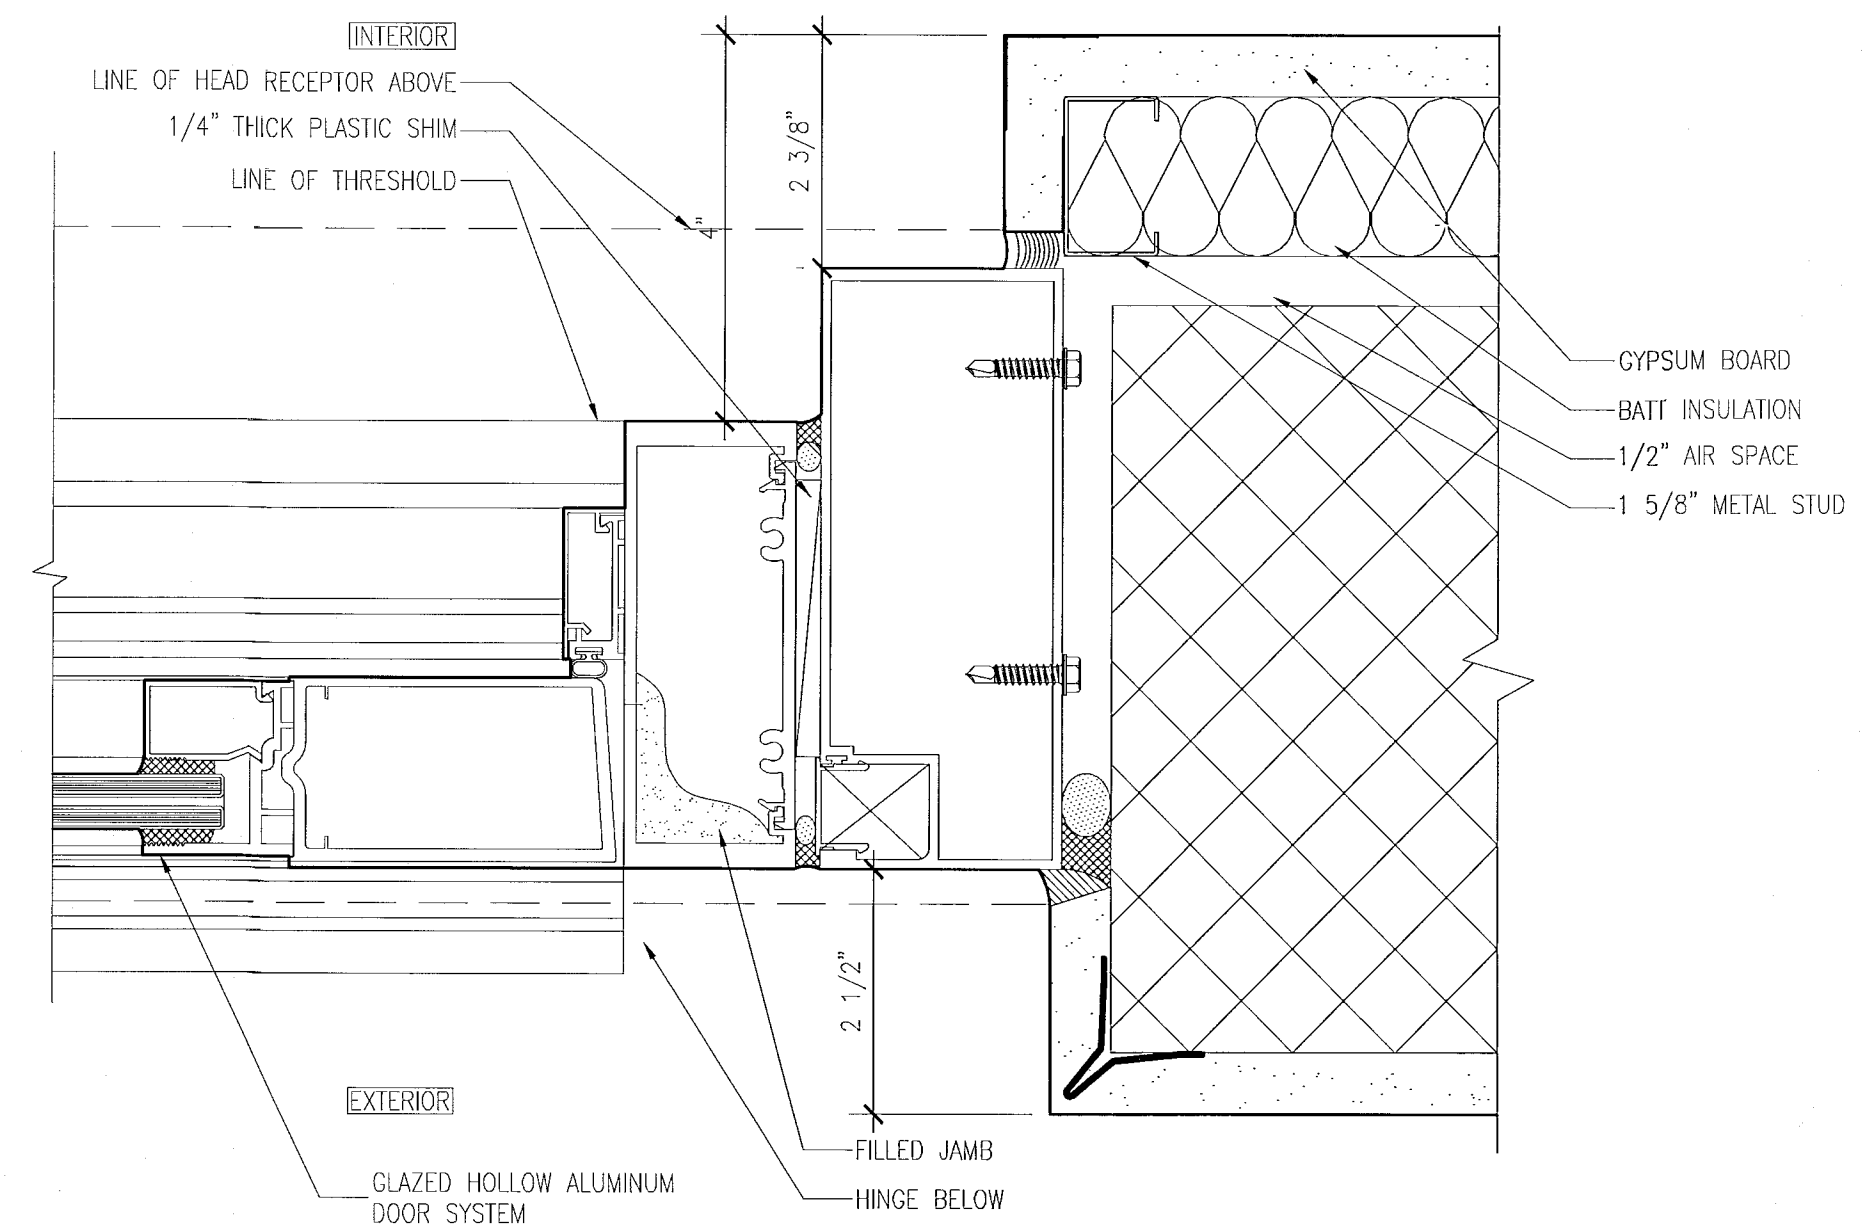

2 SWINGING DOOR JAMB
SCALE: 6" = 1'-0"

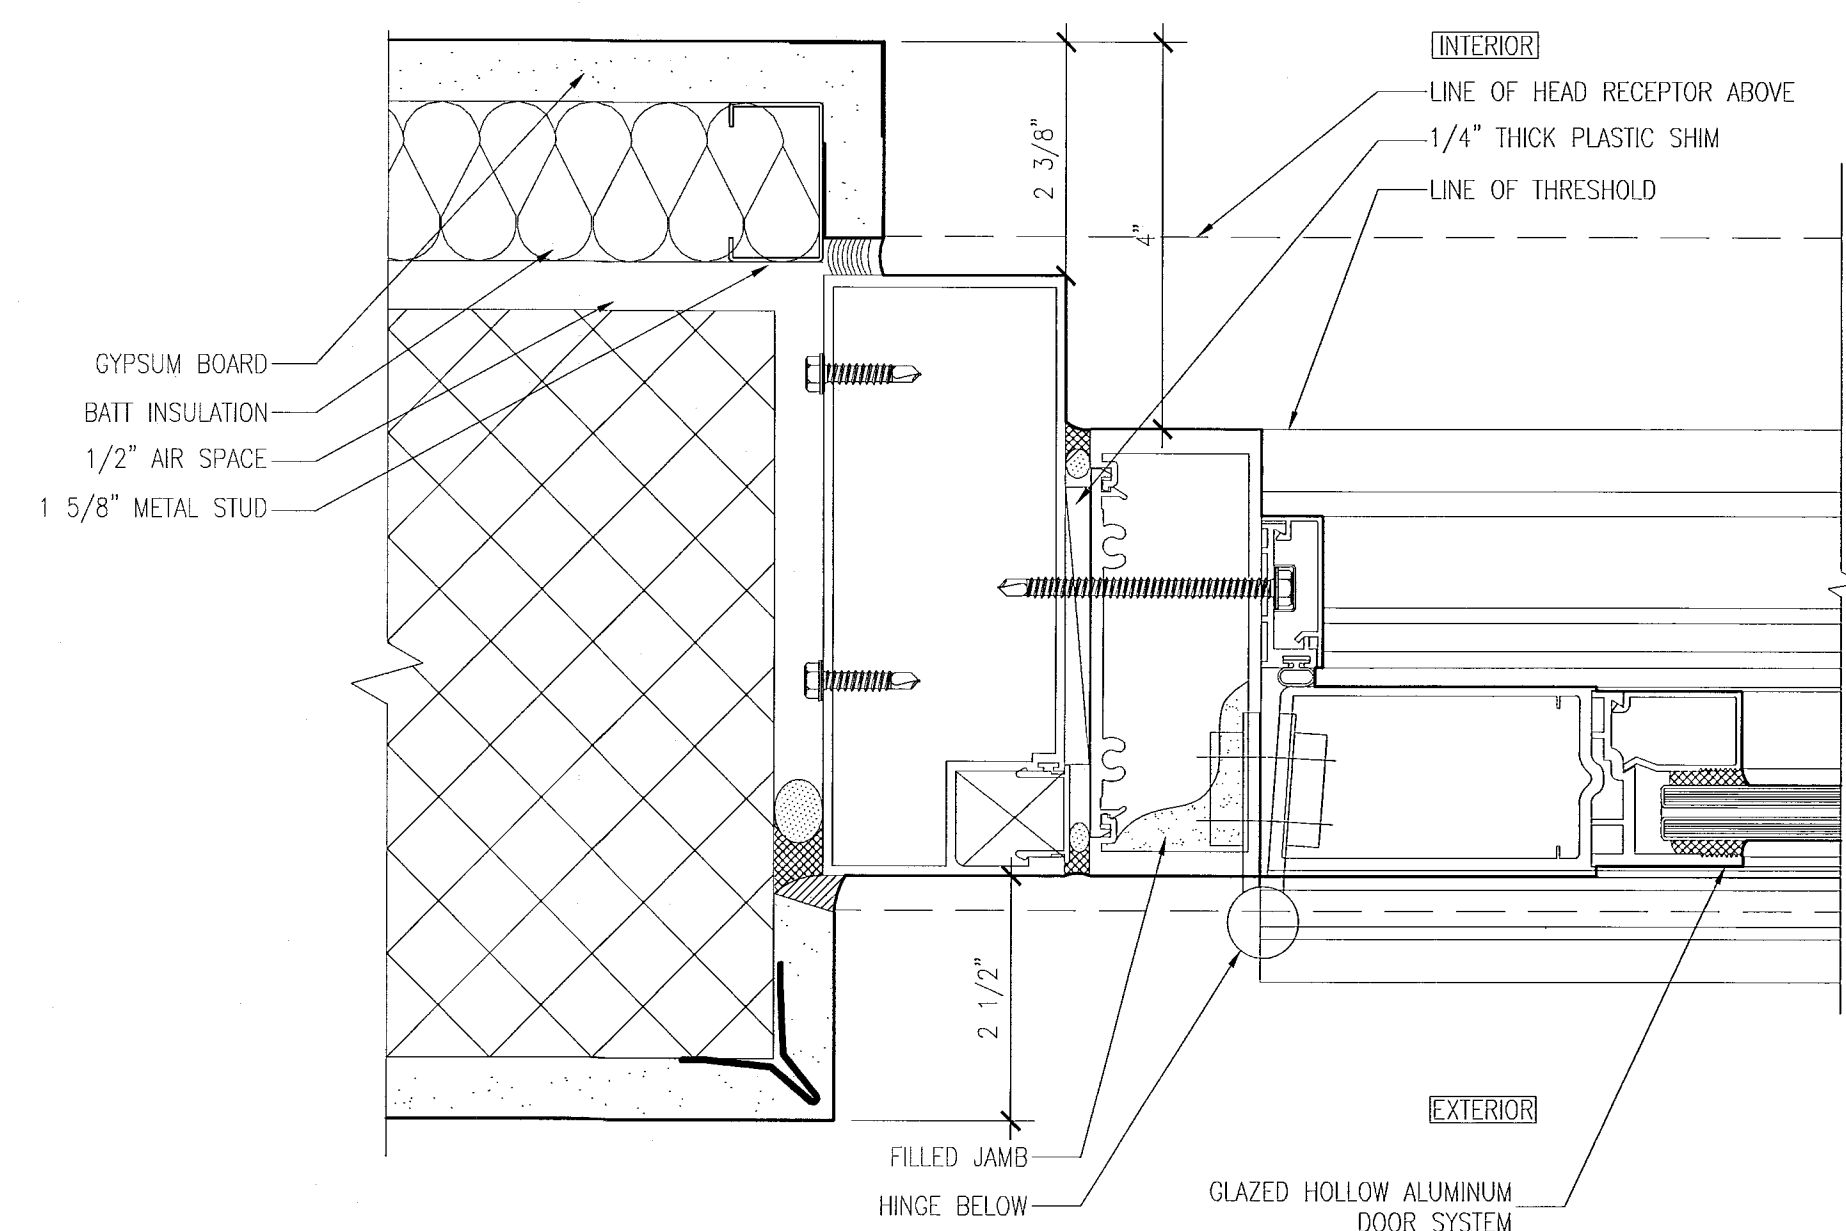

1 SWINGING DOOR JAMB AT HINGE
SCALE: 6" = 1'-0"

APPROVED
MIAMI BEACH
FIRE DEPARTMENT

KEYPLAN N.T.S.

[illegible]

SEAL

Jonathan Cardello
Lic. # AR93391

ADD Inc Architecture Interiors Planning

One Biscayne Tower
Suite 1670
Two South
Biscayne Boulevard
Miami, Fl 33131
T. 305.482.8700
F. 305.482.8770
www.addinc.com
Lic. # AA26001507

Boston Miami

JOB NUMBER: 13036.00

CHECKED BY: _____

ISSUE DATE: FEBRUARY 18, 2014

SCALE: AS NOTED


SHEET TITLE

ENLARGED VERTICAL DETAILS & PENETRATION DETAILS

SHEET NUMBER


A501

COPYRIGHT ADD, INC. 201

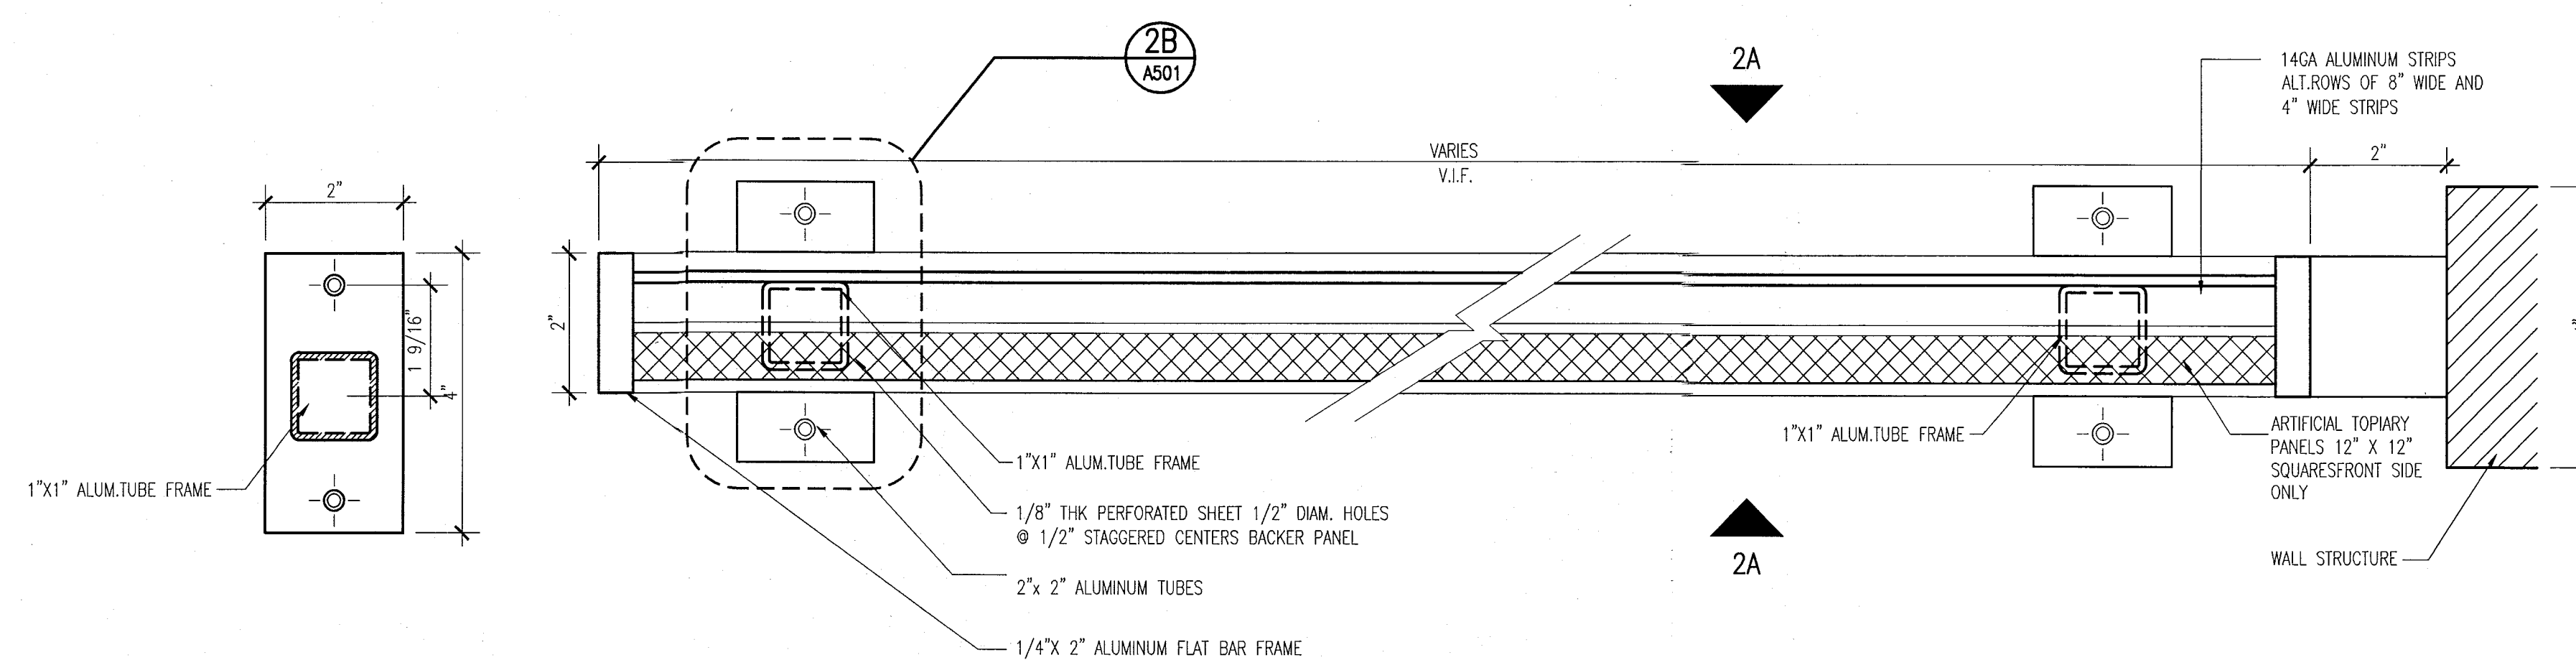


2B) DETAIL — BALCONY DIVIDER PLAN
SCALE: 6" = 1'-0"


2 BALCONY DIVIDER PLAN - AT POOL SUITES BUILDING
SCALE: 6" = 1'-0"

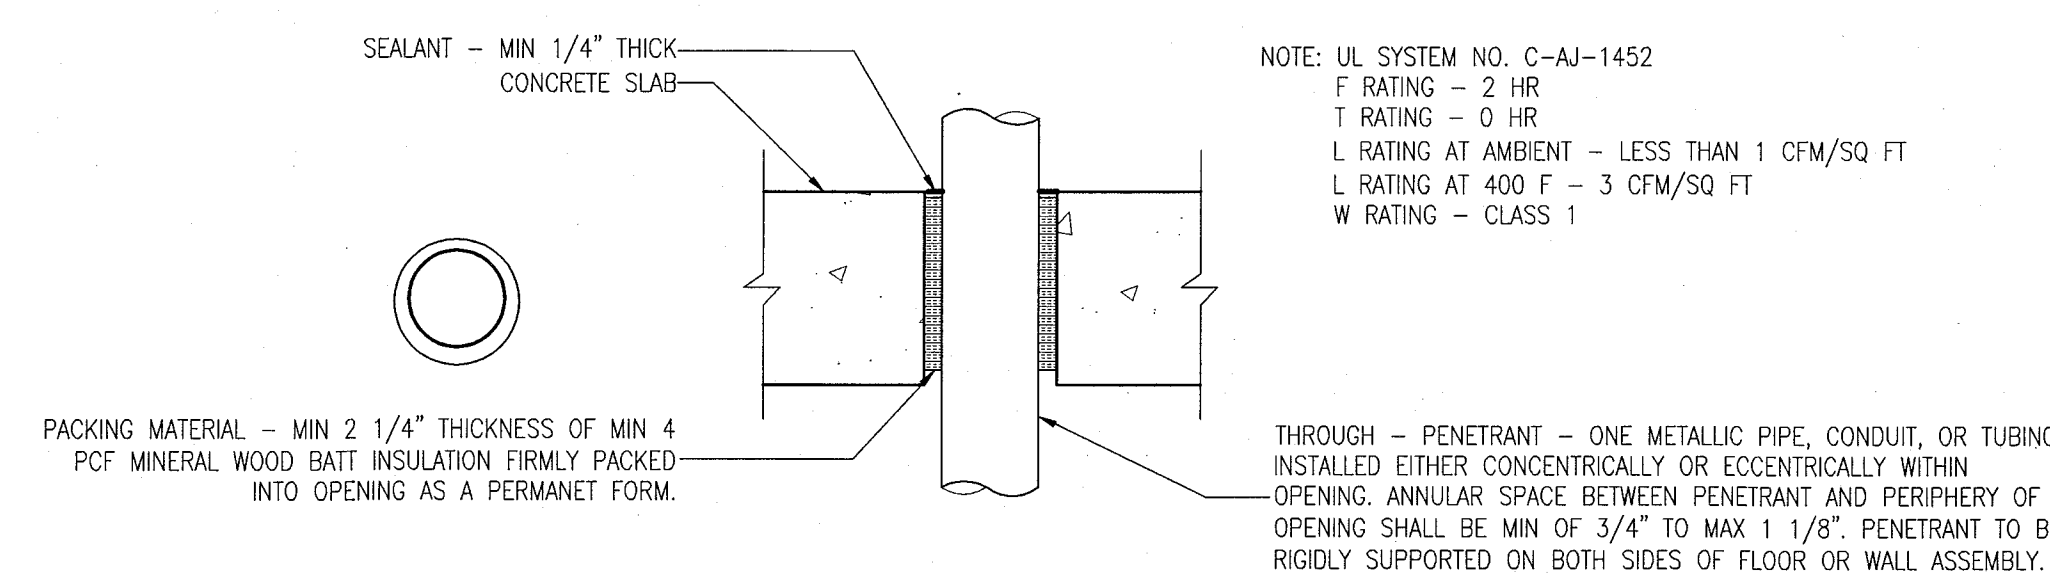

5 PENETRATION DETAIL
SCALE: NO SCALE

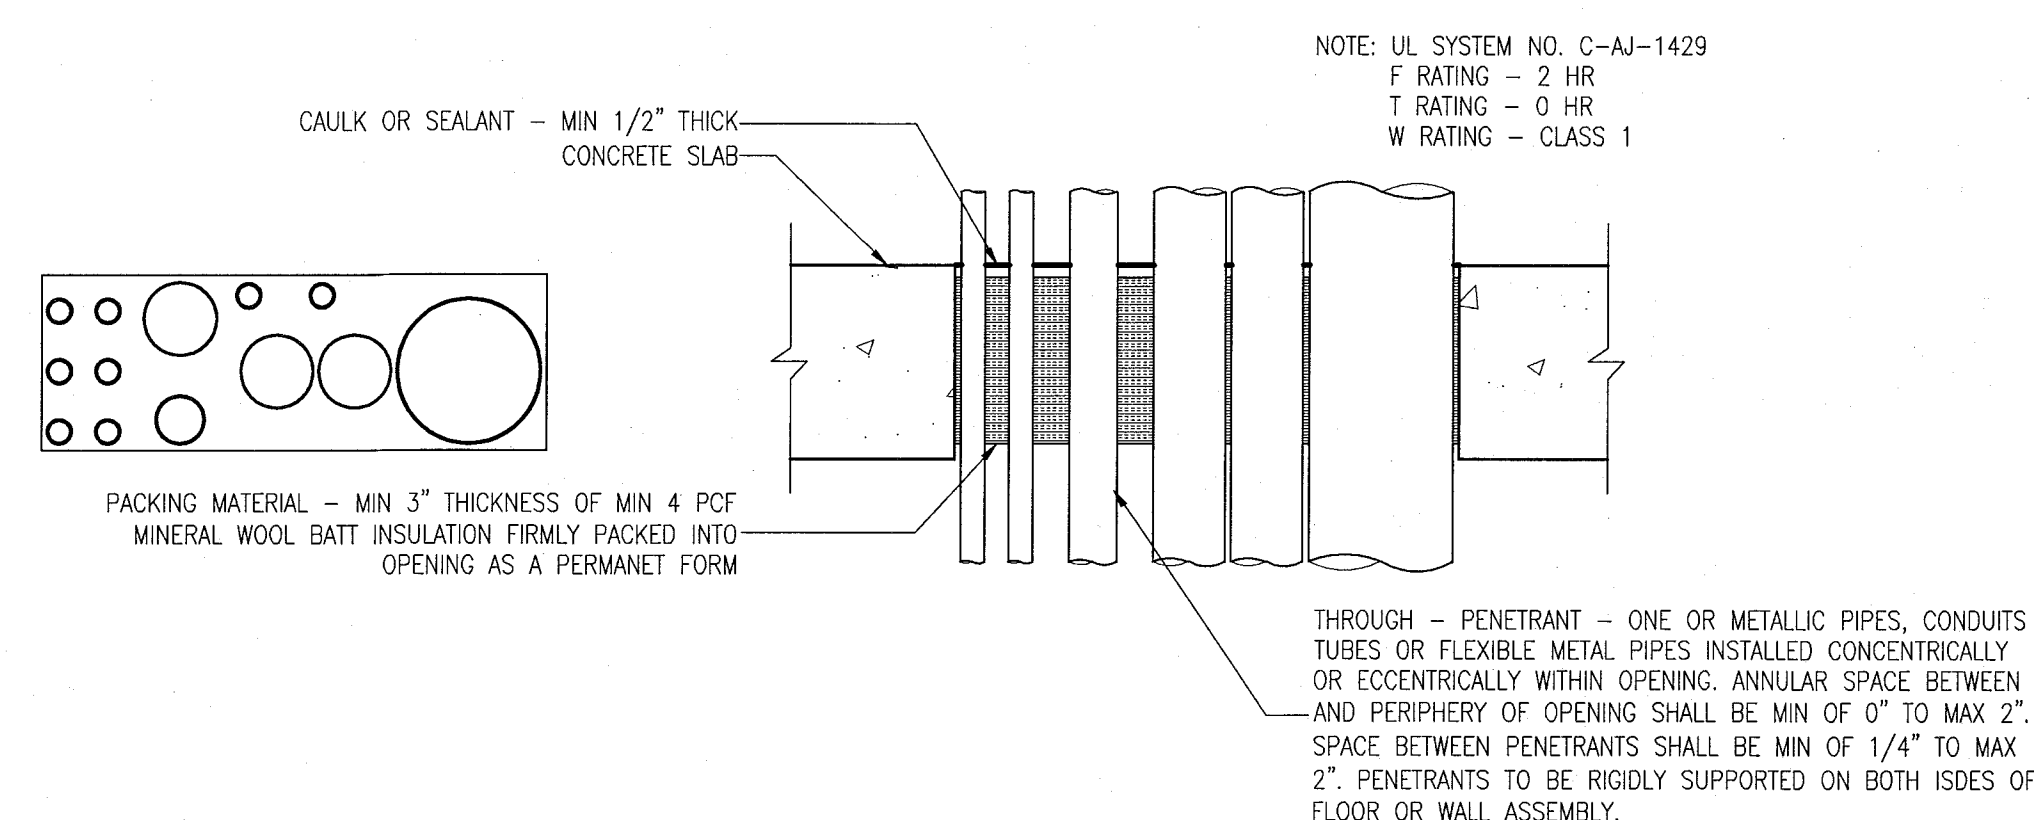


4 PENETRATION DETAIL
SCALE: NO SCALE

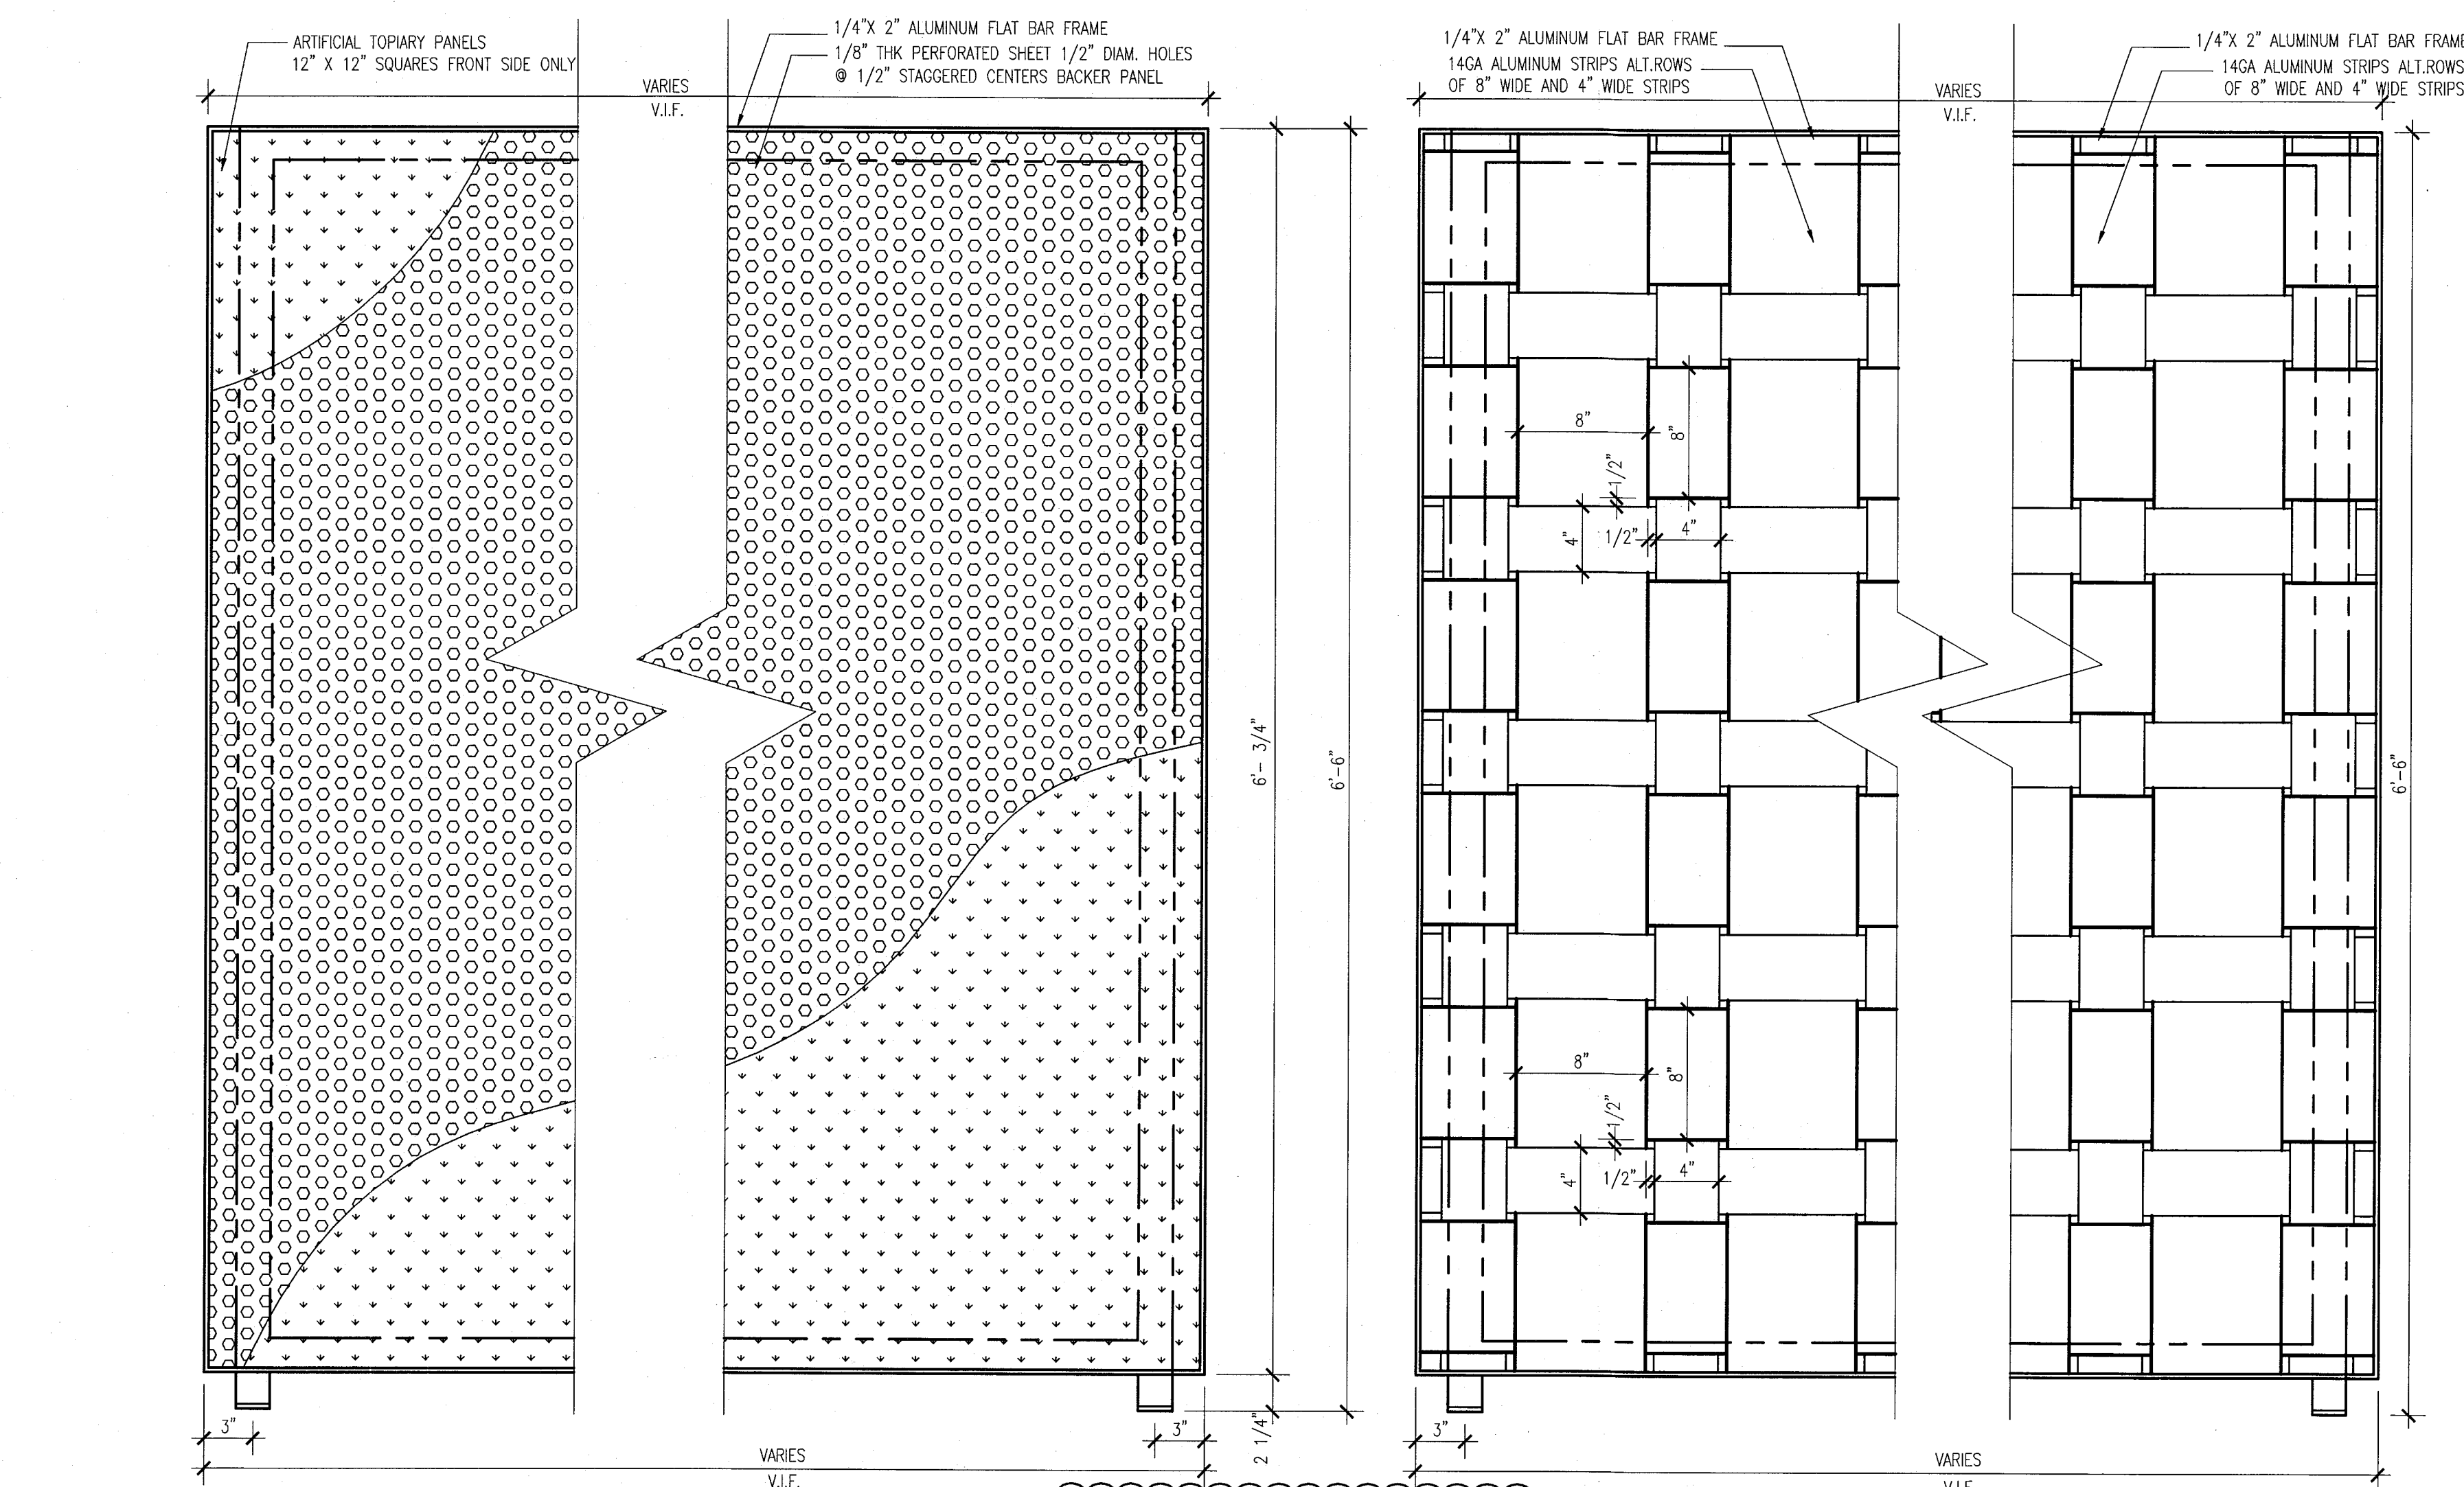


BALCONY DIVIDER ELEVATION
AT GROUND LEVEL OF POOL SUITES BLDG.


V.I.F.
BALCONY DIVIDER ELEVATION
UPPER LEVELS OF POOL SUITES BLDG.

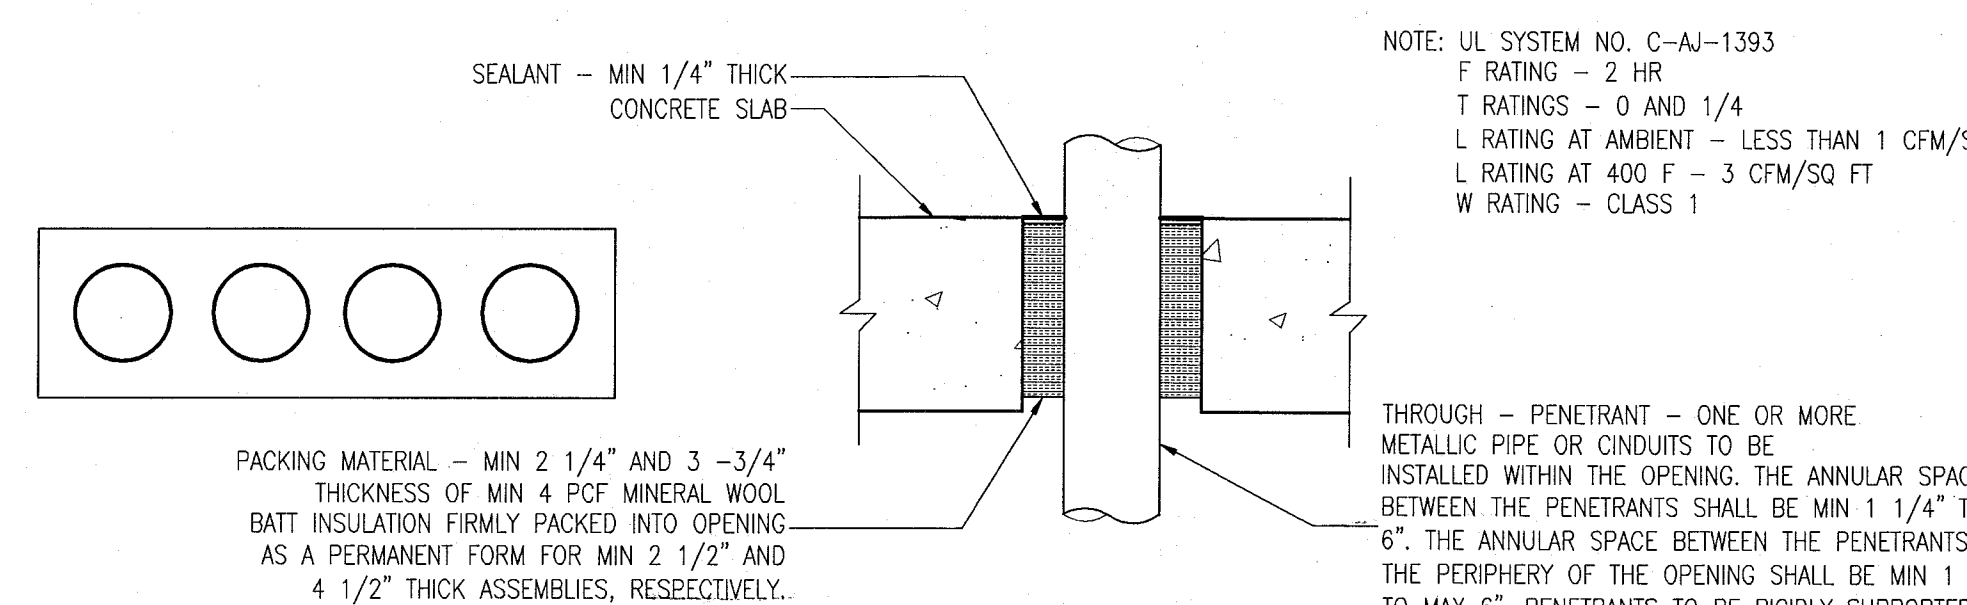

3 PENETRATION DETAIL
SCALE: NO SCALE

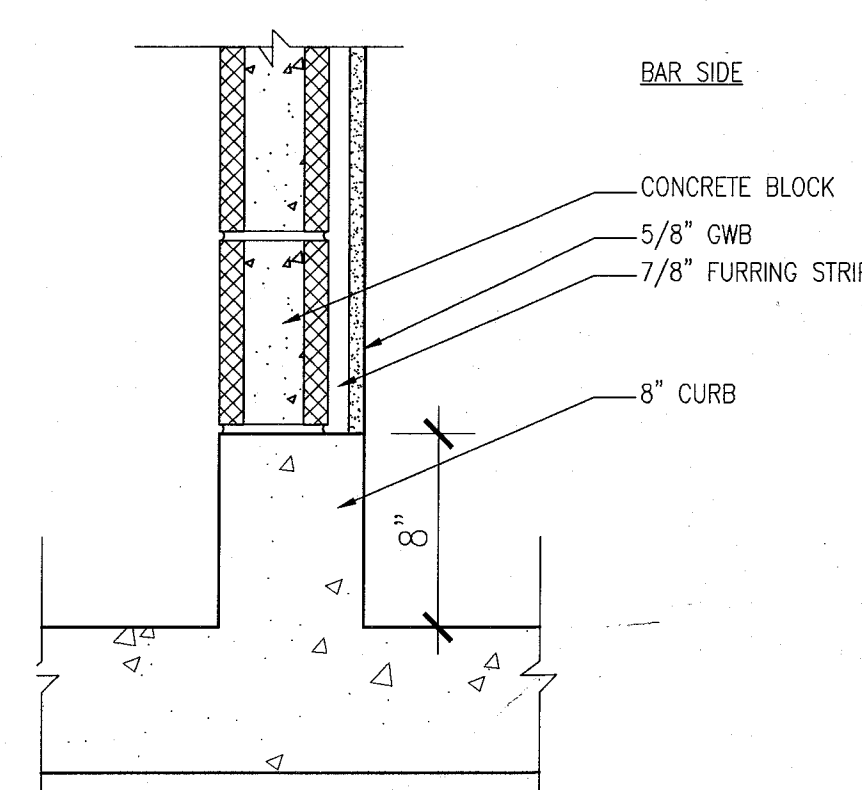

6 CURB AT BASEMENT COOLER WALL
SCALE: NO SCALE

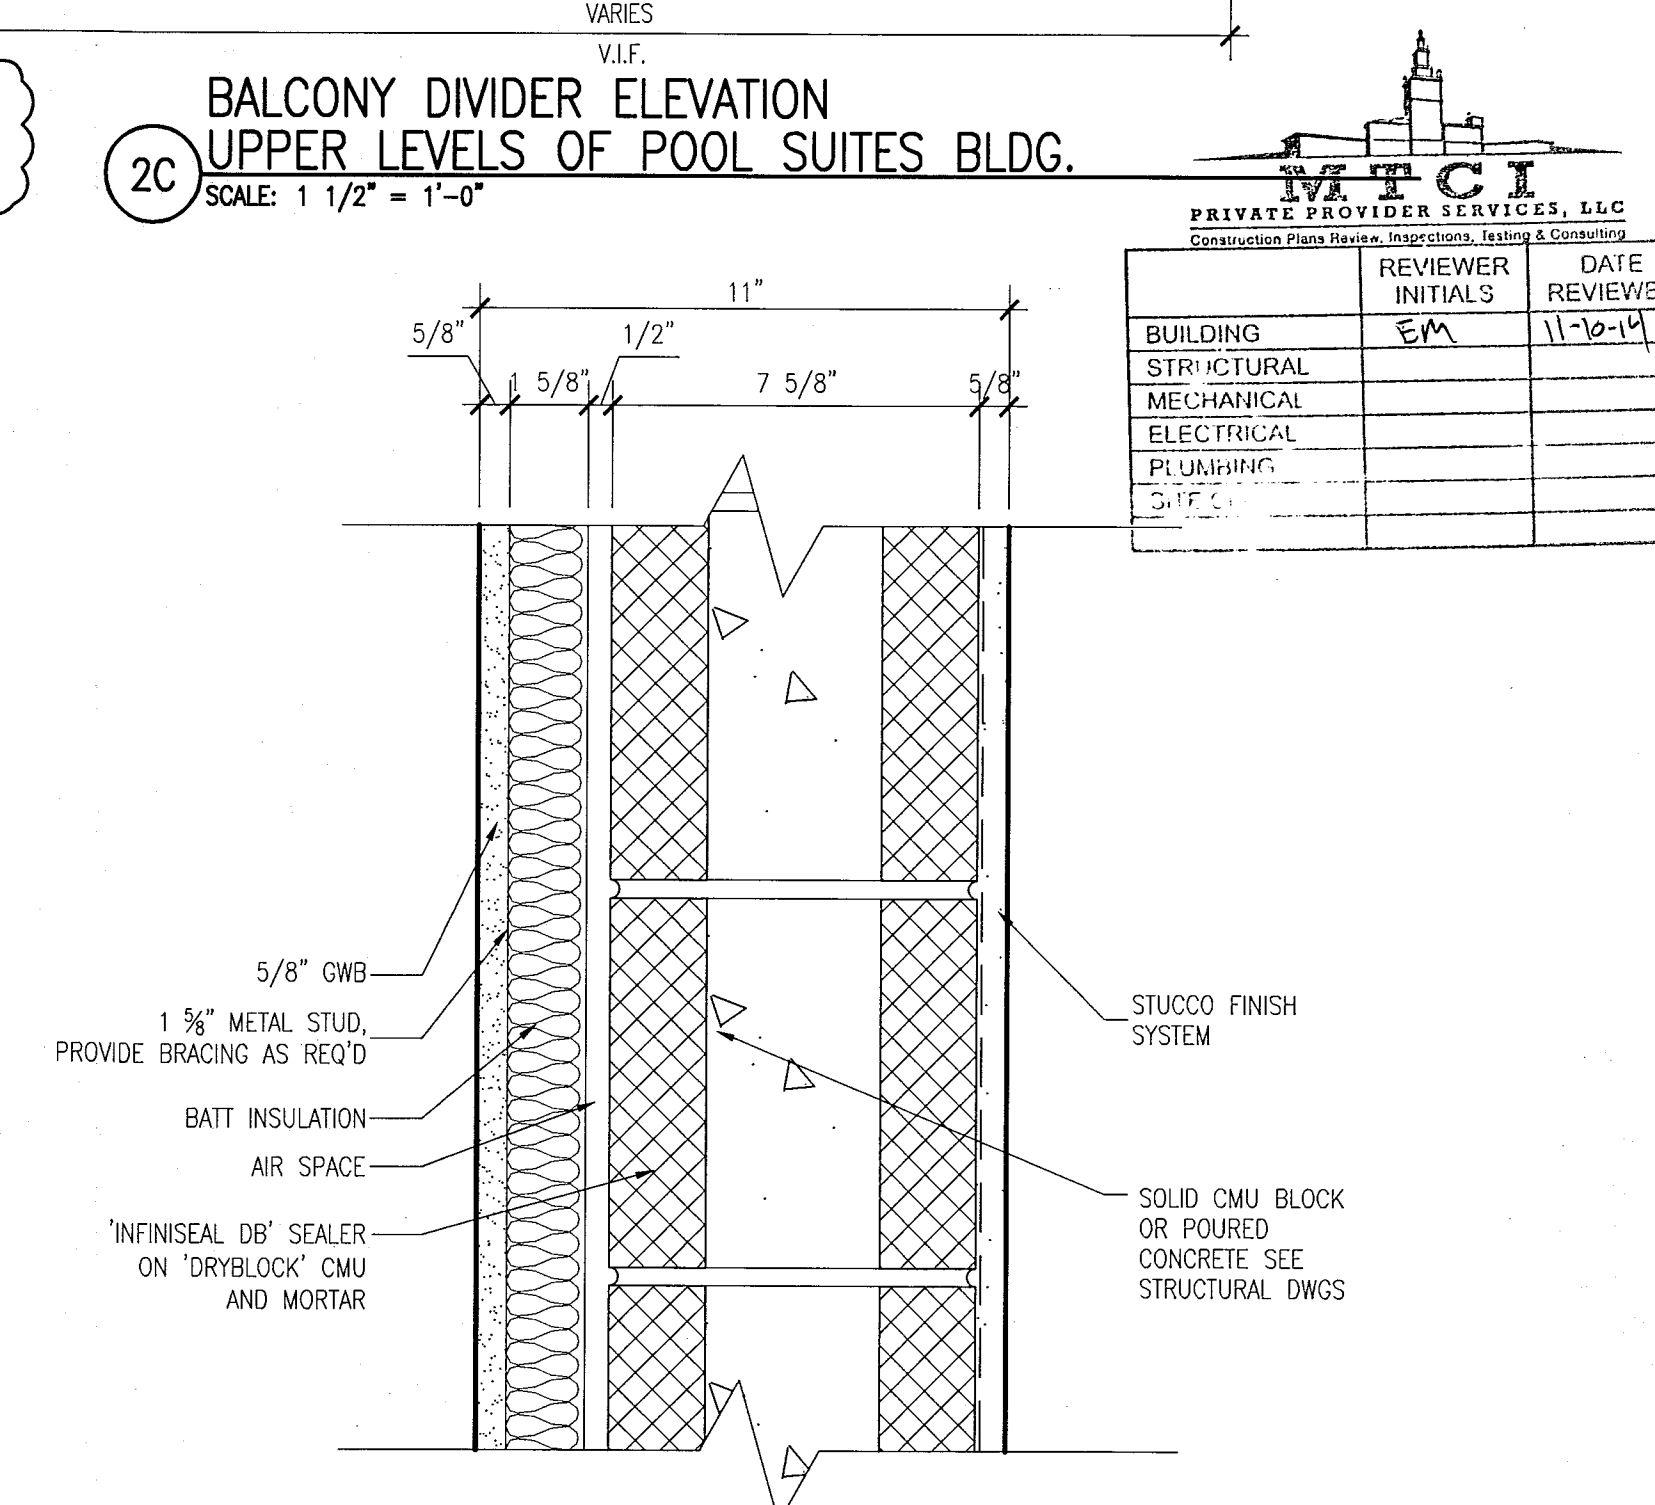

1 EXTERNAL WALL SYSTEM STS-1 @ POOL SUITES
SCALE: 3" = 1'-0"

APPROVED
MIAMI BEACH
FIRE DEPARTMENT

KEYPLAN N.T.S.

REVISIONS		
NO.	DESCRIPTION	ISSUE DATE
10	MASTER PERMIT COMMENTS	07-03-2014

100% CONSTRUCTION
DOCUMENT SET

SEAL

8-4-14
Jonathan Cardello
Lic. # AR93391

ADD Inc Architecture Interiors Planning

One Biscayne Tower
Suite 1670
Two South
Biscayne Boulevard
Miami, FL 33131
T. 305.482.8700
F. 305.482.8770
www.addinc.com
Lic. # AA28001607 Boston Miami

JOB NUMBER: 13036.00

CHECKED BY:

ISSUE DATE: FEBRUARY 18, 2014

SCALE:

SHEET TITLE

REPAIR
DETAILS

SHEET NUMBER


A502

NEW SHEET


COPYRIGHT ADD INC 2011

NOTES:

1. THE INTENT OF THESE DETAILS IS TO REPAIR DAMAGED/LEAKING LINES AND REPLACE SHOWER, SINK, AND TOILET VALVES AS REQUIRED.
2. ANY PORTION OF WALL REMOVED TO INSTALL / REPAIR WORK SHALL BE REPLACED TO MATCH EXISTING.

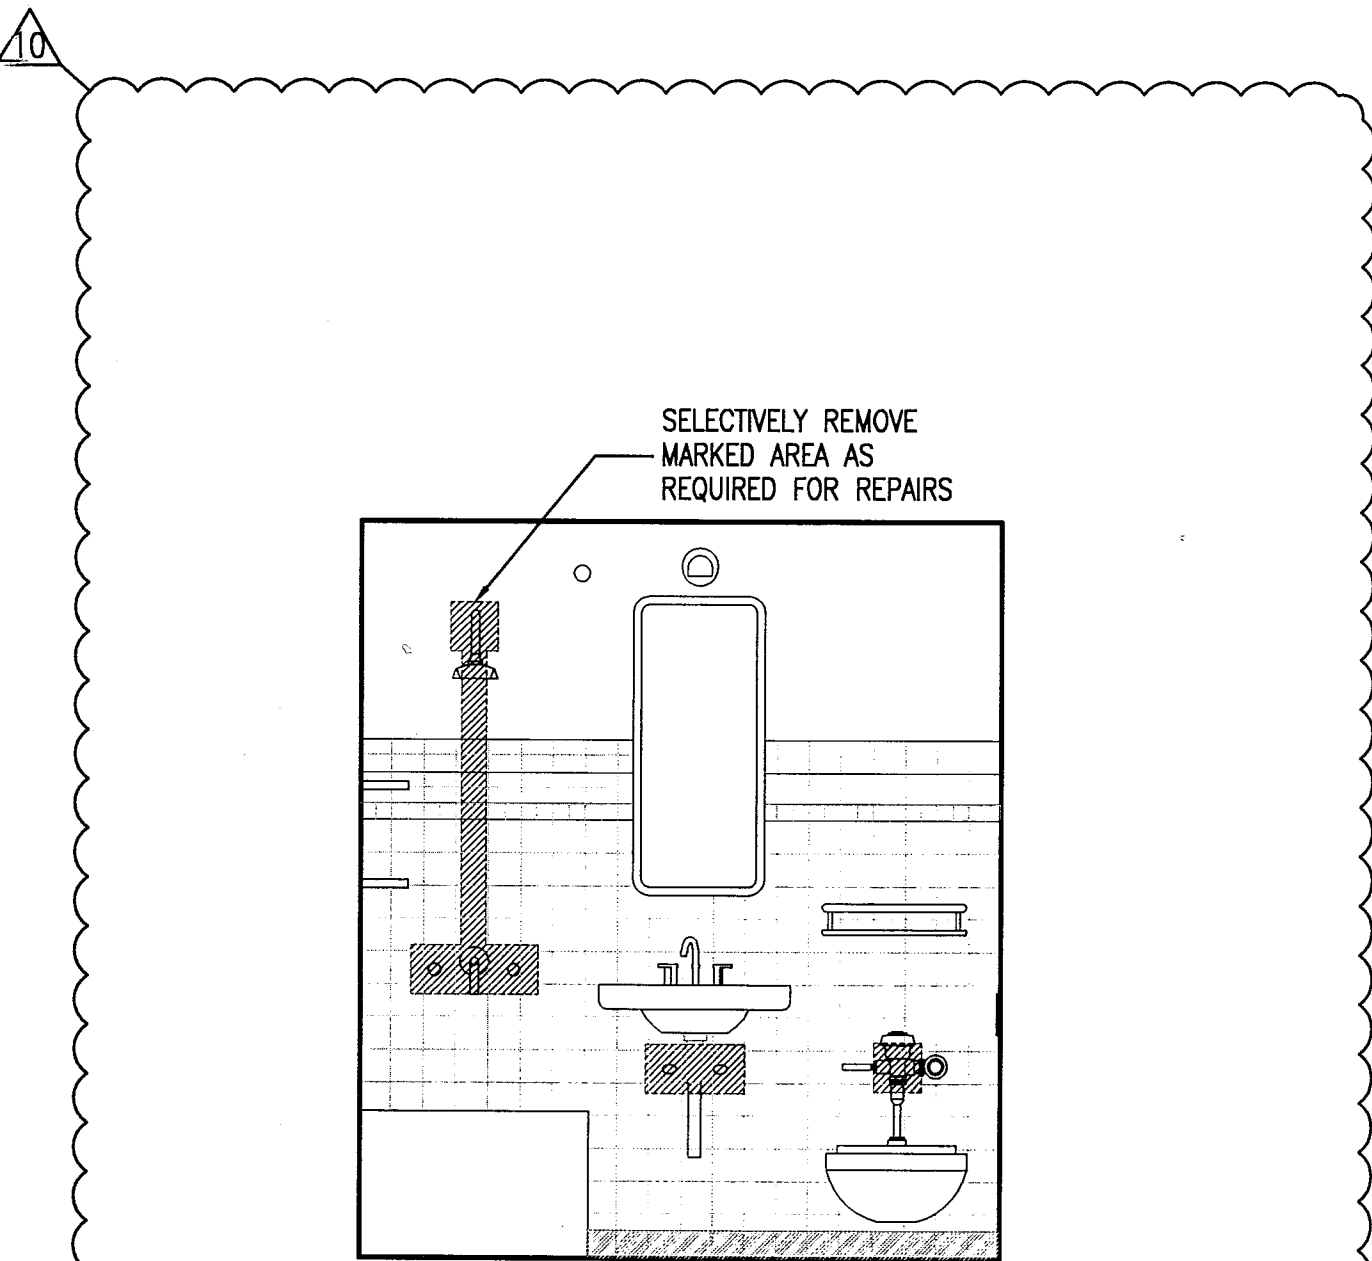


1 REPAIR DETAILS @ GUESTROOM BATHROOMS (TYP.)
SCALE: 1/2" = 1'-0"

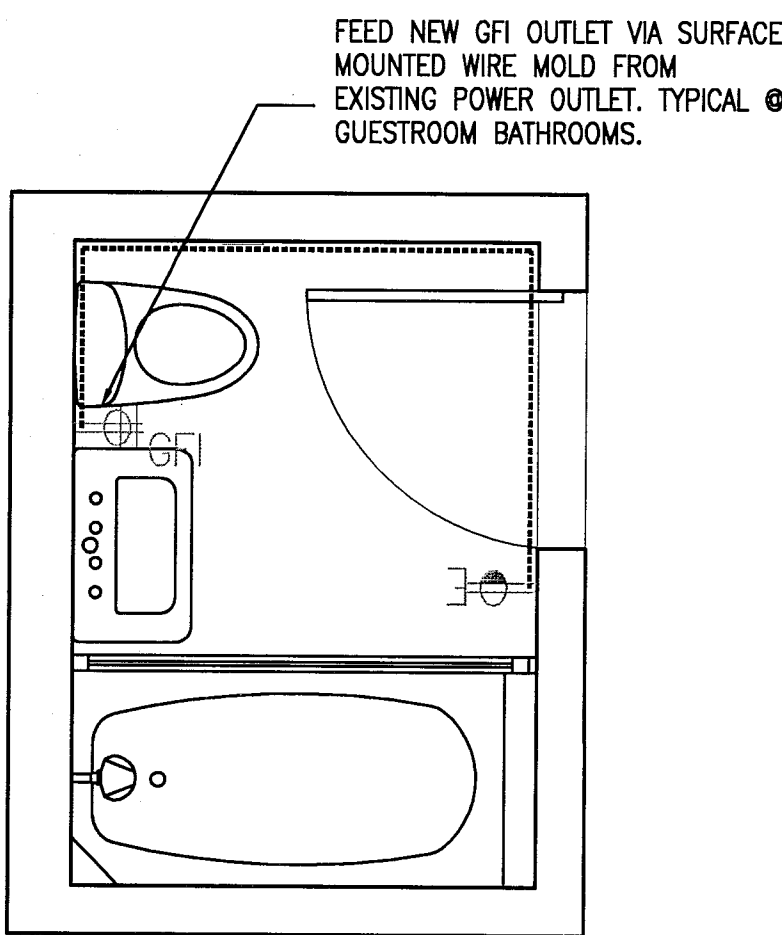

2 GFI WIRING @ GUESTROOM BATHROOM (TYP.)
SCALE: 1/2" = 1'-0"

PRIVATE PROVIDER SERVICES, LLC Specializing in Fast Turnaround, High Quality, and Cost-Effective			
BUILDING	REVIEWER	DATE	REVIEWED
STRUCTURAL	EM	11-10-14	
MECHANICAL			
ELECTRICAL			
PLUMBING			

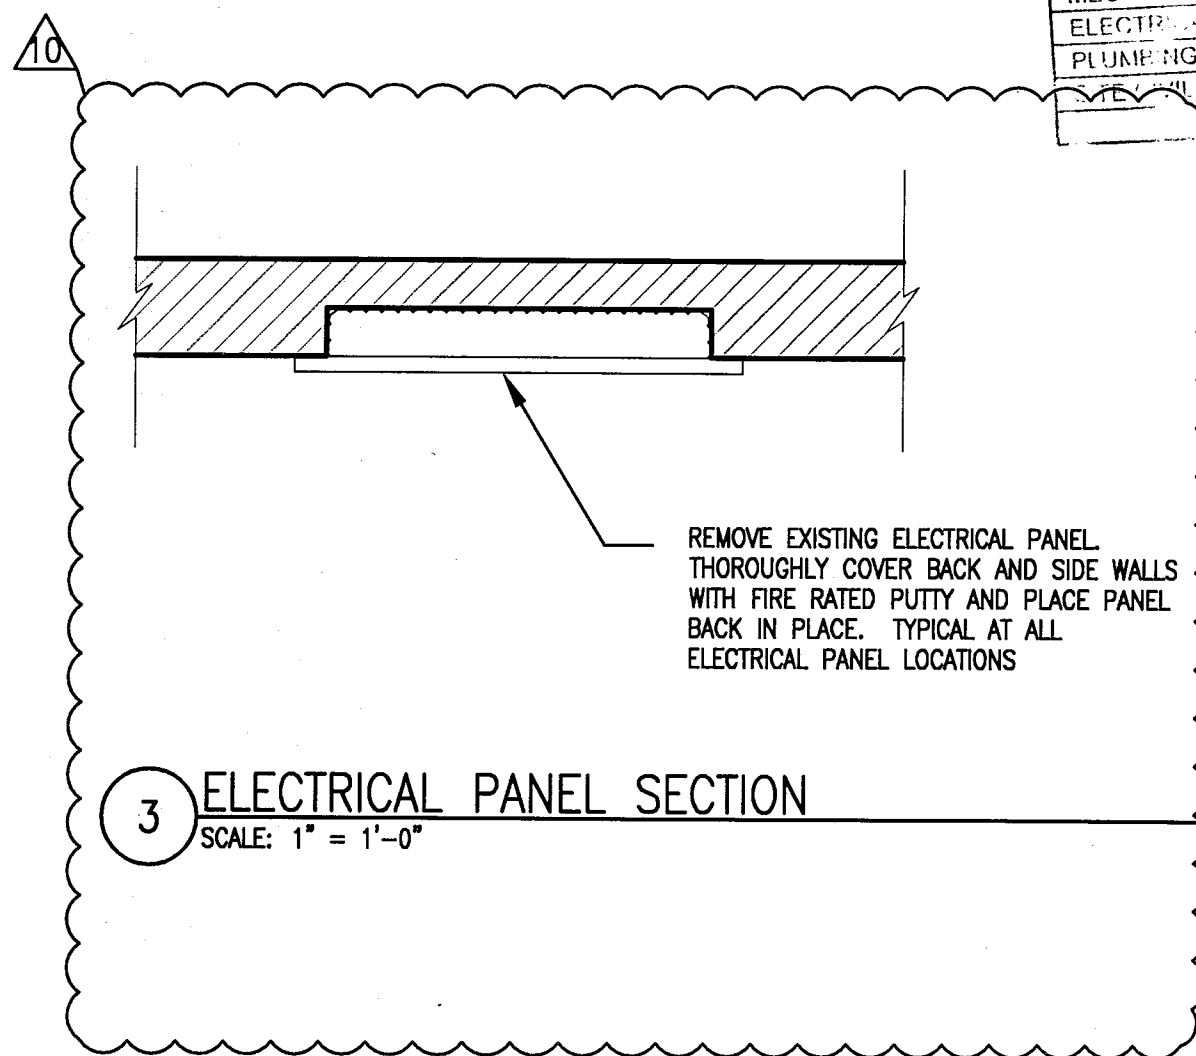

3 ELECTRICAL PANEL SECTION
SCALE: 1" = 1'-0"

APPROVED
MIAMI BEACH
FIRE DEPARTMENT


HADDON HALL
1500 COLLINS AVE
MIAMI BEACH, FL

KEYPLAN N.T.S.

REVISIONS		
NO.	DESCRIPTION	ISSUE DATE

REVIEWER		
REVIEWER	DATE	INITIALS
BUILDING	EM	11-16-14
STRUCTURAL		
MECHANICAL		
ELECTRICAL		
PLUMBING		
SITE CIVIL		

PERMIT SET

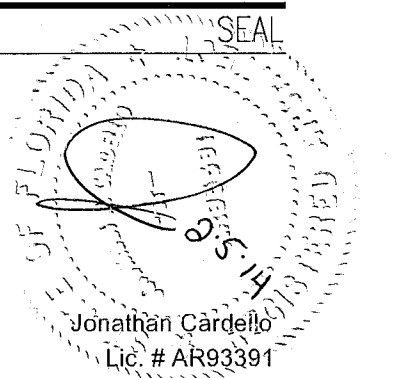

ADD Inc Architecture Interiors Planning

One Biscayne Tower
Suite 1670
Two South
Biscayne Boulevard
Miami, FL 33131
T. 305.482.8700
F. 305.482.8770
www.addinc.com
Lic. # AA26001507

Boston Miami

JOB NUMBER: 13036.00

CHECKED BY:

ISSUE DATE: JANUARY 24, 2014

SCALE: VARIES


SHEET TITLE

ROOF DETAILS


SHEET NUMBER

A591


COPYRIGHT ADD INC 2011

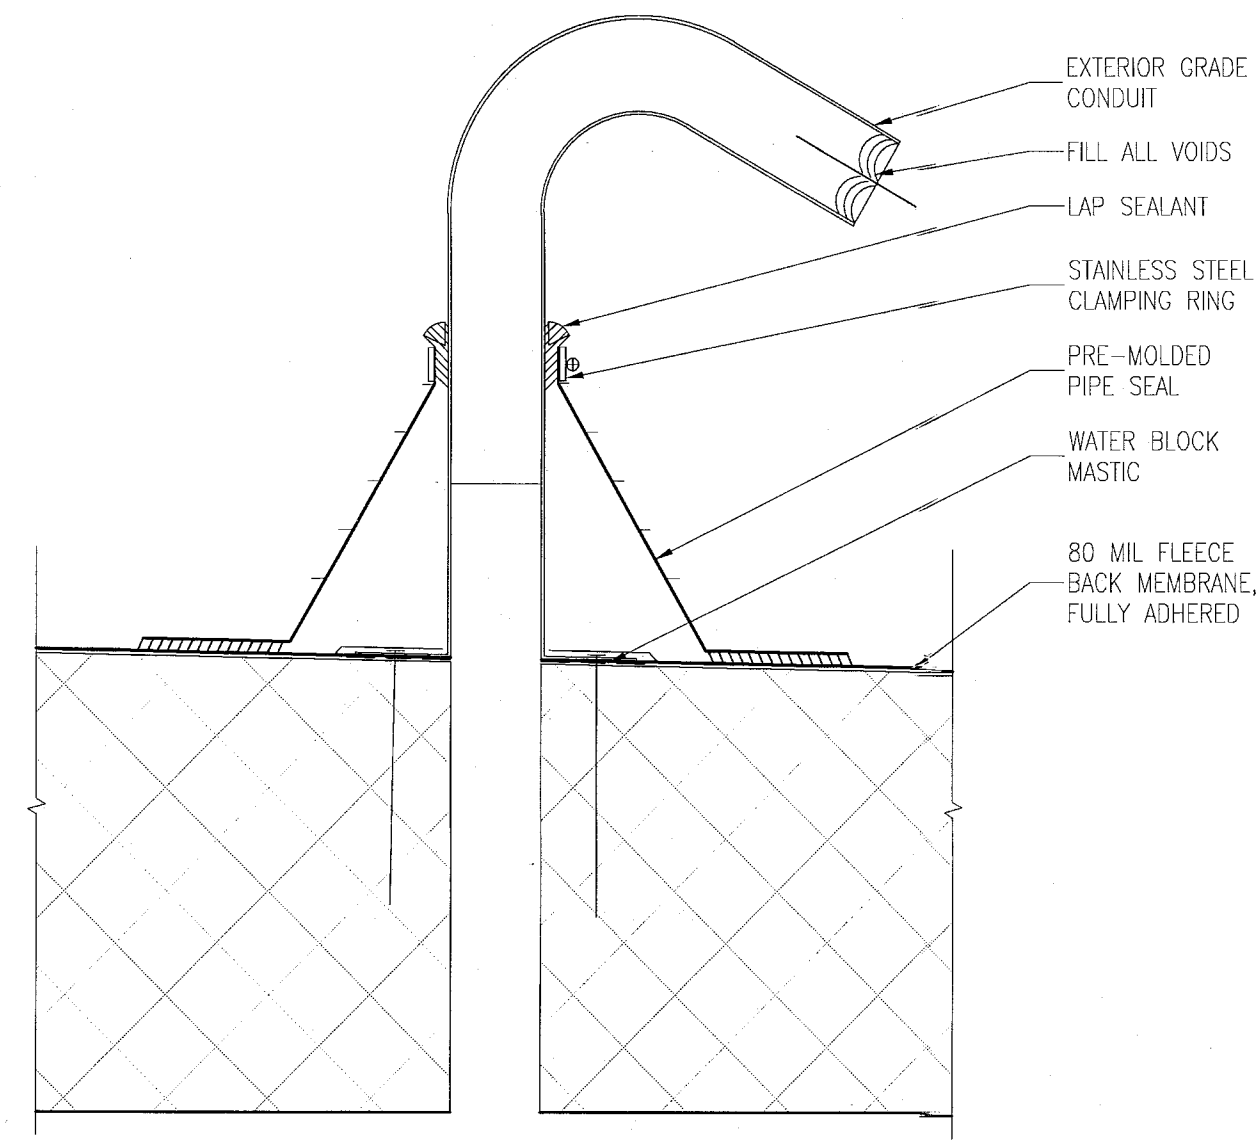


H ELECTRICAL CABLE DETAIL
SCALE: 3" = 1'-0"

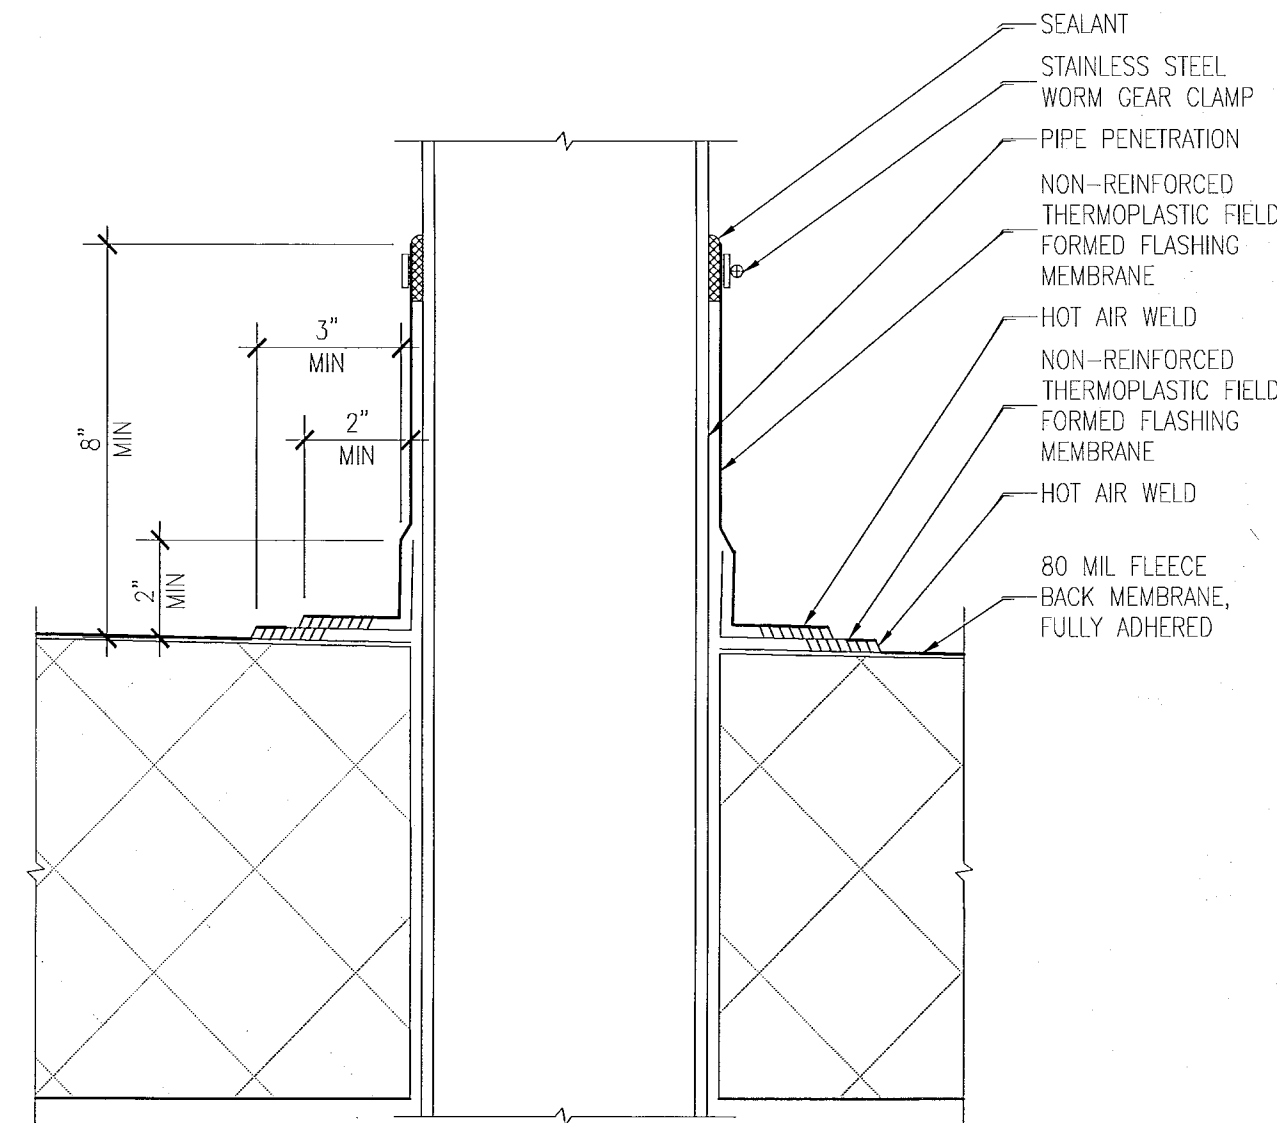


D ROOF PENETRATION DETAIL
SCALE: 3" = 1'-0"

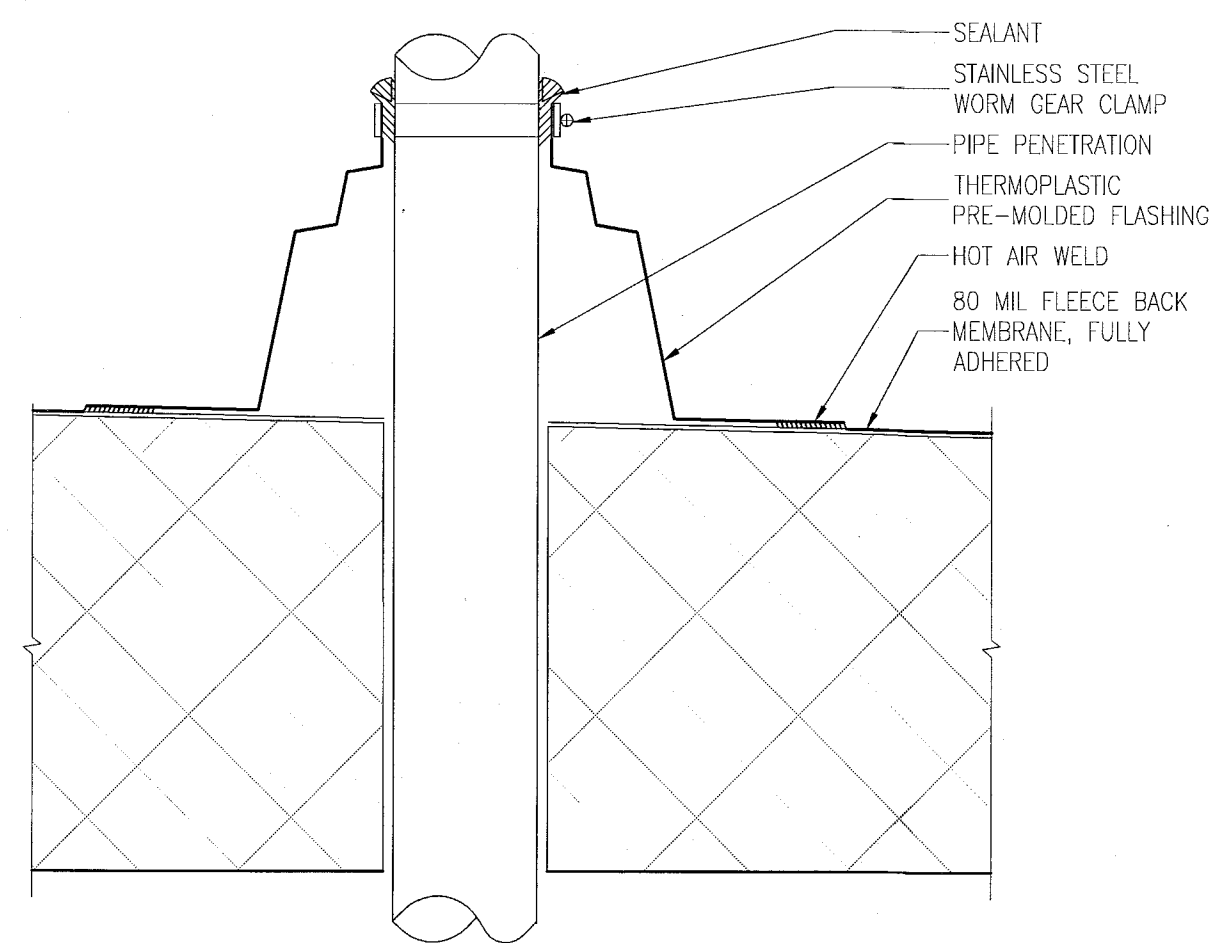


G ROOF PIPE PENETRATION
SCALE: 3" = 1'-0"

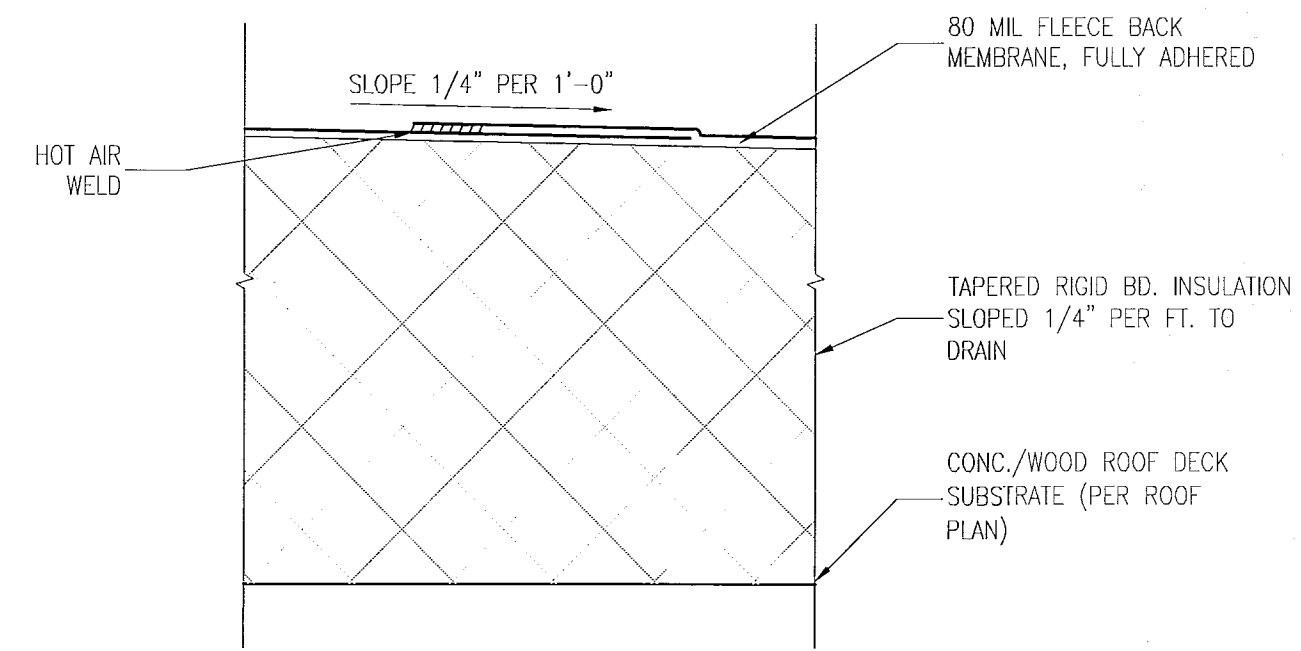


C ROOF SYSTEM - ONE (RS1)
SCALE: 3" = 1'-0"

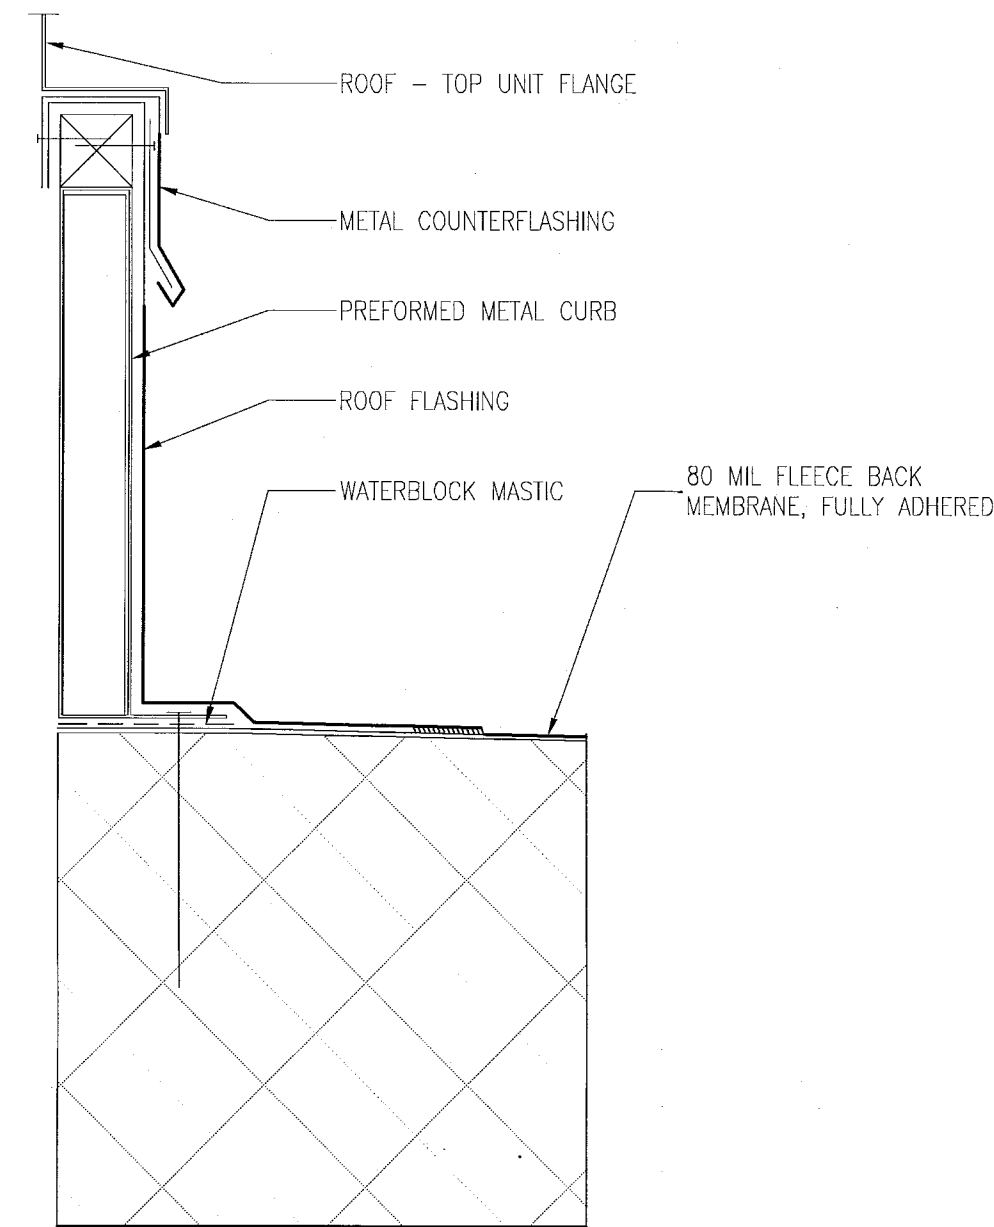


F ROOF AT RTU CURB DETAIL
SCALE: 3" = 1'-0"

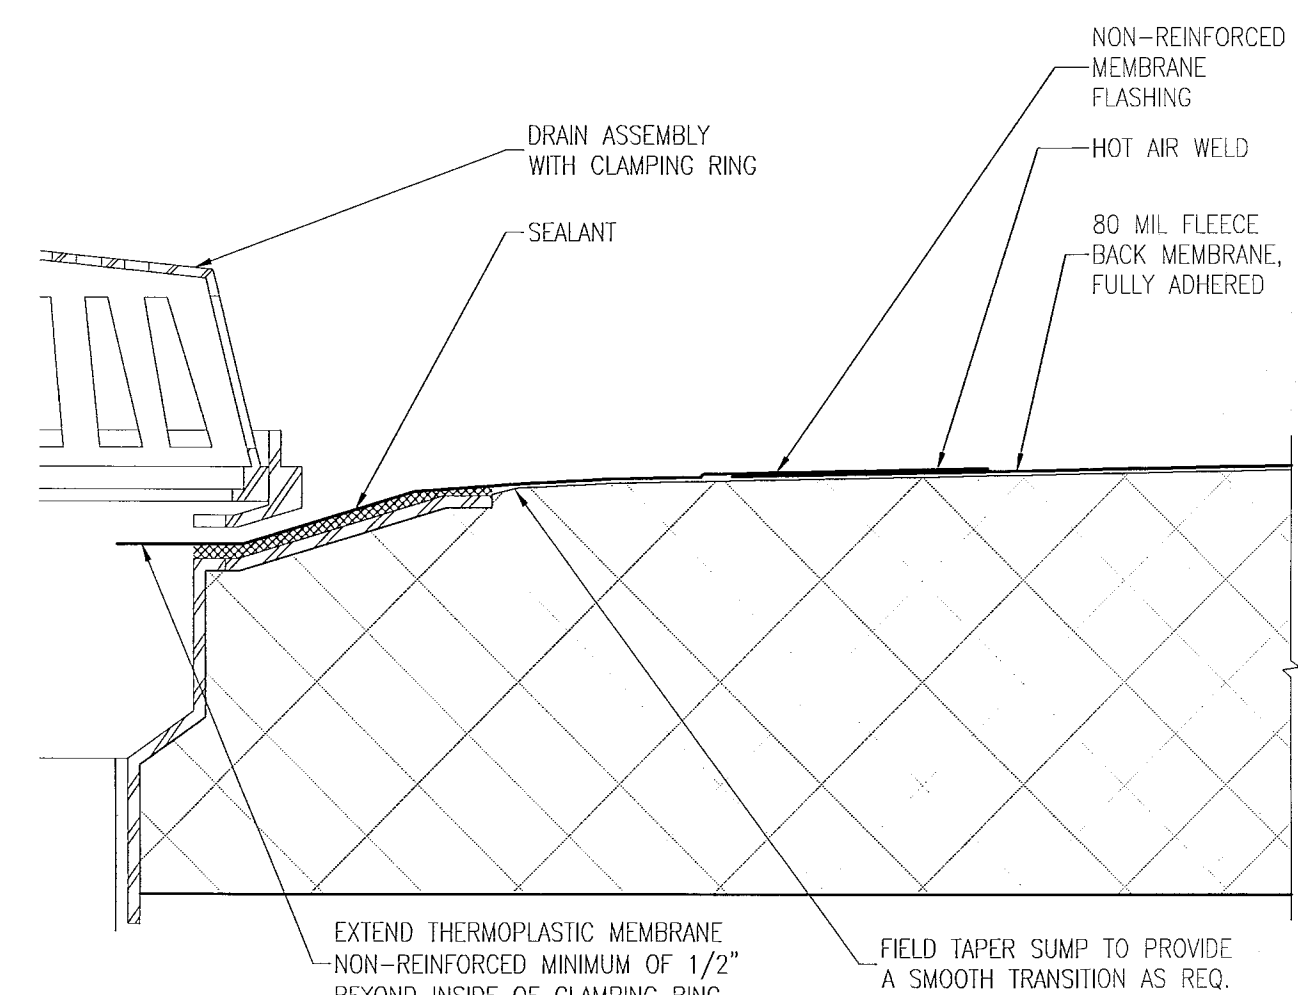


B ROOF DRAIN DETAIL
SCALE: 3" = 1'-0"

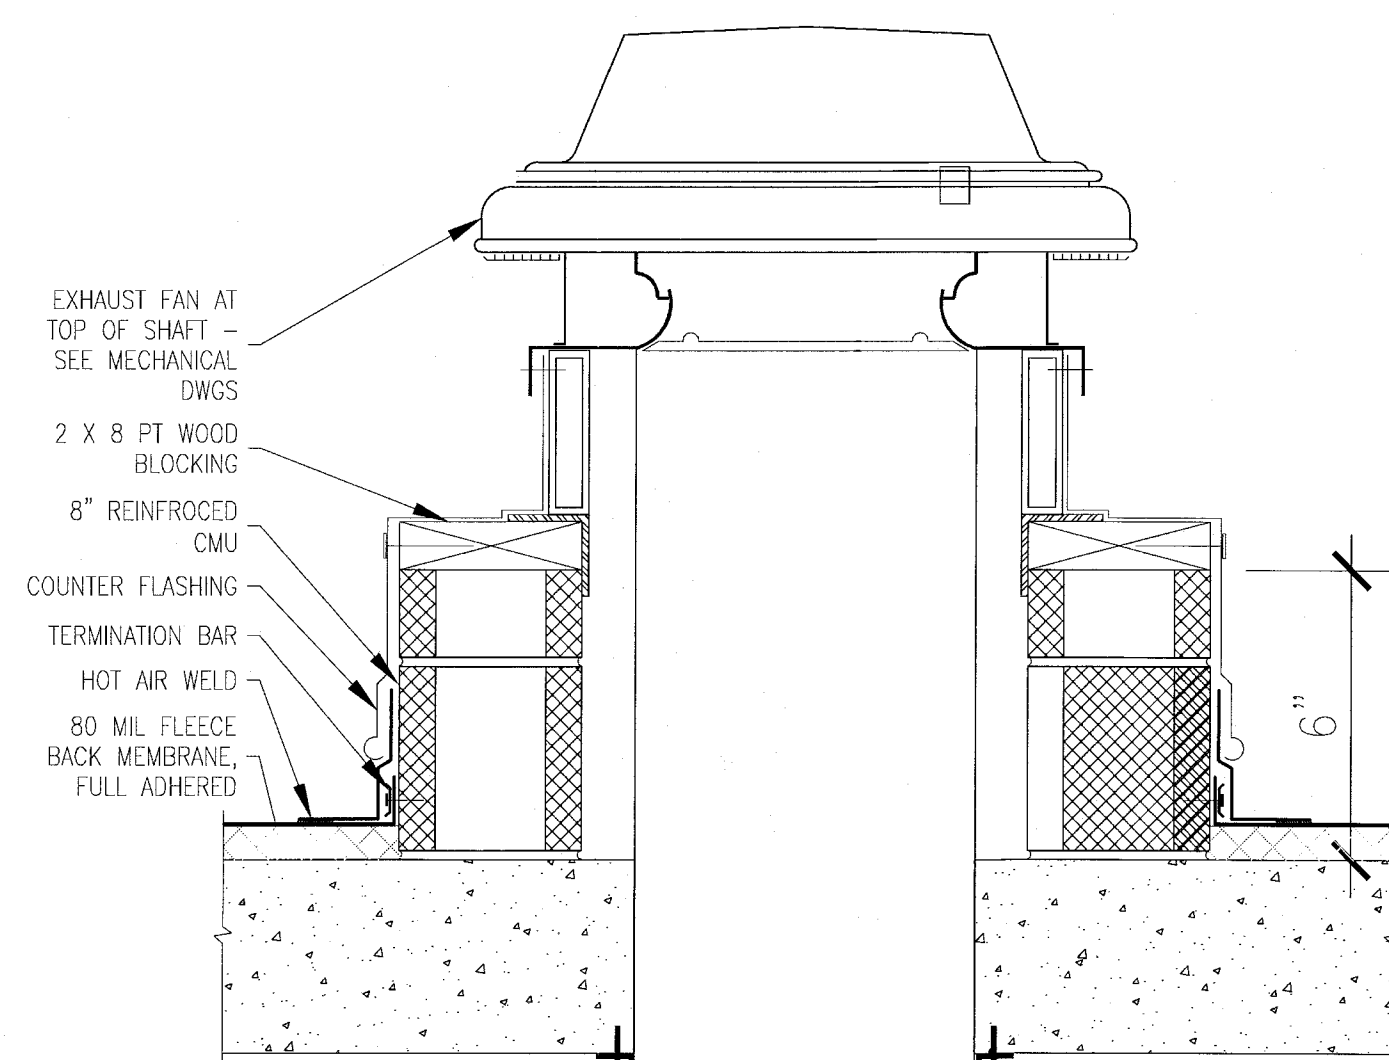

I DETAIL @ SHAFT ROOF PENETRATION
SCALE: 3" = 1'-0"

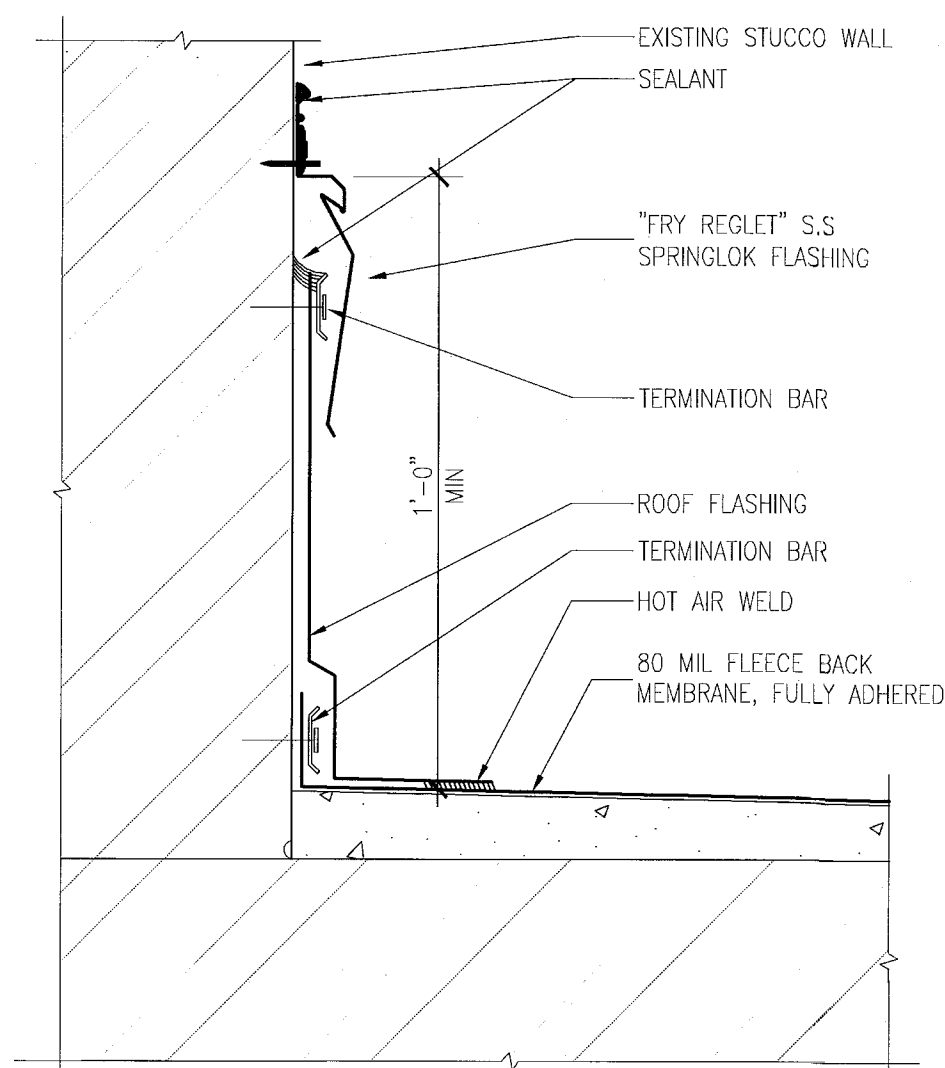

E PARAPET FLASHING DETAIL & REGLET
SCALE: 3" = 1'-0"

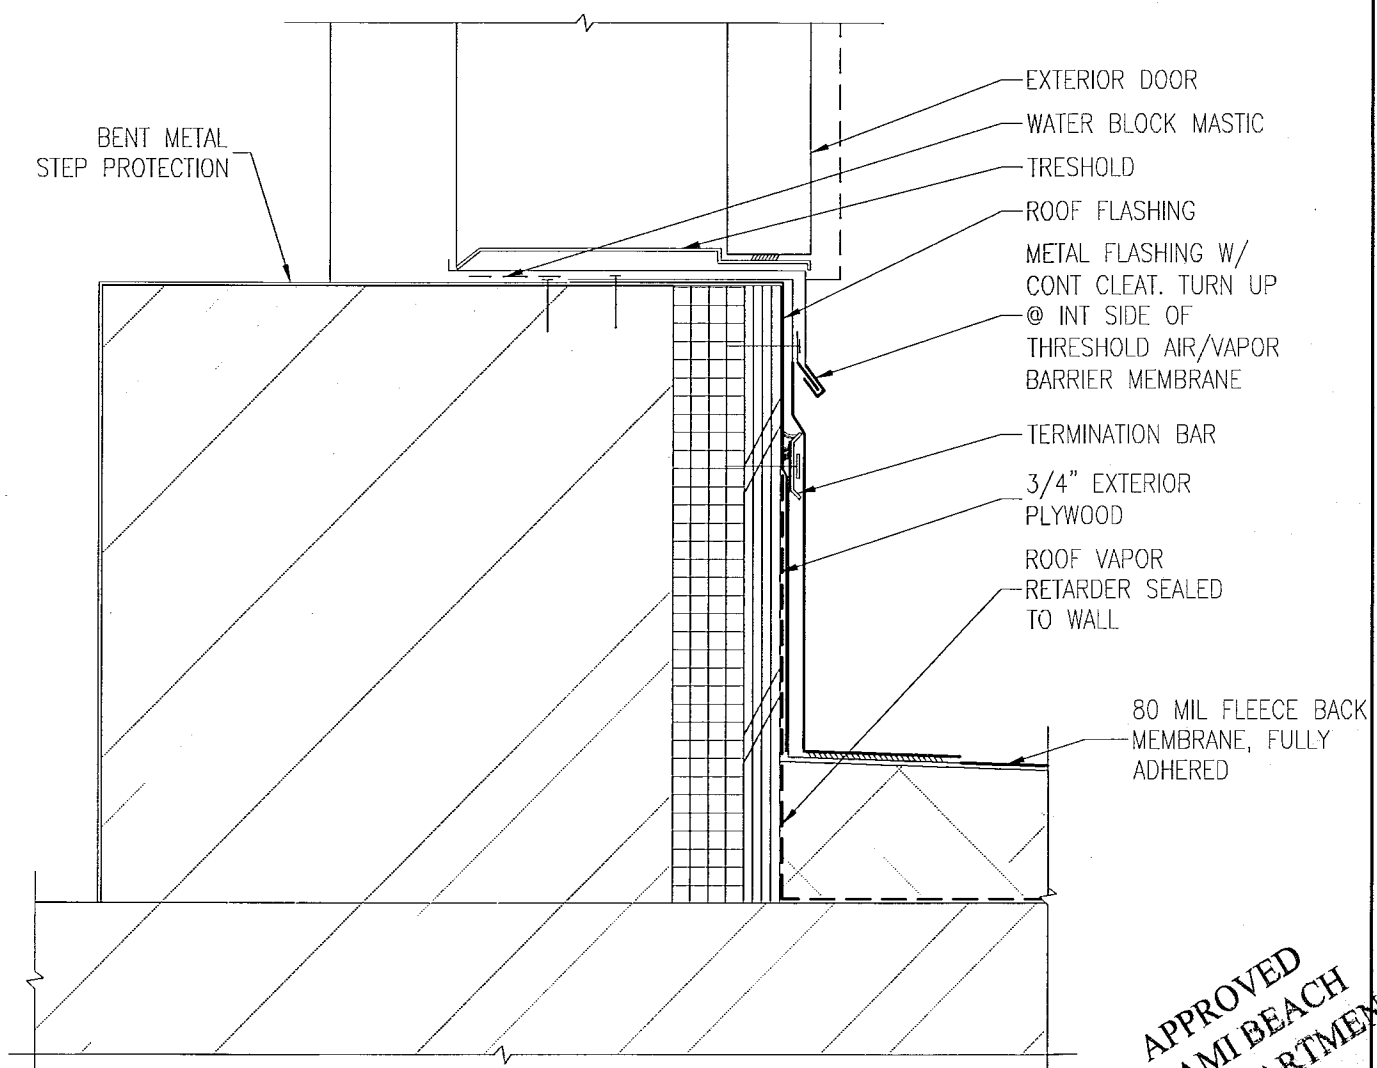

A ROOF ACCESS DOOR THRESHOLD @ STAIR
SCALE: N.T.S.


APPROVED
MIAMI BEACH
FIRE DEPARTMENT

MIAMI BEACH, FL

N.T.S

PERMIT SET

NORTH

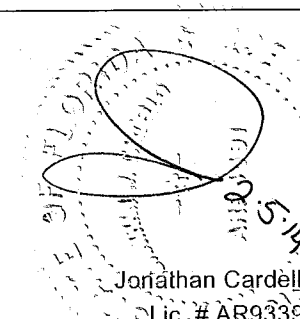

ADD Inc Architecture Interiors Planning

One Biscayne Tower
Suite 1670
Two South
Biscayne Boulevard
Miami, FL 33131
T. 305.482.8700
F. 305.482.8770
www.addinc.com
Lic. # AA26001507

JOB NUMBER: 13036

CHECKED BY:

ISSUE DATE: JANUARY 24 20

SCALE: AS NOT


 
SHEET TITLE

ELEVATOR
ENLARGED PLAN
& SECTION

SHEET NUMBER

A602

COPYRIGHT ADD INC 2

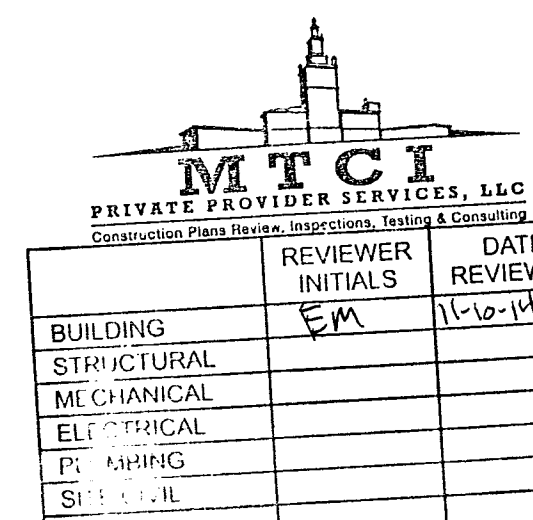


HADDON HALL 1500 COLLINS AVE MIAMI BEACH, FL

KEYPLAN N.T.S.

REVISIONS		
NO.	DESCRIPTION	ISSUE DATE
1	PROGRESS TO 100% CD	02-18-2014

100% CONSTRUCTION DOCUMENT SET

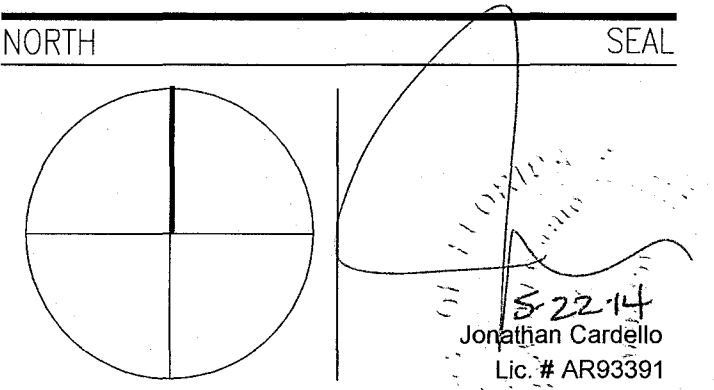

ADD Inc Architecture Interiors Planning

One Biscayne Tower
Suite 1670
Two South
Biscayne Boulevard
Miami, FL 33131
T. 305.482.8700
F. 305.482.8770
www.addinc.com
Lic. # AA25001507

JOB NUMBER: 13036.00
CHECKED BY:
ISSUE DATE: FEBRUARY 18, 2014
SCALE: AS NOTED


SHEET TITLE

**ELEVATOR INTERIOR
FINISHES**


SHEET NUMBER

A603


COPYRIGHT ADD INC 2011

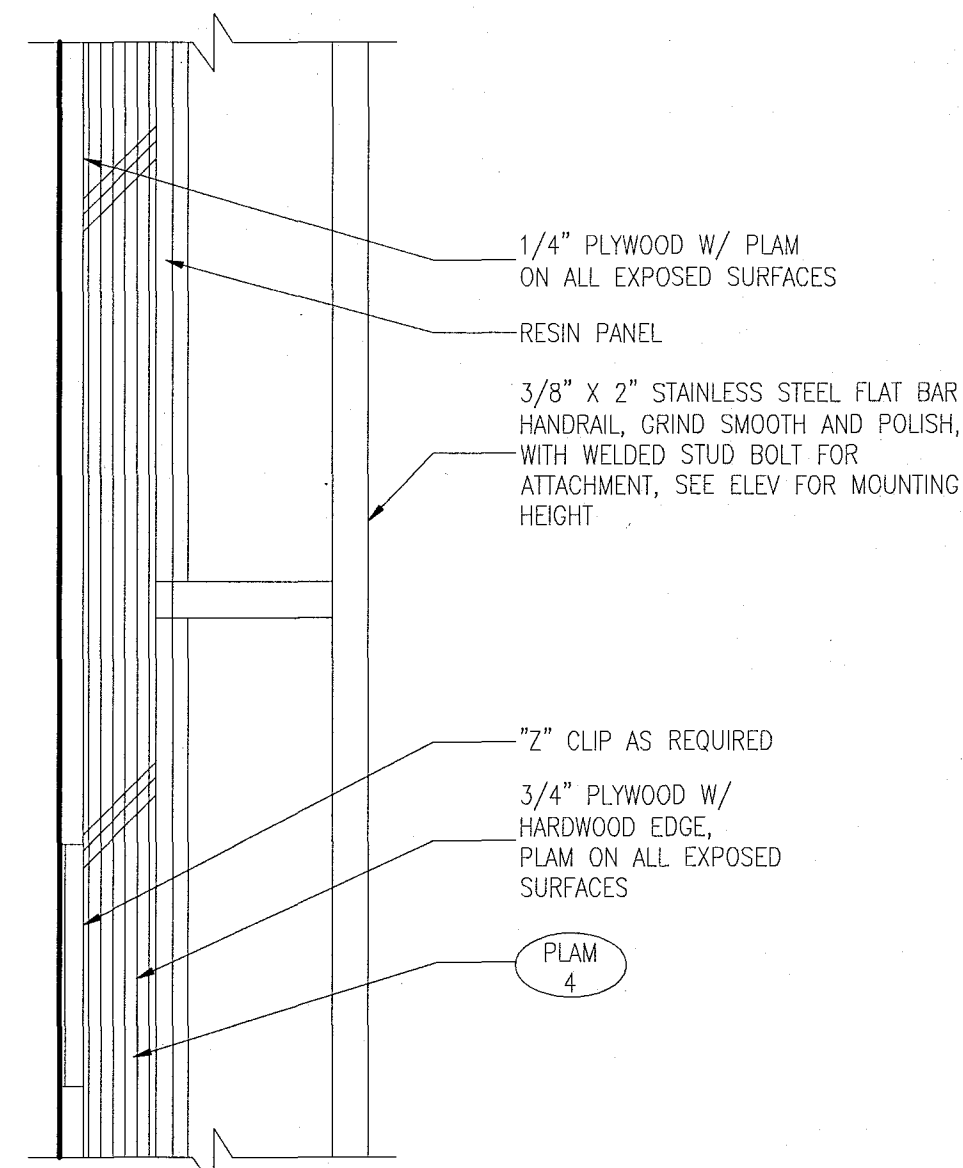


13 PLAN DETAIL @ ELEVATOR No.1 CAB HAND RAIL
SCALE: 6" = 1'-0"

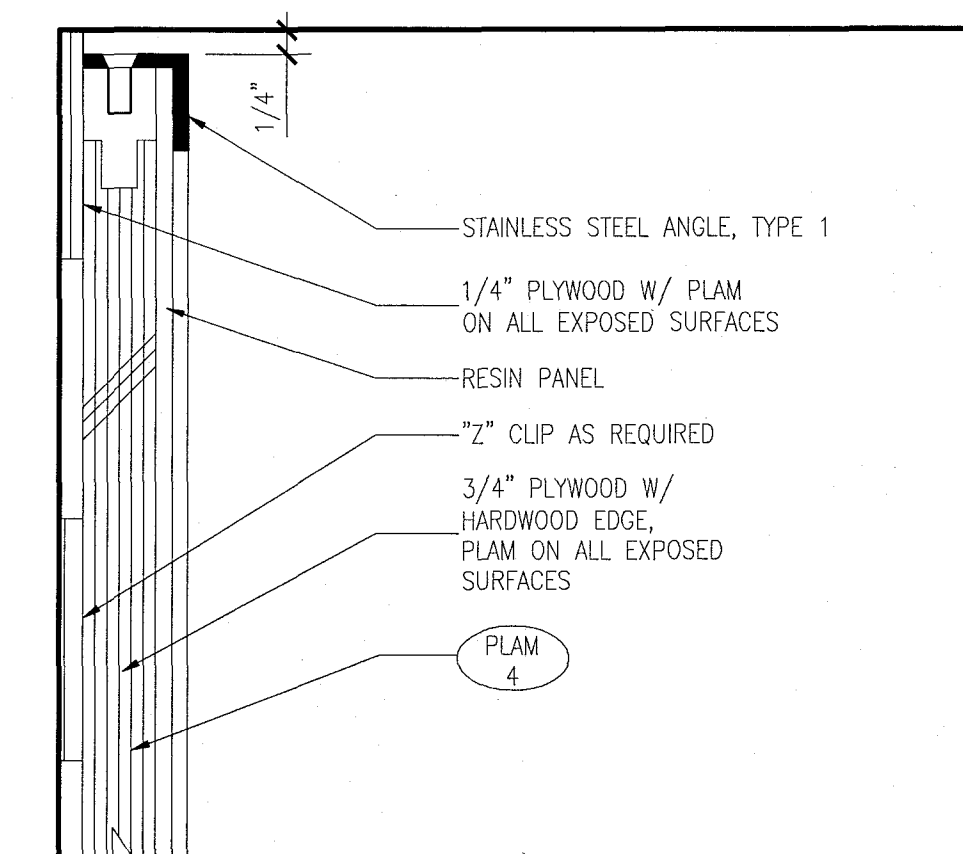


12 PLAN DETAIL @ ELEVATOR No.1 CAB CORNER
SCALE: 6" = 1'-0"

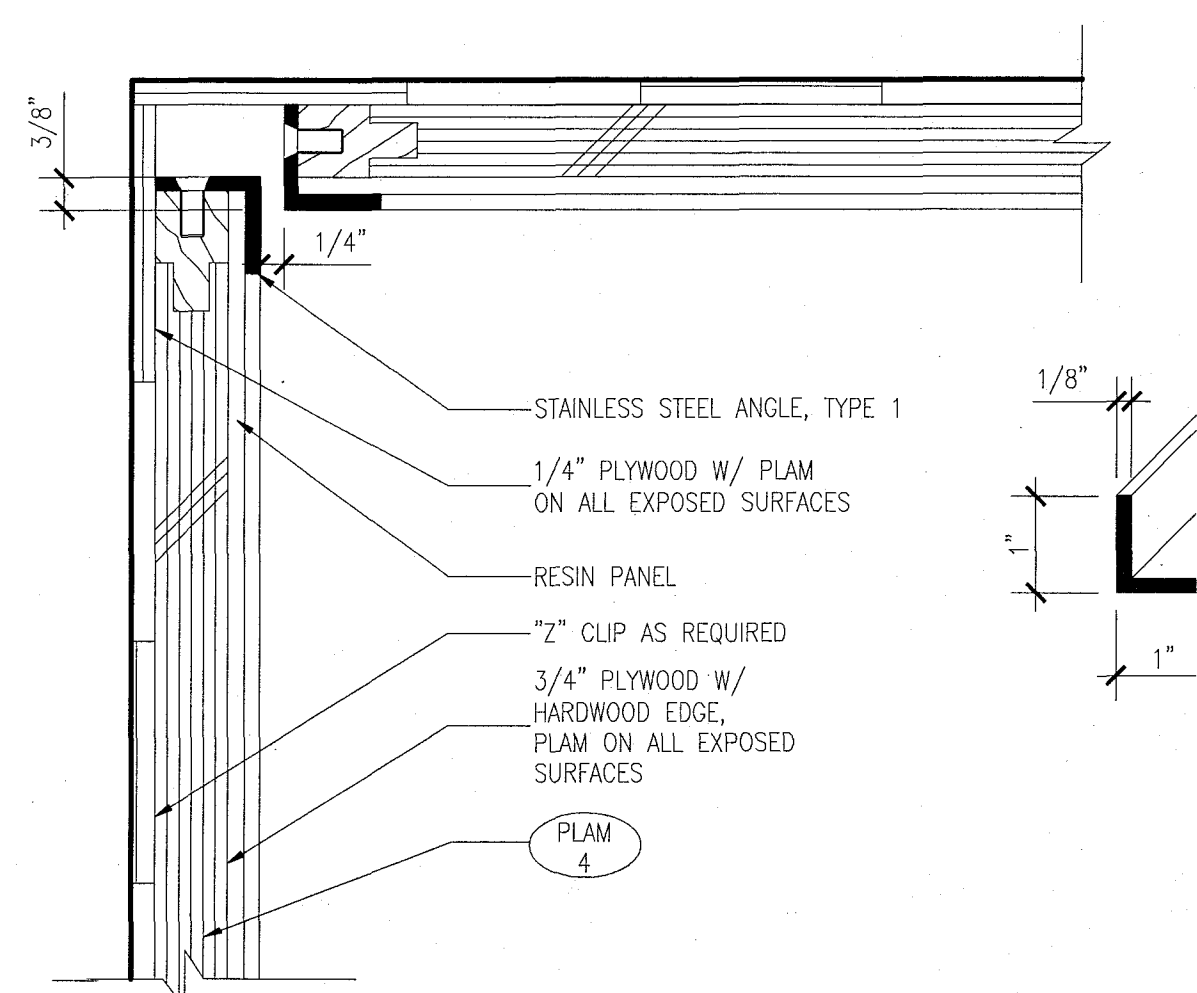


11 PLAN DETAIL @ ELEVATOR No.1 CAB CORNER
SCALE: 6" = 1'-0"

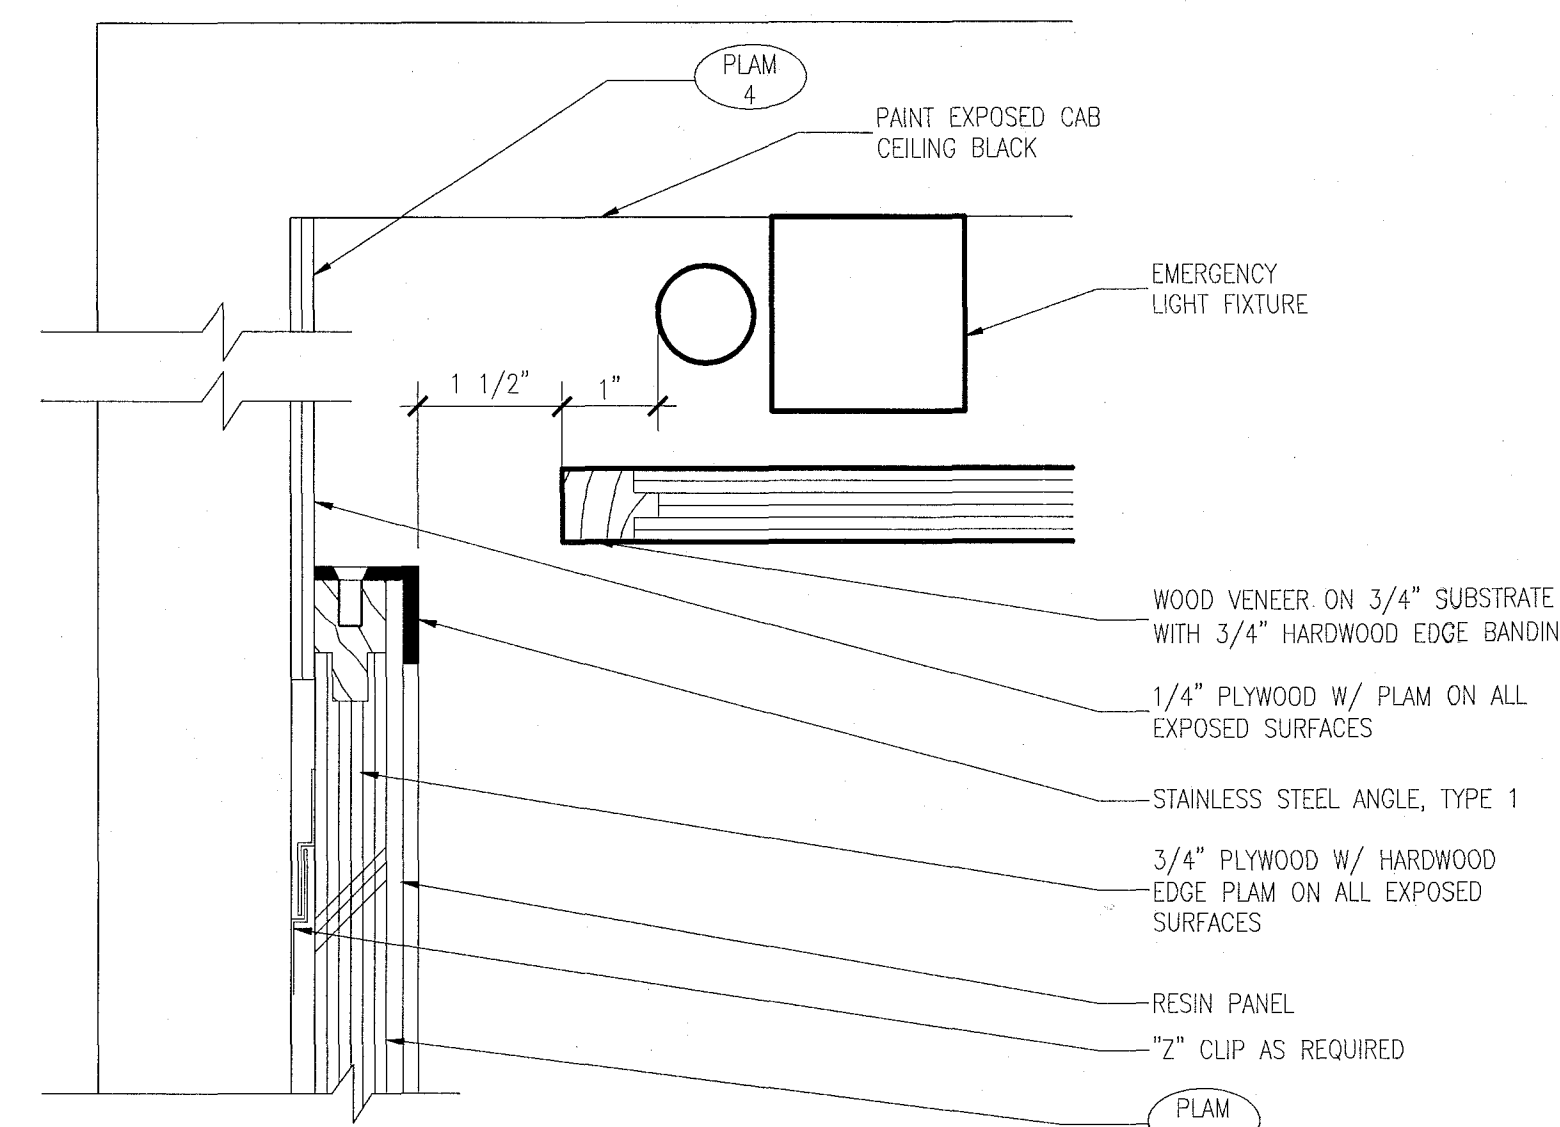


10 DETAIL @ ELEVATOR CAB CEILING
SCALE: 6" = 1'-0"

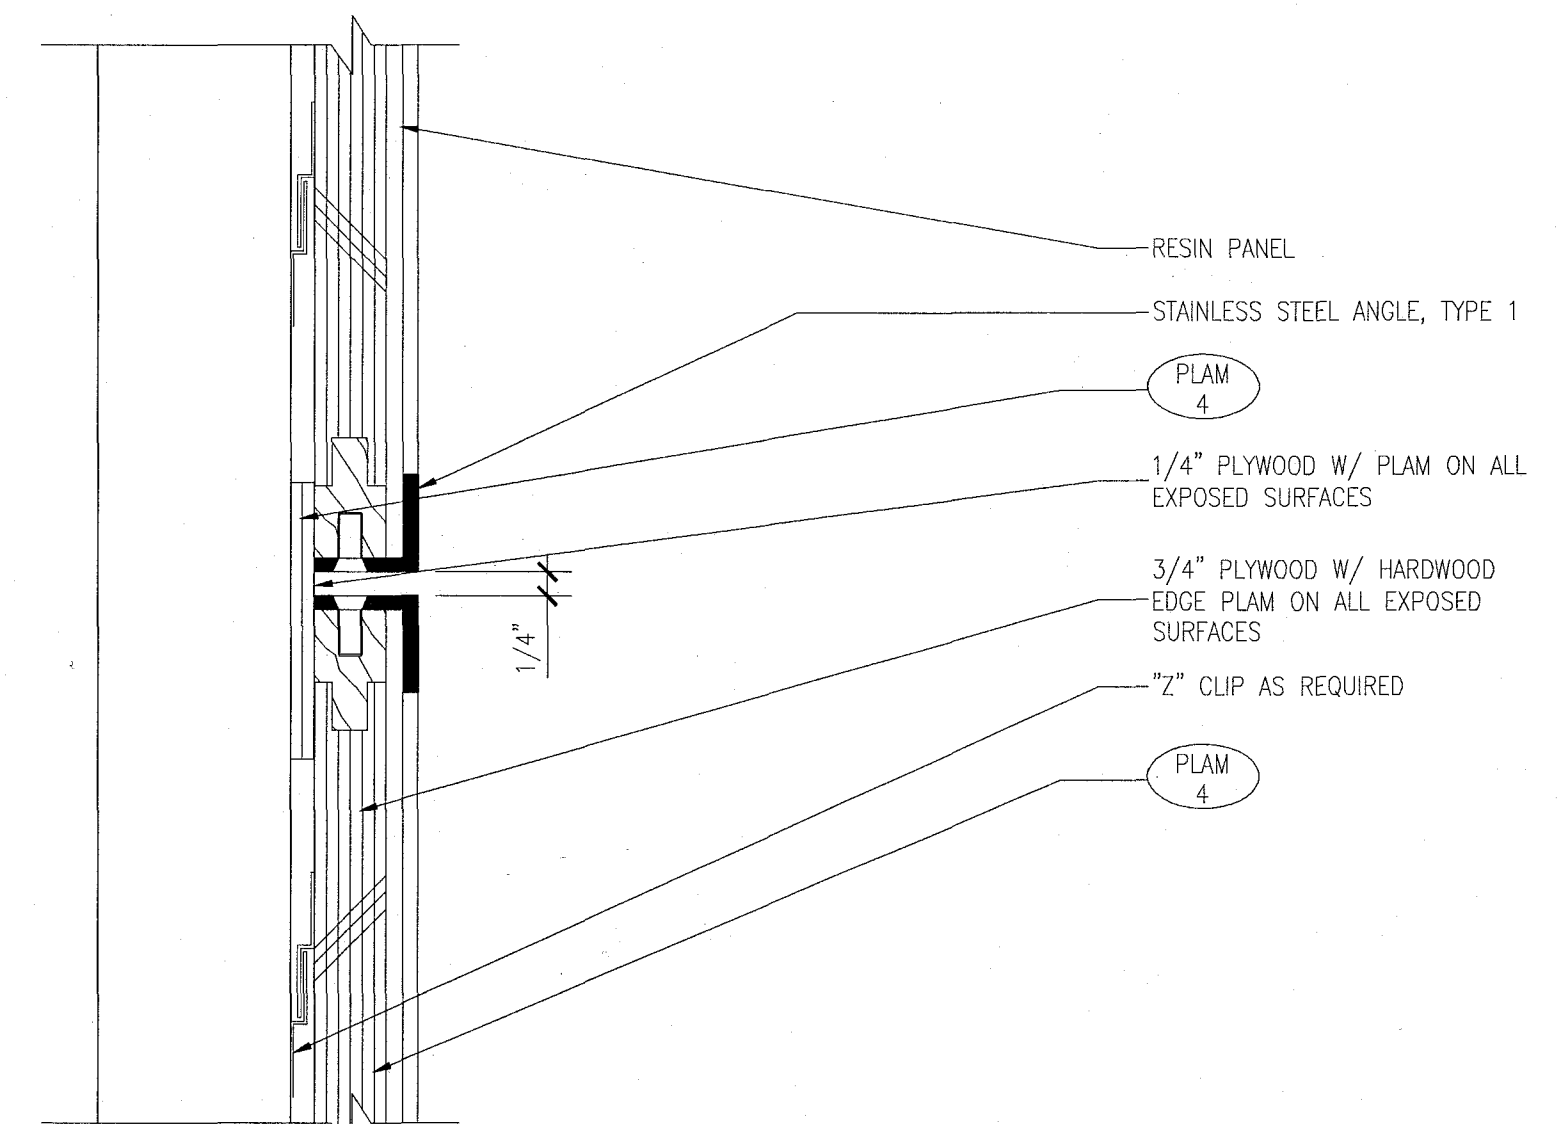


9 DETAIL @ ELEVATOR CAB PANEL REVEAL
SCALE: 6" = 1'-0"

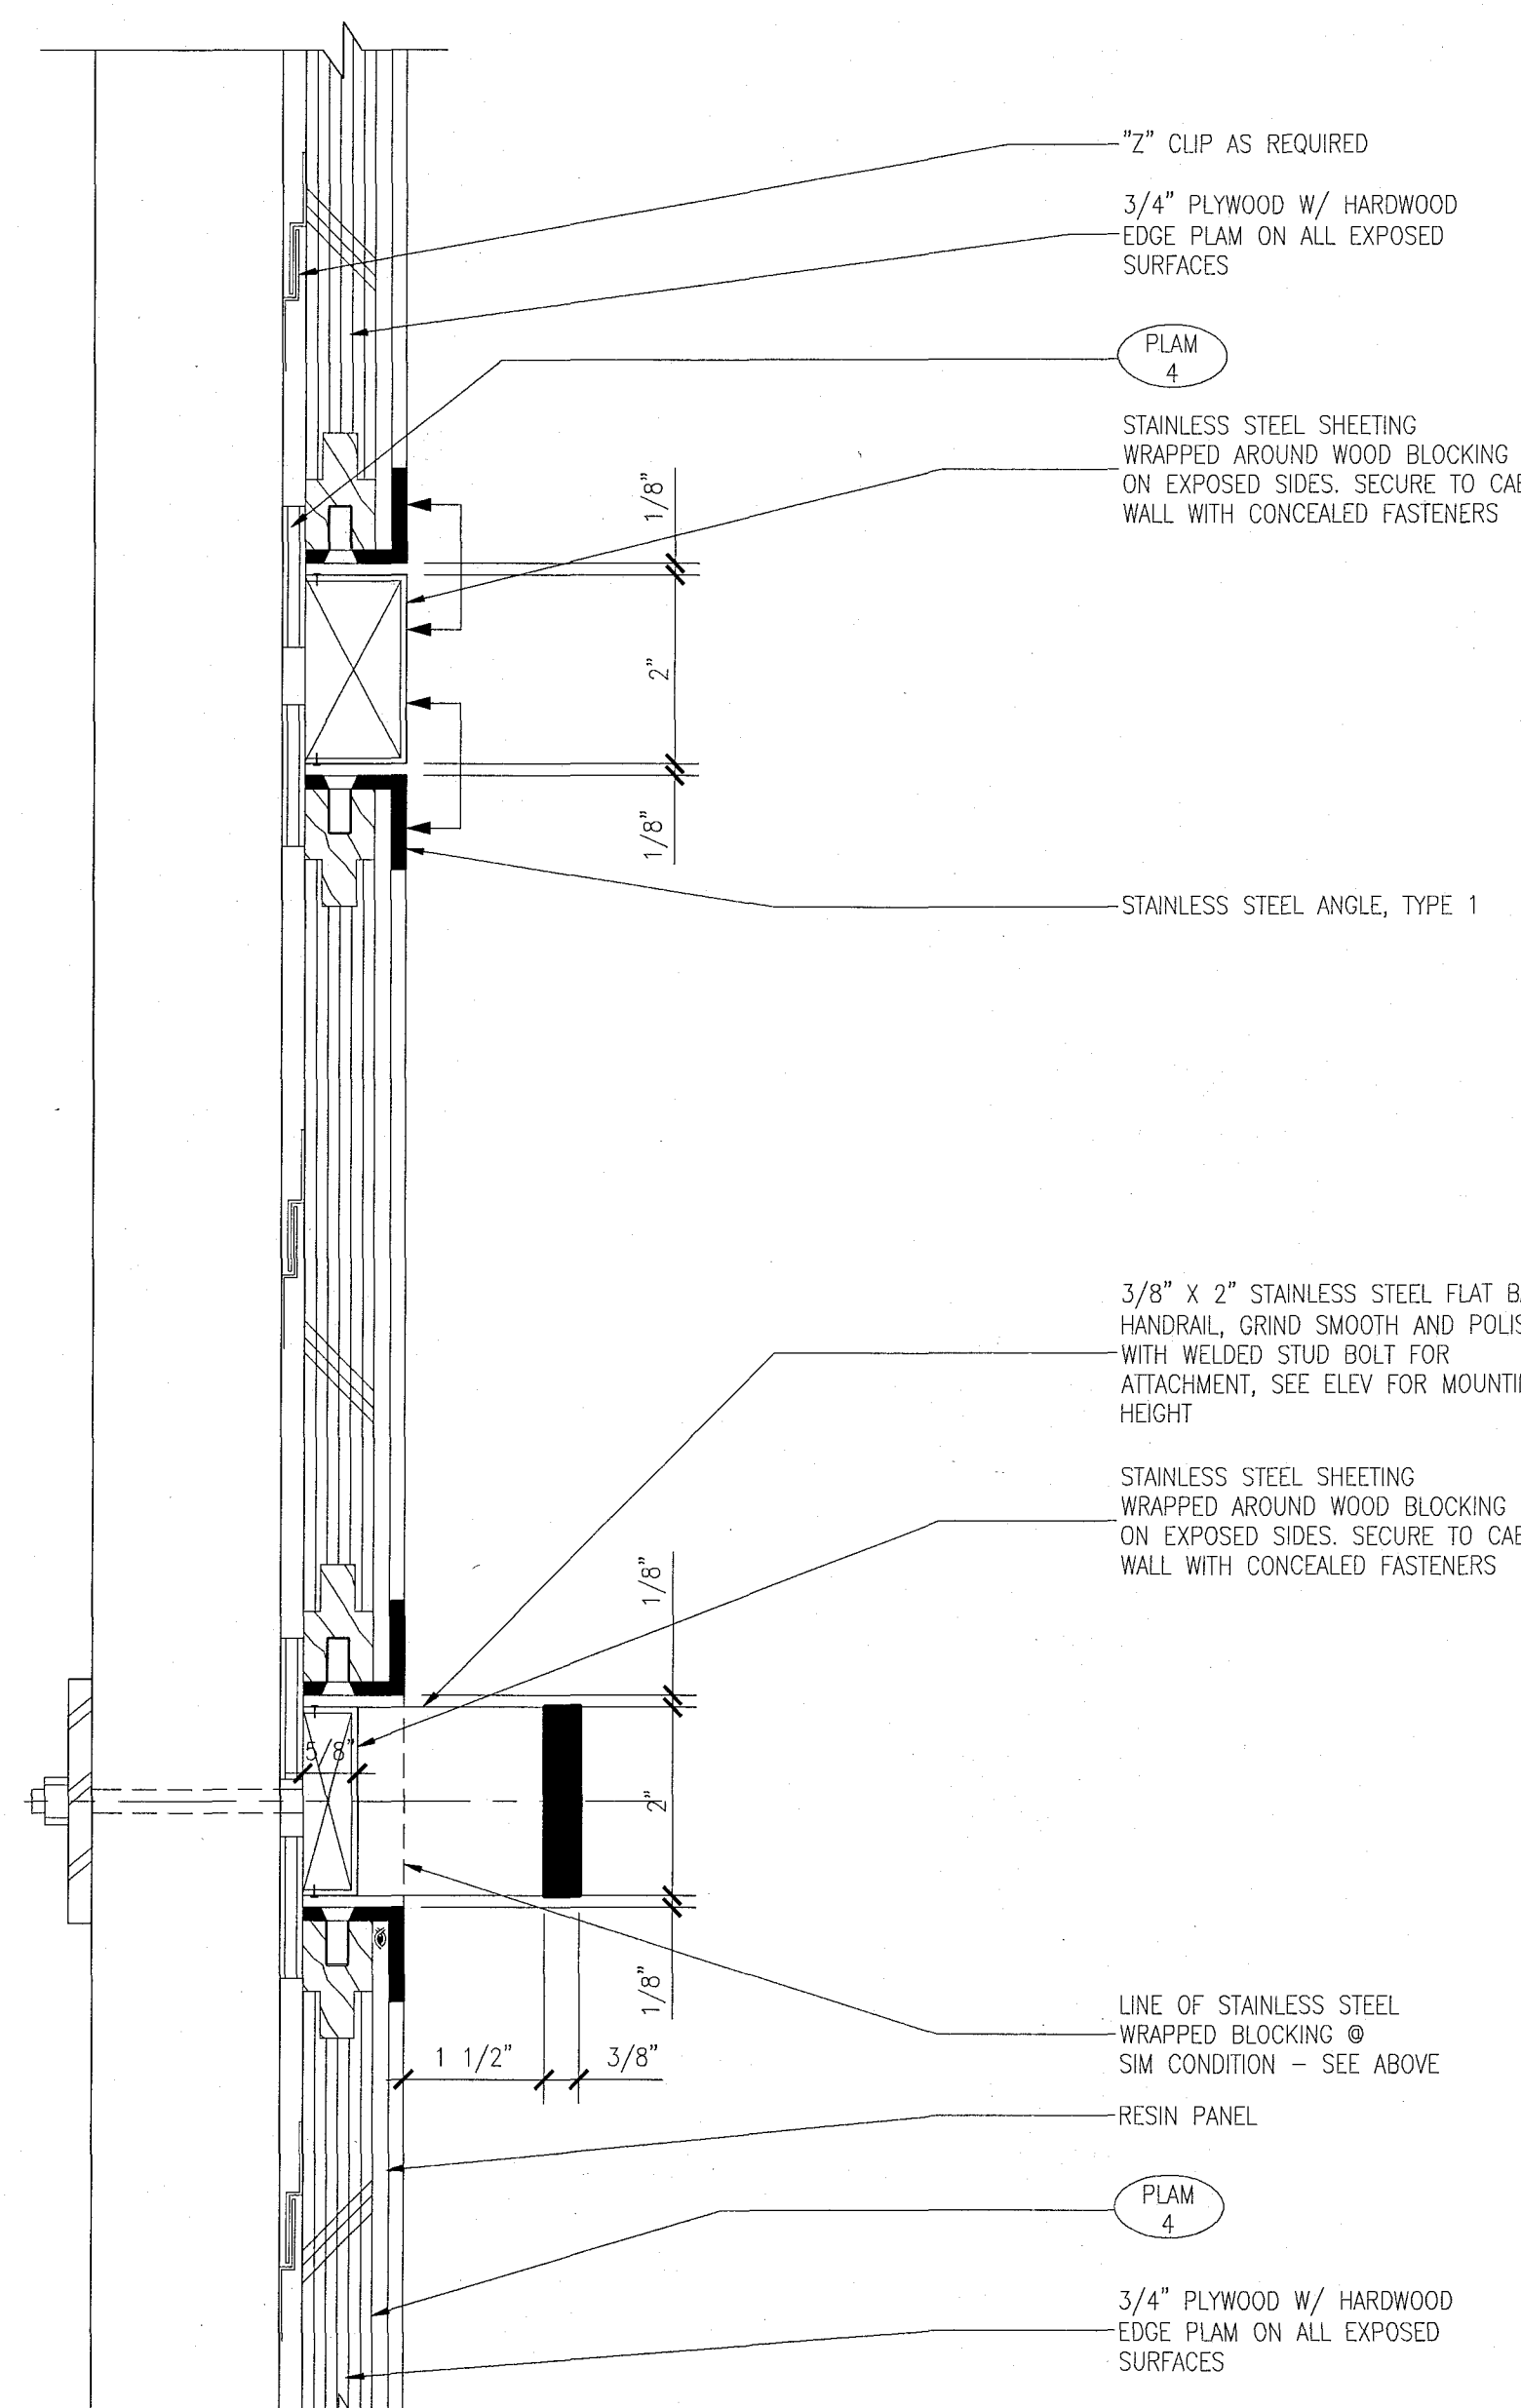


8 SECTION @ ELEVATOR CAB HAND RAIL & REVEAL
SCALE: 6" = 1'-0"

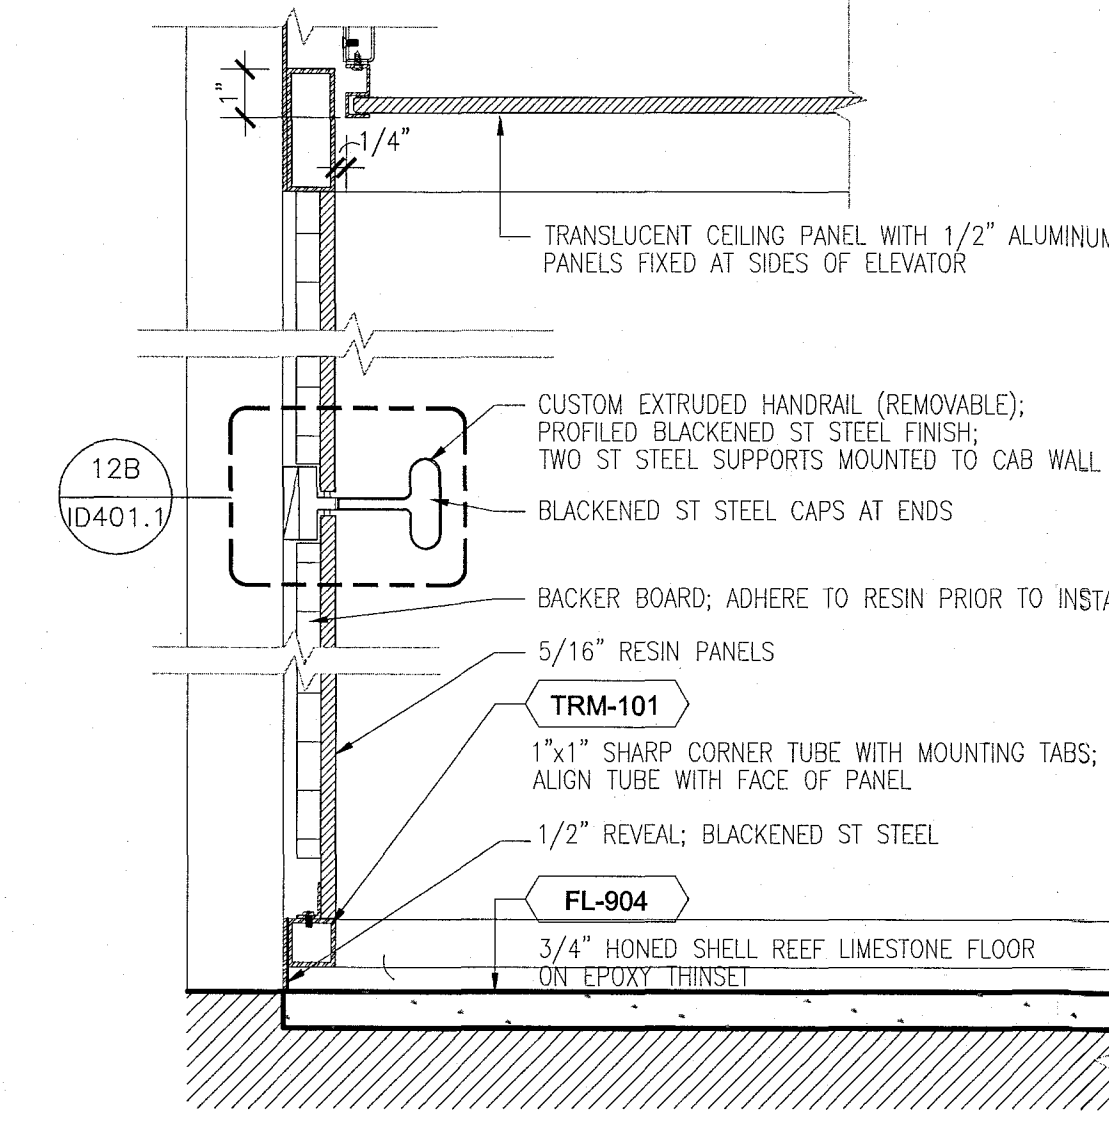


1 SECTION AT RESIN PANEL (PASSENGER)
SCALE: 3" = 1'-0"

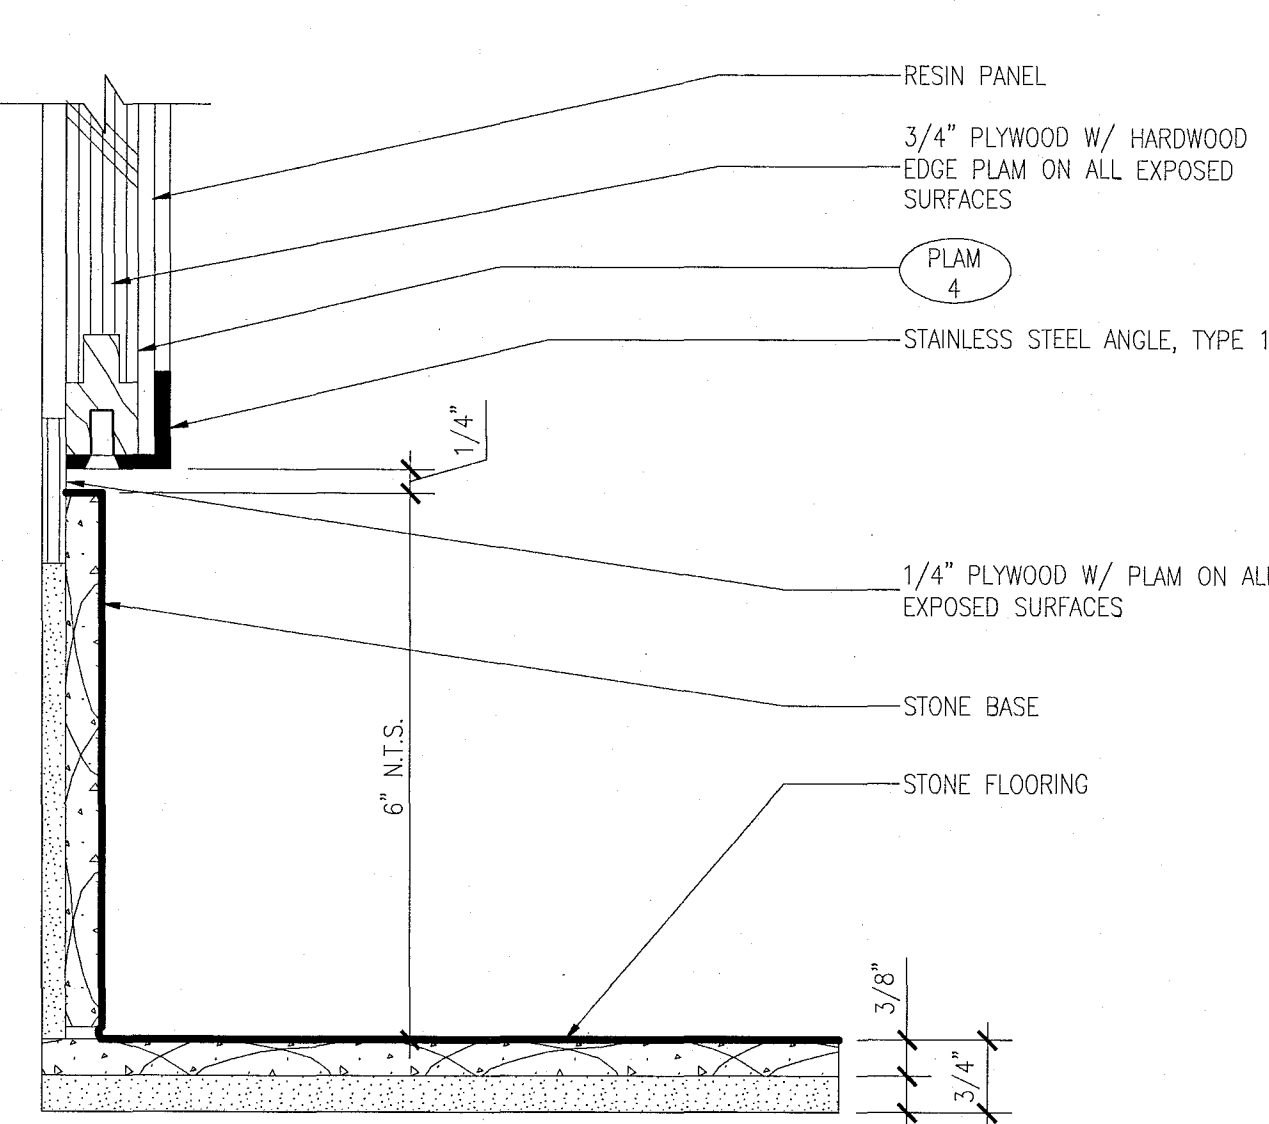

7 DETAIL @ ELEVATOR No.1 CAB BASE
SCALE: 6" = 1'-0"

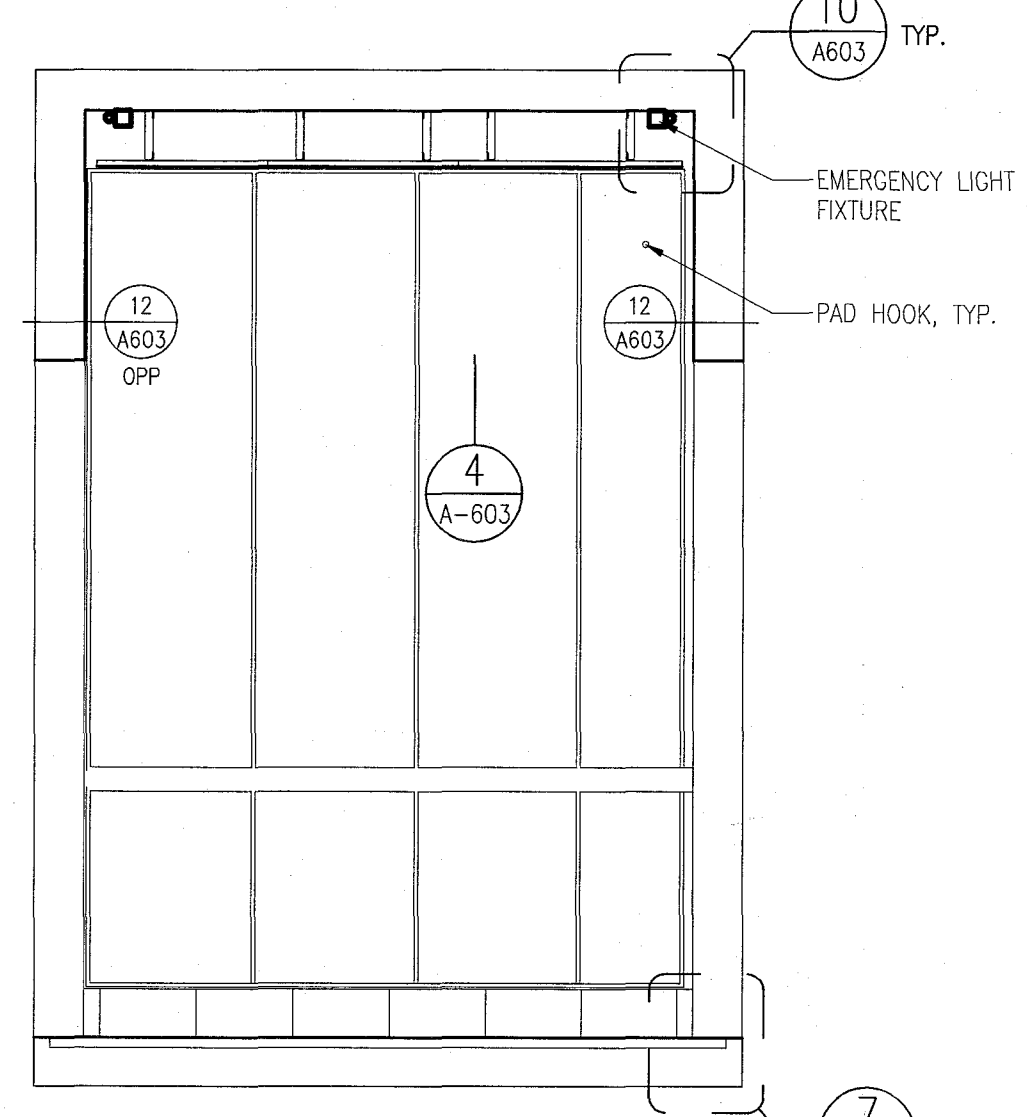


6 SIDE ELEVATION @ ELEVATOR CABS 1
SCALE: 1/2" = 1'-0"

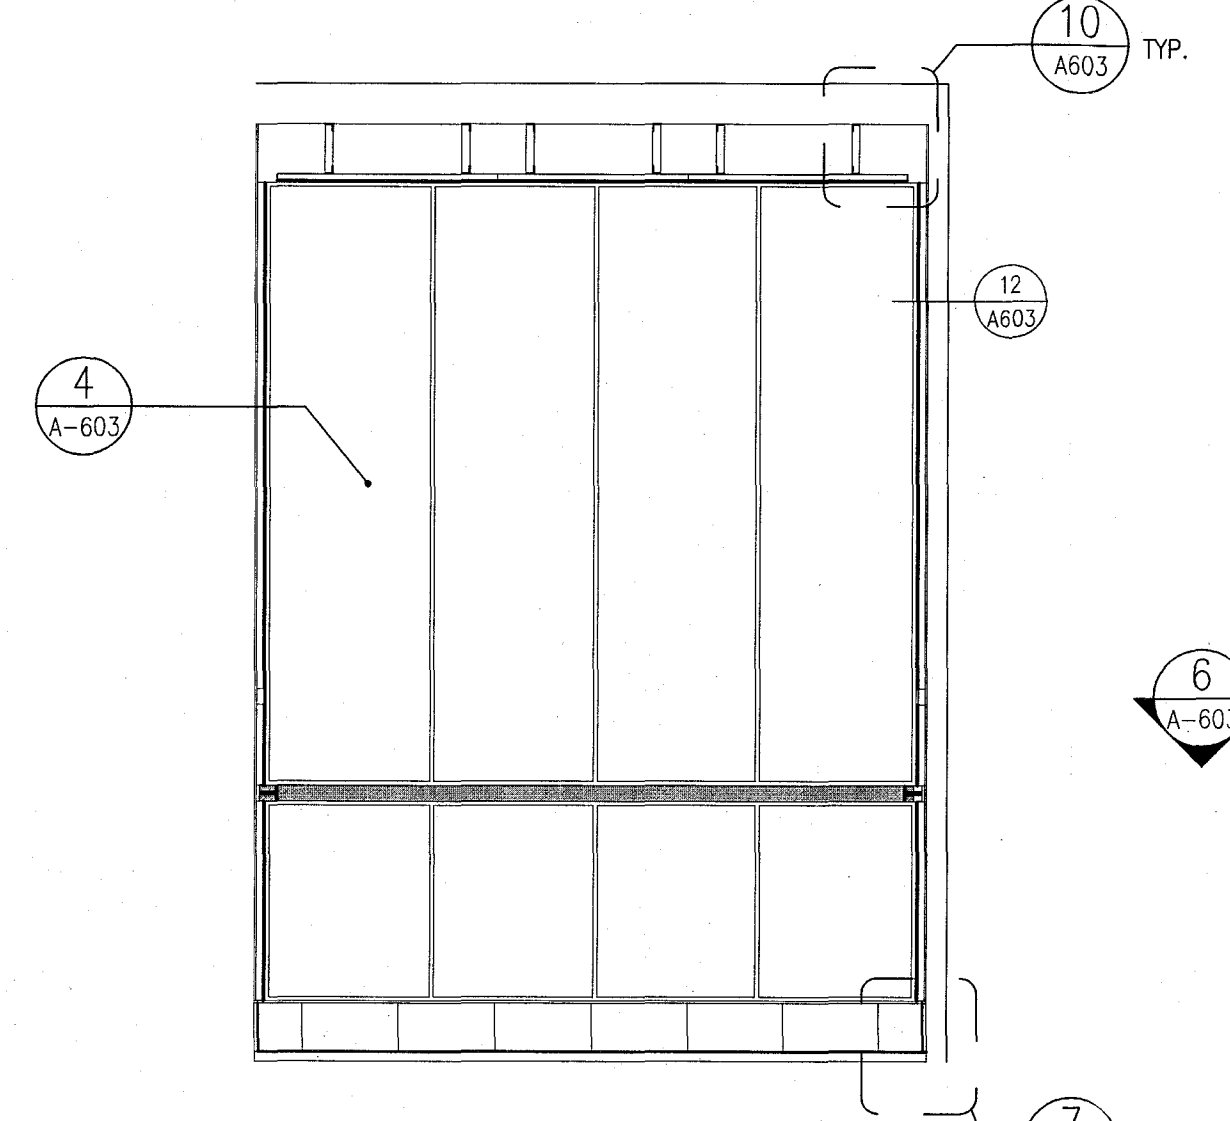


5 REAR ELEVATION @ ELEVATOR CABS 1 & 3
SCALE: 1/2" = 1'-0"


4 FRONT ELEVATION @ ELEVATOR CAB 1
SCALE: 1/2" = 1'-0"

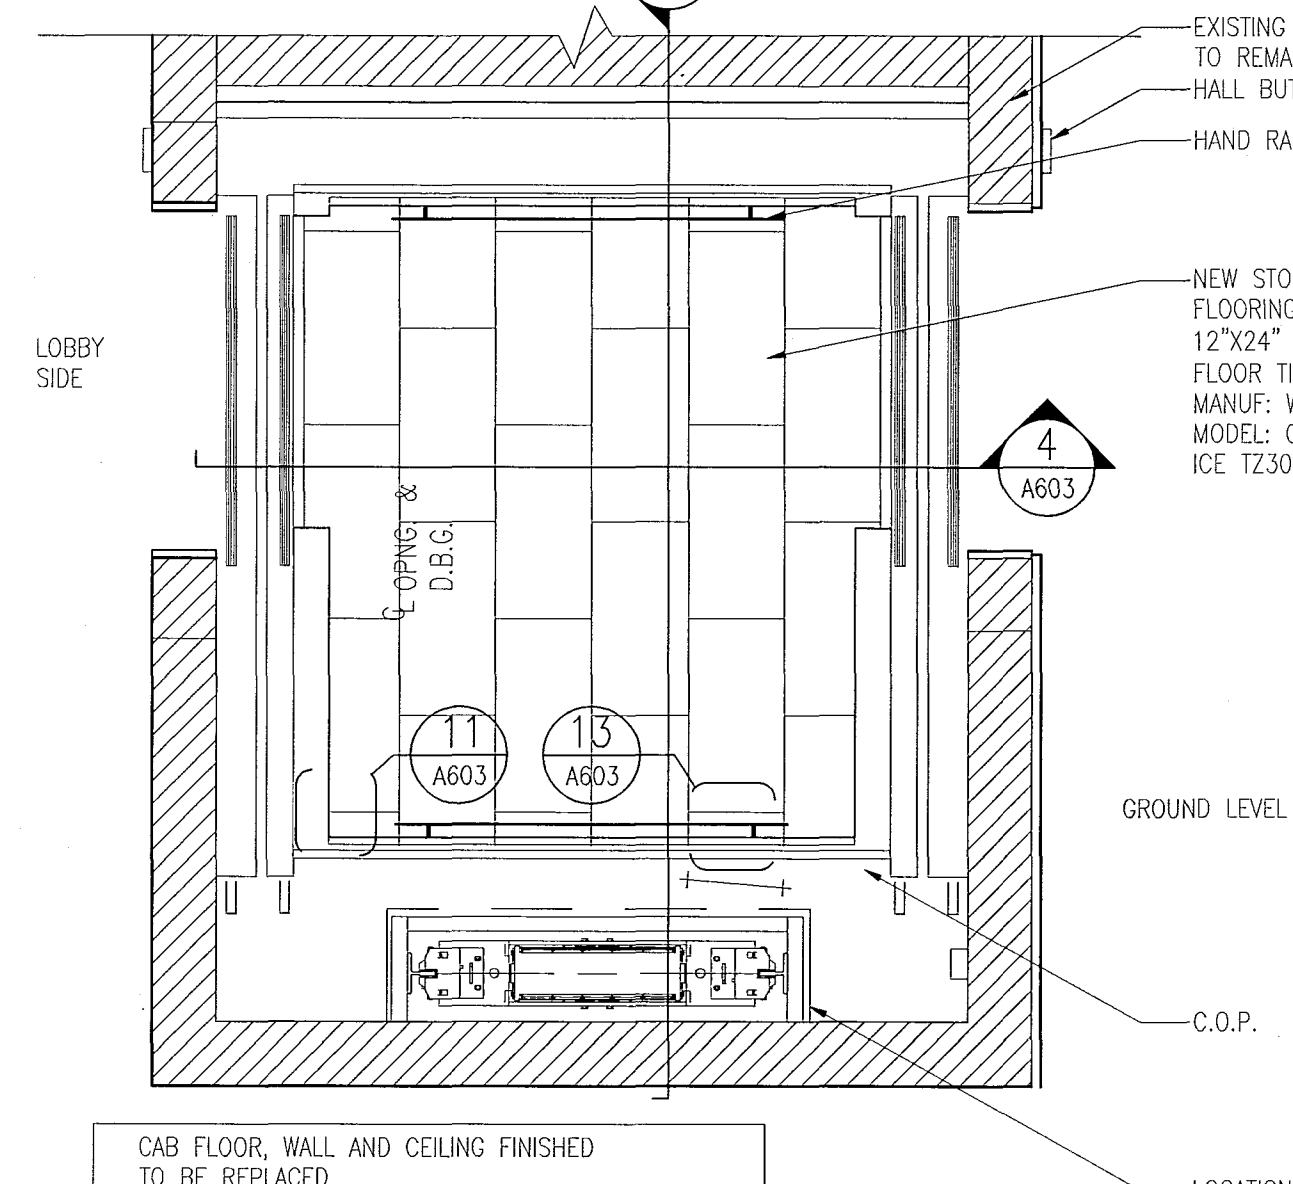

3 PLAN @ ELEVATOR CABS 2
SCALE: 1 1/2" = 1'-0"

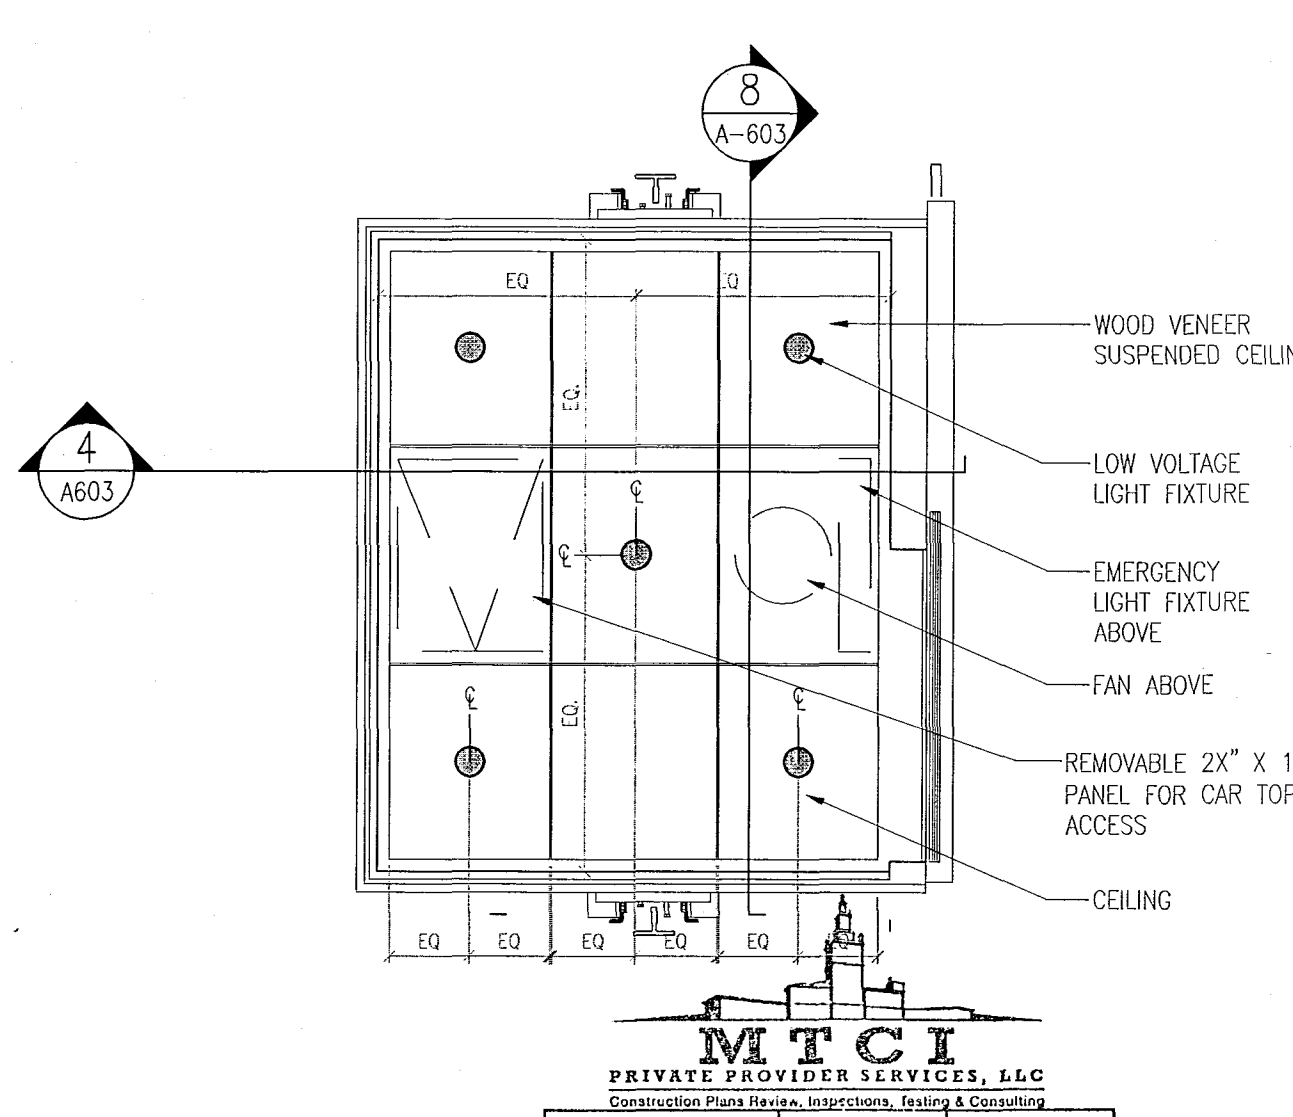

2 RCP @ ELEVATOR CABS 1 & 3
SCALE: 1/2" = 1'-0"

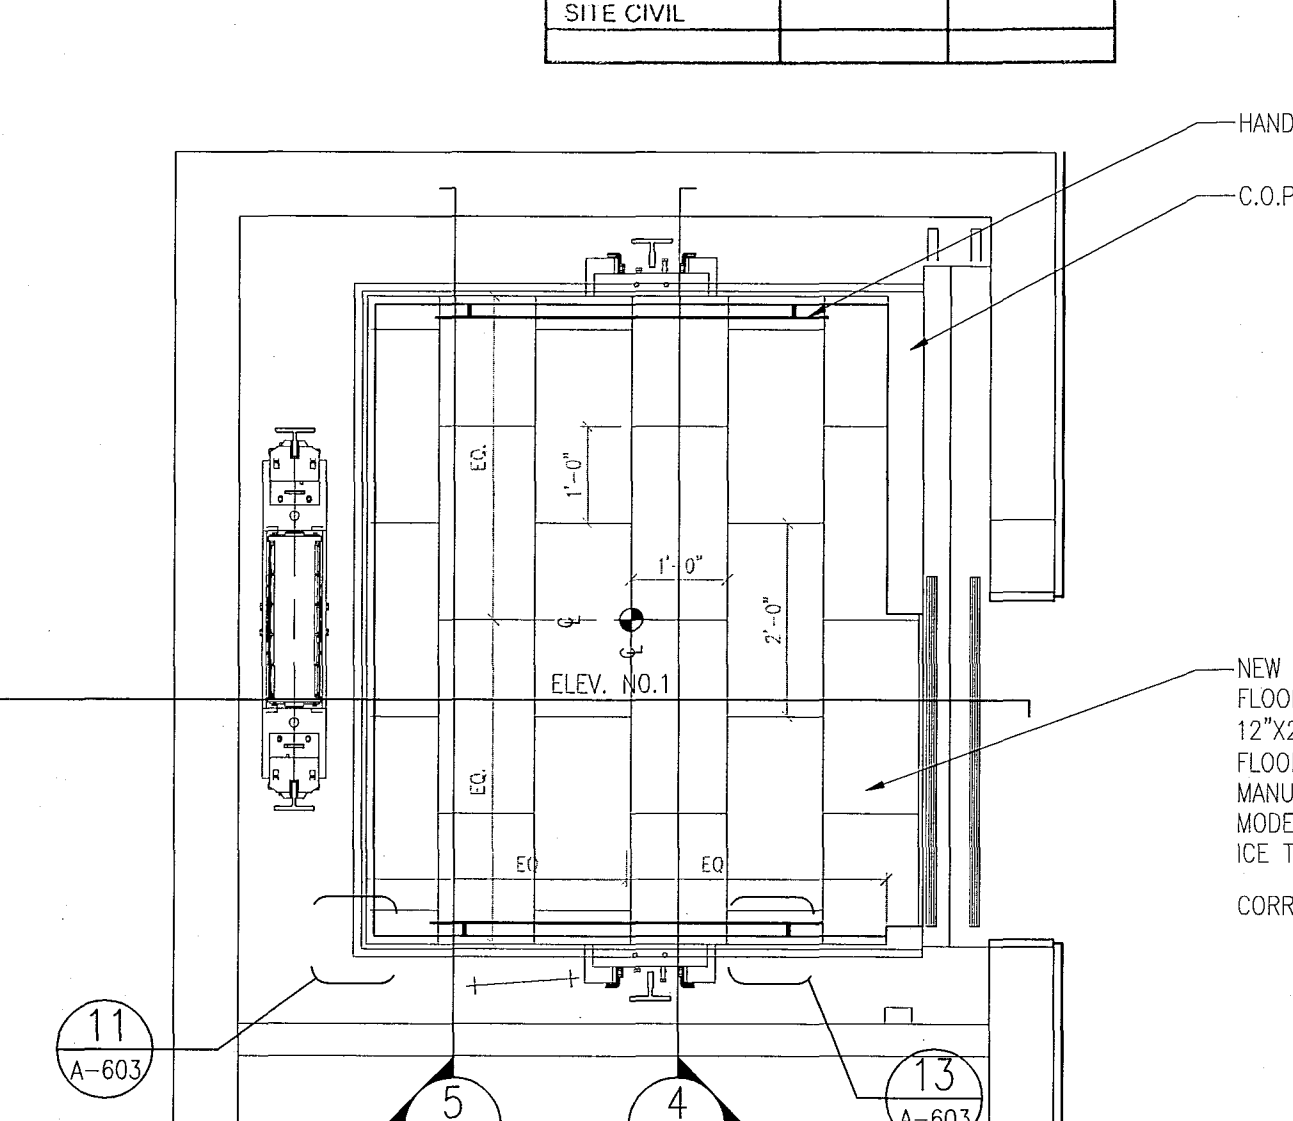

1 PLAN @ NEW ELEVATOR CABS No.1 - POOL SUITES
SCALE: 1/2" = 1'-0"

APPROVED
MIAMI BEACH
FIRE DEPARTMENT

MIAMI BEACH, FL

T.S.[illegible]

SEAL

Architecture Interiors Planning

One Biscayne Tower
Suite 1670
Two South
Biscayne Boulevard
Miami, Fl 33131
T. 305.482.8700
F. 305.482.8770
www.addinc.com
Lic. # AA28001507

Boston Miami

13036.00

FEBRUARY 18, 2014

$$\overline{1/4'' = 1' - 0''}$$






















SHEET TITLE

STAIR PLANS AT HADDON HALL

SHEET NUMBER _____

A611

COPYRIGHT ADD INC 2011

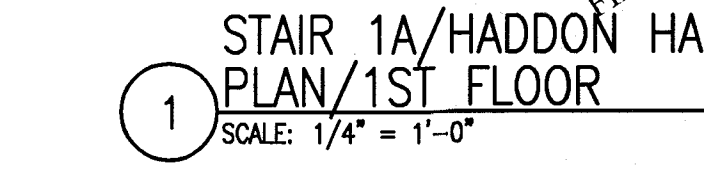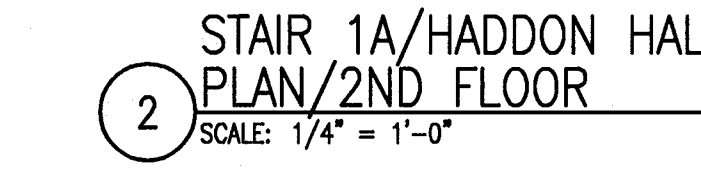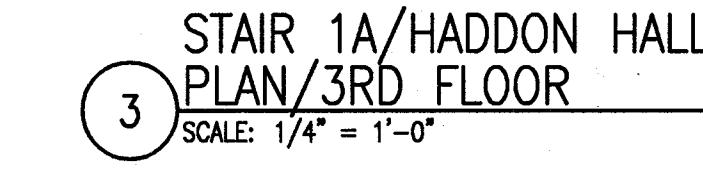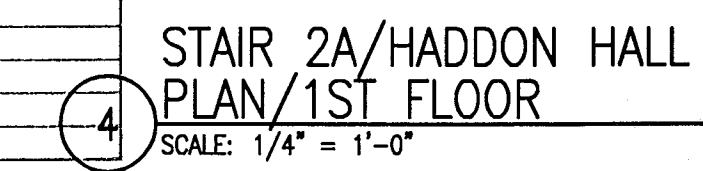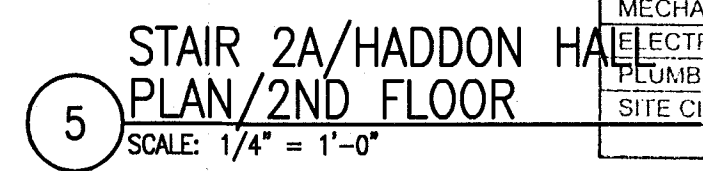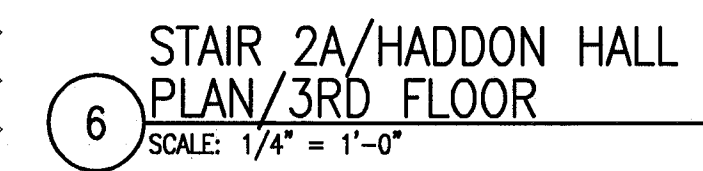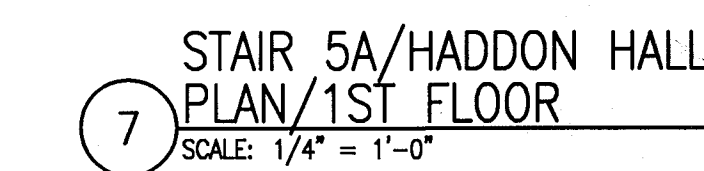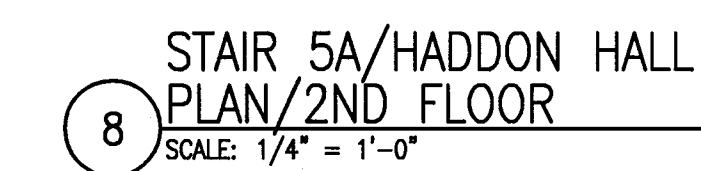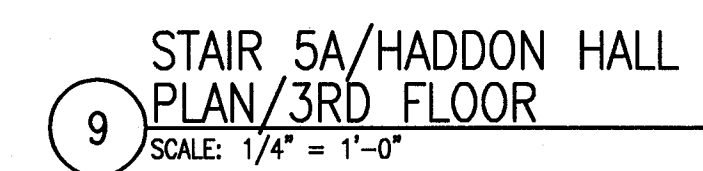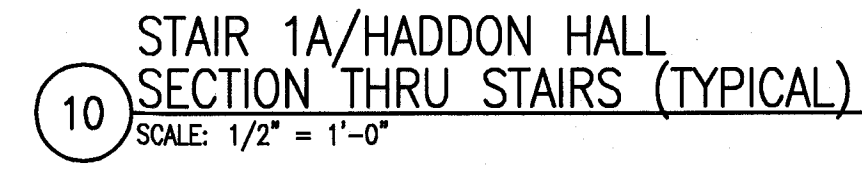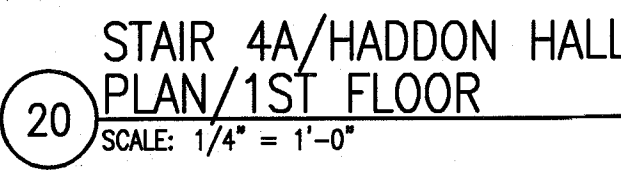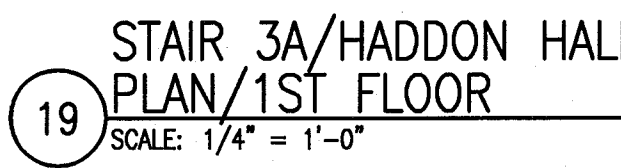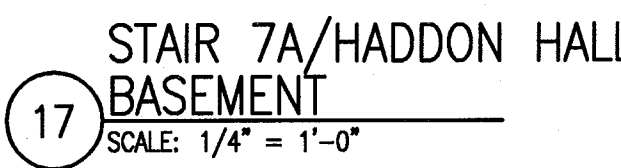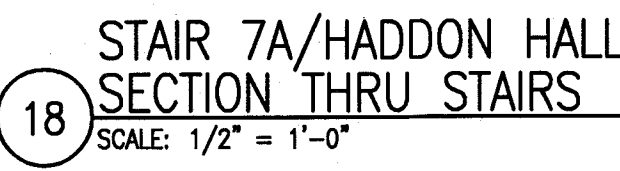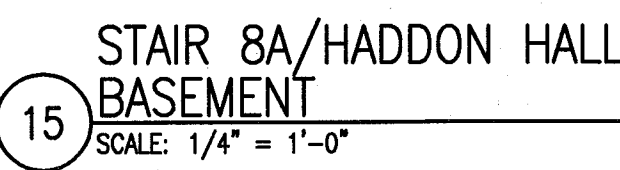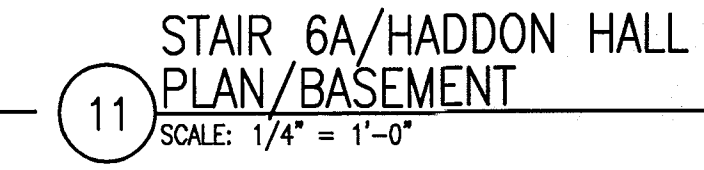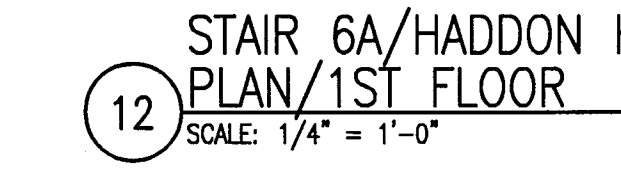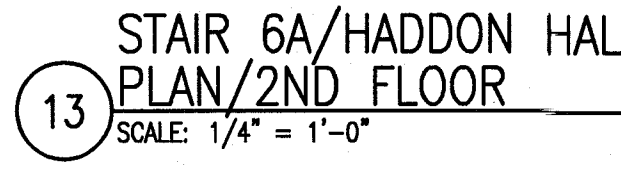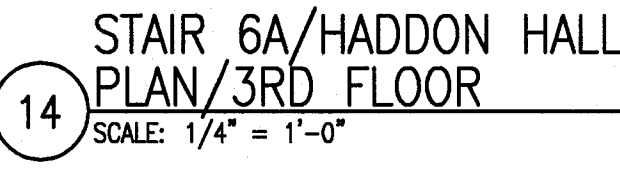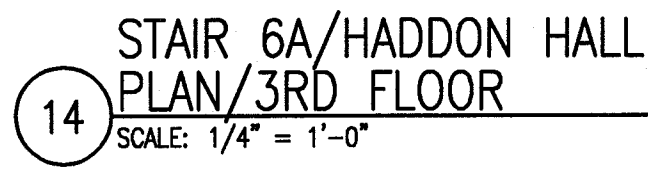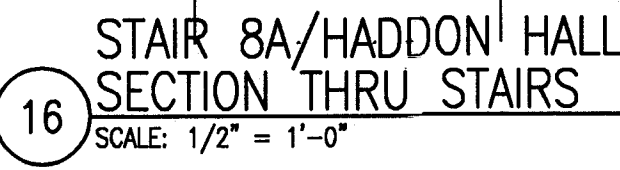

 PRIVATE PROVIDER SERVICES, LLC <i>Construction Plans Review, Inspection, Testing & Cost Estimating</i>		
	REVIEWER INITIALS	DATE REVIEWED
BUILDING	EM	11-20-14
STRUCTURAL		
MECHANICAL		
ELECTRICAL		
PLUMBING		
SITE CIVIL		

HADDON HALL 1500 COLLINS AVE MIAMI BEACH, FL

KEYPLAN N.T.S.

REVISIONS		
NO.	DESCRIPTION	ISSUE DATE
2	PERMIT REVIEW COMMENTS	03-14-2014
4	FIRE REVIEW COMMENTS	04-01-2014
5	GUESTROOM COORDINATION	03-14-2014

100% CONSTRUCTION DOCUMENT SET

SEAL
6-22-14
Jonathan Cardello
Lic. # AFS3391

ADD Inc Architecture Interiors Planning

One Biscayne Tower
Suite 1070
Two South
Biscayne Boulevard
Miami, FL 33131
T. 305.482.8700
F. 305.482.8770
www.addinc.com
Lic. # AA25001507

JOB NUMBER: 13036.00
CHECKED BY:
ISSUE DATE: FEBRUARY 18, 2014
SCALE: 1/4" = 1'-0"


SHEET TITLE

STAIR PLANS
AT CAMPTON


SHEET NUMBER

A612


COPYRIGHT ADD INC 2011

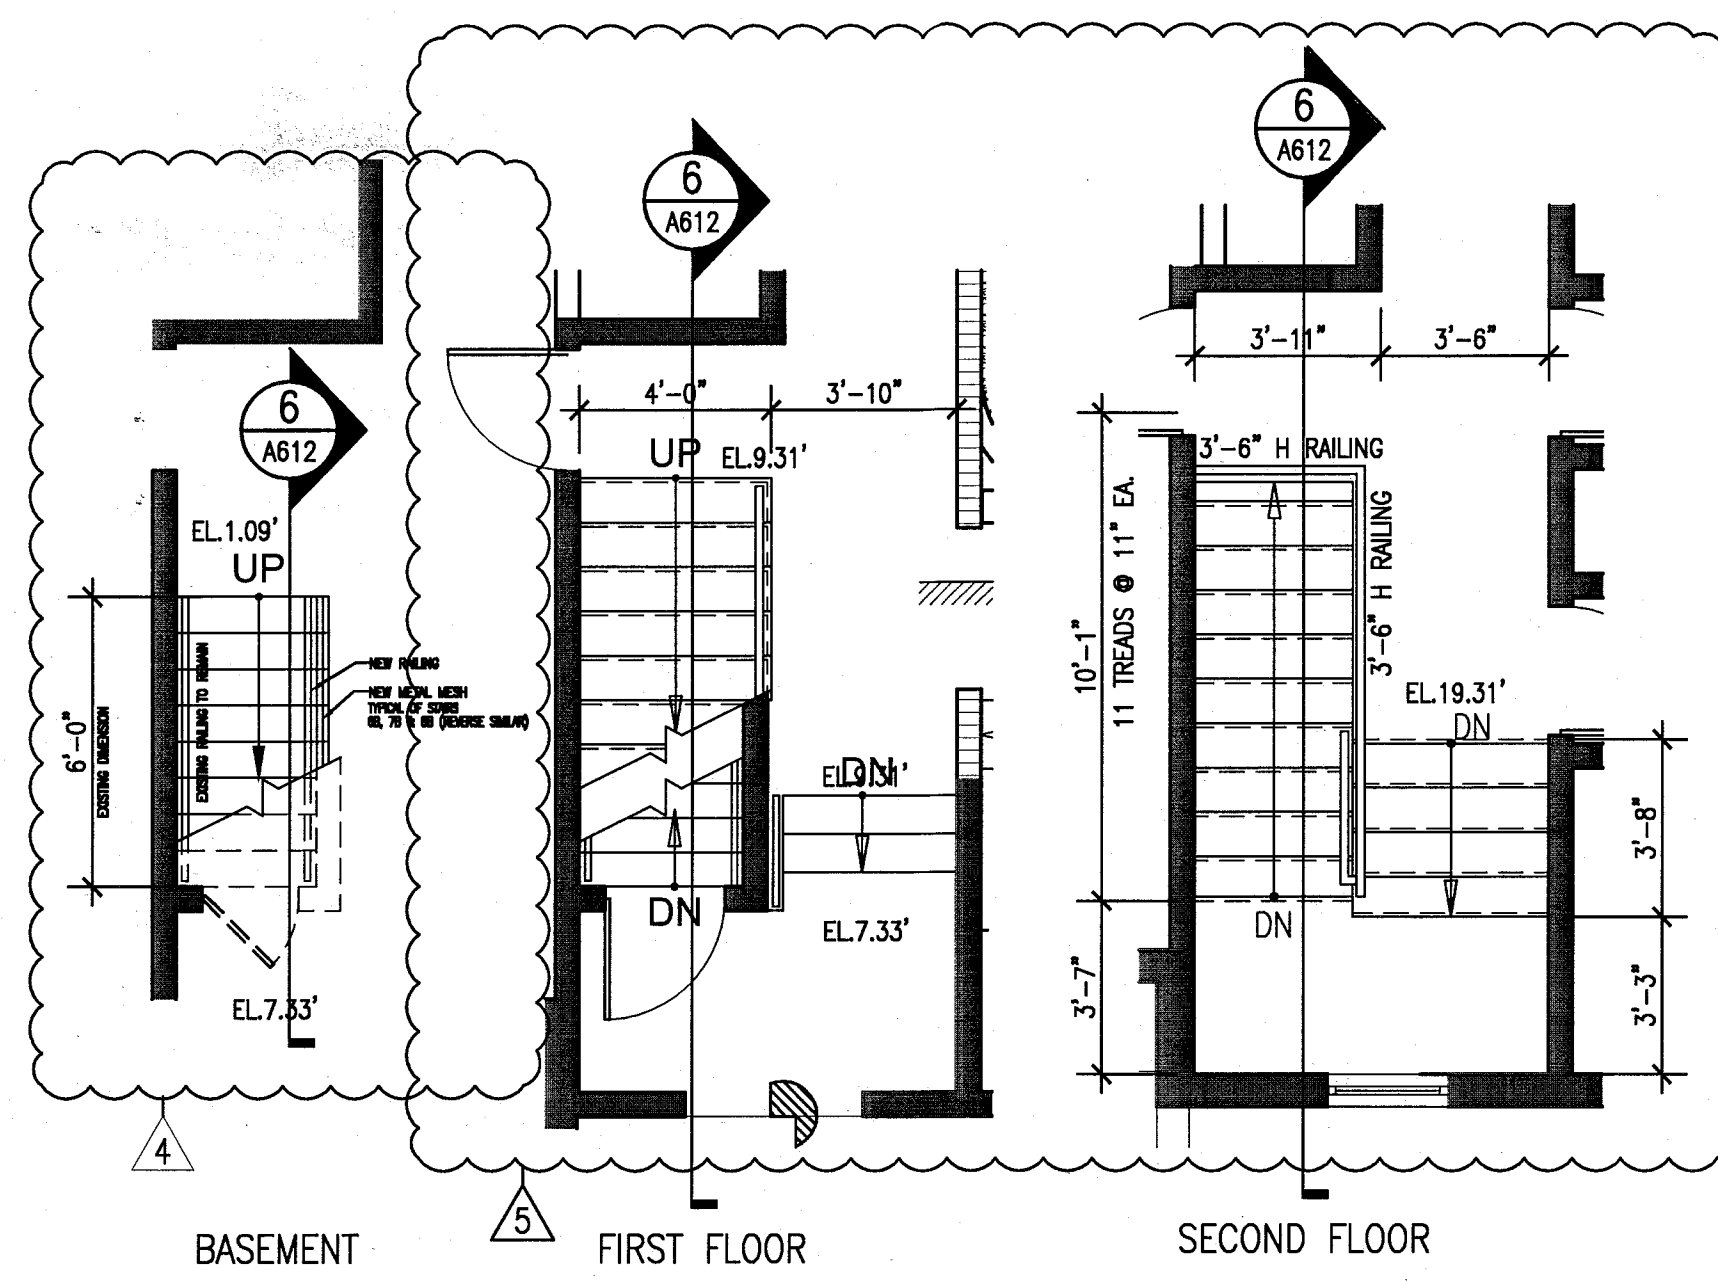


1 STAIR 6B & 11B (4B & 7B REV.SIM.)
CAMPTON/ PLANS
SCALE: 1/4" = 1'-0"

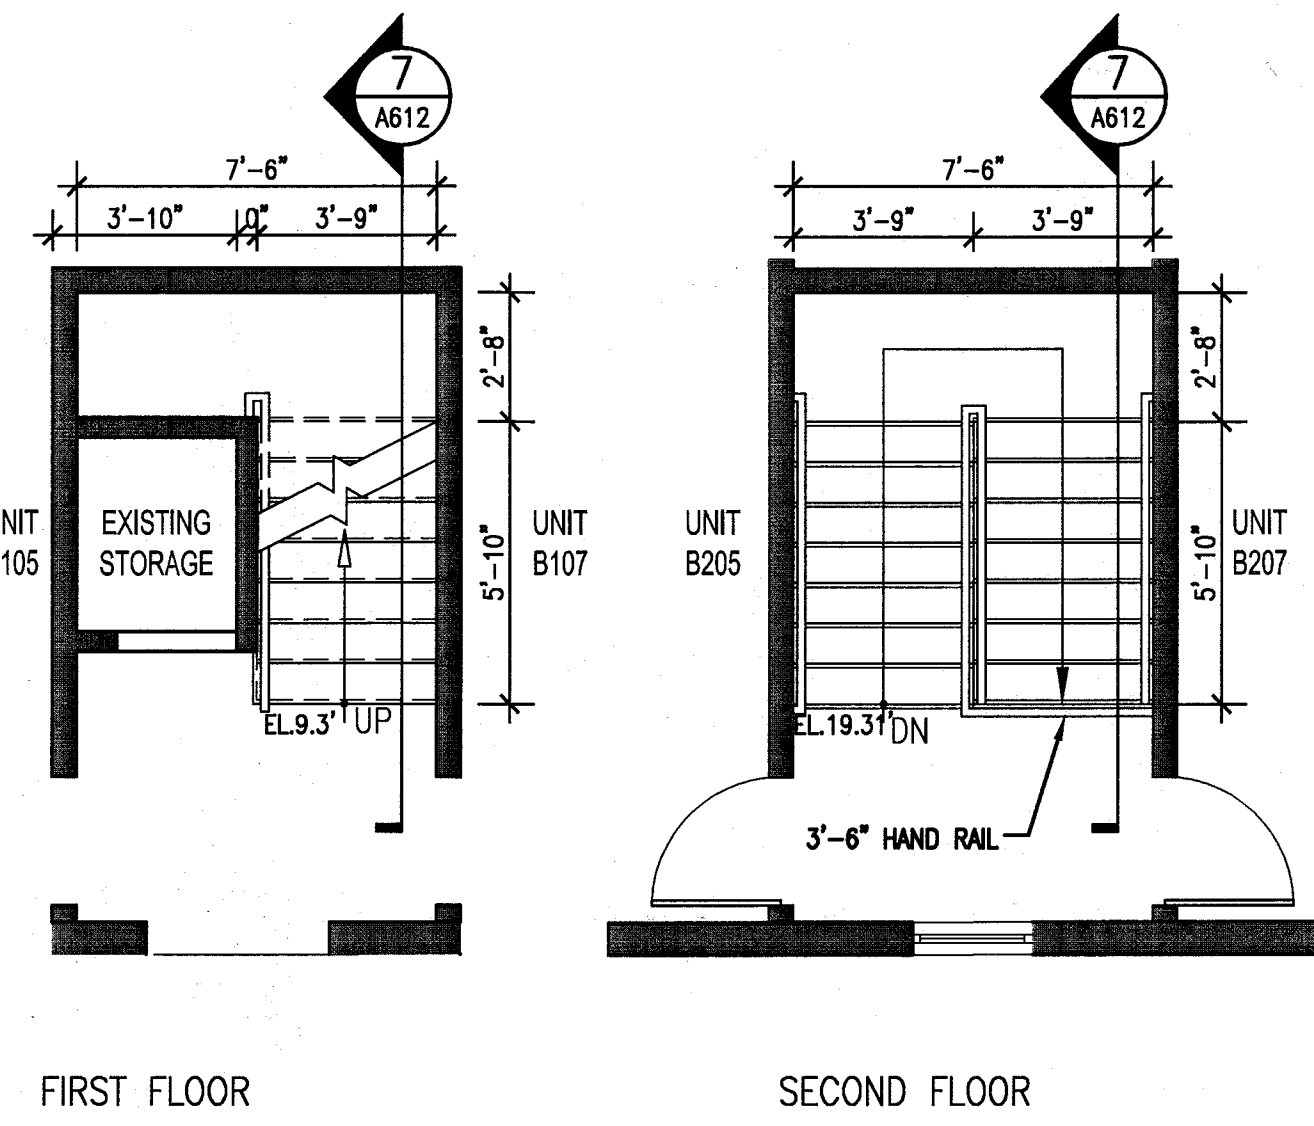


2 STAIR 5B & 10B
CAMPTON/ PLAN
SCALE: 1/4" = 1'-0"

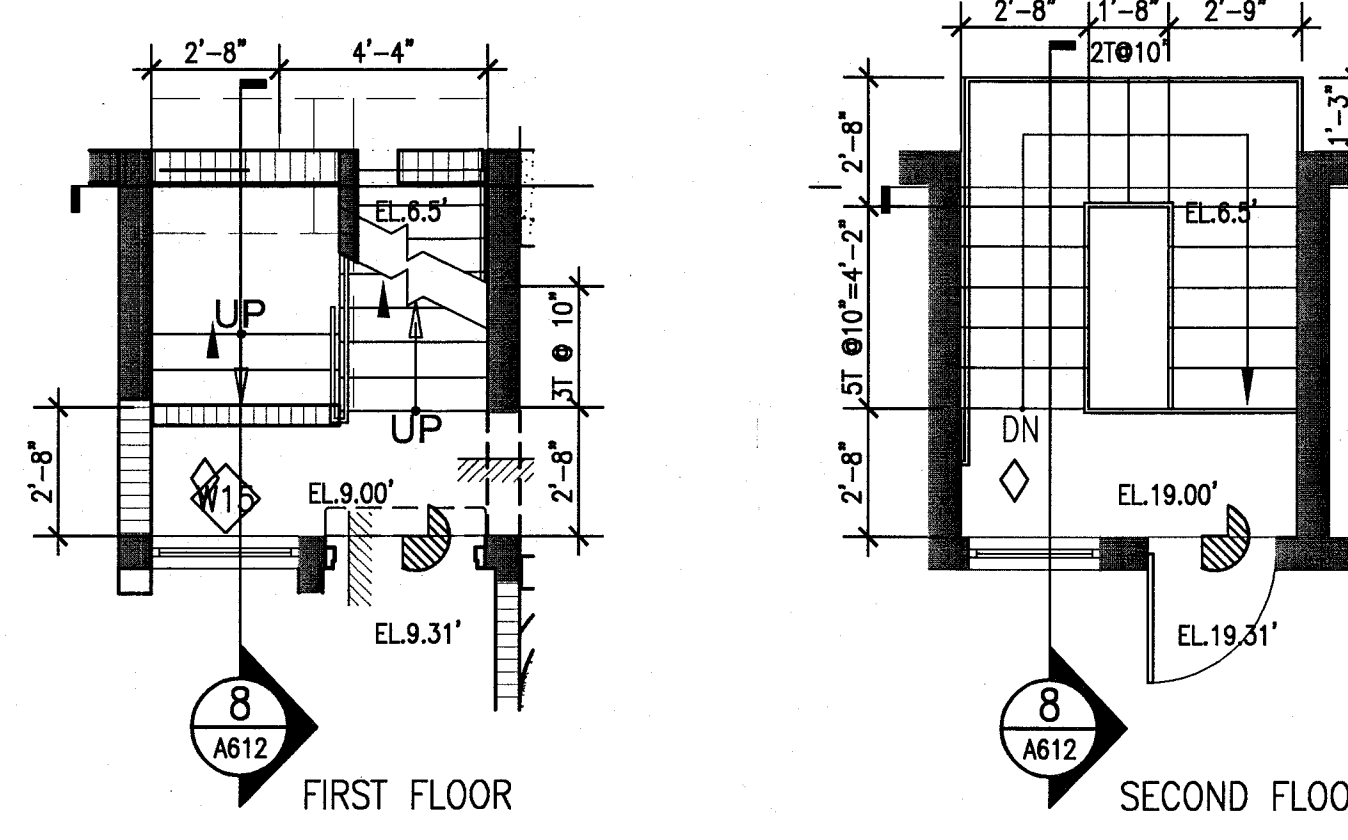


3 STAIR 1B, 3B & 9B (2B, 8B & 12B REV.SIM.)
CAMPTON/ PLANS
SCALE: 1/4" = 1'-0"

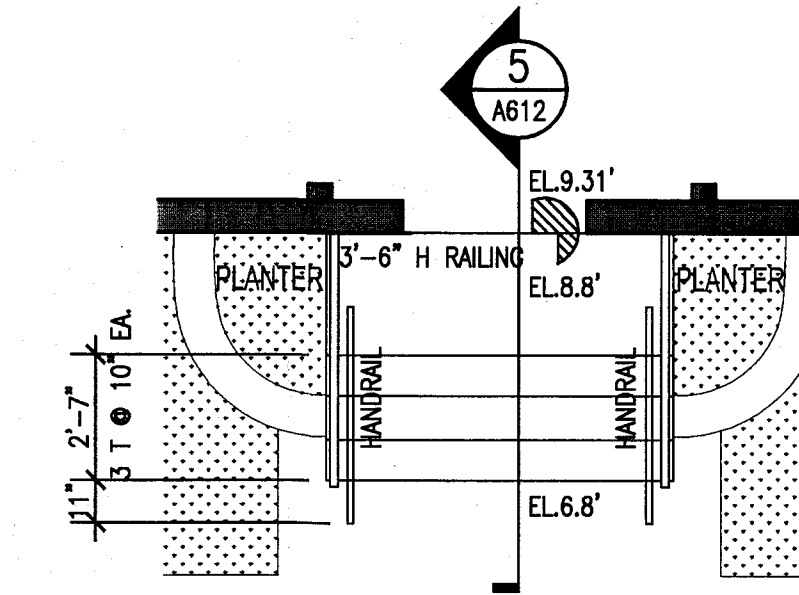


4 CAMPTON ENTRY STAIRS
PLAN
SCALE: 1/4" = 1'-0"

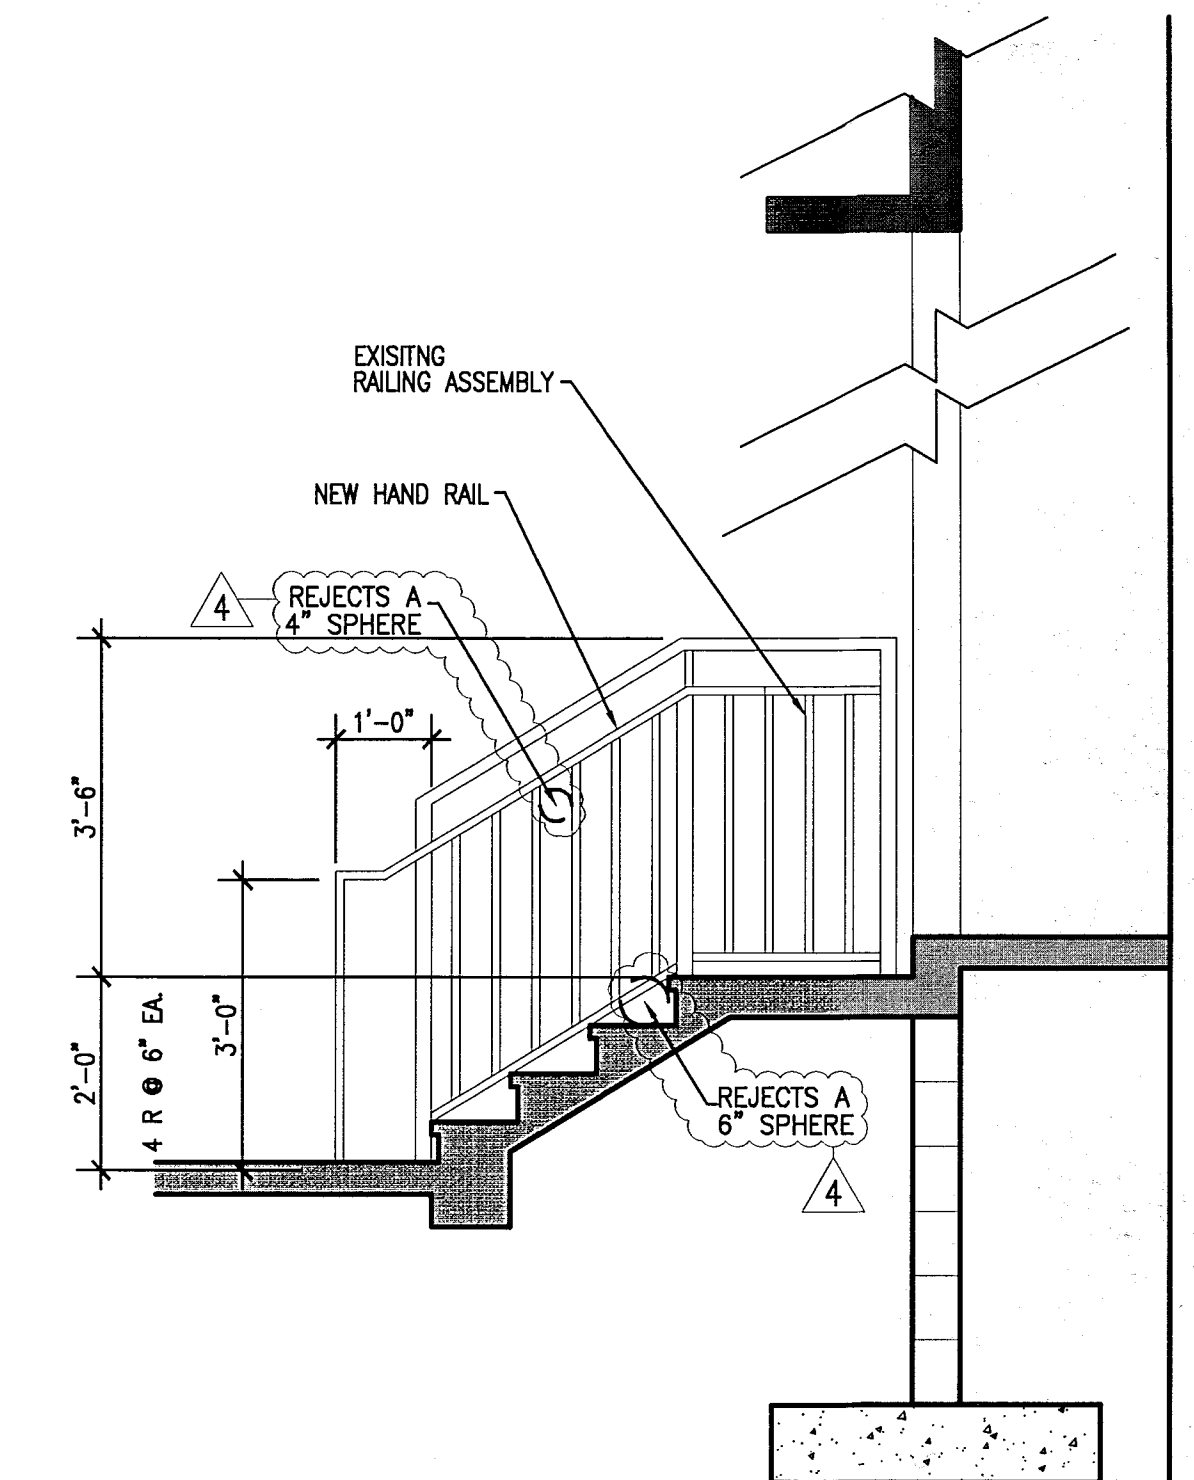


5 CAMPTON ENTRY STAIR
SECTION
SCALE: 1/2" = 1'-0"

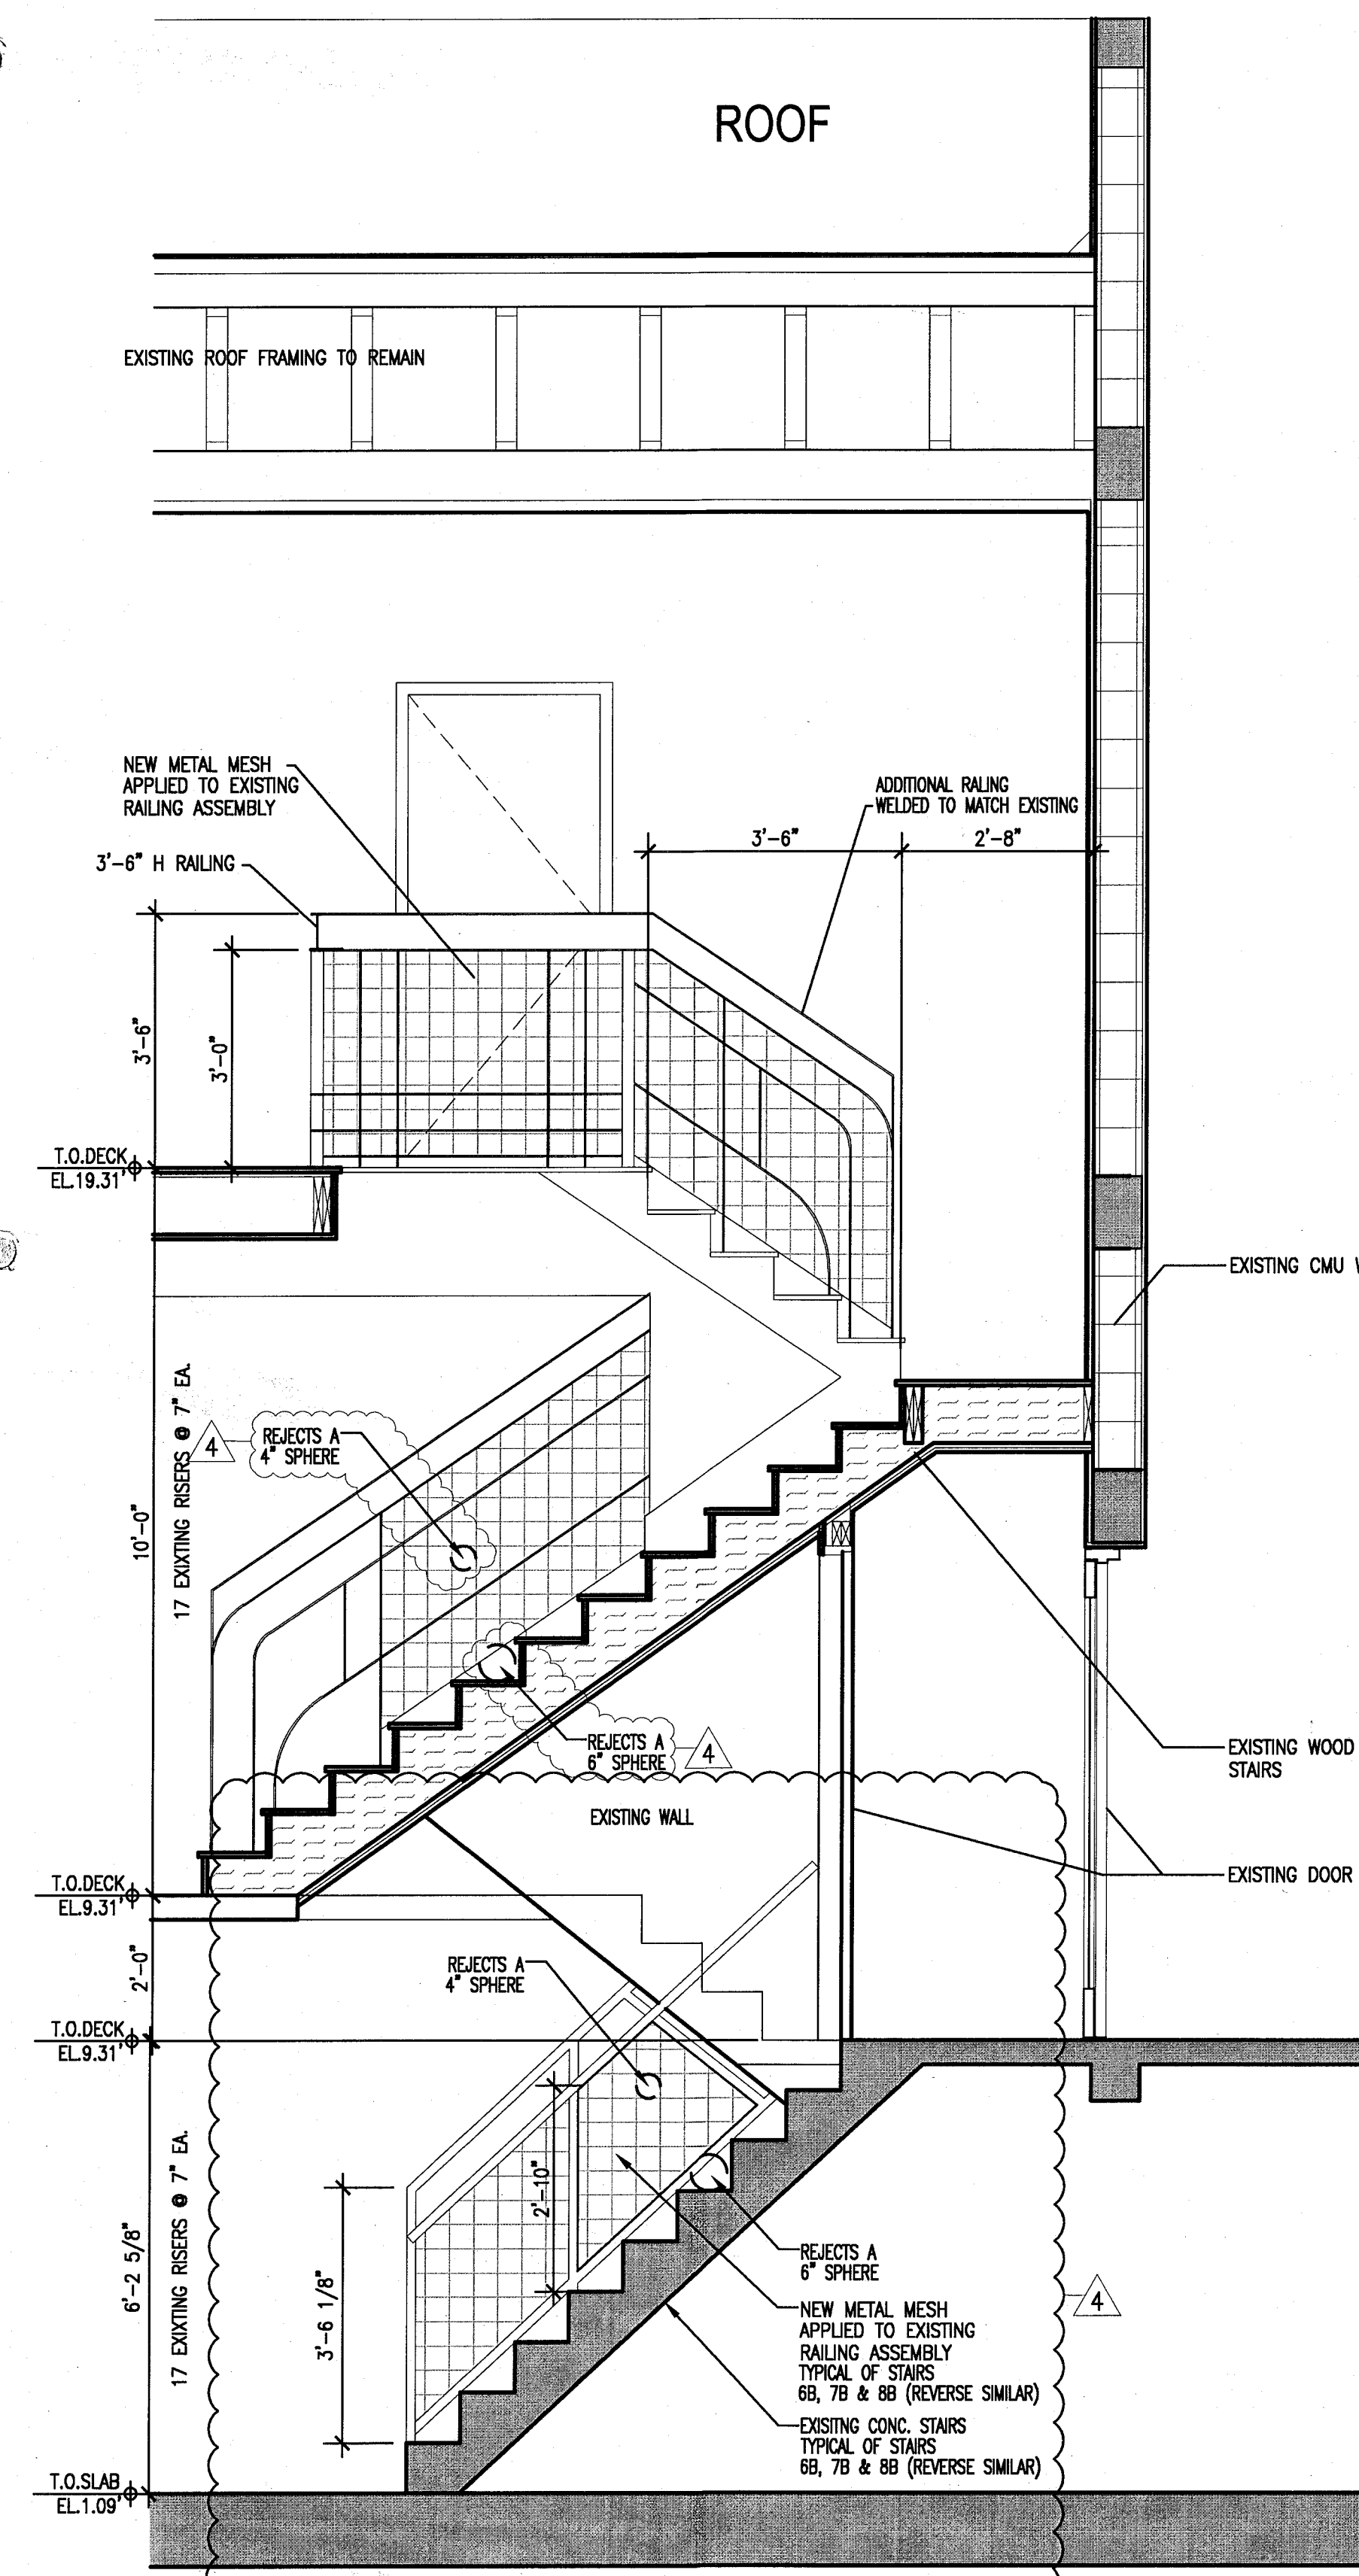


6 SECTION THRU STAIRS
6B & 11B AT CAMPTON
SCALE: 1/2" = 1'-0"

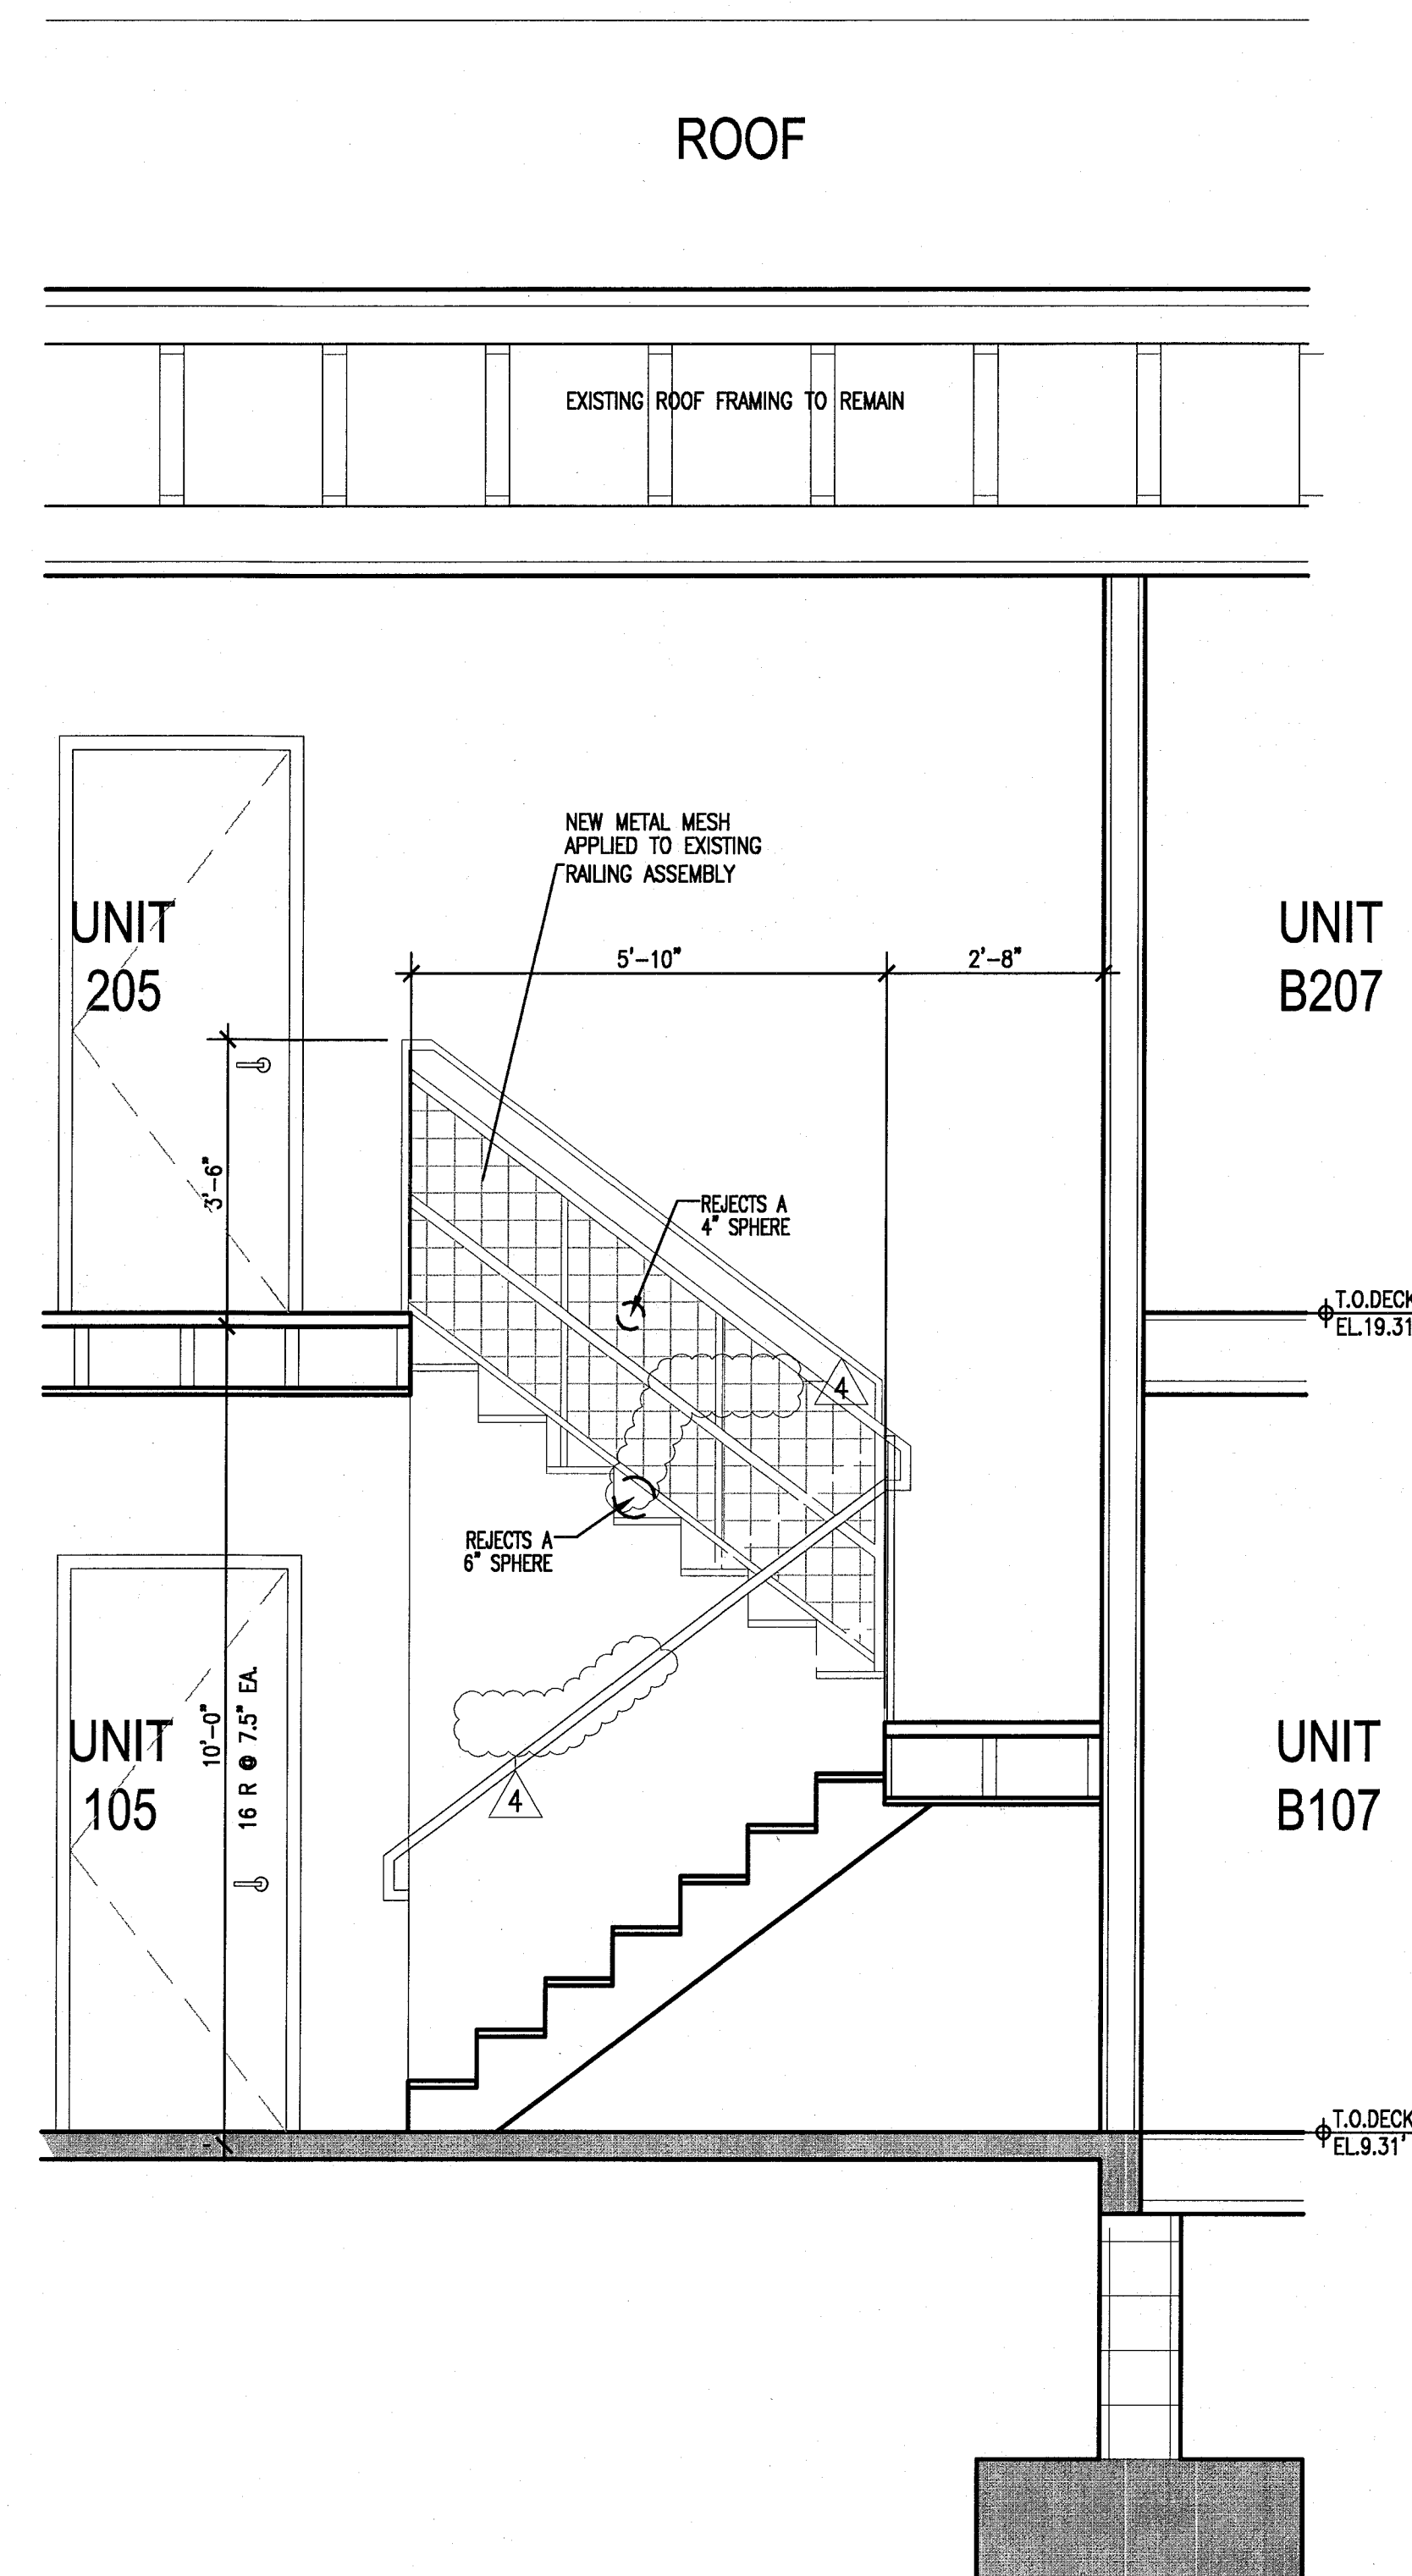

7 SECTION THRU STAIRS
5B & 10B AT CAMPTON
SCALE: 1/2" = 1'-0"

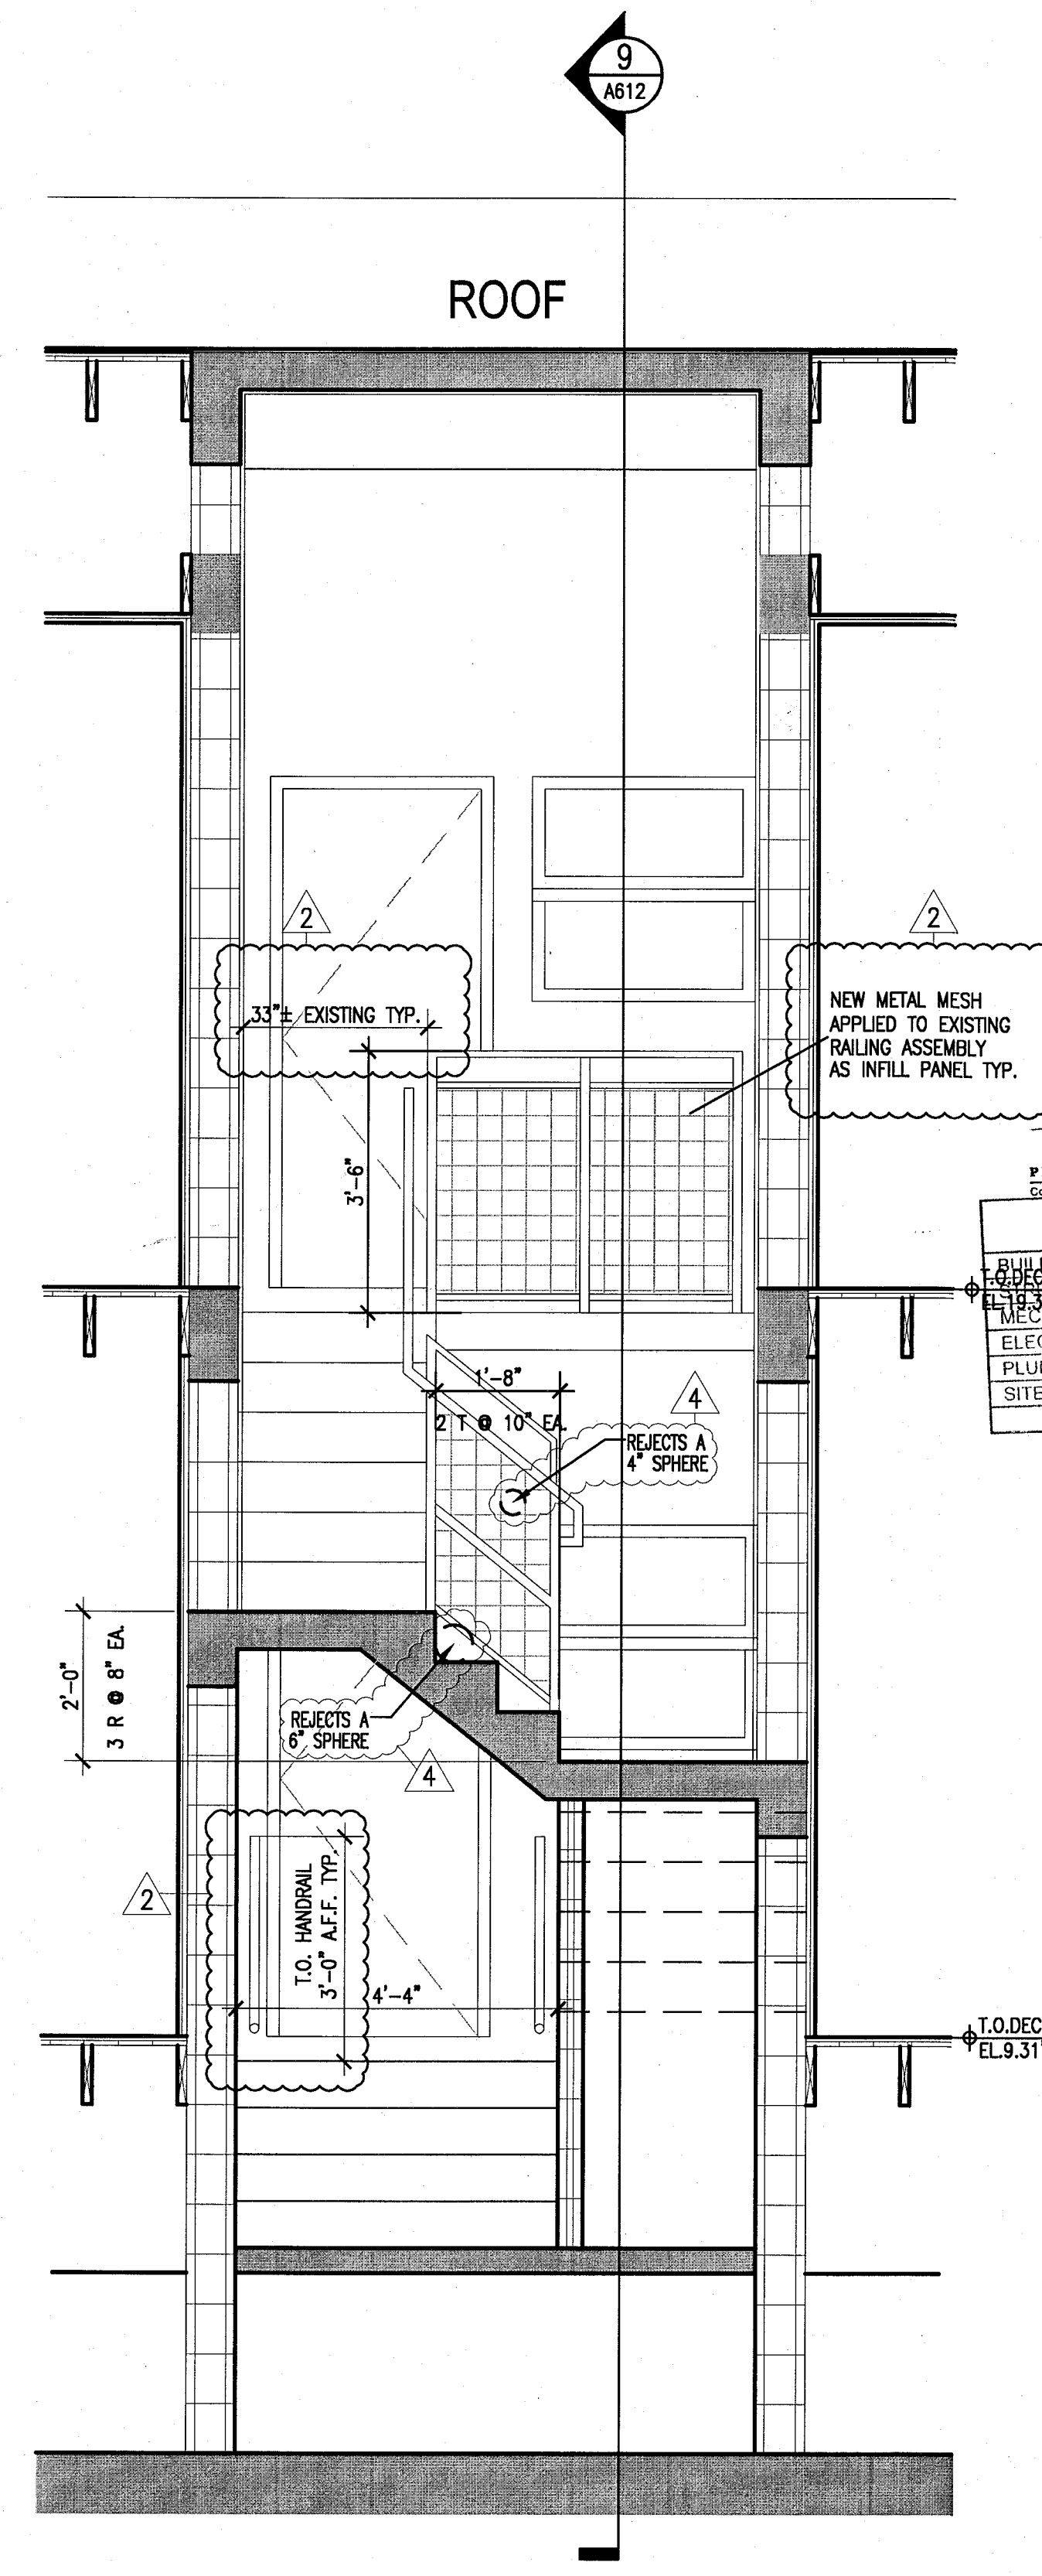

8 THRU STAIRS 1B, 3B & 9B
SECTION
SCALE: 1/2" = 1'-0"

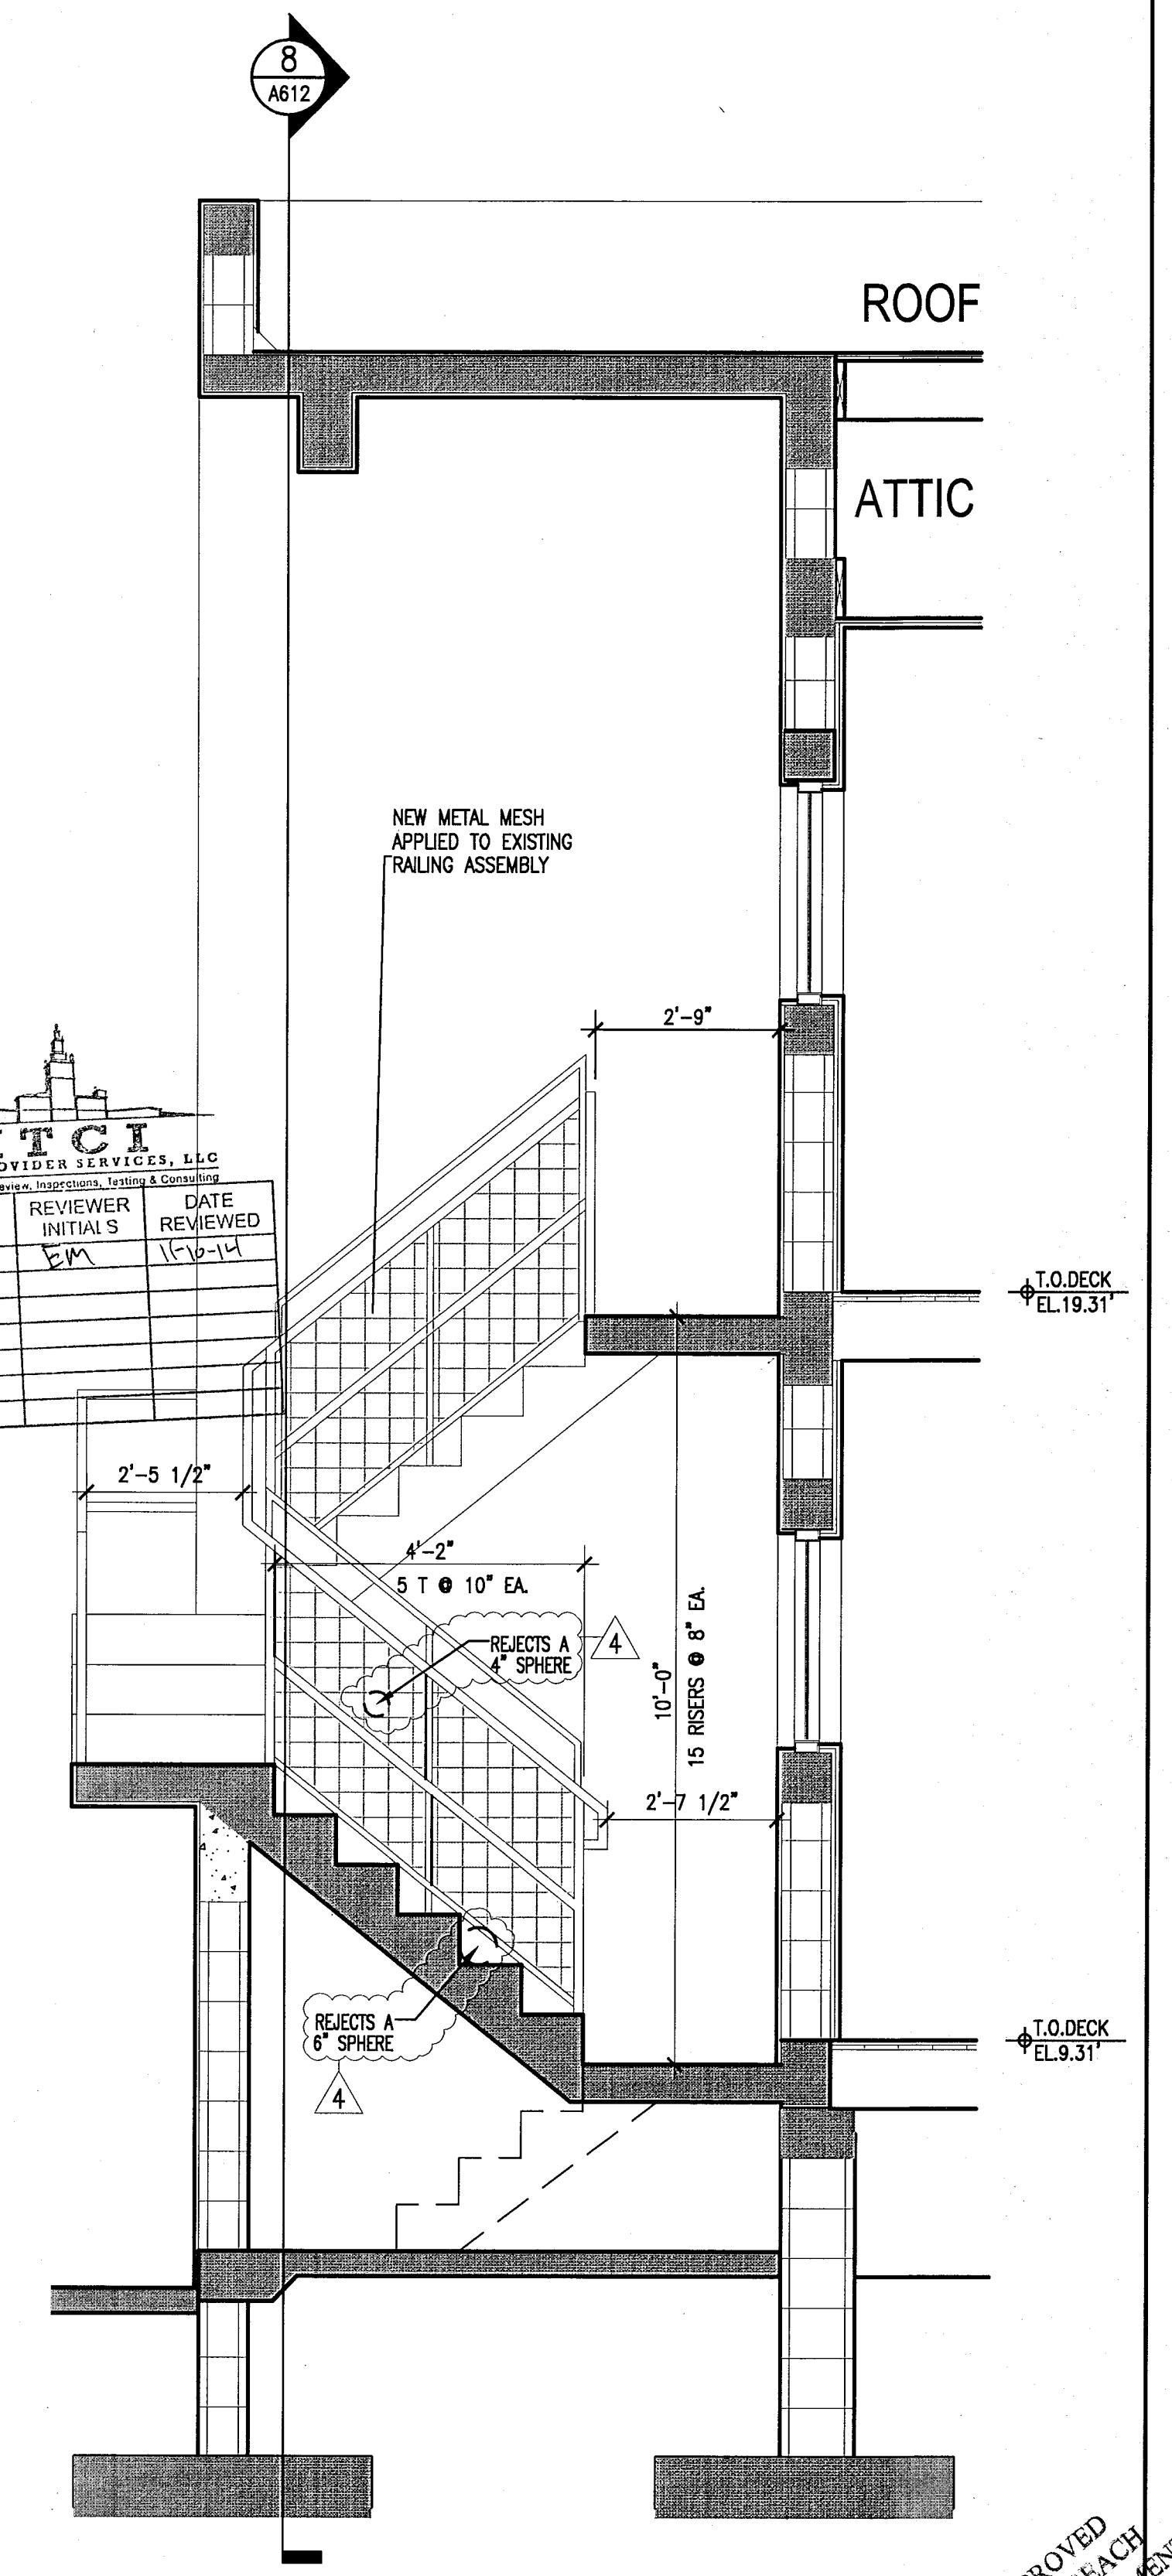

9 THRU STAIRS 1B, 3B & 9B
SECTION
SCALE: 1/2" = 1'-0"

APPROVED
MIAMI BEACH
FIRE DEPARTMENT

HADDON HALL 1500 COLLINS AVE MIAMI BEACH, FL

KEYPLAN N.T.S.

REVISIONS		
NO.	DESCRIPTION	ISSUE DATE
1	POOL SUITES WALLS	04-09-2014

100% CONSTRUCTION DOCUMENT SET

ADD Inc

Architecture Interiors Planning
One Biscayne Tower
Suite 1670
Two South
Biscayne Boulevard
Miami, FL 33131
T. 305.482.8700
F. 305.482.8770
www.addinc.com
Lic. # AA26001507

JOB NUMBER: 13036.00
CHECKED BY:
ISSUE DATE: FEBRUARY 18, 2014
SCALE: 1/2" = 1'-0"



SHEET TITLE

SECTIONS THRU STAIRS #1 & #2 POOL SUITES (C)


SHEET NUMBER

A613

COPYRIGHT ADD INC 2011

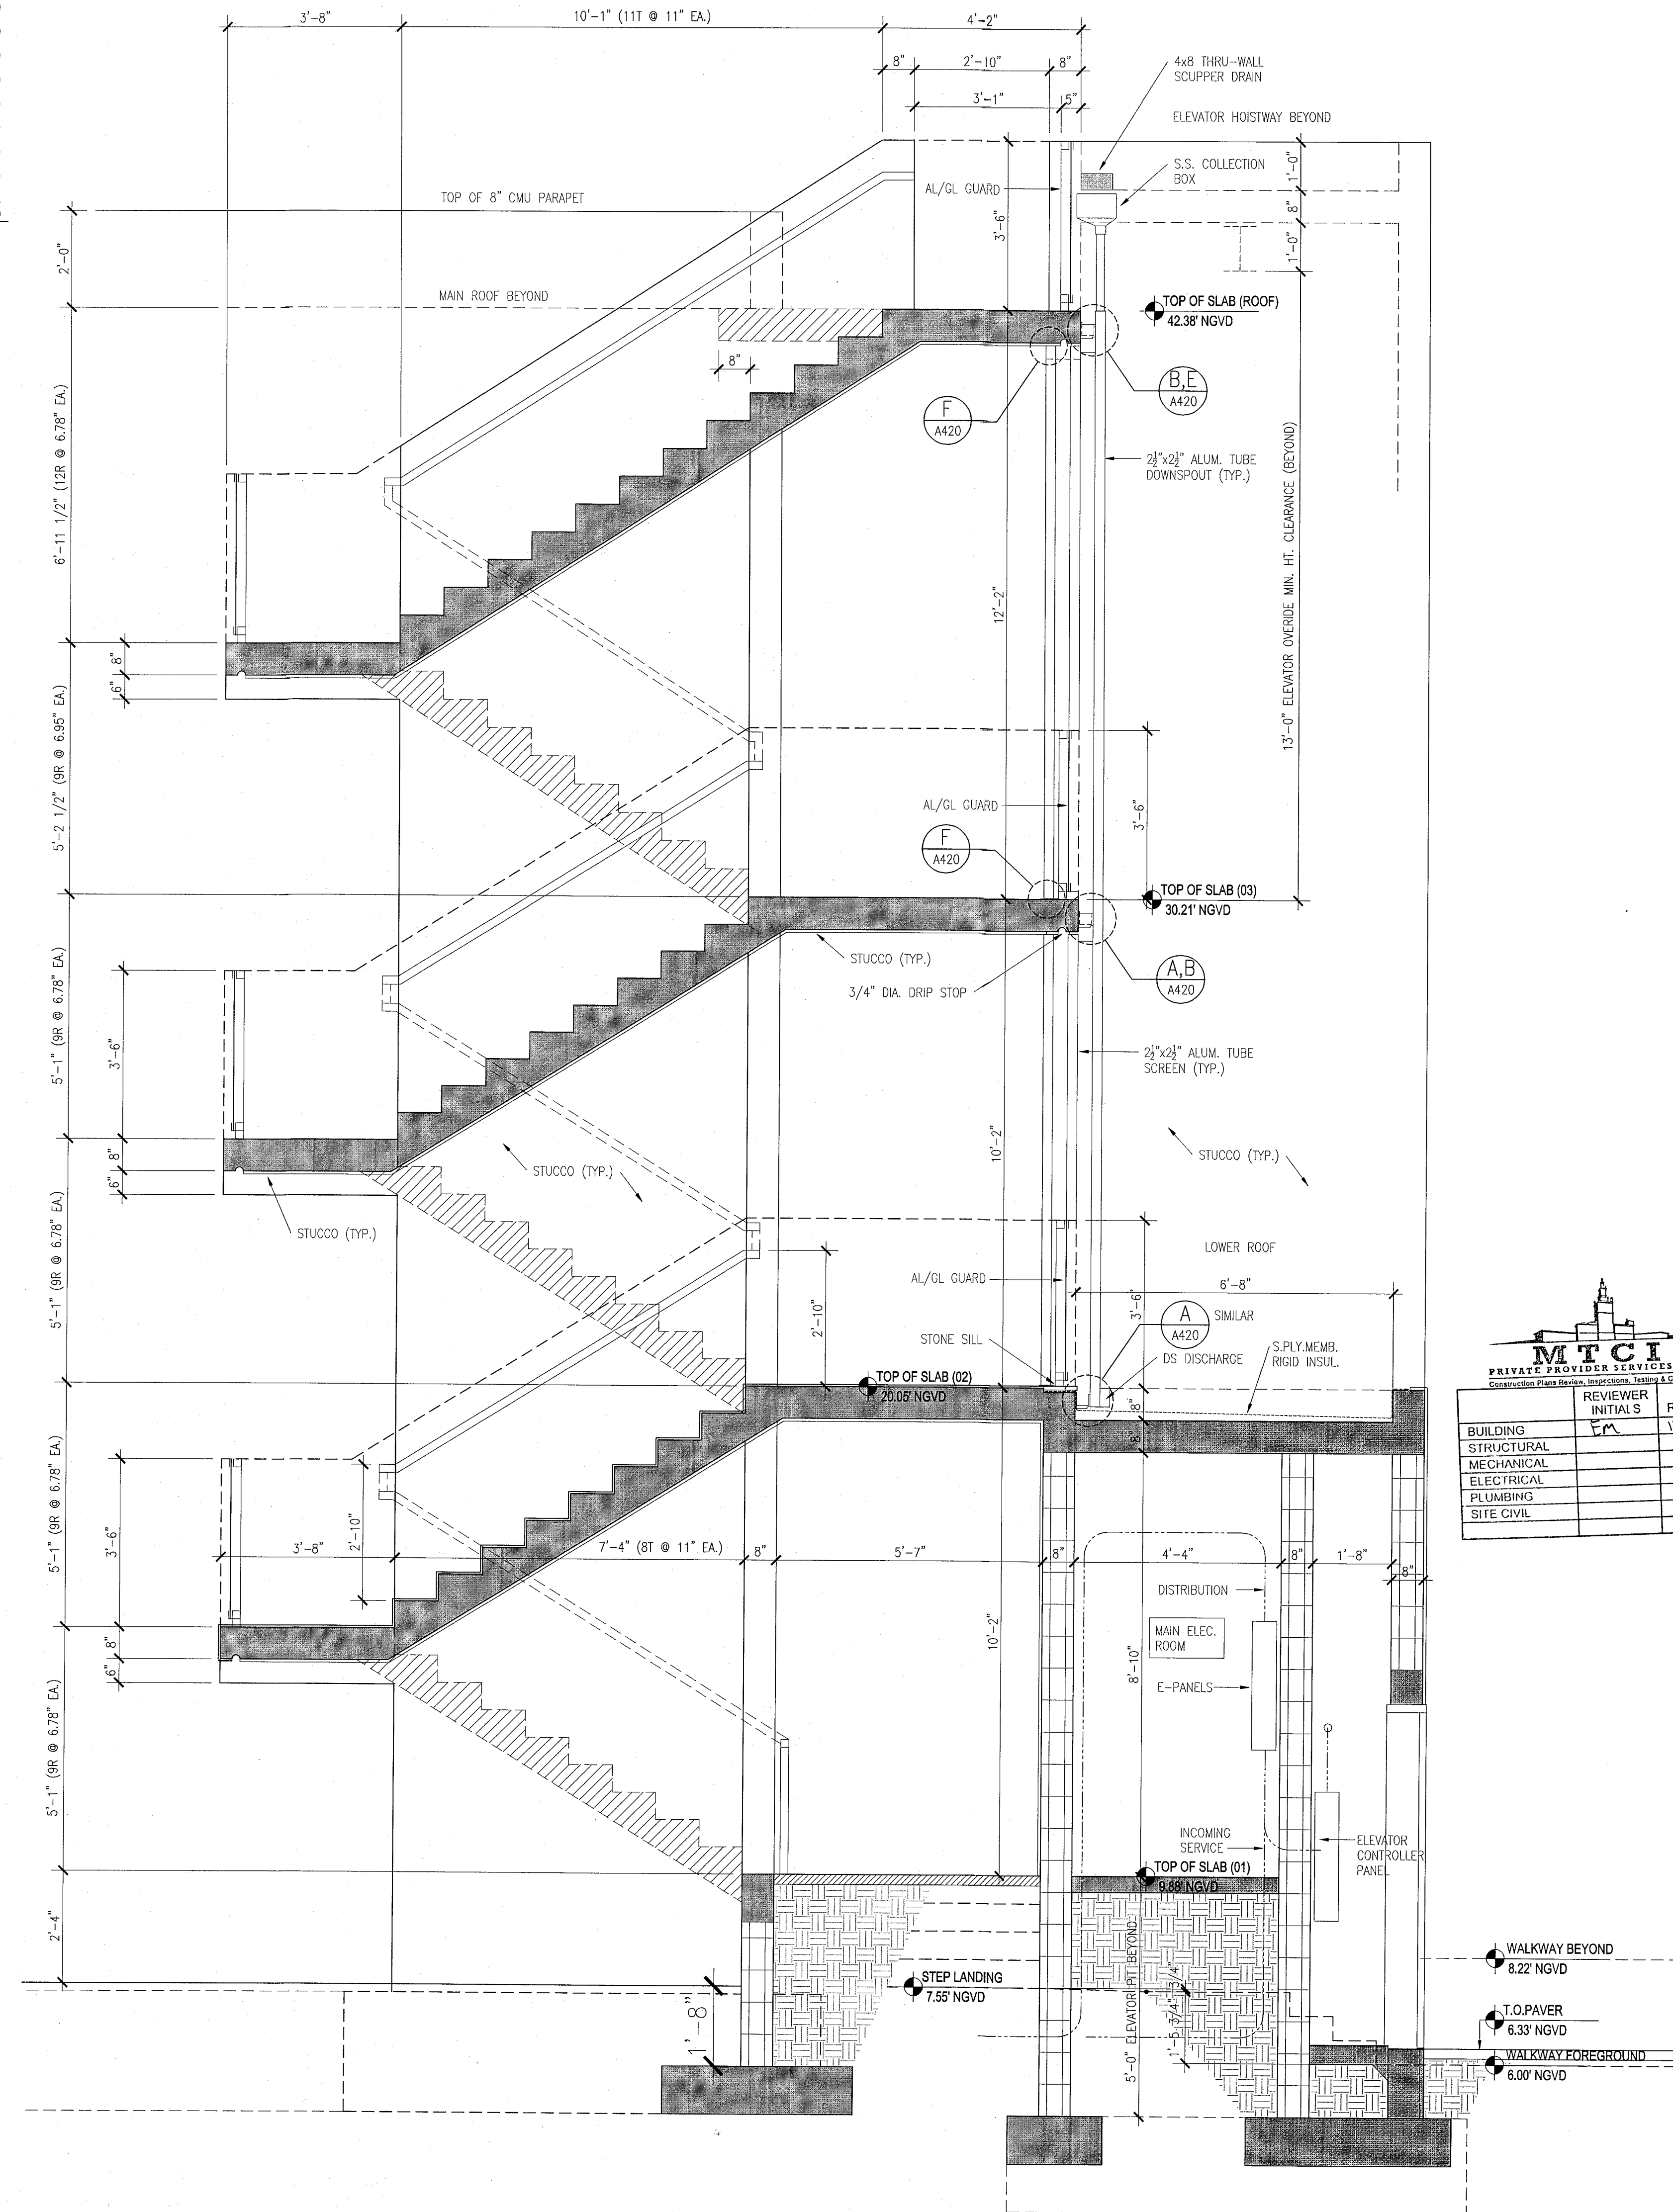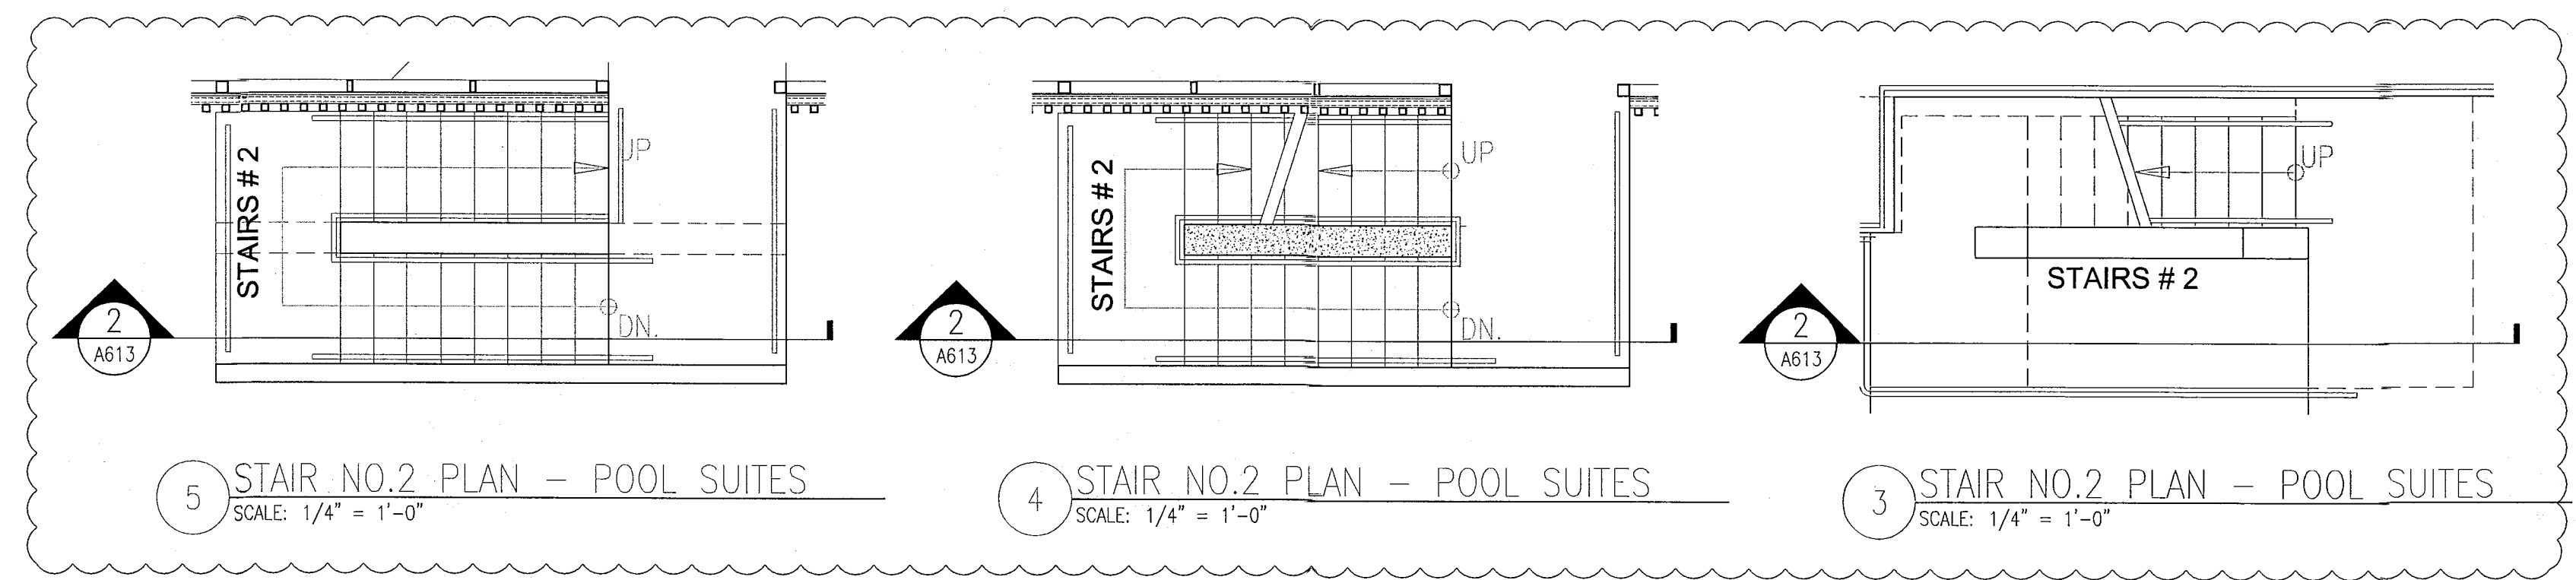

REVIEWER		
BUILDING	REVIEWER INITIALS	DATE
STRUCTURAL	EA	11/10/14
MECHANICAL		
ELECTRICAL		
PLUMBING		
SITE CIVIL		

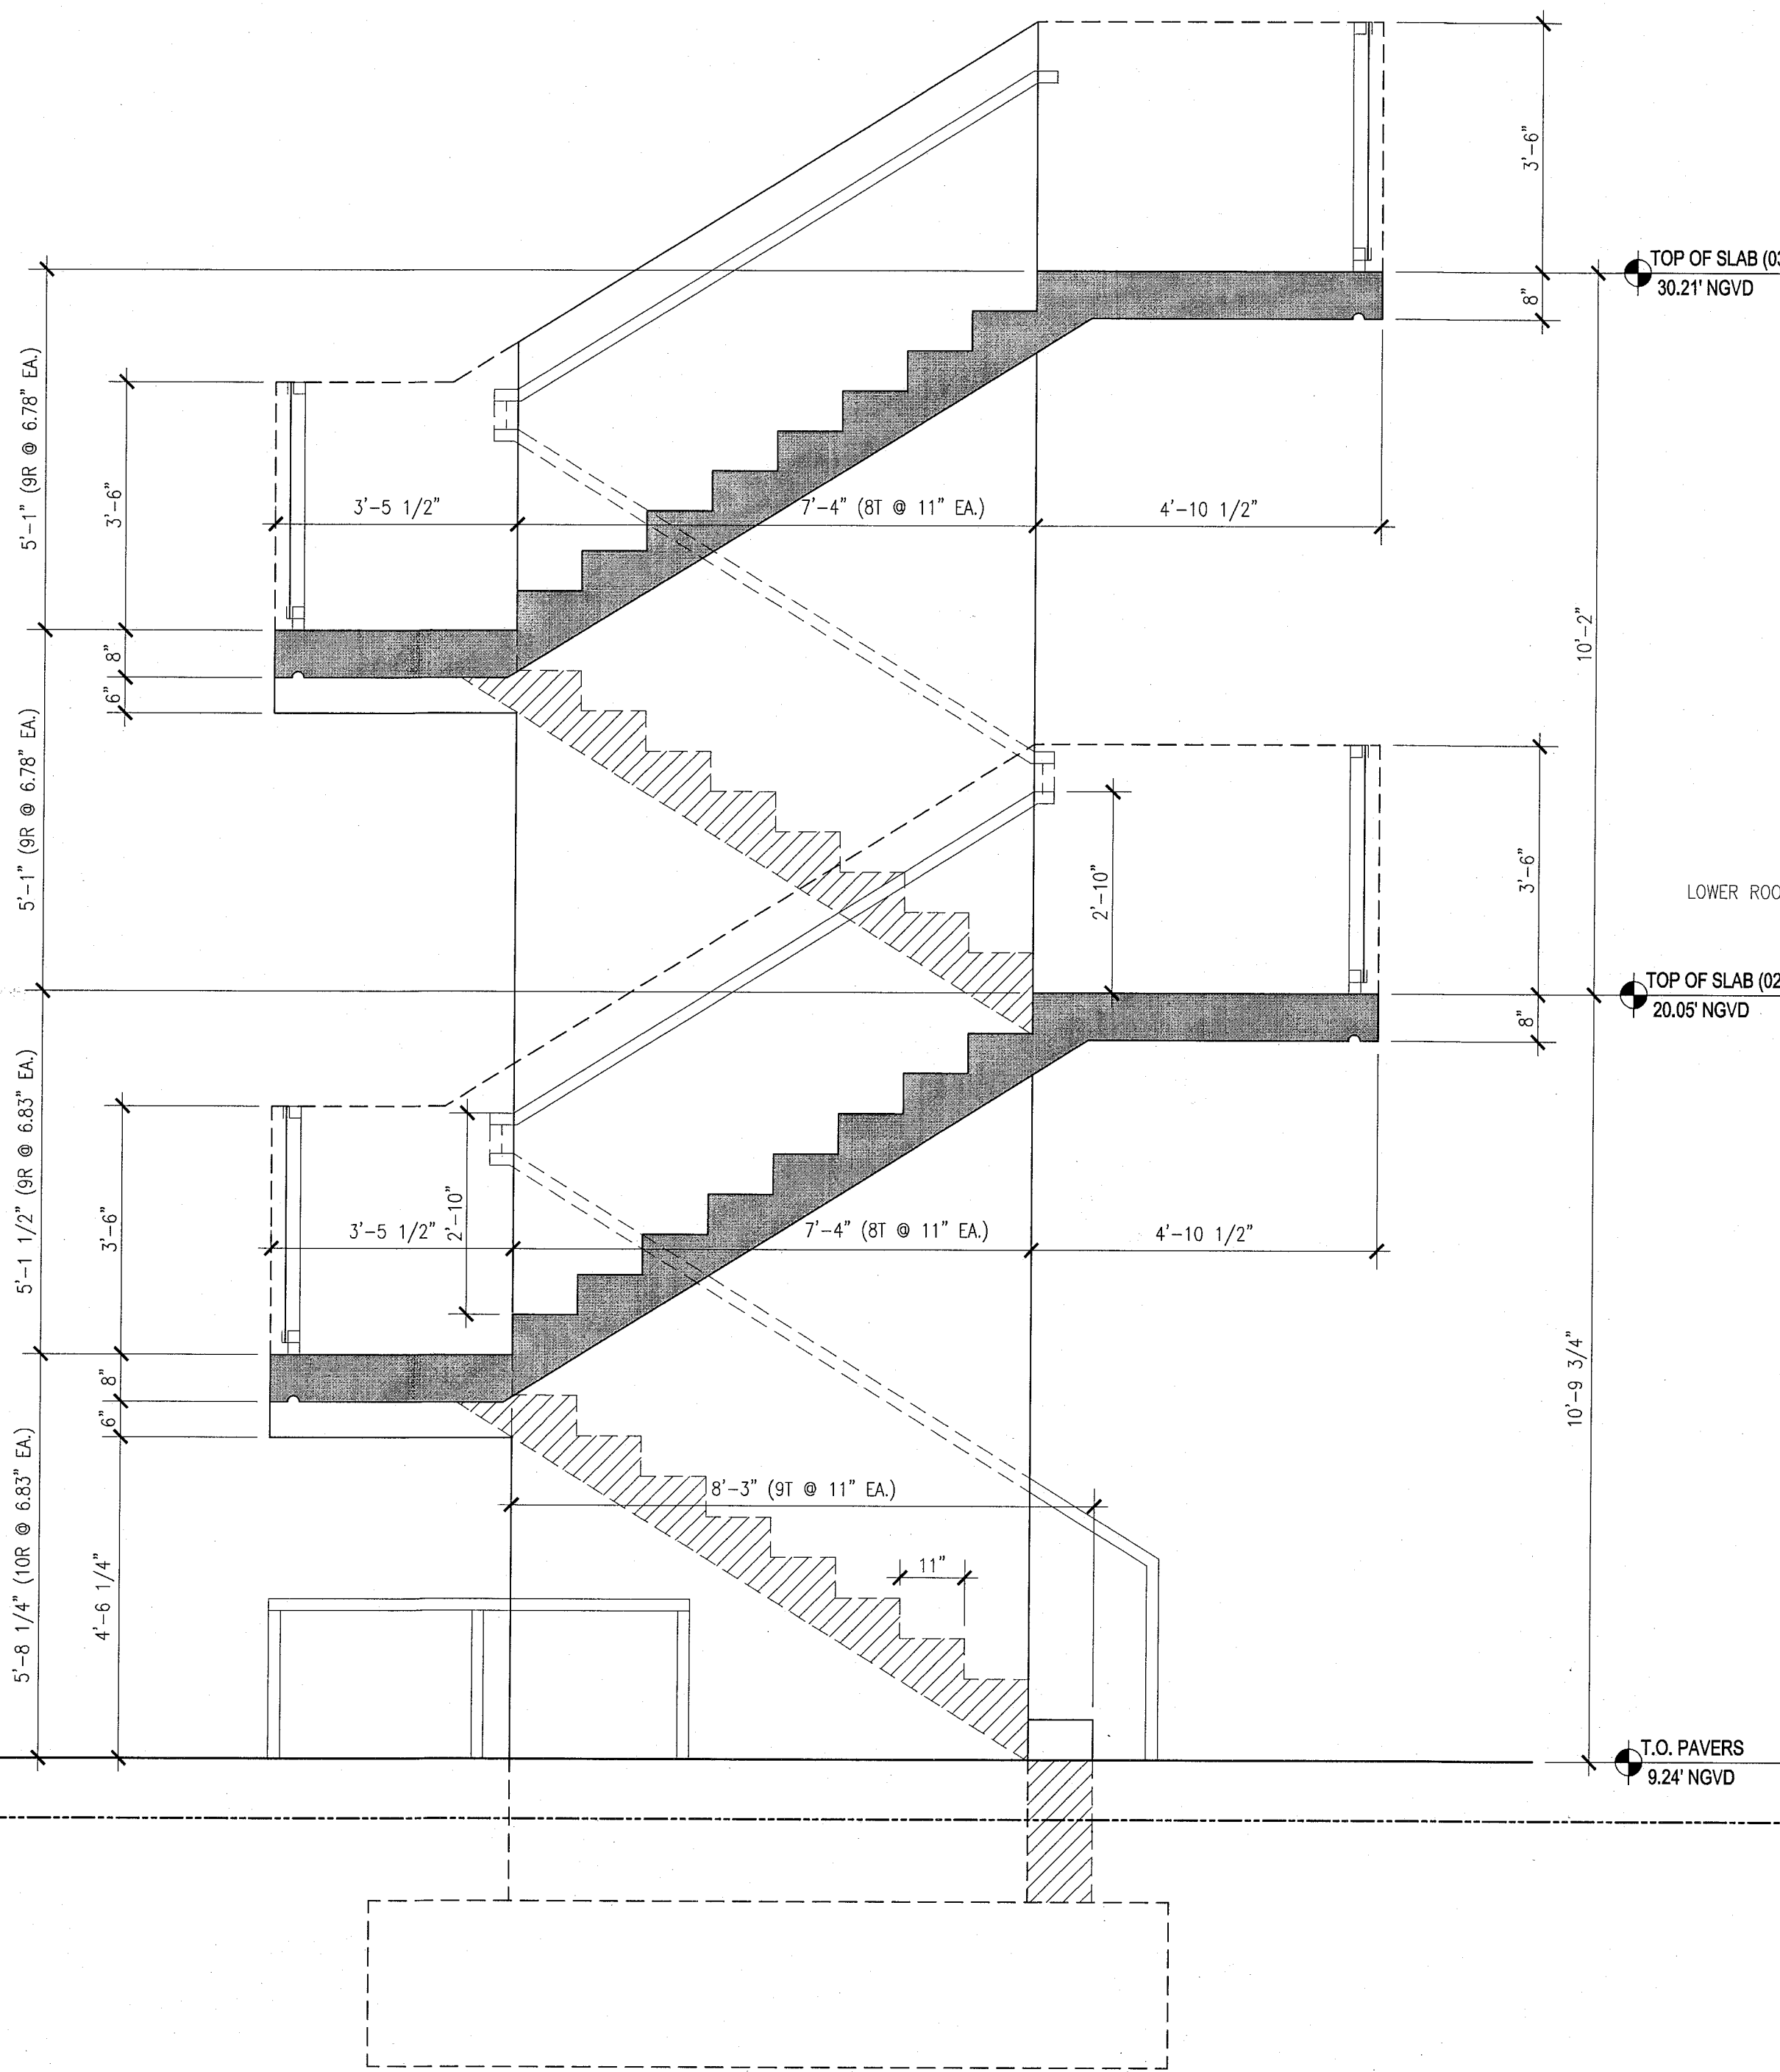

2 STAIR NO.2 SECTION - POOL SUITES
SCALE: 1/2" = 1'-0"

1 STAIR NO.1 SECTION - POOL SUITES
SCALE: 1/2" = 1'-0"

MIAMI BEACH, FL

T.S.[illegible]

Construction Plans Review - 11/10/2019, 14:51:19, 5-10-2019		
	REVIEWER INITIALS	DATE REVIEWED
BUILDING	EM	11-10-19
STRUCTURAL		
MECHANICAL		
ELECTRICAL		
PLUMBING		
SITE/CIVIL		

Architecture Interiors Planning

One Biscayne Tower
Suite 1670
Two South
Biscayne Boulevard
Miami, FL 33131
T. 305.482.8700
F. 305.482.8770
www.addinc.com
Lic. # AA26001507

Boston Miami

JOB NUMBER:	13036.00
CHECKED BY:	
ISSUE DATE:	FEBRUARY 18, 2014
SCALE:	AS NOTED


SHEET TITLE _____

STAIR TYP. DETAILS


SHEET NUMBER

A617


COPYRIGHT ADD INC 2011

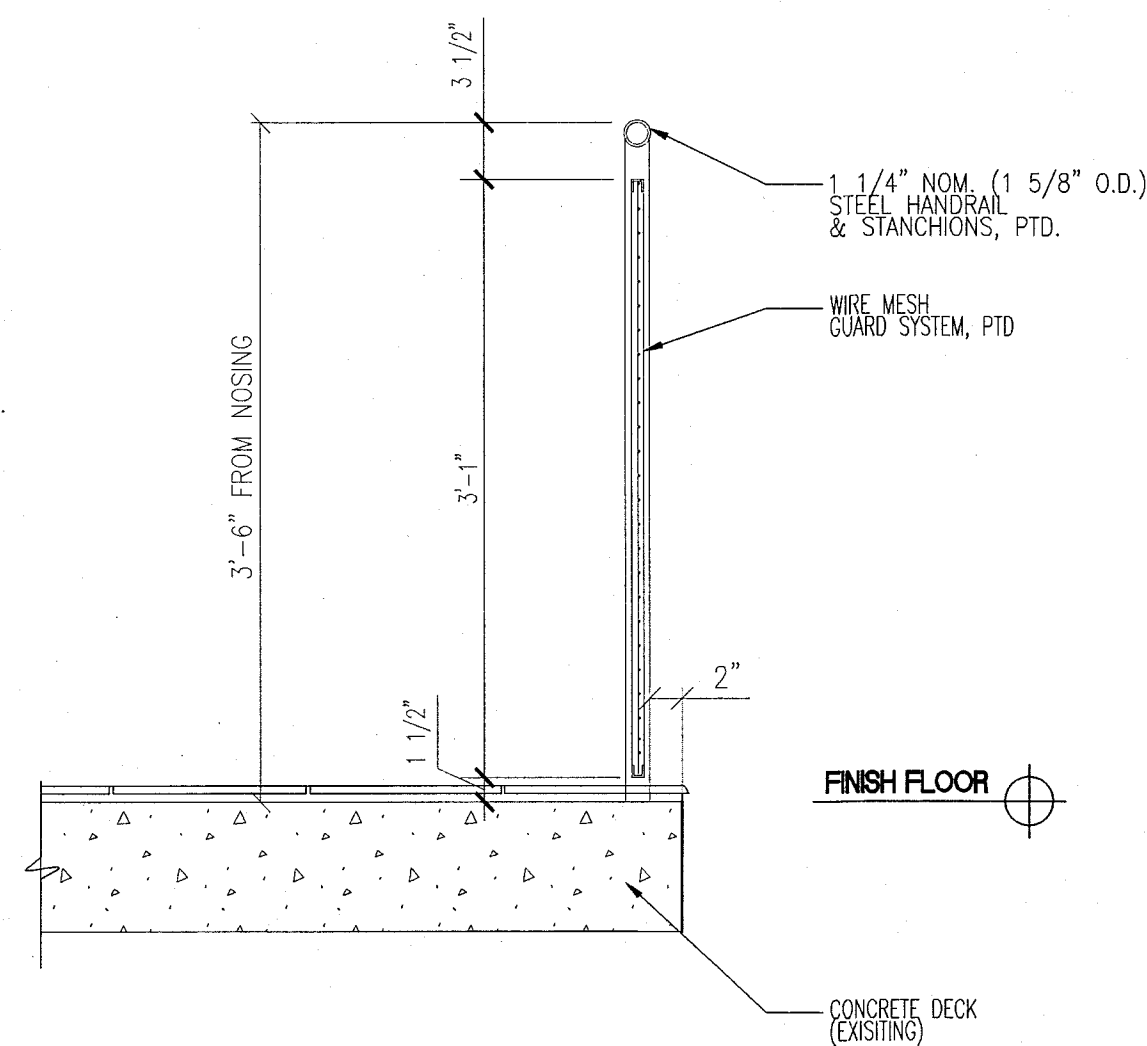


11 SECTION AT TOP BALCONY
SCALE: 1" = 1'-0"

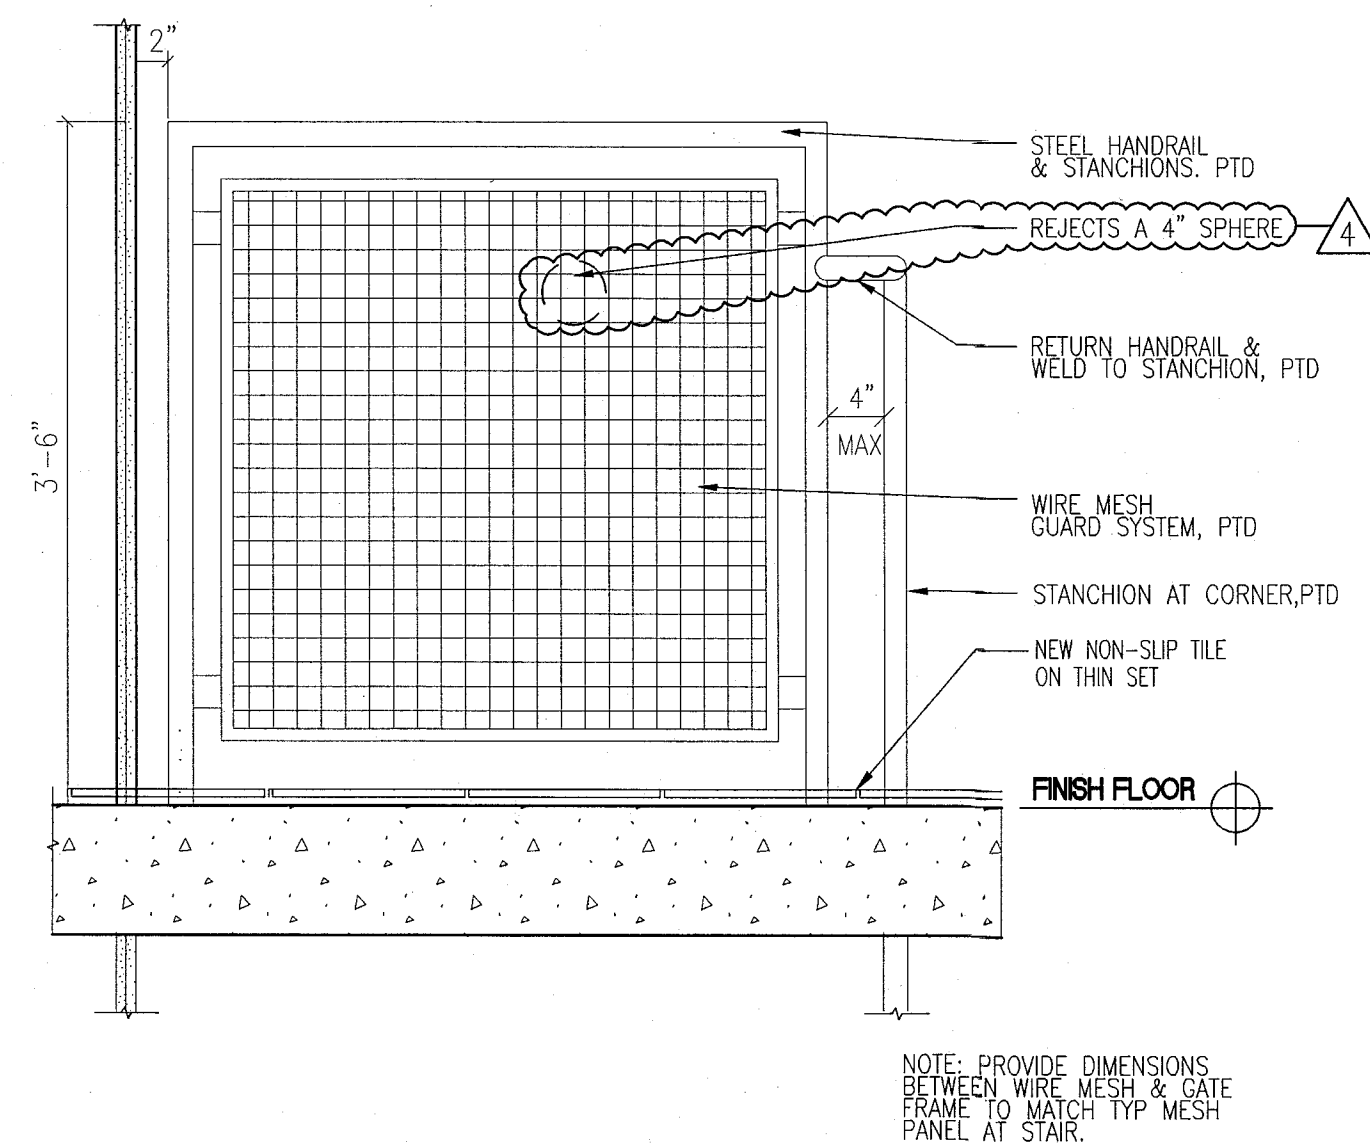


6 GUARDRAIL AT TOP LANDING
SCALE: 1" = 1'-0"

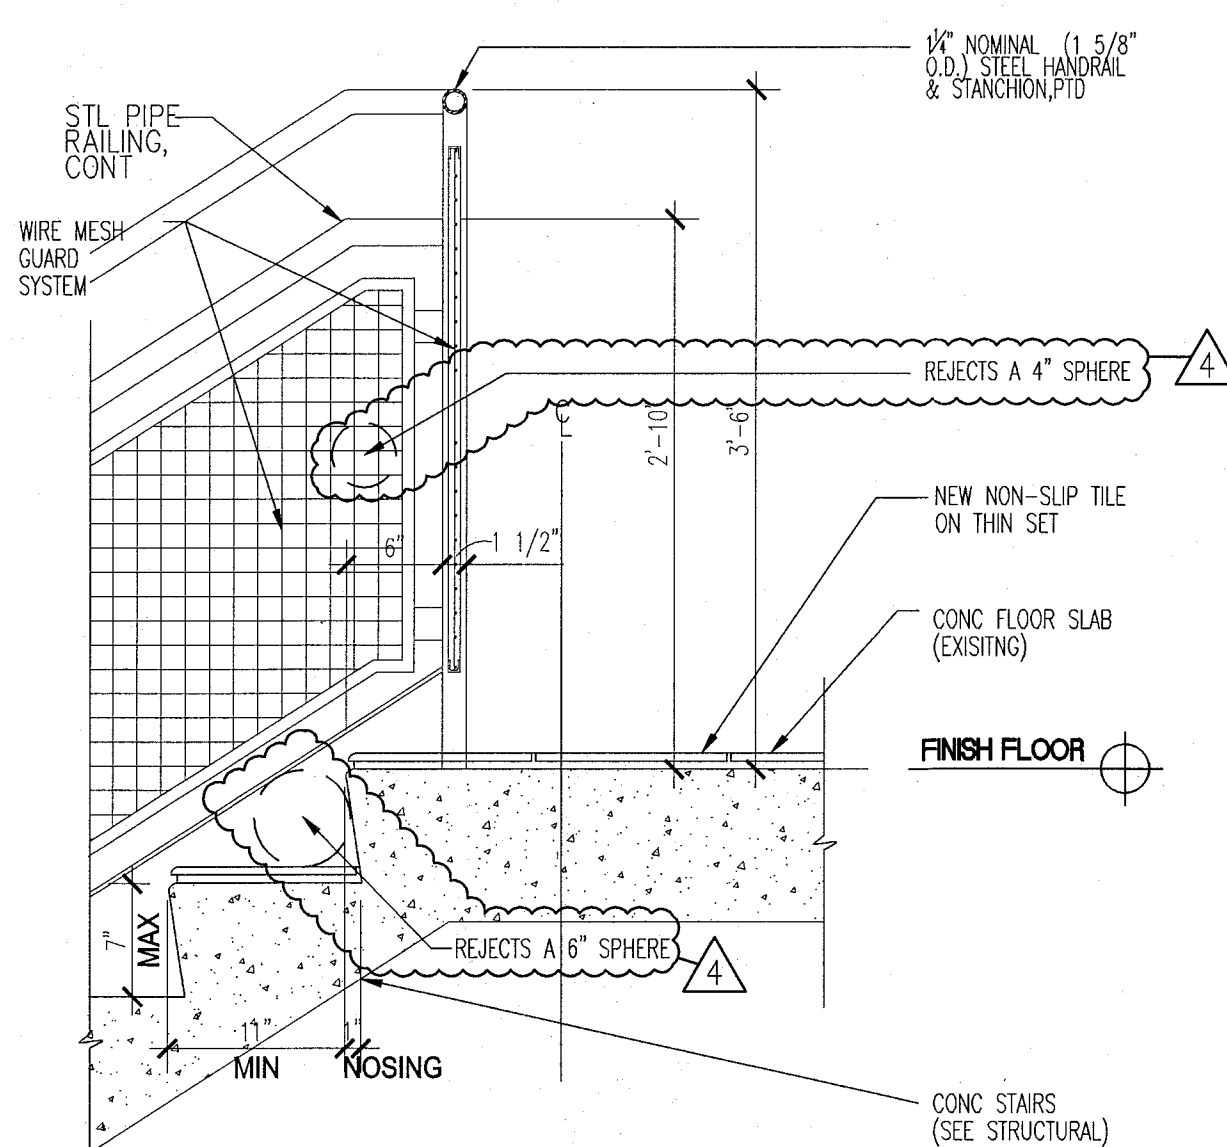


9 DETAIL AT TOP LANDING BALCONY
SCALE: 1" = 1'-0"

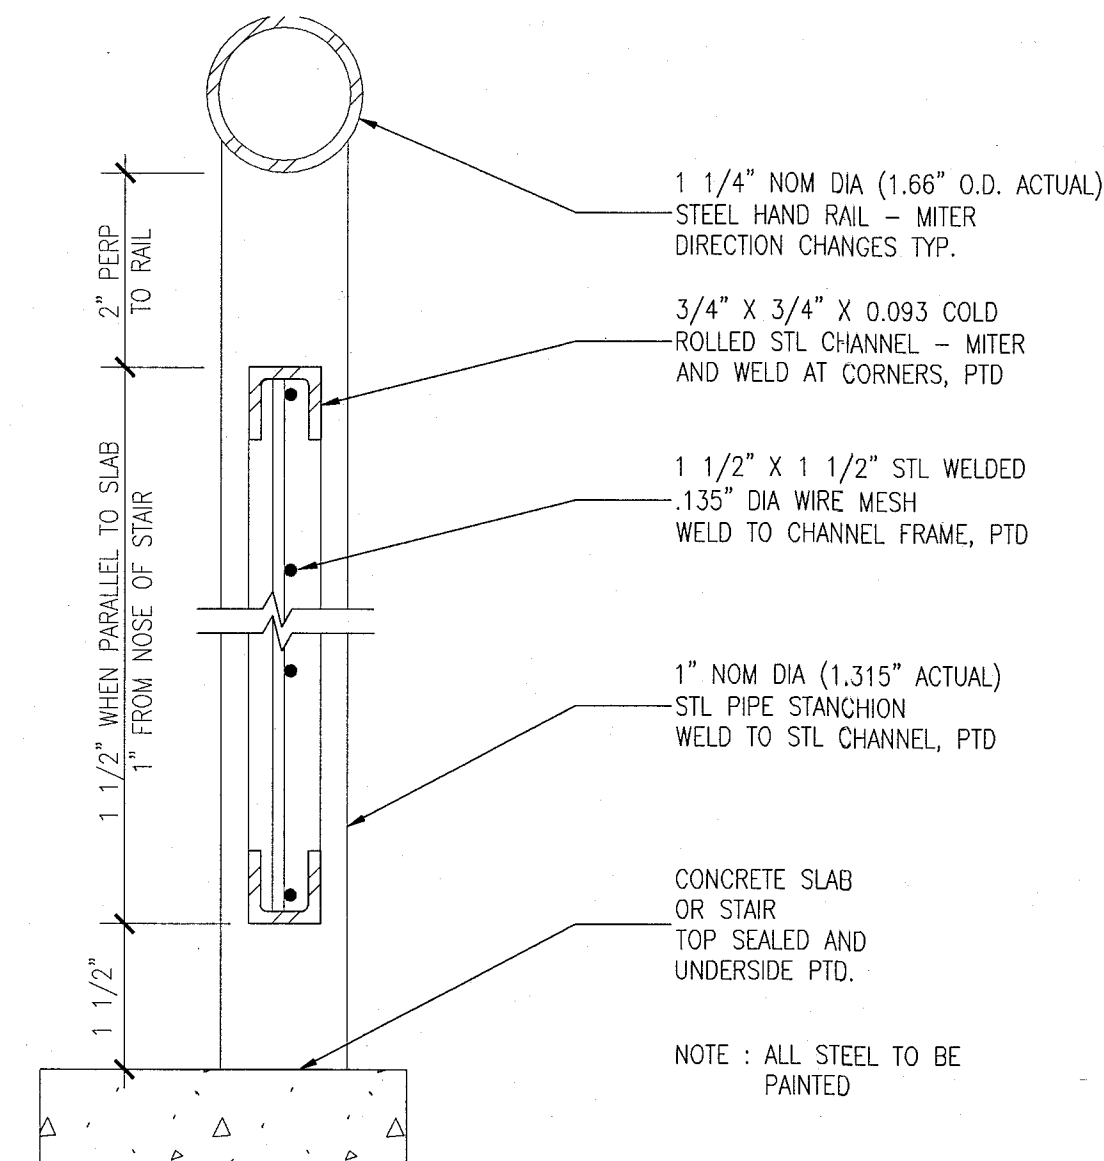


5 DETAIL AT RAILING - WIRE MESH GUARD SYSTEM
SCALE: 6" = 1'-0"

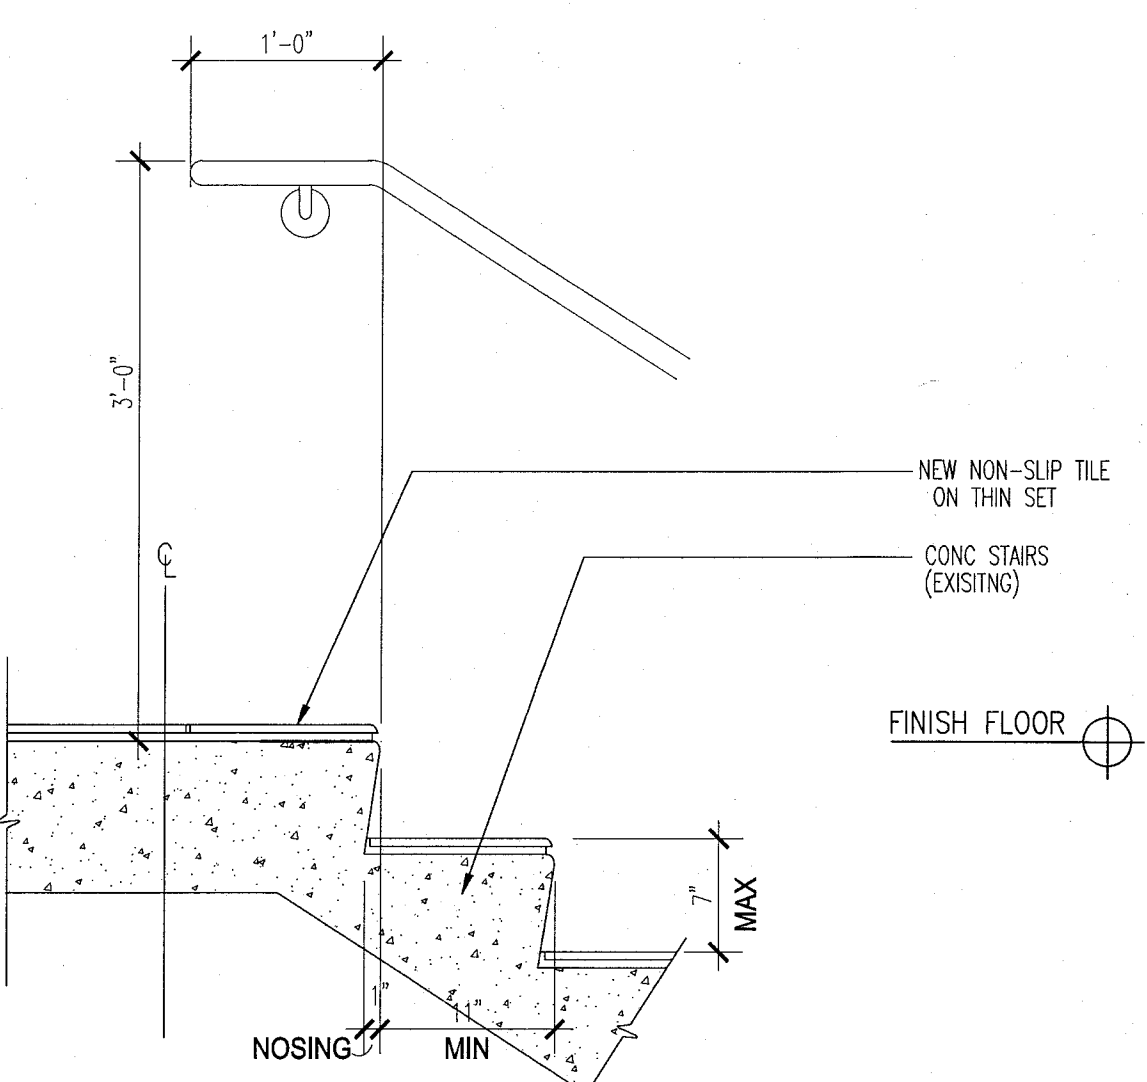


8 DETAIL AT TOP LANDING AT STAIR
SCALE: 1" = 1'-0"

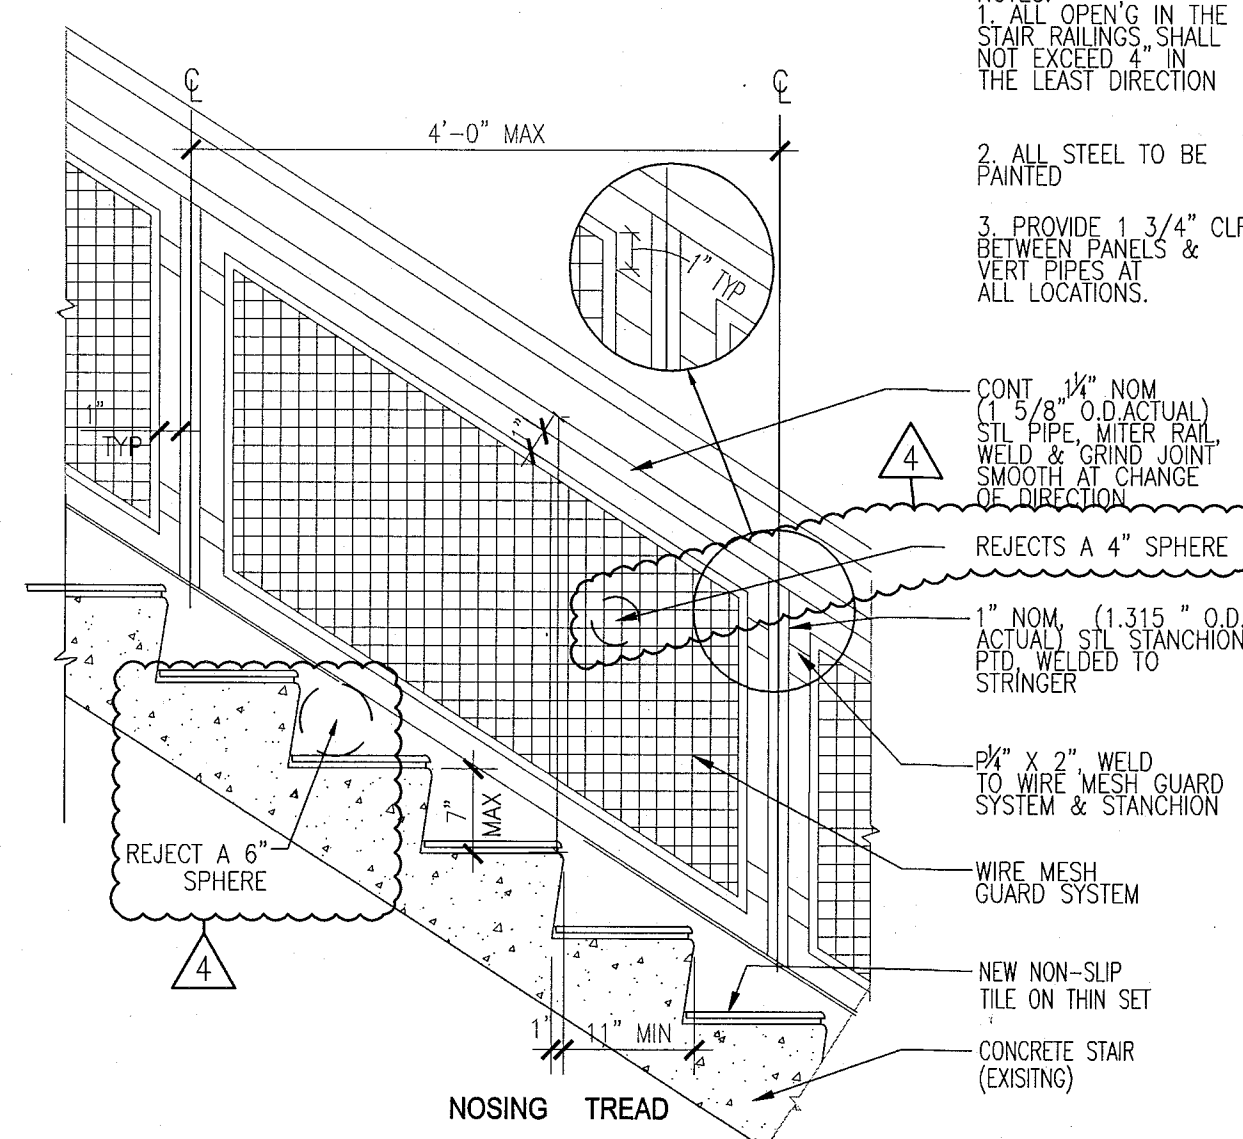


4 TYPICAL WIRE MESH GUARD SYSTEM & STAIR
SCALE: 3/4" = 1'-0"

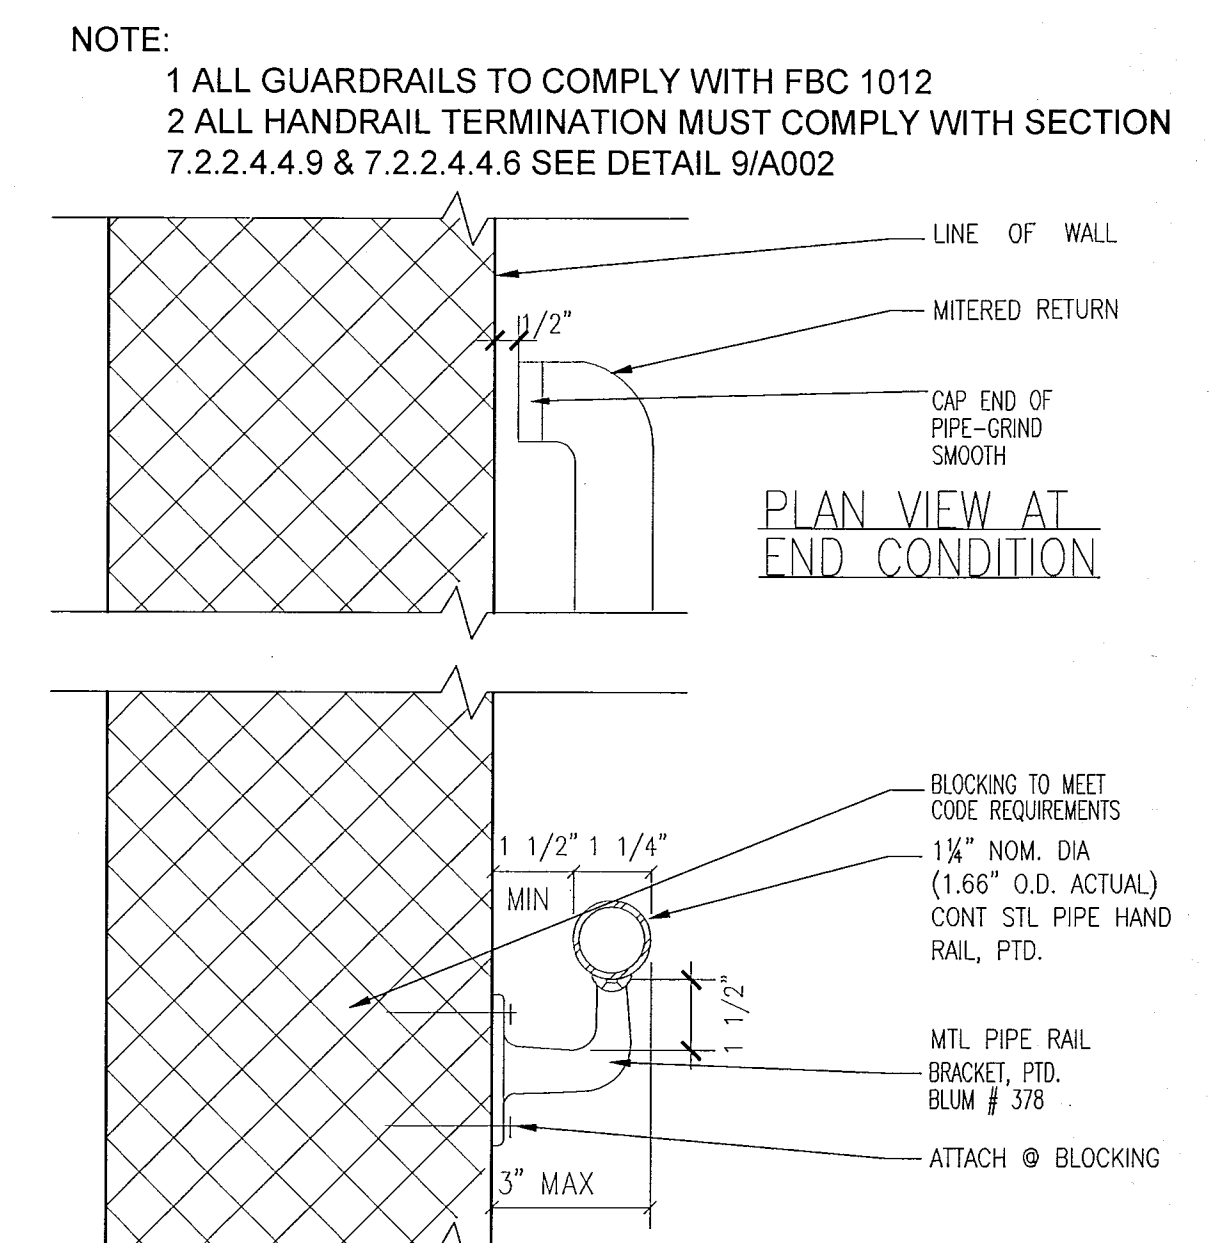


2 TYPICAL WALL MOUNTED HANDRAIL
SCALE: 1" = 1'-0"

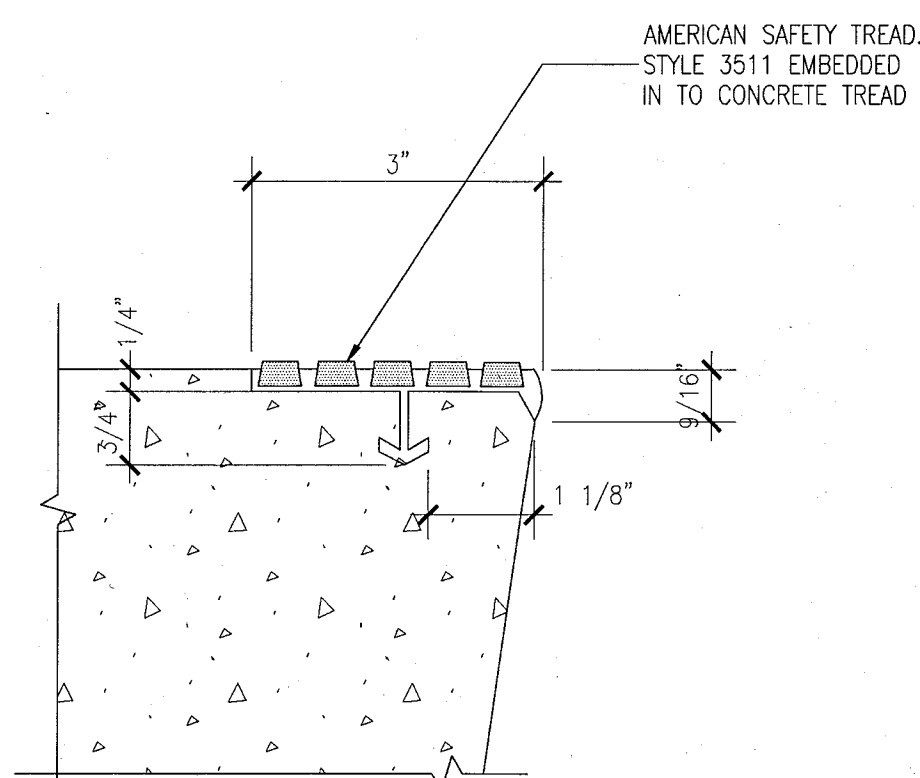


10 TREAD NOSING DETAIL
SCALE: 6" = 1'-0"

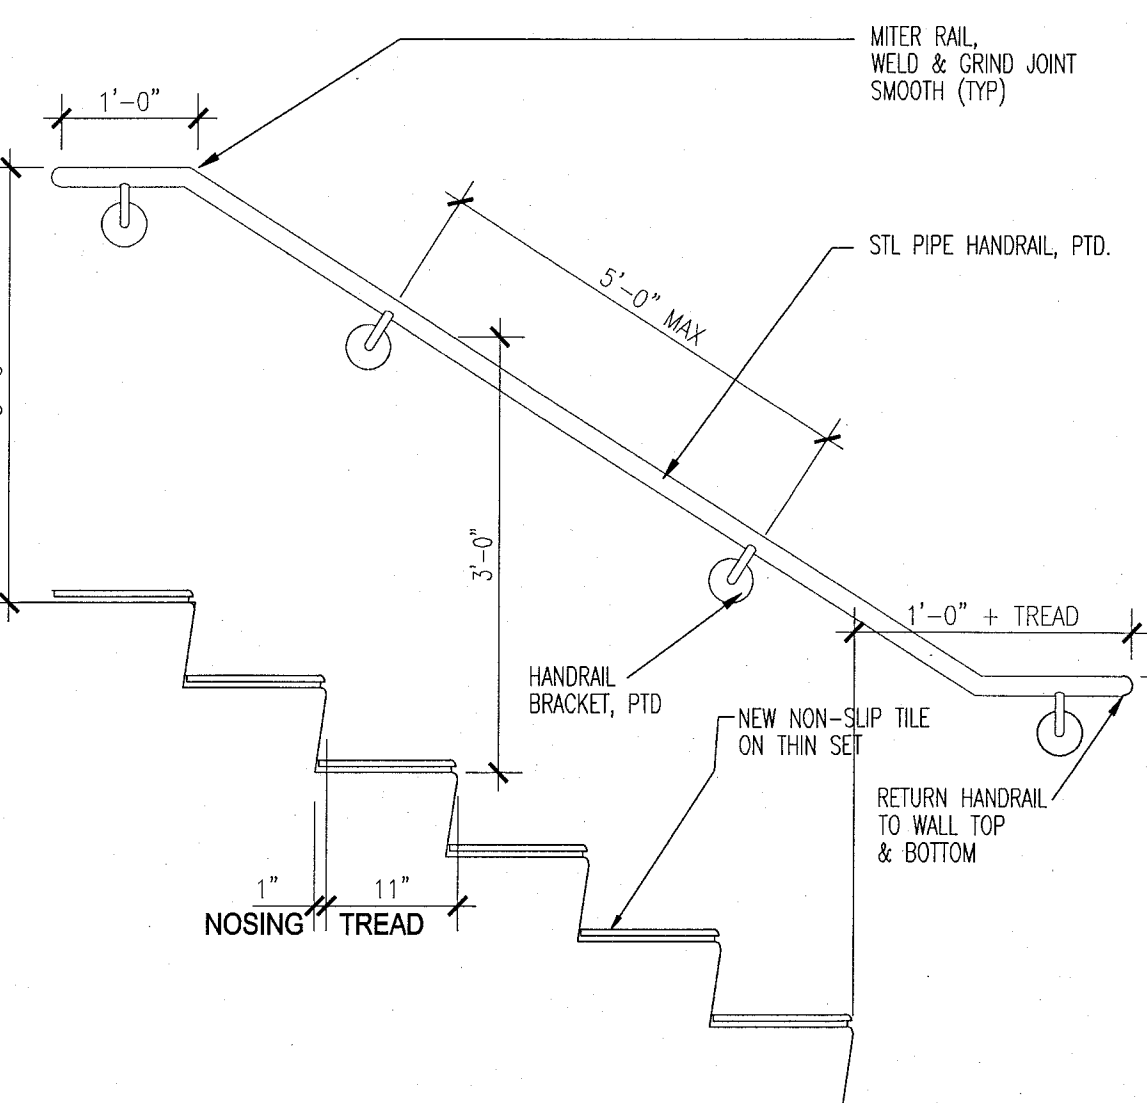

7 TYPICAL WALL RAIL DIAGRAM
SCALE: 1" = 1'-0"

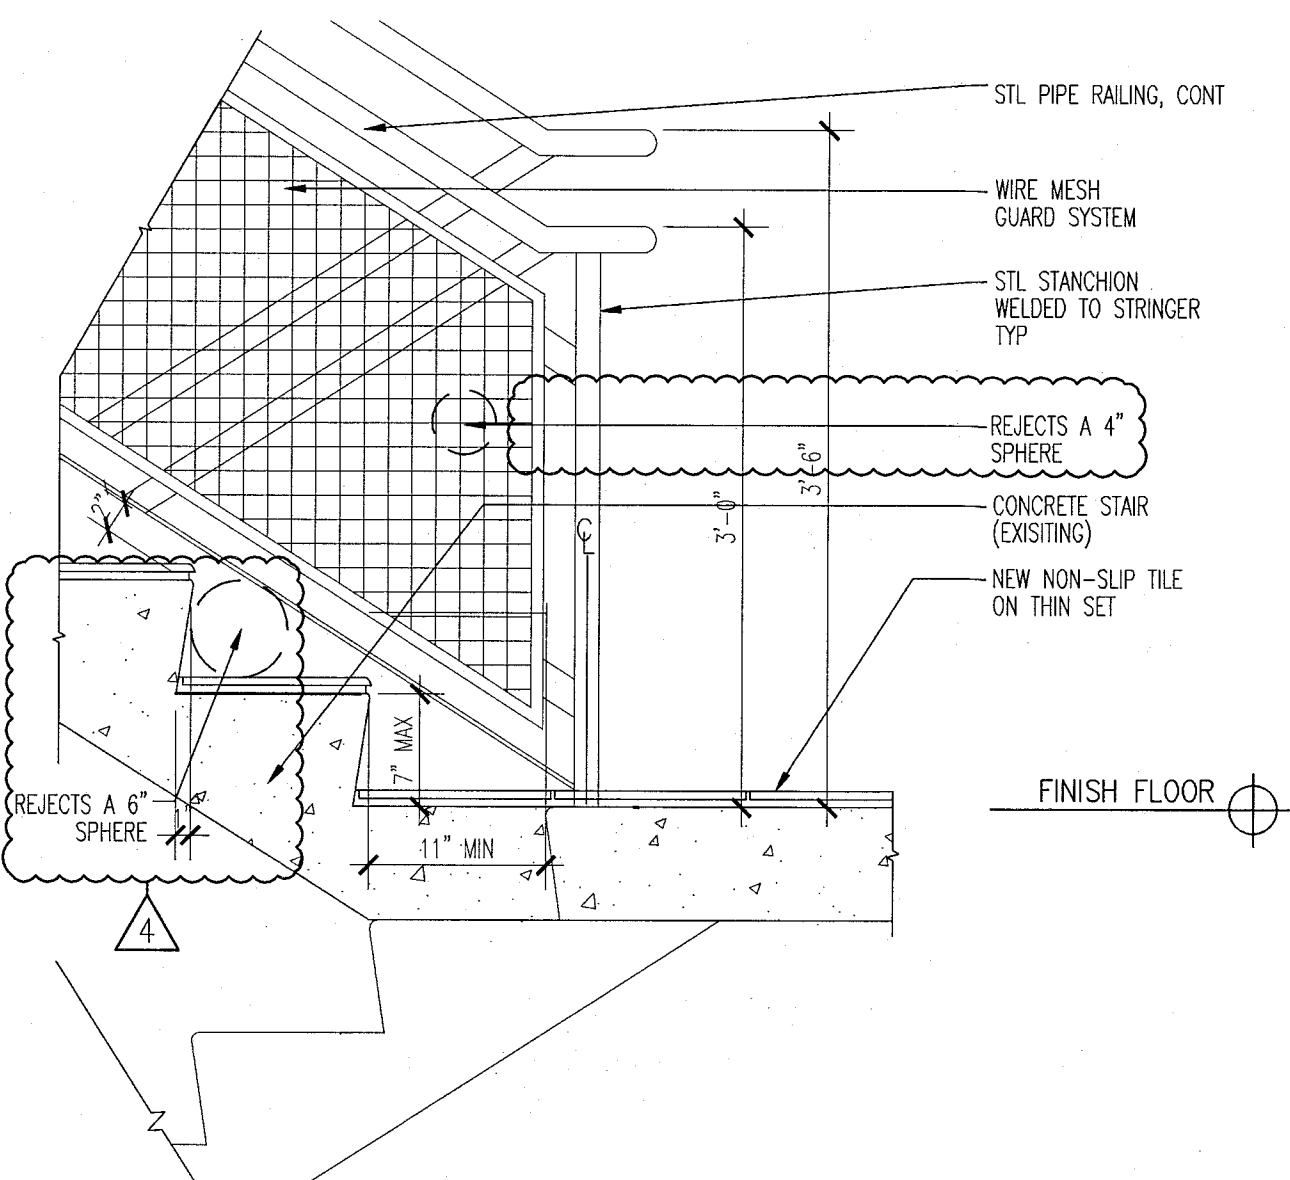

3 DETAIL AT FLOOR LANDING OFFSET TREAD
SCALE: 1" = 1'-0"

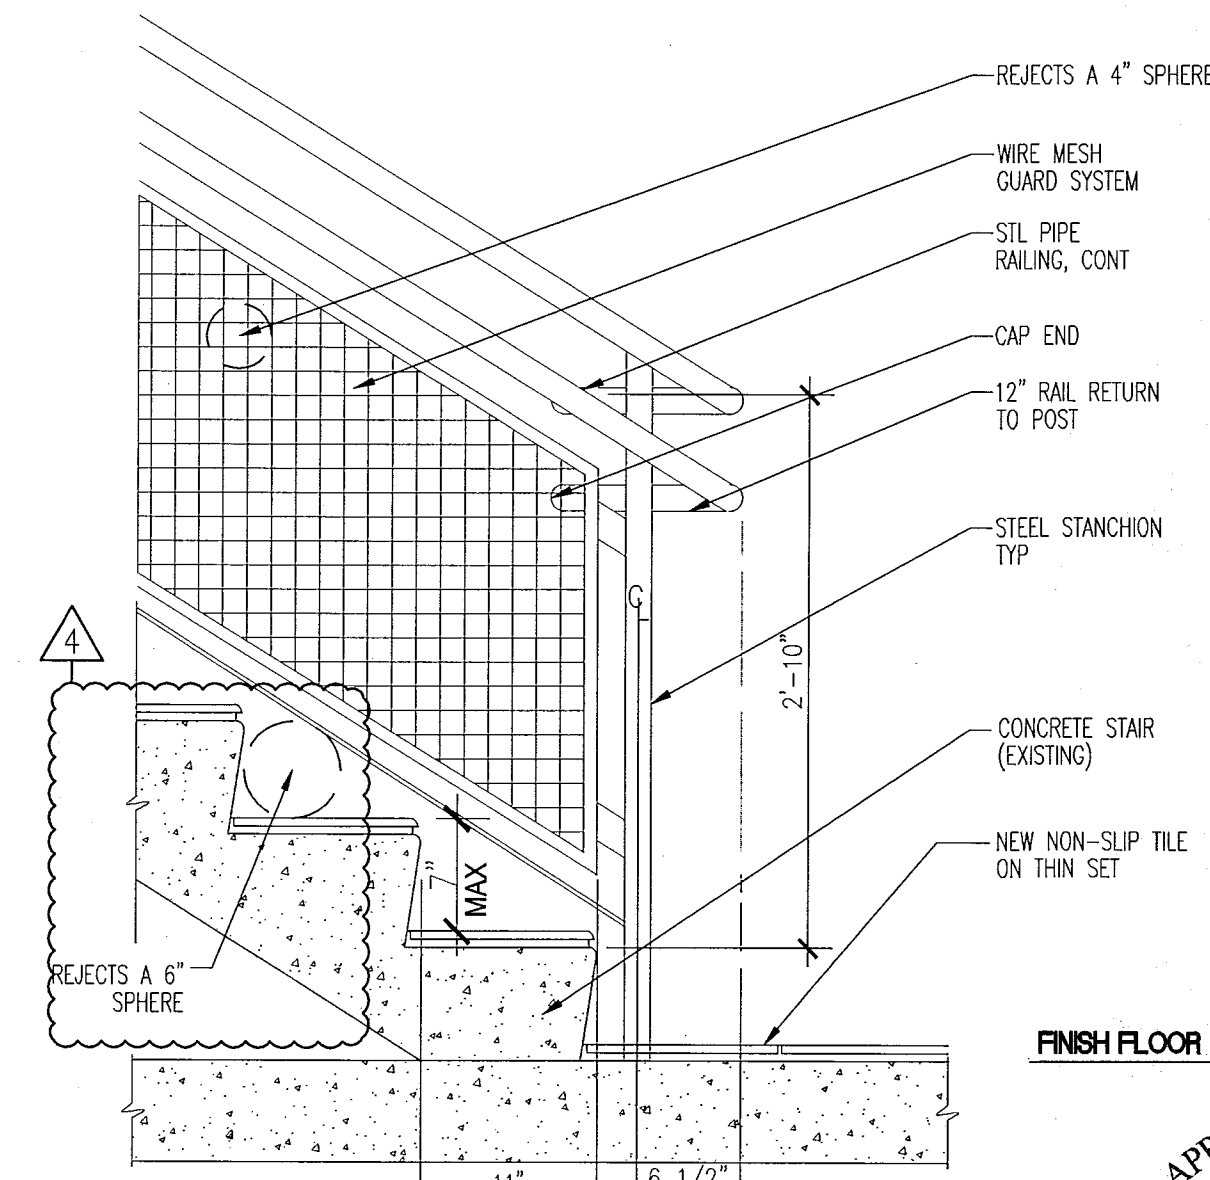

1 DETAIL AT BOTTOM LANDING
SCALE: 1" = 1'-0"

APPROVED
MIAMI BEACH
FIRE DEPARTMENT

- 1 NOTIFY THE ARCHITECT OF ANY UNEXPECTED FIELD CONDITION OR
2 ANY DISCREPANCY BEFORE PROCEEDING. GENERAL CONTRACTOR IS
3 TO COORDINATE THE COMPLETE SCOPE OF WORK WITH
4 CONSTRUCTION DOCUMENTS.
- 5 IF EXISTING OUTLETS OCCUR WITHIN 1'-0" OF A NEW OUTLET
6 LOCATION, VERIFY WITH ARCHITECT IF EXISTING LOCATION CAN
7 OVER RIDE FOR REUSE.
- 8 ALL OUTLETS PLACED WITHIN A 6'-0" RADIUS OF WET WALL
9 LOCATIONS TO BE GIC TYP.
- 10 GC TO COORDINATE ALL AUDIO/VISUAL EQUIPMENT NEEDS W/
11 TENANT.
- 12 ALL EXISTING OUTLETS TO REMAIN, U.O.N.
- 13 MOUNTING HEIGHTS OF ALL DEVICES ARE SHOWN ON POWER &
14 SIGNAL POWER ELEVATION, U.O.N. REFER TO A7-51.
- 15 ALL WORK SHALL COMPLY WITH FEDERAL, STATE, AND LOCAL
16 BUILDING CODES AND REGULATIONS.
- 17 LOCATION OF ALL POWER & SIGNAL DRIVES ARE TO BE
18 COORDINATED WITH ARCHITECTURAL DRAWINGS. NOTIFY ARCHITECT OF
19 ANY DISCREPANCIES BETWEEN ARCHITECTURAL AND ELECTRICAL
20 DRAWING PRIOR TO INSTALLATION. REFER TO ENGINEER'S DRAWINGS
21 FOR EQUIPMENT REQUIREMENTS.
- 22 ALL OUTLETS LOCATED ABOVE OR BELOW THE COUNTER TOPS IN
23 KITCHEN, COFFEE AREAS, TOILET ROOMS, ETC (WET AREAS) SHALL BE
24 GIC AS PER CODE (REFER TO ELECTRICAL DRAWINGS).

- 10 STAGGER ALL DEVICES SHOWN BACK TO BACK ON OPPOSITE SIDES OF SHARED PARTITIONS. DEVICE SHALL NOT OCCUPY THE SAME STUD CAVITY.
- 11 GROUP MULTIPLE DEVICES (POWER/SIGNAL) ON WALL TO BE ENGINEERED NOT MORE THAN 6" APART.
- 12 REFER TO DRAWING DRAWINGS FOR SMOKE DETECTOR, THERMOSTAT, FIRE HORN, STROBE LIGHT, AND PULL STATION LOCATIONS AND REQUIREMENTS, U.O.N. VERIFY LOCATIONS WITH ARCHITECT PRIOR TO CONSTRUCTION.
- 13 LOCATE SWITCHES 6" CLEAR OF THE EDGE OF THE DOOR FRAME, U.O.N. DOUBLE DOORS OR DOORS WITH Sidelights, LOCATE SWITCHES 3'-6" FROM DOOR AT SIDE WALL, U.O.N.
- 14 ALL WEP-3P DEVICES AND FIRE EXTINGUISHER CABINETS ARE TO BE ALIGNED ON CENTERLINE, U.O.N.
- 15 WHERE SWITCHES FOR DEVICES OTHER THAN LIGHTS (I.E. EXHAUST FAN) ARE ADJACENT TO LIGHT SWITCHES, LOCATE LIGHT SWITCHES CLOSEST TO THE ENTRY DOOR.
- 16 FINISHES FOR COVER PLATES TO BE WHITE U.O.N. FINISHES FOR ELECTRICAL AND FIRE ALARM DEVICES TO BE WHITE, U.O.N.

	EXISTING PARTITION TO REMAIN	GFCI	OUTLET - GROUND FAULT INTERRUPTOR CIRCUIT	3	THREE WAY SWITCH
	EXISTING BLOCK WALL TO REMAIN	4	NEW VOICE/DATA OUTLET	E	INDICATES EXISTING POWER/SIGNAL DEVICE
	NEW PARTITION	D	OUTLET-DEDICATED DUPLEX		
		1	RELOCATED THERMOSTAT		
	N.I.C. SHADING	P	NEW POWER OUTLET		
	EXISTING STRUCTURE	S	SWITCH		
	EXISTING DOOR TO REMAIN	PDP	OUTLET- CEILING COMBINATION POWER AND VOICE		
	NEW DOOR	TV	TELEVISION JACK		
	KEYNOTE INDICATOR	F	FLOOR QUAD		
		C	OUTLET - CEILING		

KEYPLAN N.T.S.

[illegible]

NORTH	SEAL

ADD Inc | Architecture Interiors Planning

One Biscayne Tower
Suite 1670
Two South
Biscayne Boulevard
Miami, FL 33131
T. 305.482.8700
F. 305.482.8770
www.addinc.com
Lic. # AA26001507


Boston Miami

JOB NUMBER:	13036.00
CHECKED BY:	
ISSUE DATE:	JANUARY 24, 2014
SCALE:	1/4" = 1'-0"

BASEMENT LEVEL POWER & SIGNAL PLAN

A700

COPYRIGHT ADD INC 2011

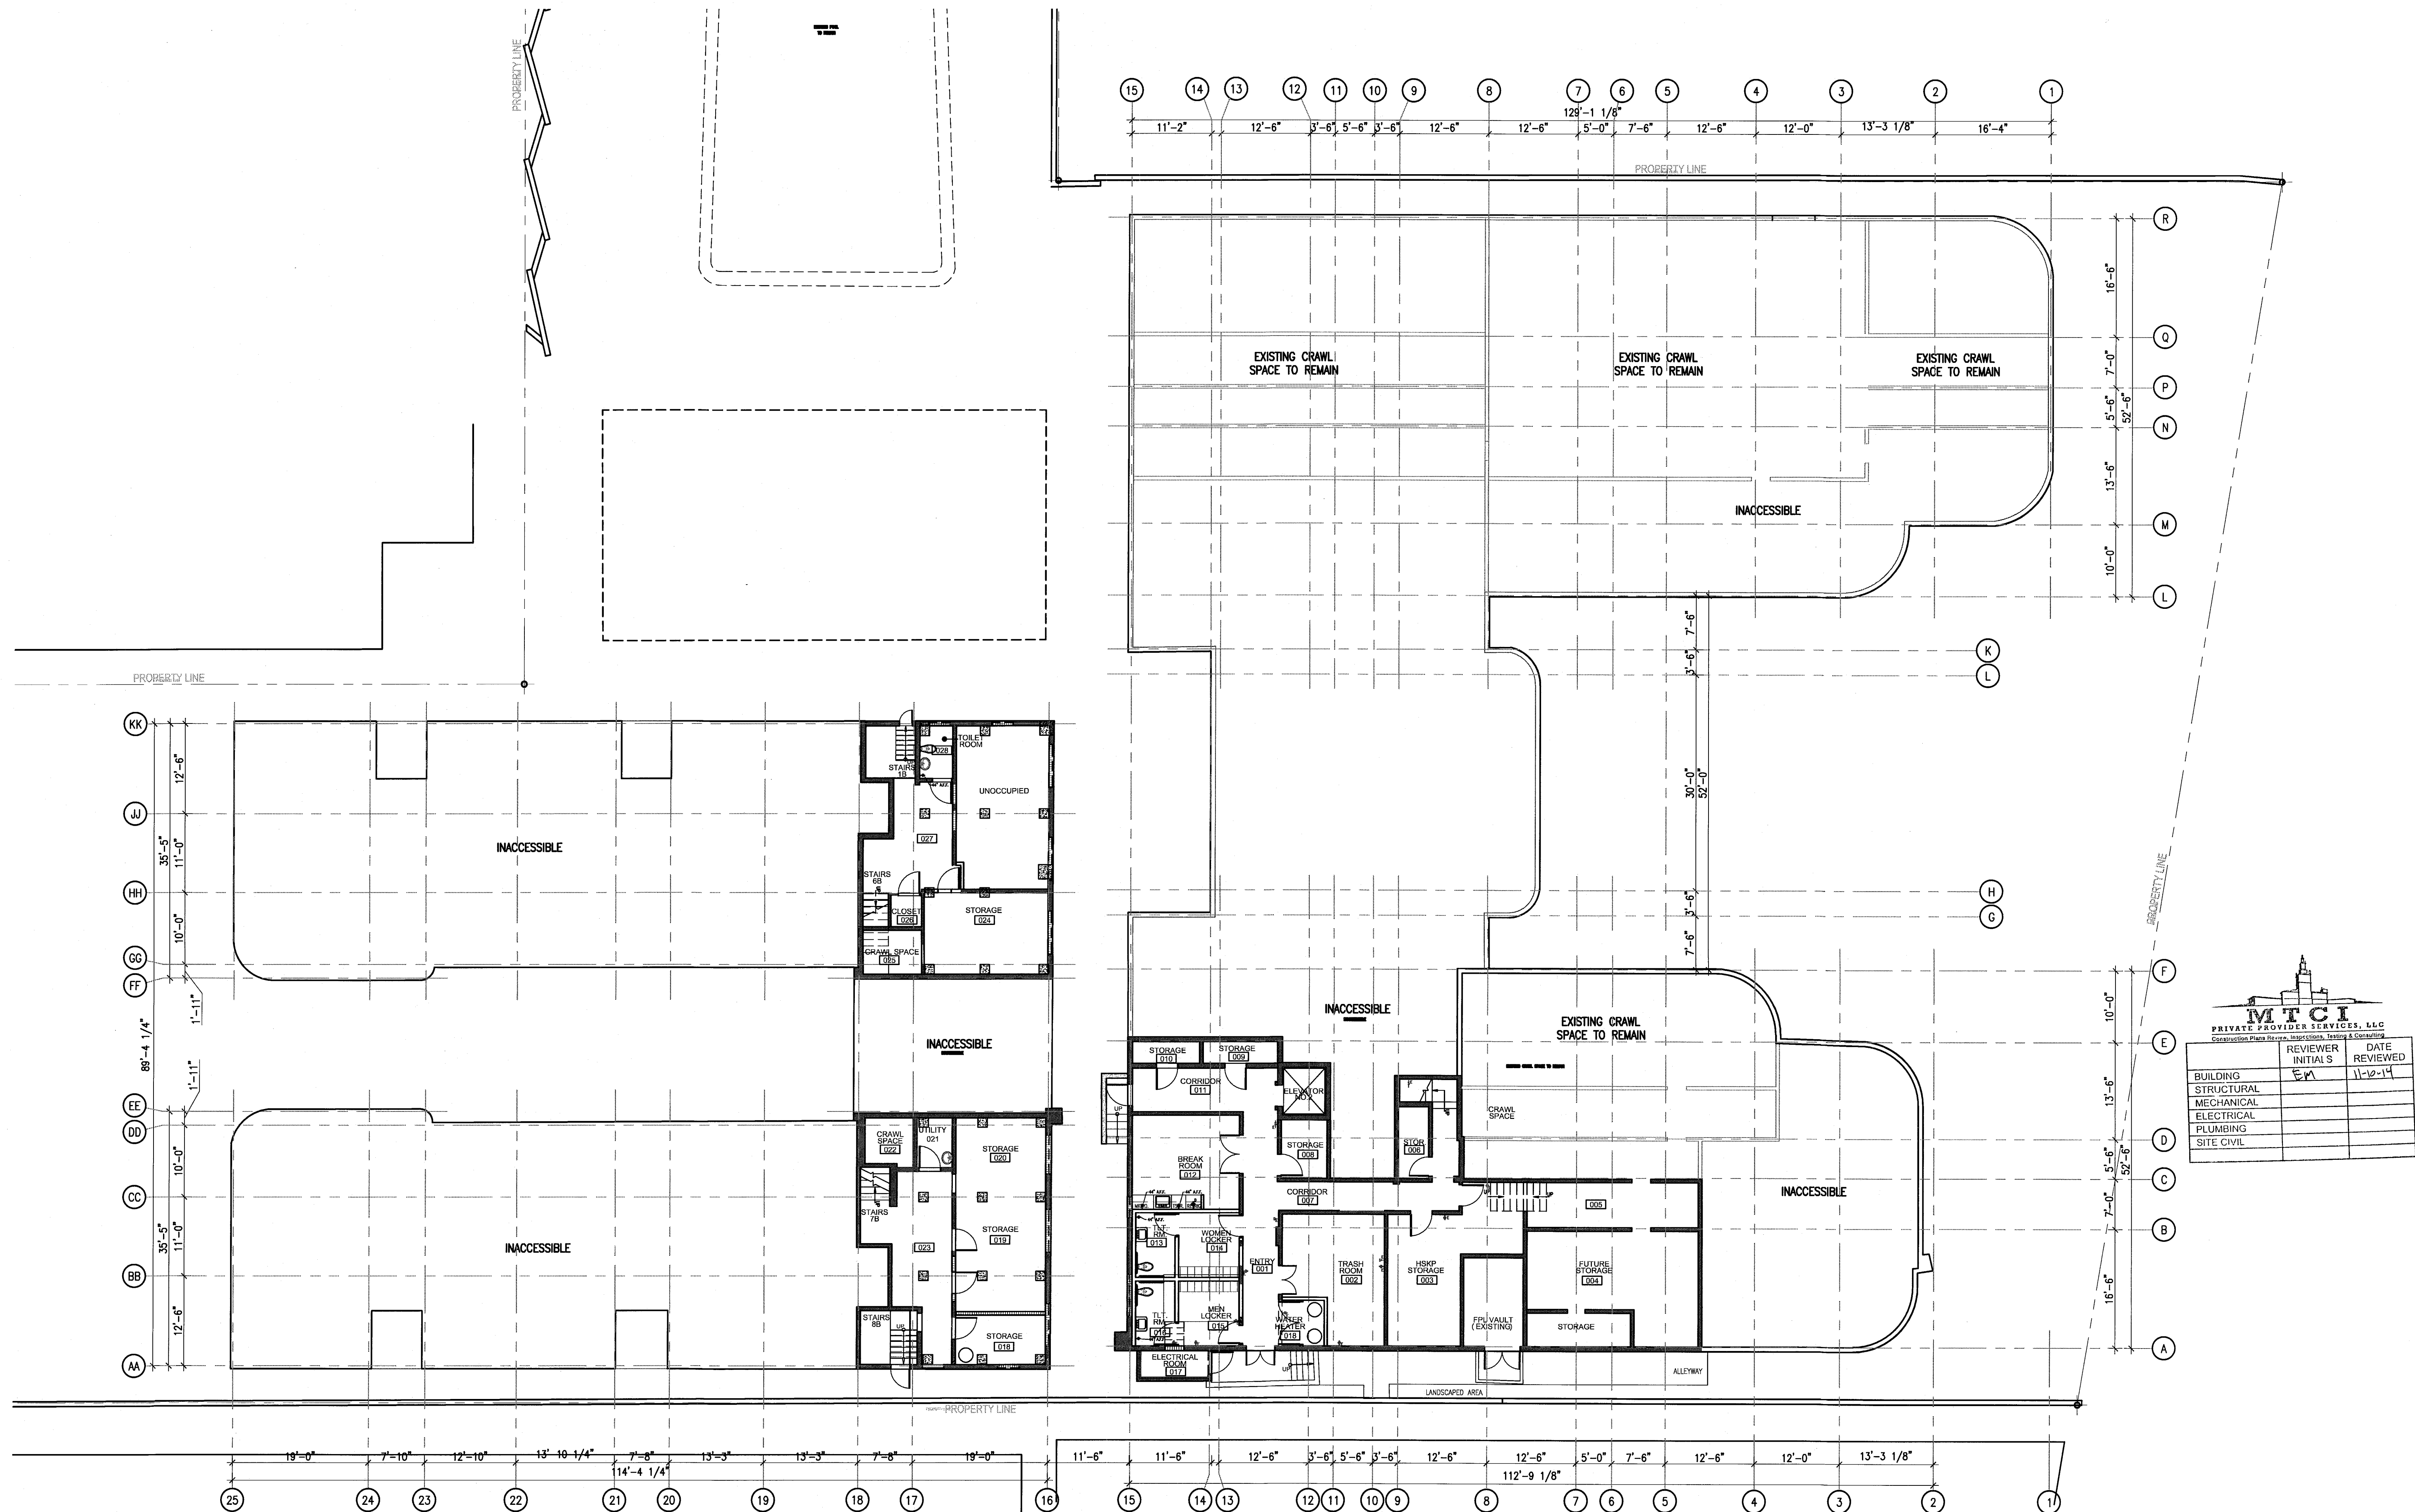


1 BASEMENT LEVEL POWER AND SIGNAL PLAN
SCALE: 3/32" = 1'-0"

APPROVED
MIAMI BEACH
FIRE DEPARTMENT

GENERAL NOTES


1. NOTIFY THE ARCHITECT OF ANY UNEXPECTED FIELD CONDITION OR ANY DISCREPANCY BEFORE PROCEEDING. GENERAL CONTRACTOR IS TO COORDINATE THE COMPLETE SCOPE OF WORK WITH CONSTRUCTION DOCUMENTS.
2. IF EXISTING OUTLETS OCCUR WITHIN 1'-0" OF A NEW OUTLET LOCATION, VERIFY WITH ARCHITECT IF EXISTING LOCATION CAN OVER RISE FOR REUSE.
3. ALL OUTLETS PLACED WITHIN A 6'-0" RADIUS OF NEW WALL LOCATIONS TO BE GFCI TYP.
4. GC TO COORDINATE ALL AUDIO/VISUAL EQUIPMENT NEEDS W/ TOWN.
5. ALL EXISTING OUTLETS TO REMAIN, U.O.N.
6. MOUNTING HEIGHTS OF ALL DEVICES ARE SHOWN ON POWER & SIGNAL DEVICE ELEVATION, U.O.N. REFER TO A751.
7. ALL WORK SHALL COMPLY WITH FEDERAL, STATE, AND LOCAL BUILDING CODES AND REGULATIONS.
8. LOCATION OF ALL POWER & SIGNAL DEVICES ARE TO BE COORDINATED WITH ARCHITECTURAL DRAWINGS. NOTIFY ARCHITECT OF ANY DISCREPANCIES BETWEEN ARCHITECTURAL AND ELECTRICAL DRAWINGS PRIOR TO INSTALLATION. REFER TO ENGINEER'S DRAWINGS FOR OTHER REQUIREMENTS.
9. ALL OUTLETS LOCATED ABOVE OR BELOW THE COUNTER TOPS IN KITCHENS, COFFEE AREAS, TOILET ROOMS, ETC. (NET HEAD) SHALL BE GFI AS PER CODE (REFER TO ELECTRICAL DRAWINGS).
10. STAGED ALL DEVICES SHOWN BACK TO BACK ON OPPOSITE SIDES OF SHUTTER PARTITIONS. DEVICES SHALL NOT OCCUPY THE SAME STAG DUTY.
11. GROUP MULTIPLE DEVICES (POWER/SIGNAL) ON WALL TO BE GROUPED NOT MORE THAN 6" APART.
12. REFER TO ENGINEERING DRAWINGS FOR SMOKE DETECTOR, THERMISTOR, FIRE HORN, STROBE LIGHT, AND PULL STATION LOCATIONS AND REQUIREMENTS, U.O.N. VERIFY LOCATIONS WITH ARCHITECT PRIOR TO CONSTRUCTION.
13. LOCATE SWITCHES 6" CLEAR OF THE EDGE OF THE DOOR FRAME, U.O.N. AT DOUBLE DOORS OR DOORS WITH SIGHTGLASS, LOCATE SWITCHES 3'-8" FROM DOOR AT SIDE WALL, U.O.N.
14. ALL WEP-FP DEVICES AND FIRE EXTINGUISHER CABINETS ARE TO BE ADJACENT TO CORRIDOR, U.O.N.
15. WHERE SWITCHES FOR SMOKE OTHER THAN LIGHTS (I.E. EXHAUST FAN) ARE ADJACENT TO LIGHT SWITCHES, LOCATE LIGHT SWITCHES CLOSEST TO THE ENTRY DOOR.
16. FINISHES FOR COVER PLATES TO BE WHITE, U.O.N. FINISHES FOR ELECTRICAL AND FIRE ALARM DEVICES TO BE WHITE, U.O.N.

LEGEND

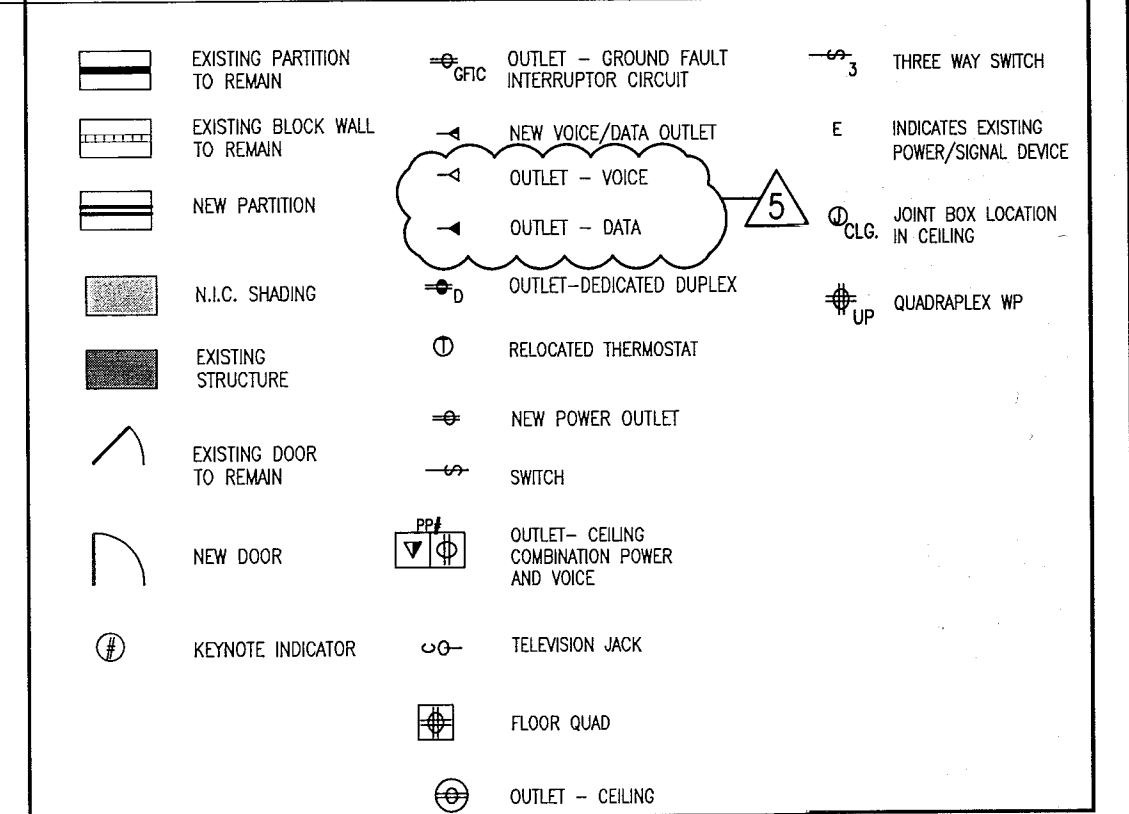

HADDON HALL
1500 COLLINS AVE
MIAMI BEACH, FL

KEYPLAN N.T.S.

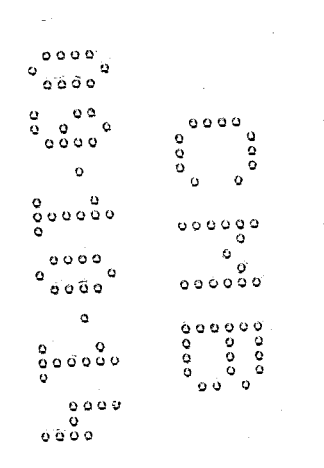


REVISIONS

NO.	DESCRIPTION	ISSUE DATE
1	PROGRESS TO 100% CD	02-18-2014
2	GUESTROOM COORDINATION	03-14-2014

100% CONSTRUCTION DOCUMENT SET

NORTH

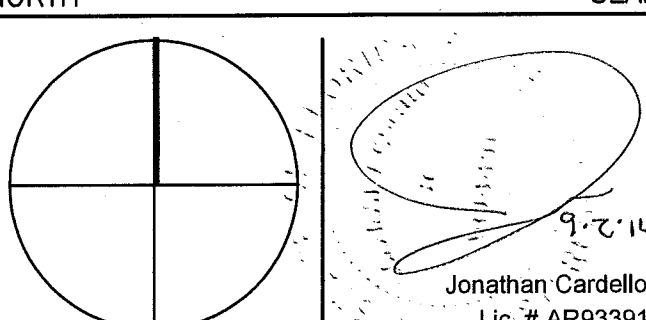

ADD Inc

Architecture Interiors Planning

One Biscayne Tower
Suite 1670
Two South
Biscayne Boulevard
Miami, FL 33131
T. 305.482.8700
F. 305.482.8770
www.addinc.com
Lic. # A426001507

JOB NUMBER: 13036.00

CHECKED BY:

ISSUE DATE: FEBRUARY 18, 2014

SCALE: 1/8" = 1'-0"

SHEET TITLE

FIRST FLOOR
POWER & SIGNAL
PLAN

SHEET NUMBER

A701

COPYRIGHT ADD INC 2011

1 FIRST FLOOR POWER & SIGNAL PLAN
SCALE: 1/8" = 1'-0"

GENERAL NOTES

1. NOTIFY THE ARCHITECT OF ANY UNEXPECTED FIELD CONDITION OR ANY DISCREPANCY BEFORE PROCEEDING. GENERAL CONTRACTOR IS TO COORDINATE THE COMPLETE SCOPE OF WORK WITH CONSTRUCTION DOCUMENTS.
2. IF EXISTING OUTLETS OCCUR WITHIN 1'-0" OF A NEW OUTLET LOCATION, VERIFY WITH ARCHITECT IF EXISTING LOCATION CAN OVER FUSE FOR REUSE.
3. ALL OUTLETS PLACED WITHIN A 6'-0" RADIUS OF MET WALL LOCATIONS TO BE GFCI TYPE.
4. CO-ORDINATE ALL AUDIO/VISUAL EQUIPMENT NEEDS W/ TENANT.
5. ALL EXISTING OUTLETS TO REMAIN, U.O.N.
6. MOUNTING HEIGHTS OF ALL DEVICES ARE SHOWN ON POWER & SIGNAL DEVICE ELEVATION, U.O.N. REFER TO A751.
7. ALL WORK SHALL COMPLY WITH FEDERAL, STATE, AND LOCAL BUILDING CODES AND REGULATIONS.
8. LOCATION OF ALL POWER & SIGNAL DEVICES ARE TO BE COORDINATED WITH ARCHITECTURAL DRAWINGS. NOTIFY ARCHITECT OF ANY DISCREPANCIES BETWEEN ARCHITECTURAL AND ELECTRICAL DRAWINGS PRIOR TO INSTALLATION. REFER TO ENGINEER'S DRAWINGS FOR OTHER REQUIREMENTS.
9. ALL OUTLETS LOCATED ABOVE OR BELOW THE COUNTER TOPS IN KITCHEN, COTTAGE AREAS, TOILET ROOMS, ETC. (NET AREAS) SHALL BE GFI AS PER CODE (REFER TO ELECTRICAL DRAWINGS).
10. STAGGER ALL DEVICES SHOWN BACK TO BACK ON OPPOSITE SIDES OF SHARED PARTITIONS. DEVICES SHALL NOT OCCUPY THE SAME STUD Cavity.
11. GROUP MULTIPLE DEVICES (POWER/SIGNAL) ON WALL TO BE GROUPED NOT MORE THAN 6" APART.
12. REFER TO ENGINEERING DRAWINGS FOR SMOKE DETECTOR, THERMISTOR, FIRE ALARM, SMOKE LIGHT, AND PULL STATION LOCATIONS AND REQUIREMENTS, U.O.N. VERIFY LOCATIONS WITH ARCHITECT PRIOR TO CONSTRUCTION.
13. LOCATE SWITCHES 6" CLEAR OF THE EDGE OF THE DOOR FRAME, U.O.N. AT DOUBLE DOORS OR DOORS WITH DRILLINGS, LOCATE SWITCHES 3'-0" FROM DOOR AT SIDE WALL, U.O.N.
14. ALL MEP-FF DEVICES AND FIRE EXTINGUISHER CABINETS ARE TO BE ADJUSTED ON CENTERLINE, U.O.N.
15. WHERE SWITCHES FOR DEVICES OTHER THAN LIGHTS (I.E. EXHAUST FAN) ARE ADJACENT TO LIGHT SWITCHES, LOCATE LIGHT SWITCHES CLOSEST TO THE ENTRY DOOR.
16. FINISHES FOR COVER PLATES TO BE WHITE, U.O.N. FINISHES FOR ELECTRICAL AND FIRE ALARM DEVICES TO BE WHITE, U.O.N.

SHEET NOTES

LEGEND

- EXISTING PARTITION TO REMAIN
- EXISTING BLOCK WALL TO REMAIN
- NEW PARTITION
- N.I.C. SHOWN
- EXISTING STRUCTURE
- EXISTING DOOR TO REMAIN
- NEW DOOR
- KEYNOTE INDICATOR
- OUTLET - GROUND FAULT INTERRUPTER CIRCUIT
- NEW VOLTAGE/AMPERE OUTLET
- OUTLET - VOICE
- OUTLET - DATA
- OUTLET - DEDICATED DUPLEX
- REDUCED THERMOSTAT
- NEW POWER OUTLET
- SWITCH
- OUTLET - CEILING CONCEALED POWER AND VOICE
- TELEPHONE JACK
- FLOOR GUARD
- OUTLET - CEILING
- THREE WAY SWITCH
- INDICATES EXISTING POWER/SIGNAL DEVICES
- JOINT BOX LOCATION IN CEILING
- QUADPLEX WP


HADDON HALL
1500 COLLINS AVE
MIAMI BEACH, FL

KEYPLAN N.T.S.

REVISIONS

NO.	DESCRIPTION	ISSUE DATE
1	PROGRESS TO 100% CD	02-18-2014
2	GUESTROOM COORDINATION	03-14-2014

100% CONSTRUCTION DOCUMENT SET

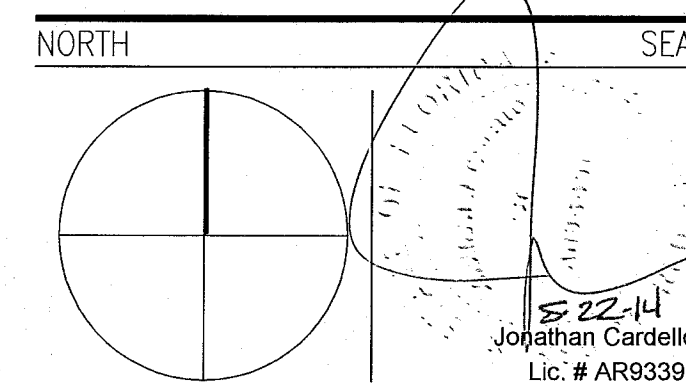

ADD Inc Architecture Interiors Planning

One Biscayne Tower
Suite 1670
Two South
Biscayne Boulevard
Miami, FL 33131
T. 305.482.8700
F. 305.482.8770
www.addinc.com
Lic. # AA28001507

JOB NUMBER: 13036.00
CHECKED BY:
ISSUE DATE: FEBRUARY 18, 2014
SCALE: 1/8" = 1'-0"


SHEET TITLE

SECOND FLOOR
POWER & SIGNAL
PLAN

SHEET NUMBER

A702

COPYRIGHT ADD INC 2011

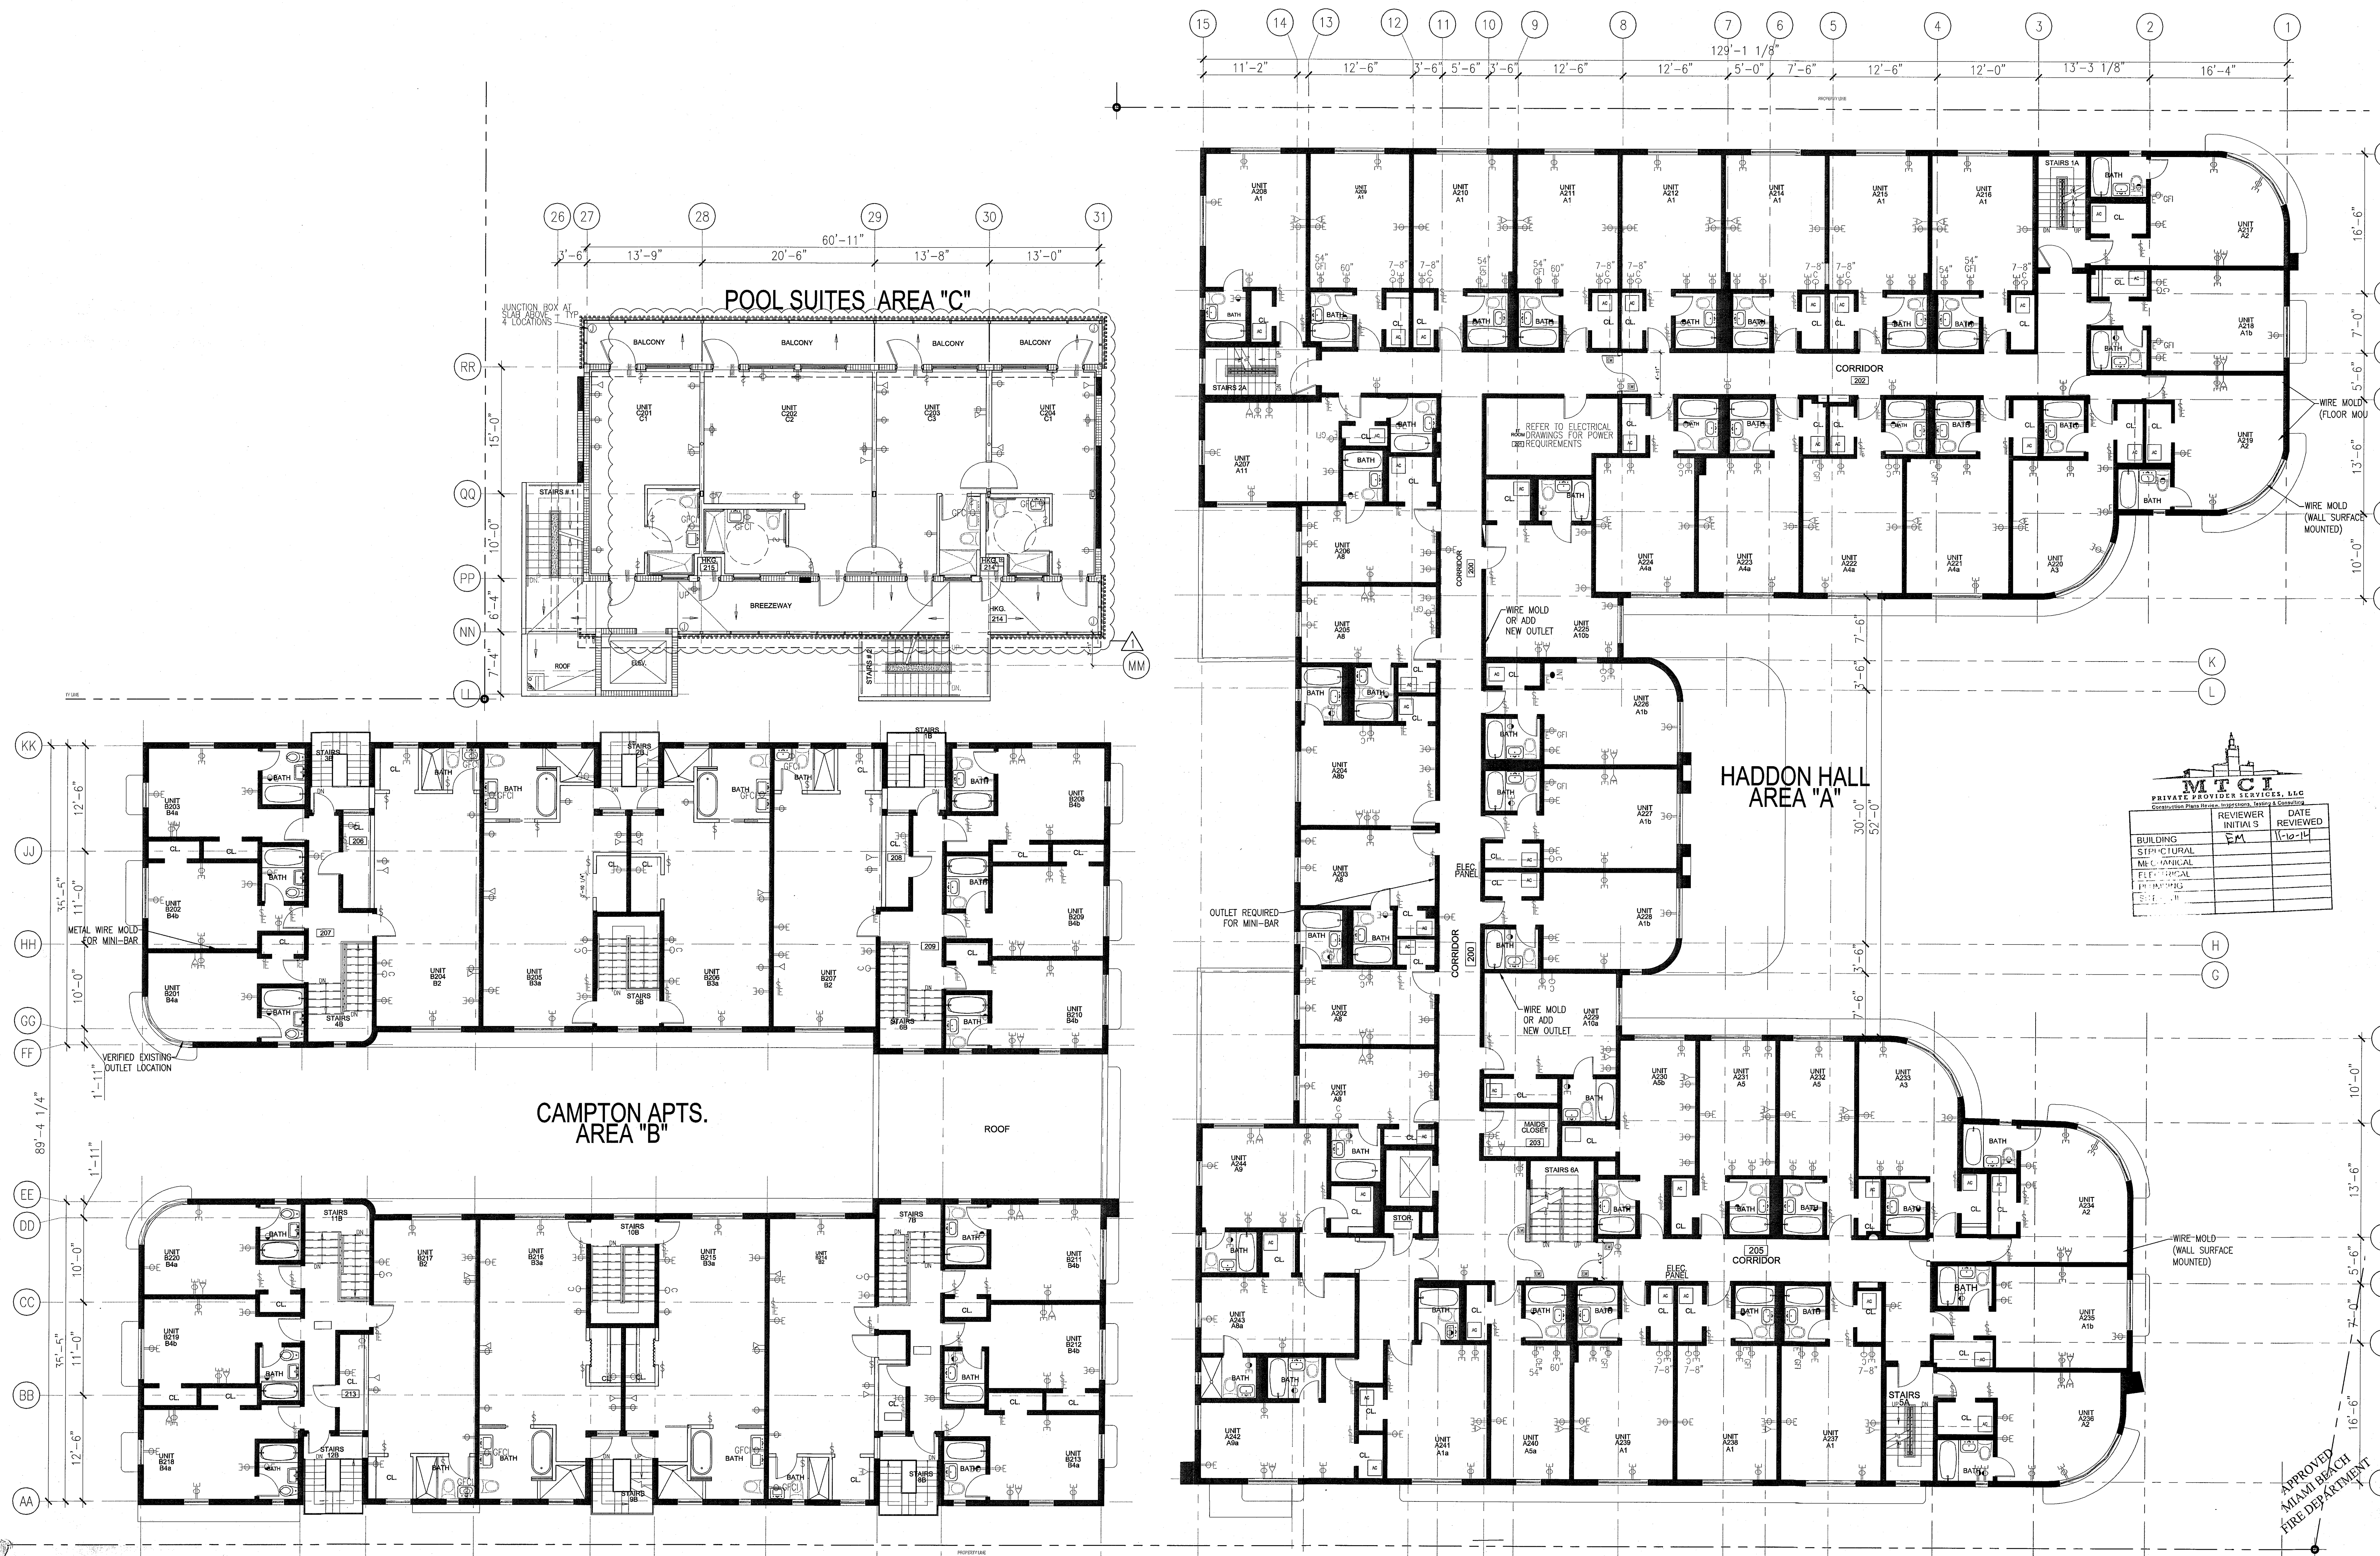

1 SECOND FLOOR POWER & SIGNAL PLAN
SCALE: 1/8" = 1'-0"

GENERAL NOTES

1. NOTIFY THE ARCHITECT OF ANY UNEXPECTED FIELD CONDITION OR ANY DISCREPANCY BEFORE PROCEEDING. GENERAL CONTRACTOR IS TO COORDINATE THE COMPLETE SCOPE OF WORK WITH CONSTRUCTION DOCUMENTS.
2. IF EXISTING OUTLETS OCCUR WITHIN 1'-0" OF A NEW OUTLET LOCATION, VERIFY WITH ARCHITECT IF EXISTING LOCATION CAN OVER RIDE FOR REUSE.
3. ALL OUTLETS PLACED WITHIN A 6'-0" RADIUS OF NEW WALL LOCATIONS TO BE GFCI TYPE.
4. GO TO COORDINATE ALL AUDIO/VISUAL EQUIPMENT NEEDS W/ TENANT.
5. ALL EXISTING OUTLETS TO REMAIN, U.O.N.
6. MOUNTING HEIGHTS OF ALL DEVICES ARE SHOWN ON POWER & SIGNAL DEVICE ELEVATION, U.O.N. REFER TO A751.
7. ALL WORK SHALL COMPLY WITH FEDERAL, STATE, AND LOCAL BUILDING CODES AND REGULATIONS.
8. LOCATION OF ALL POWER & SIGNAL DEVICES ARE TO BE COORDINATED WITH ARCHITECTURAL DRAWINGS. NOTIFY ARCHITECT OF ANY DISCREPANCIES BETWEEN ARCHITECTURAL AND ELECTRICAL DRAWING PRIOR TO INSTALLATION. REFER TO ENGINEER'S DRAWINGS FOR OTHER REQUIREMENTS.
9. ALL OUTLETS LOCATED ABOVE OR BELOW THE COUNTER TOPS IN KITCHEN, COFFEE AREAS, TOILET ROOMS, ETC. (WET AREAS) SHALL BE GFI AS PER CODE (REFER TO ELECTRICAL DRAWINGS).
10. STAGGER ALL DEVICES SHOWN BACK TO BACK ON OPPOSITE SIDES OF SHARED PARTITIONS. DEVICES SHALL NOT OCCUPY THE SAME STUD CAVITY.
11. GROUP MULTIPLE DEVICES (POWER/SIGNAL) ON WALL TO BE GROUPED NOT MORE THAN 6" APART.
12. REFER TO ENGINEERING DRAWINGS FOR SMOKE DETECTOR, THERMOSTAT, FIRE ALARM, SMOKE LIGHT, AND PULL STATION LOCATIONS AND REQUIREMENTS, U.O.N. VERIFY LOCATIONS WITH ARCHITECT PRIOR TO CONSTRUCTION.
13. LOCATE SWITCHES 6" CLEAR OF THE EDGE OF THE DOOR FRAME, U.O.N. AT DOUBLE DOORS OR DOORS WITH SILENTS, LOCATE SWITCHES 3'-6" FROM DOOR AT SIDE WALL, U.O.N.
14. ALL WEP-PP DEVICES AND FIRE EXTINGUISHER CABINETS ARE TO BE ADJACENT ON CENTERLINE, U.O.N.
15. WHERE SWITCHES FOR DEVICES OTHER THAN LIGHTS (I.E. EXHAUST FAN) ARE ADJACENT TO LIGHT SWITCHES, LOCATE LIGHT SWITCHES CLOSEST TO THE ENTRY DOOR.
16. FINISHES FOR COVER PLATES TO BE WHITE, U.O.N. FINISHES FOR ELECTRICAL AND FIRE ALARM DEVICES TO BE WHITE, U.O.N.

SHEET NOTES

LEGEND

- EXISTING PARTITION TO REMAIN
- EXISTING BLOCK WALL TO REMAIN
- NEW PARTITION
- N.L.C. SHADING
- EXISTING STRUCTURE
- EXISTING DOOR TO REMAIN
- NEW DOOR
- KEYNOTE INDICATOR
- OUTLET - GROUND FAULT INTERRUPTOR CIRCUIT
- NEW VOICE/DATA OUTLET
- OUTLET - VOICE
- OUTLET - DATA
- OUTLET - DEDICATED DUPLEX
- RELOCATED THERMOSTAT
- NEW POWER OUTLET
- SWITCH
- OUTLET - CEILING CONDUIT/POWER AND VOICE
- TELEVISION JACK
- FLOOR QUAD
- OUTLET - CEILING
- THREE WAY SWITCH
- INDICATES EXISTING POWER/SIGNAL DEVICE
- JOINT BOX LOCATION IN CLASH
- QUICK-RELEASE WP


HADDON HALL 1500 COLLINS AVE MIAMI BEACH, FL

KEYPLAN N.T.S.

REVISIONS

NO.	DESCRIPTION	ISSUE DATE
1	PROGRESS TO 100% CD	02-18-2014

100% CONSTRUCTION DOCUMENT SET

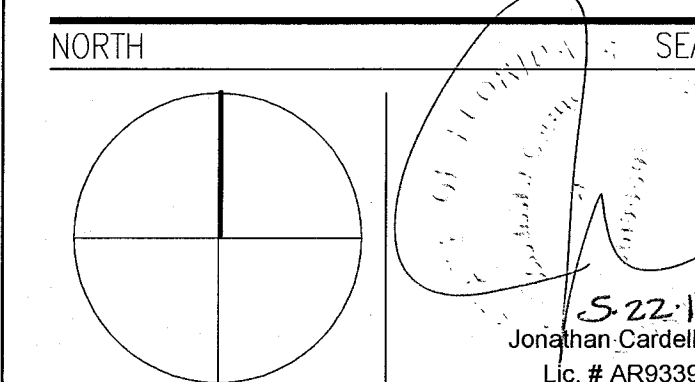

ADD Inc Architecture Interiors Planning

One Biscayne Tower
Suite 1670
Two South
Biscayne Boulevard
Miami, FL 33131
T. 305.482.8700
F. 305.482.8770
www.addinc.com
Lic. # AA26001507

JOB NUMBER: 13036.00
CHECKED BY:
ISSUE DATE: FEBRUARY 18, 2014
SCALE: 1/8" = 1'-0"

SHEET TITLE

THIRD FLOOR POWER & SIGNAL PLAN


SHEET NUMBER

A703

COPYRIGHT ADD INC 2011

1 THIRD FLOOR POWER & SIGNAL PLAN

SCALE: 1/8" = 1'-0"

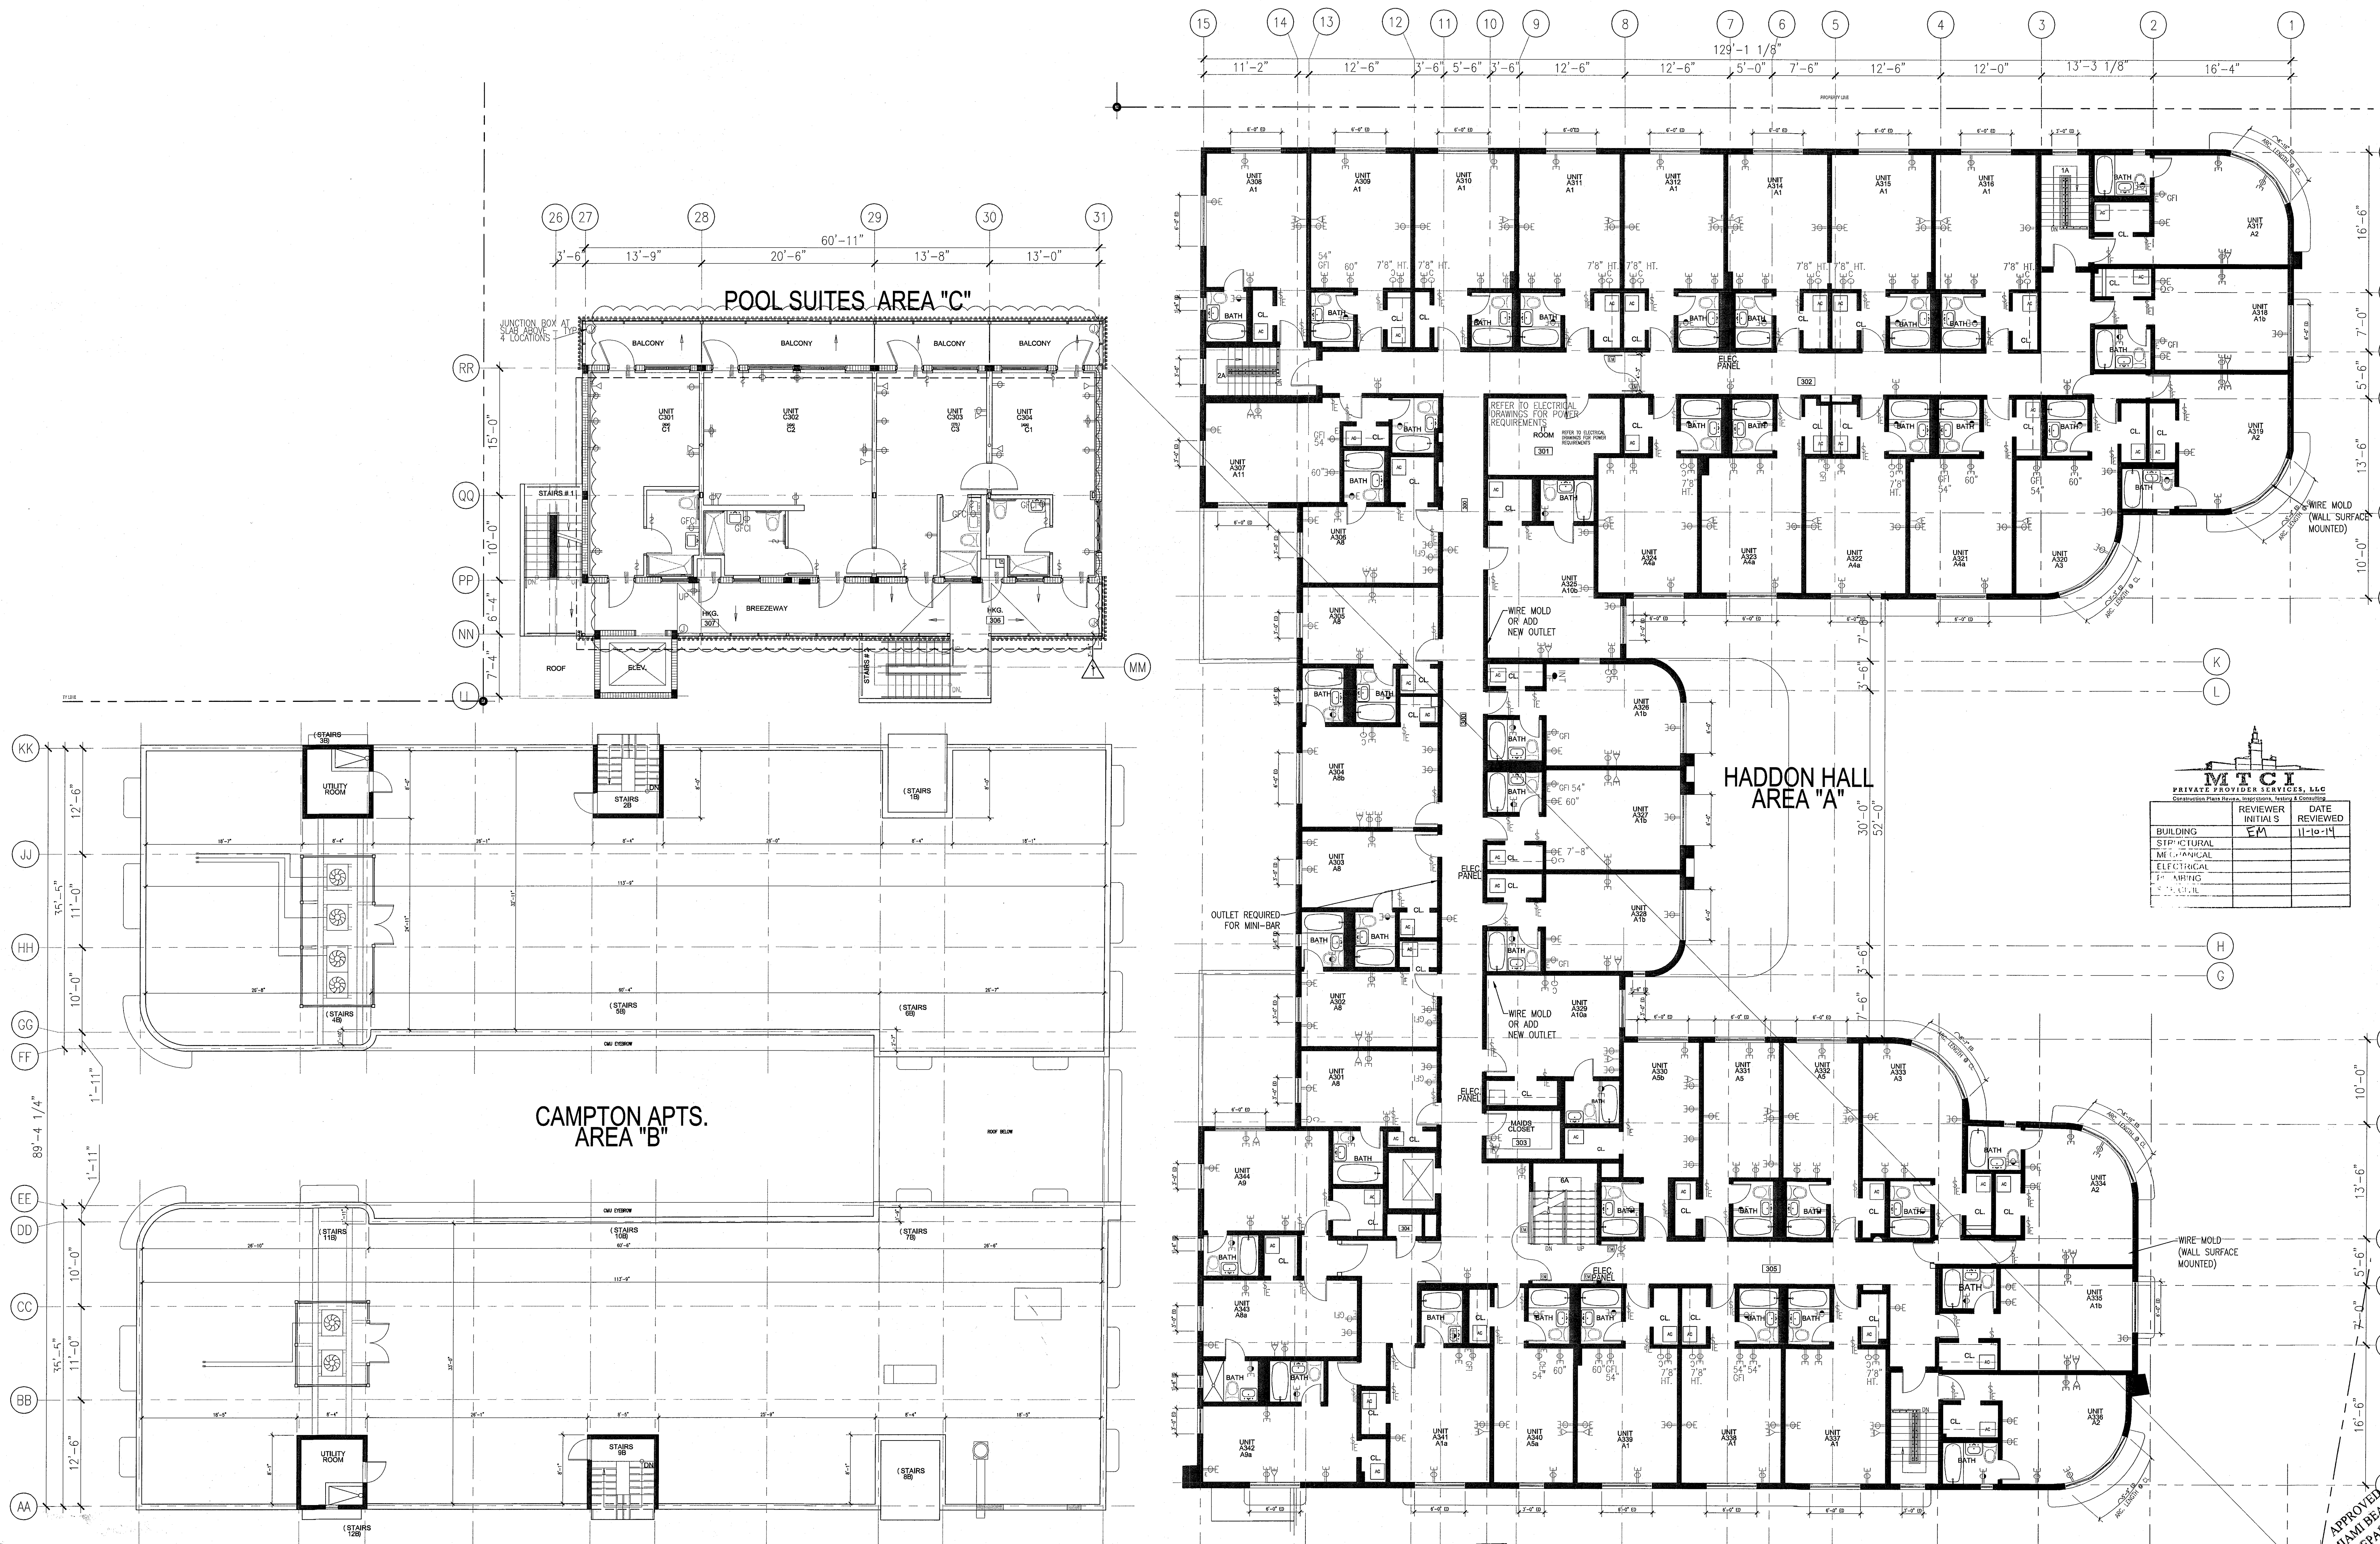

APPROVED
MIAMI BEACH
FIRE DEPARTMENT

GENERAL NOTES

- NOTIFY THE ARCHITECT OF ANY UNEXPECTED FIELD CONDITION OR ANY DISCREPANCY BEFORE PROCEEDING. GENERAL CONTRACTOR IS TO COORDINATE THE COMPLETE SCOPE OF WORK WITH CONSTRUCTION DOCUMENTS.
- IF EXISTING OUTLETS OCCUR WITHIN 1'-0" OF A NEW OUTLET LOCATION, VERIFY WITH ARCHITECT IF EXISTING LOCATION CAN OVER RIDE FOR REUSE.
- ALL OUTLETS PLACED WITHIN A 6'-0" RADIUS OF WET WALL LOCATIONS TO BE GFCI TYP.
- GC TO COORDINATE ALL AUDIO/VISUAL EQUIPMENT NEEDS W/ TENANT.
- ALL EXISTING OUTLETS TO REMAIN, U.O.N.
- MOUNTING HEIGHTS OF ALL DEVICES ARE SHOWN ON POWER & SIGNAL DEVICE ELEVATION, U.O.N. REFER TO A751.
- ALL WORK SHALL COMPLY WITH FEDERAL, STATE, AND LOCAL BUILDING CODES AND REGULATIONS.
- LOCATION OF ALL POWER & SIGNAL DEVICES ARE TO BE COORDINATED WITH ARCHITECTURAL DRAWINGS. NOTIFY ARCHITECT OF ANY DISCREPANCIES BETWEEN ARCHITECTURAL AND ELECTRICAL DRAWING PRIOR TO INSTALLATION. REFER TO ENGINEER'S DRAWINGS FOR OTHER REQUIREMENTS.
- ALL OUTLETS LOCATED ABOVE OR BELOW THE COUNTER TOPS IN KITCHEN, COFFEE AREAS, TOILET ROOMS, ETC (WET AREAS) SHALL BE GFI AS PER CODE (REFER TO ELECTRICAL DRAWINGS).

- STAGGER ALL DEVICES SHOWN BACK TO BACK ON OPPOSITE SIDES OF SHARED PARTITIONS. DEVICE SHALL NOT OCCUPY THE SAME STUD CAVITY.
- GROUP MULTIPLE DEVICES (POWER/SIGNAL) ON WALL TO BE GROUPED NOT MORE THAN 6" APART.
- REFER TO ENGINEERING DRAWINGS FOR SMOKE DETECTOR, THERMOSTAT, FIRE HORN, STROBE LIGHT, AND PHIL. STATION LOCATIONS AND REQUIREMENTS, U.O.N. VERIFY LOCATIONS WITH ARCHITECT PRIOR TO CONSTRUCTION.
- LOCATE SWITCHES 6" CLEAR OF THE EDGE OF THE DOOR FRAME, U.O.N. AT DOUBLE DOORS OR DOORS WITH SIDELIGHTS, LOCATE SWITCHES 3'-6" FROM DOOR AT SIDE WALL, U.O.N.
- ALL WET-TP DEVICES AND FIRE EXTINGUISHER CABINETS ARE TO BE ALIGNED ON CENTERLINE, U.O.N.
- WHERE SWITCHES FOR DEVICES OTHER THAN LIGHTS (I.E. EXHAUST FAN) ARE ADJACENT TO LIGHT SWITCHES, LOCATE LIGHT SWITCHES CLOSEST TO THE ENTRY DOOR.
- FINISHES FOR COVER PLATES TO BE WHITE U.O.N. FINISHES FOR ELECTRICAL AND FIRE ALARM DEVICES TO BE WHITE, U.O.N.

SHEET NOTES

LEGEND


- | | | | | | |
|--|-------------------------------|--|--|--|--|
| | EXISTING PARTITION TO REMAIN | | OUTLET - GROUND FAULT INTERRUPTOR CIRCUIT | | THREE WAY SWITCH |
| | EXISTING BLOCK WALL TO REMAIN | | NEW VOICE/DATA OUTLET | | INDICATES EXISTING POWER/SIGNAL DEVICE |
| | NEW PARTITION | | OUTLET-DEDICATED DUPLEX | | |
| | N.L.C. SHADING | | RELOCATED THERMOSTAT | | |
| | EXISTING STRUCTURE | | NEW POWER OUTLET | | |
| | EXISTING DOOR TO REMAIN | | SWITCH | | |
| | NEW DOOR | | OUTLET - CEILING COMBINATION POWER AND VOICE | | |
| | KEYNOTE INDICATOR | | TELEVISION JACK | | |
| | | | FLOOR QUAD | | |
| | | | OUTLET - CEILING | | |

HADDON HALL
1500 COLLINS AVE
MIAMI BEACH, FL

KEYPLAN N.T.S.

REVISIONS		
NO.	DESCRIPTION	ISSUE DATE

PERMIT SET

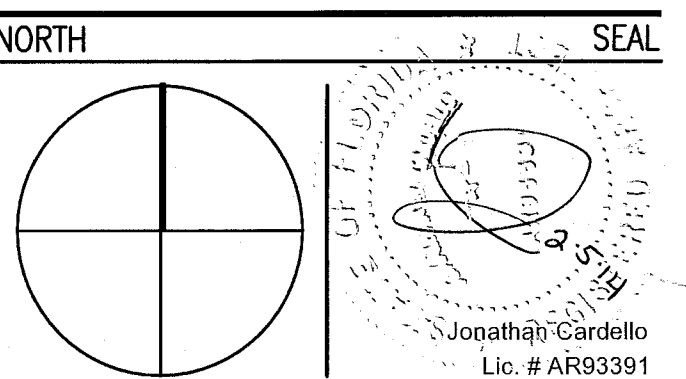

ADD Inc Architecture Interiors Planning

One Biscayne Tower
Suite 1670
Two South
Biscayne Boulevard
Miami, FL 33131
T. 305.482.8700
F. 305.482.8770
www.addinc.com
Lic. # AA26001507

JOB NUMBER: 13036.00

CHECKED BY:

ISSUE DATE: JANUARY 24, 2014

SCALE: 3/32" = 1'-0"


SHEET TITLE

ROOF LEVEL
POWER & SIGNAL
PLAN

SHEET NUMBER

A704

COPYRIGHT ADD INC 2011

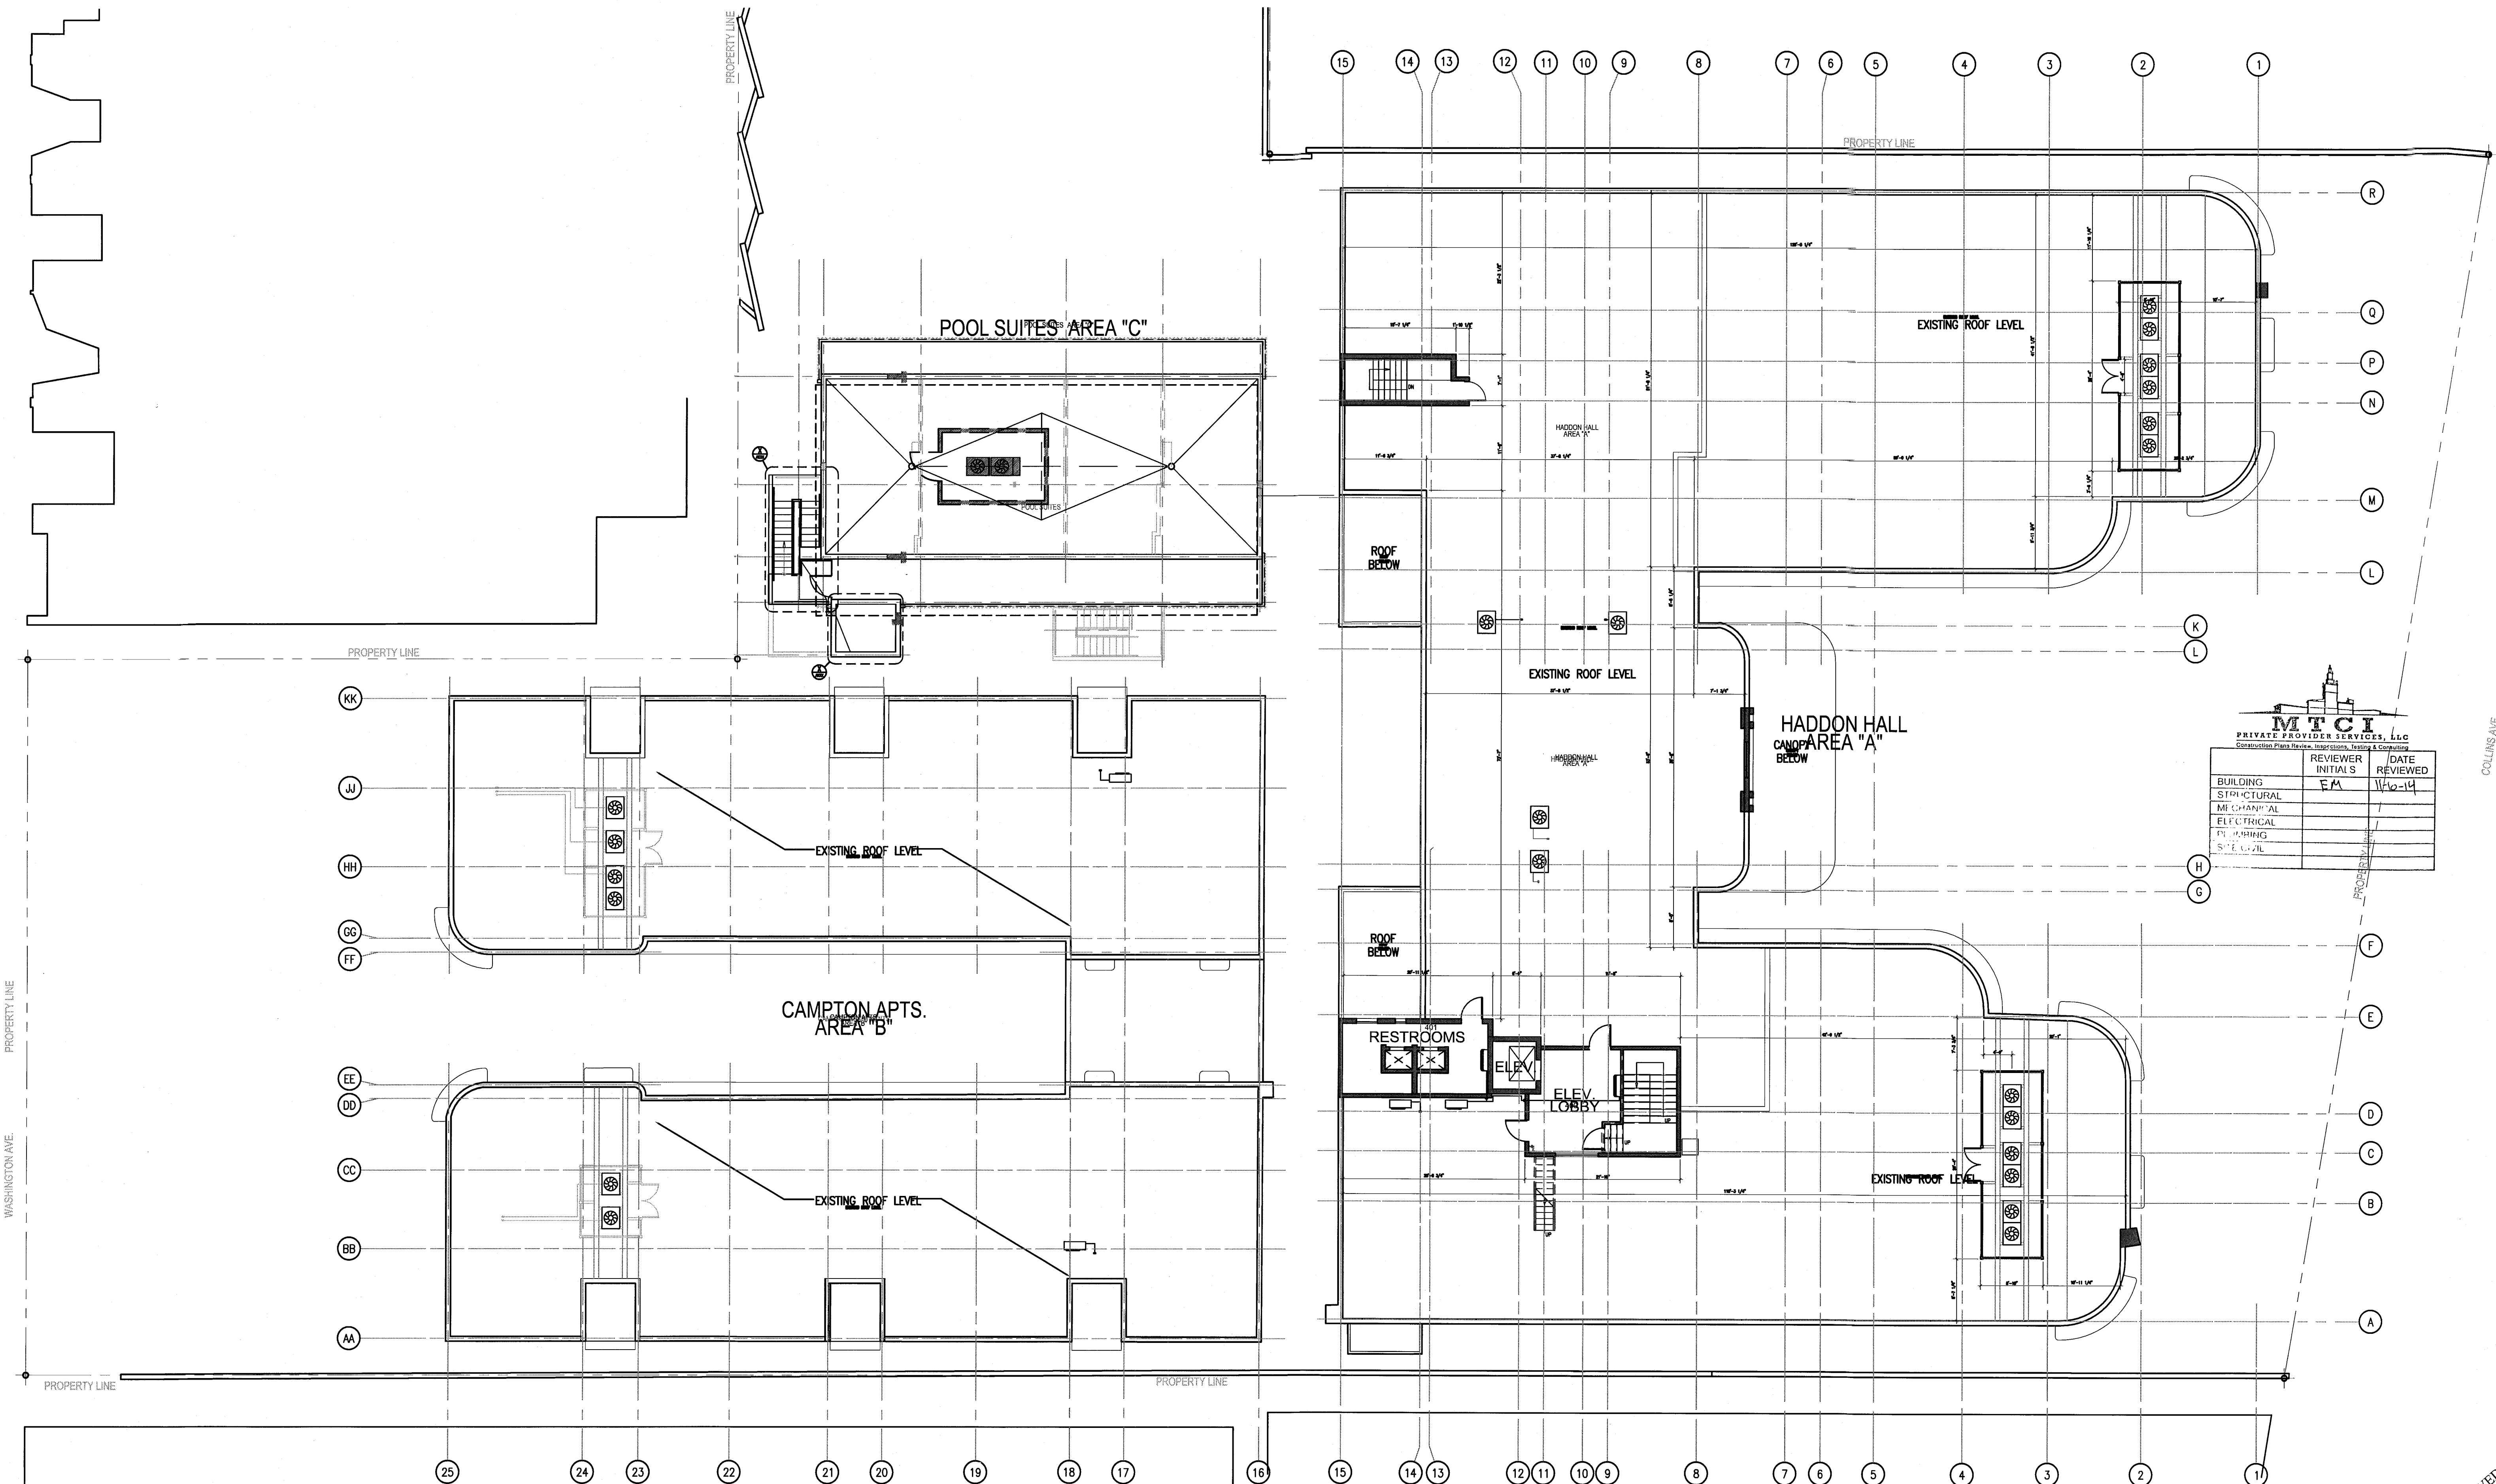

1 ROOF LEVEL POWER AND SIGNAL PLAN
SCALE: 3/32" = 1'-0"

APPROVED
MIAMI BEACH
FIRE DEPARTMENT